


CONSTRUCTION NOTES

1. CALL UTILITY LOCATE AT 811 72 HOURS PRIOR TO TRENCHING OR DIGGING.
2. THE EXISTENCE AND LOCATION OF ANY UNDER GROUND UTILITY PIPES OR DIGGING STRUCTURE SHOWN ON THESE PLANS WERE OBTAINED BY FIELD INSPECTION AND A SEARCH OF THE AVAILABLE CITY OR COUNTY RECORDS. SINCE THE ACTUAL LOCATION AND NATURE OF THE UNDER GROUND FACILITIES MAY BE SOME WHAT DIFFERENT FROM THE SHOWN. THE CONTRACTOR IS REQUIRED TO VERIFY PRIOR TO EXCAVATION.
3. FOR UNDERGROUND ACTIVITY: TEST AND VENTILATE MANHOLE/UTILITY VAULT PRIOR TO ENTRY. PLACE WARNING DEVICES AND WORK AREA PROTECTION AS REQUIRED, AND USE EYE AND HEAD SAFETY PROTECTION PER FEDERAL WAY, STATE, AND LOCAL REGULATIONS.
4. ALL EXCAVATION, TRENCHING, AND SHORING IS TO ADHERE TO THE CODE OF REGULATIONS (CFR) 1926.650 SUBPART P.
 - a. PROVIDED ALL PITS WITH 1'X 1' SLOPE ART ONE END OF EXCAVATION FOR TECHNICIAN INGRESS/EGRESS.
 - b. EXCAVATED SPOILS ARE TO BE NO LESS THAN 24" FROM EDGE OF PIT OR TRENCH.
 - c. BARRICADE ALL OPEN PITS AND TRENCHING FOR PUBLIC SAFETY. ALL BARRICADE MUST BE EQUIPPED WITH FLASHING LIGHTS FOR NIGHT VISIBILITY.
 - d. FOR PITS GREATER THAN 4' IN DEPTH, USE APPROPRIATE SHORING FOR WALL STABILITY
5. TRENCH COVER IS TO BE 9" MINIMUM AND FREE OF ROCKS, DEBRIS, AND CLODS. THE TRENCH IS TO BE A MINIMUM OF 9" COVER IN DEVELOPED AREAS AND A MINIMUM OF 48" OF COVER IN UNDEVELOPED AREAS (ANY VARIANCE FROM THESE STANDARDS WILL BE SPECIFIED ON THE PLANS)
6. ALL ASPHALT/CONCRETE AND LANDSCAPING REMOVED, DISTURBED, OR DAMAGES AS A RESULT OF CONSTRUCTION SHALL BE RESTORED TO ORIGINAL CONDITION OR BETTER.
7. NORMAL / GUIDED-BORING METHOD RECOMMENDED WHEN BORING.
8. ADHERE TO AIRTIGHT GUIDELINES UNLESS OTHERWISE NOTED.
9. BOND BURIED/AERIAL FACILITIES AS A REQUIRED BY JURISDICTIONAL AGENCY(S).
10. AERIAL FACILITIES ARE TO BE TESTED PRIOR TO BEGINING WORK PER STATE AND LOCAL REGULATIONS.
11. ALL WORK AREA PROTECTION FOR TRAFFIC CONTROL IS TO BE WITH APPROVED WARNING DEVICES AND PLACED PER STATE DEPARTMENT OF TRANSPORTATION AND/OR PUBLIC WORKS ENGINEERING. DEPARTMENT STANDARDS AND SPECIFICATIONS. IF REQUIRED, A TRAFFIC CONTROL PLAN SHALL BE SUBMITTED TO THE REQUESTING PERMITTING AGENCY. PRIOR TO BEGINNING WORK, PERMITTING AGENCIES MUST BE NOTIFIED 48 HOURS IN ADVANCE OF CONSTRUCTION ACTIVITIES.
12. EXISTING PEDESTRIAN CROSSWALKS AND WALKING AREAS SHALL BE MAINTAINED AT ALL TIMES. AS NECESSARY, TEMPORARY PEDESTRIAN CROSSWALKS AND WALKING AREAS SHALL BE PROVIDED AND MAINTAINED PER STATE DEPARTMENT OF TRANSPORTATION AND/OR PUBLIC WORKS ENGINEERING DEPARTMENT STANDARDS AND SPECIFICATIONS.
13. THE FOLLOWING FOOTAGES ARE ESTIMATES. FOOTAGES TO BE VERIFIED PRIOR TO CONSTRUCTIONS.

VICINITY MAP

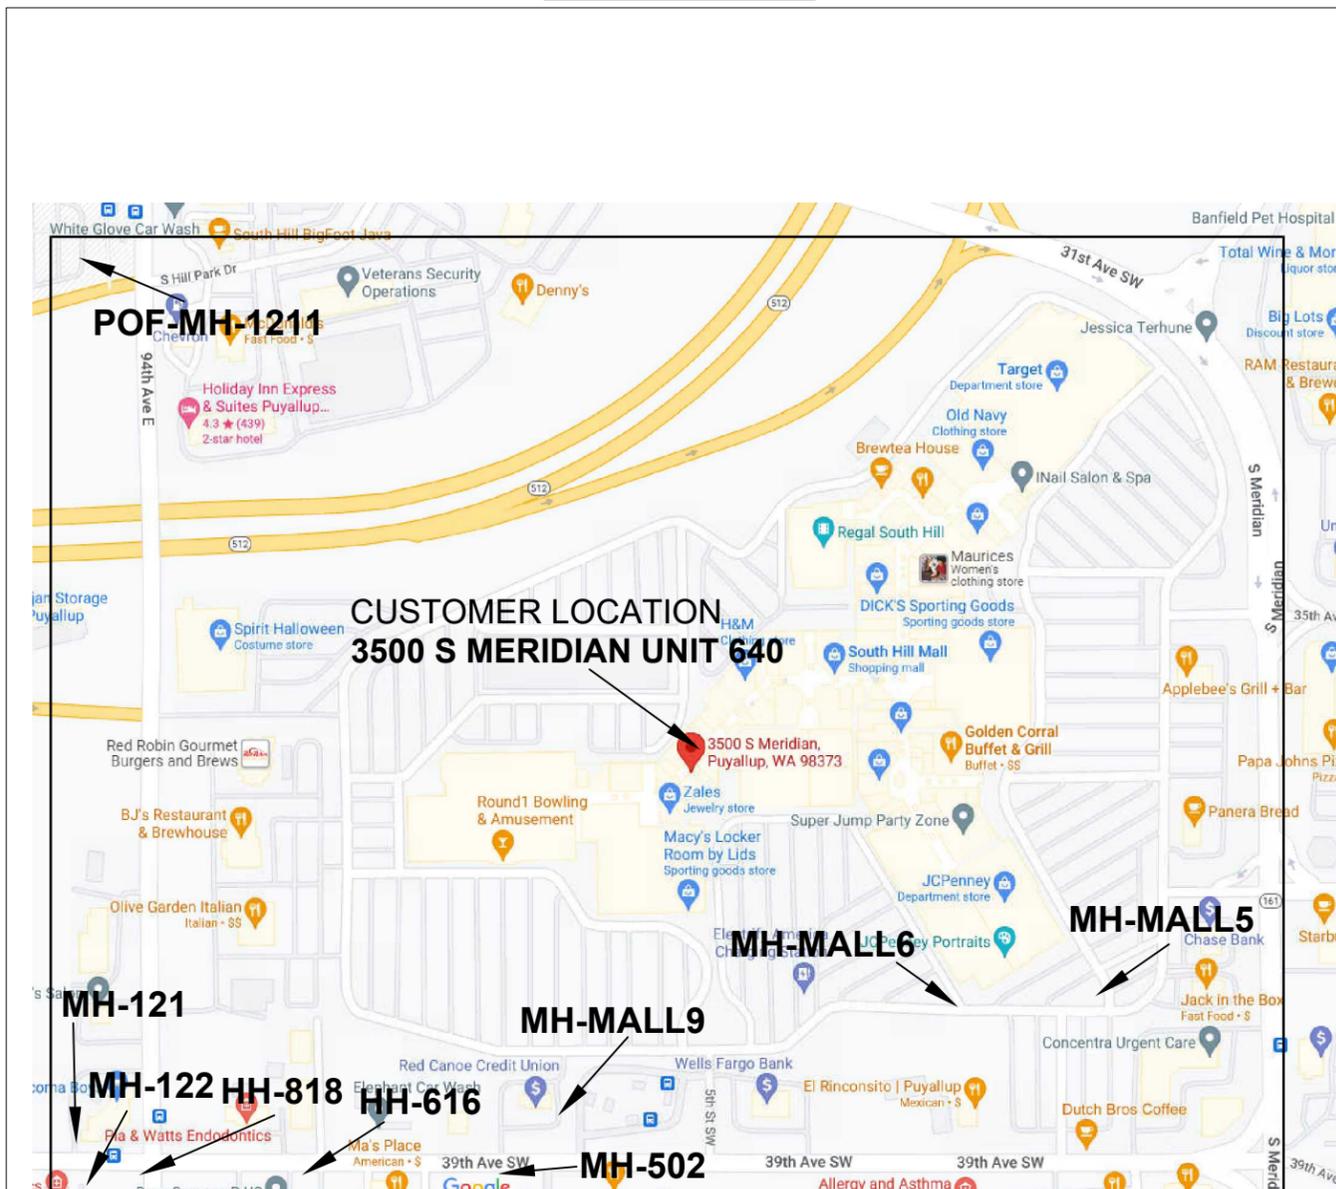

PERMITS

	YES	NO
DESIGNED SERVICES:	<input type="checkbox"/>	<input type="checkbox"/>
HELD ORDERS:	<input type="checkbox"/>	<input type="checkbox"/>
ROW REQUIRED:	<input type="checkbox"/>	<input type="checkbox"/>
CIY:	<input type="checkbox"/>	<input type="checkbox"/>
COUNTY:	<input type="checkbox"/>	<input type="checkbox"/>
STATE:	<input type="checkbox"/>	<input type="checkbox"/>
RAIL ROAD:	<input type="checkbox"/>	<input type="checkbox"/>
LOOP QUAL:	<input type="checkbox"/>	<input type="checkbox"/>
PREMIS FORM:	<input type="checkbox"/>	<input type="checkbox"/>

ADDITIONAL PERMIT INFO:

CONFORMANCE TEST:
SEE NDS

LCON NAME: ANNE MARTIN
LCON NUMBER: 402-779-7412
FIBER ENGINEER: JEREMIAH SCHERER
FIBER ENGINEER CONTACT: 702-395-2776
FIELD ENGINEER:
FIELD ENGINEER CONTACT:
CUSTOMER NAME: THE BUCKLE INC
ADDRESS: 3500 S MERIDIAN, UNIT 640
PUYALLUP, WA 98373

TOTAL PLUF FIBER PLACEMENT: 2240'
TOTAL PLAF FIBER PLACEMENT: 450'
TOTAL PLAC FIBER PLACEMENT: 0'
TOTAL INBF FIBER PLACEMENT: 50'
TOTAL BORE: 0'
TOTAL TRENCH: 0'

NARRATIVE: THIS PROJECT WILL PROVIDE CDFS SERVICE TO 3500 S MERIDIAN UNIT 640. EXISTING 720 FIBER CABLE FROM POF_MH-1211 TO MH-121, MH-122 IN EXISTING CONDUIT. PLACE NEW 48 FIBER CABLE FROM MH-122 TO HH-818 IN EXISTING CONDUIT. EXISTING 48 FIBER CABLE FROM HH-818 TO HH-616 IN EXISTING CONDUIT. PLACE NEW 24 FIBER CABLE FROM HH-616 TO MH-502 PASSING THROUGH POLES IN PROPOSED AERIAL ROUTE AND EXISTING CONDUIT. EXISTING 24 FIBER CABLE FROM MH-502 TO MH-MALL5 PASSING THROUGH MH-MALL9, MH-MALL6 IN EXISTING CONDUIT. PLACE NEW 24 FIBER CABLE FROM MH-MALL6 TO CUSTOMER MPOP PASSING THROUGH MH-MALL5 IN EXISTING CONDUIT.

	CUSTOMER INFORMATION	ENGINEERING CONTACT	CONTRACT ENGINEER		EXCEPT AS MAY BE OTHERWISE PROVIDED BY CONTRACT, THESE DRAWINGS AND SPECIFICATIONS SHALL REMAIN THE PROPERTY OF CENTURY LINK BEING ISSUED IN STRICT CONFIDENCE	
	NAME: THE BUCKLE INC ADDRESS: 3500 S MERIDIAN, UNIT 640 CITY, STATE: PUYALLUP WA ZIP CODE: 98373 CLLI: PYLPWA01	NAME: JEREMIAH SCHERER PHONE: 702-395-2776 	NAME: LAKEN HUNTER PHONE: 662-871-6309 CYIENT INC			
				SECTION: 4 TOWNSHIP: 19N RANGE: 4E	SCALE: 1"=100'	REVISION: 2 JOB: P.058208 DATE: 10/29/2023 SH: 01 OF 10

LEGEND SHEET


SYMBOLOLOGY




BACK OF CURB	
EDGE OF PAVEMENT	
CENTERLINES	
MONUMENT LINE	
DRIVEWAY	
SIDEWALK	
PROPERTY LINE	
RIGHT OF WAY	
PUE	
NON-VEHICLE-ACCESS EASEMENT	
MATCHLINE	
RAILROAD	
CATV LINE	
ELECTRIC	
OVERHEAD ELECTRIC	
OVERHEAD T & E	
GAS	
IRRIGATION	
SEWER	
SITE TRIANGLE	
STORM DRAIN	
TELEPHONE	
JOINT TRENCH TELCO/ELEC	
AERIAL UTILITY (FIBER OPTIC)	
BURIED UTILITY (FIBER OPTIC)	
ABN TELCO	
WATER	
FENCE	
WALL	
CITY LIMITS	
COUNTY LINE	
TRAFFIC SIGNAL	
STREET LIGHT	
BORE	
ASPHALT CUT & RESTORE	
TRENCH	

	BRASS CAP		STORM DRAIN INTAKE
	CENTERLINE TICK		CULVERT
	MAILBOX		SEWER MANHOLE
	STREET SIGN		STORM DRAIN MANHOLE
	TREE		RWCD IRRIGATION PIPE
	BUSH		IRRIGATION MANHOLE
	CACTUS		IRRIGATION VALVE
	POWER POLE		CATV HANDHOLE
	TELEPHONE POLE		CATV VAULT
	CATV ANCHOR		CATV PEDESTAL
	POWER / TELEPHONE ANCHOR		GAS VALVE
	TRAFFIC LIGHT POLE		GAS VAULT
	TRAFFIC SIGNAL POST		GAS METER
	TRAFFIC SIGNAL J-BOX		TEL PEDESTAL EXISTING
	JOINT POLE		TEL PEDESTAL NEW
	STREET LIGHT		TEL MANHOLE EXISTING
	ELECTRIC SWITCHGEAR		TEL MANHOLE NEW
	JUNCTION BOX		TELCO HANDHOLE EXISTING
	ELECTRIC VAULT		TELCO HANDHOLE NEW
	GROUND TRANSFORMER		4'x4' BOREPIT
	AERIAL TRANSFORMER		SAI EXISTING
	ELECTRIC HANDHOLE		SAI NEW
	ELECTRIC MANHOLE		RT EXISTING
	POWER PED EXISTING		RT NEW
	POWER PED NEW		TELCO REPEATER NEW
	WATER METER		TELCO REPEATER EXISTING
	WATER VALVE		COOLPED NEW
	FIRE HYDRANT		COOLPED EXISTING

 TRENCH FOOTAGE
 ASPHALT CUT FOOTAGE
 BORE FOOTAGE
 SLACK LOOP FOOTAGE
ALL PROPOSED EQUIPMENT WILL BE BOLD



CUSTOMER INFORMATION NAME: THE BUCKLE INC ADDRESS: 3500 S MERIDIAN, UNIT 640 CITY, STATE: TACOMA, WA ZIP CODE: 98373 CLLI: PYLPWA01	ENGINEERING CONTACT NAME: JEREMIAH SCHERER PHONE: 702-395-2776 	CONTRACT ENGINEER NAME: LAKEN HUNTER PHONE: 662-871-6309 CYIENT INC	CALL TWO WORKING DAYS BEFORE YOU DIG 		EXCEPT AS MAY BE OTHERWISE PROVIDED BY CONTRACT, THESE DRAWINGS AND SPECIFICATIONS SHALL REMAIN THE PROPERTY OF CENTURY LINK BEING ISSUED IN STRICT CONFIDENCE	
				SECTION: 4	SCALE: 1"=100'	REVISION: 2
				TOWNSHIP: 19N	RANGE: 4E	JOB: P.058208 DATE: 10/29/2023 SH: 02 OF 10

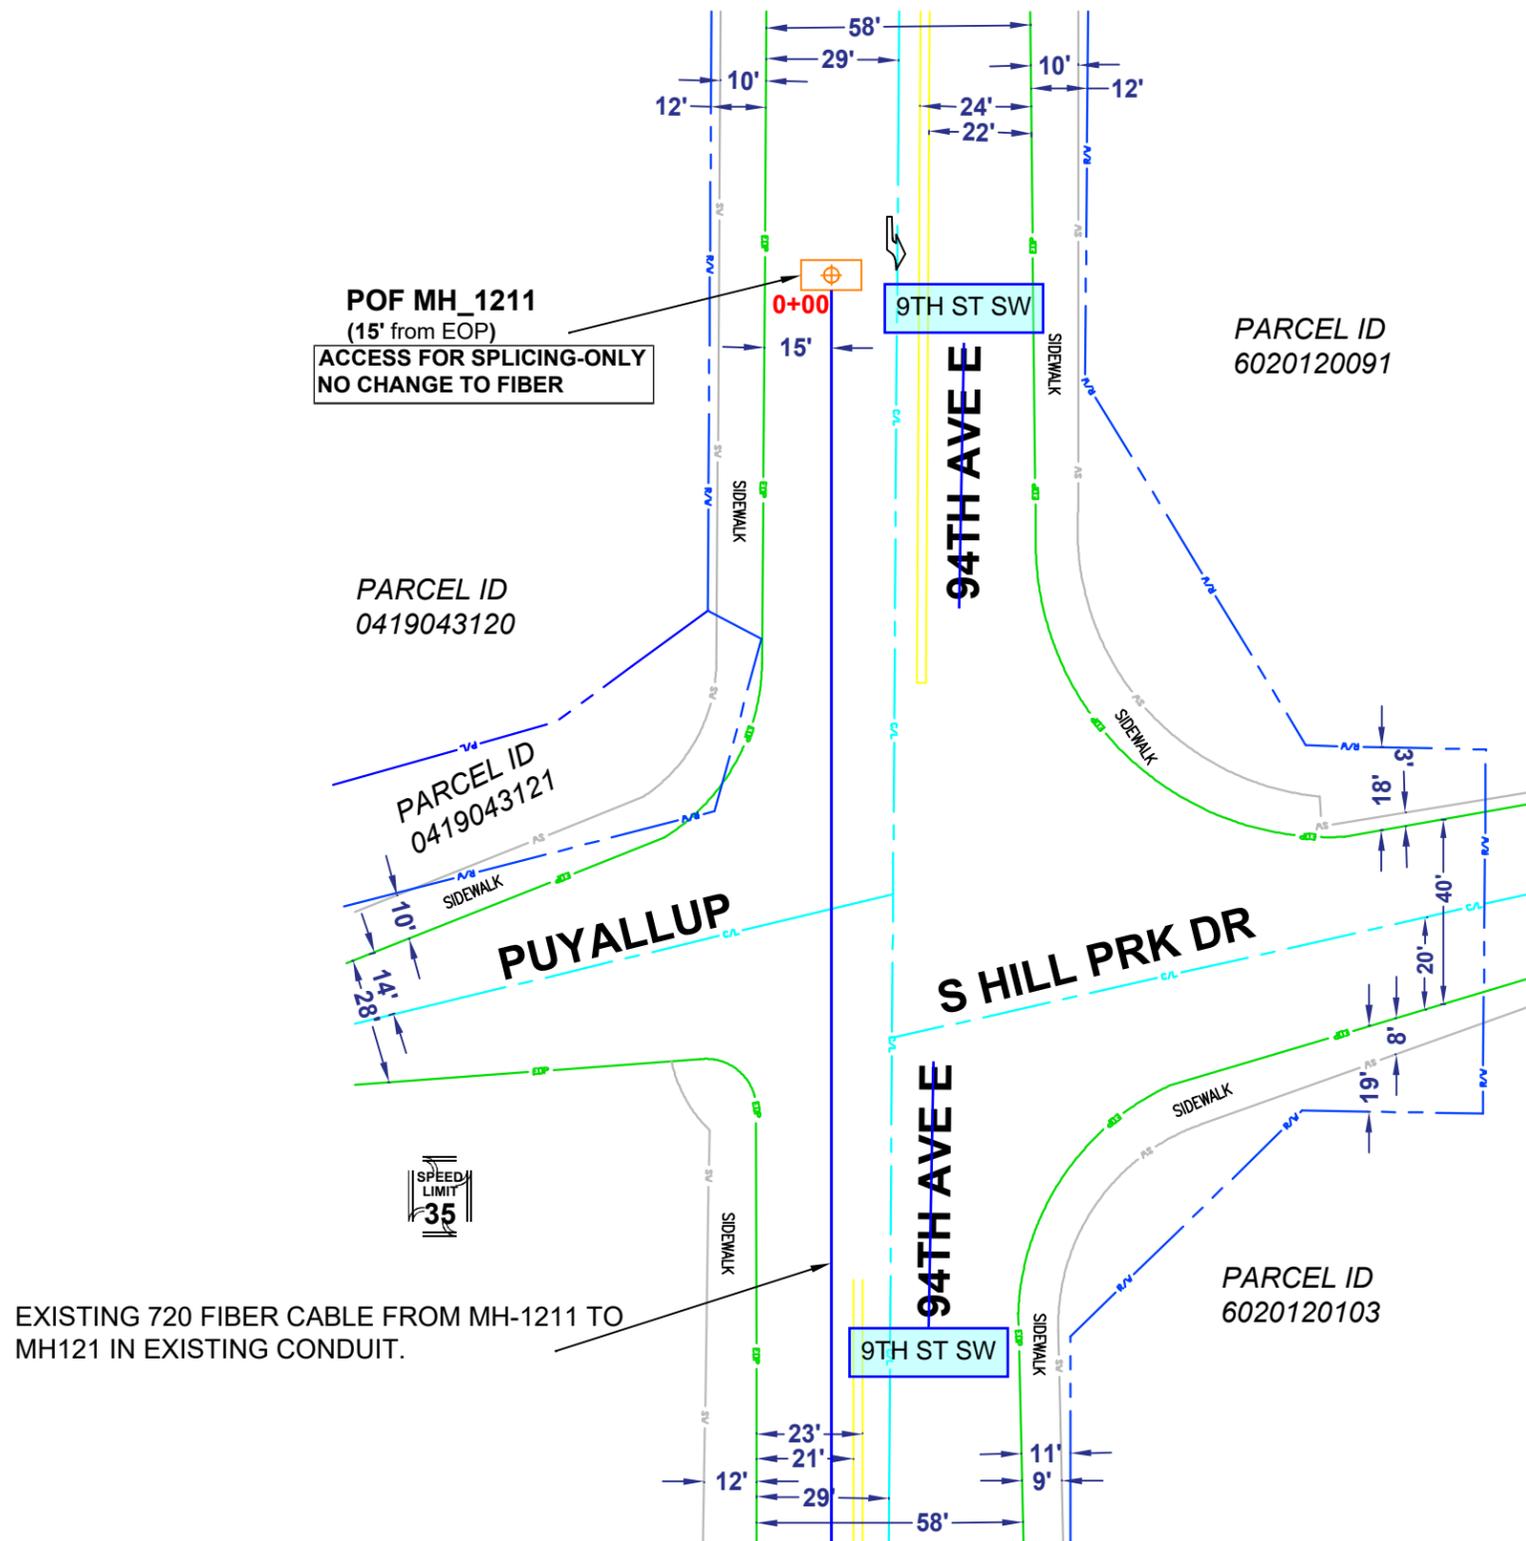

EXISTING 720 FIBER CABLE FROM MH-1211 TO MH121 IN EXISTING CONDUIT.

	CUSTOMER INFORMATION	ENGINEERING CONTACT	CONTRACT ENGINEER		EXCEPT AS MAY BE OTHERWISE PROVIDED BY CONTRACT, THESE DRAWINGS AND SPECIFICATIONS SHALL REMAIN THE PROPERTY OF CENTURY LINK BEING ISSUED IN STRICT CONFIDENCE		
	NAME: THE BUCKLE INC ADDRESS: 3500 S MERIDIAN, UNIT 640 CITY, STATE: PUYALLUP, WA ZIP CODE: 98373 CLLI: PYLPWA01	NAME: JEREMIAH SCHERER PHONE: 702-395-2776 	NAME: LAKEN HUNTER PHONE: 662-871-6309 CYIENT INC				CALL TWO WORKING DAYS BEFORE YOU DIG
	SECTION: 4		SCALE: 1"=100'				REVISION: 2
	TOWNSHIP: 19N		JOB: P.058208				DATE: 10/29/2023
RANGE: 4E		SH: 03 OF 10					

EXISTING 720 FIBER CABLE FROM MH-1211 TO MH121 IN EXISTING CONDUIT.

MH_121
(9' from EOP)
ACCESS FOR SPLICING-ONLY
NO CHANGE TO FIBER

PARCEL ID
0419047029

SPEED
LIMIT
35

PARCEL ID
0419044103

PARCEL ID
0419044102

PARCEL ID
0419044132

EXISTING 720 FIBER CABLE FROM MH-121 TO MH122 IN EXISTING CONDUIT.

MH_122
(7' from EOP)
ACCESS FOR SPLICING-ONLY
NO CHANGE TO FIBER

PARCEL ID
7766500010

PARCEL ID
4320000010


PARCEL ID
4320000043

PARCEL ID
4320000042

PLACE NEW 48 FIBER CABLE FROM MH-122 TO HH-818 IN EXISTING CONDUIT.

HH-818
(5' from EOP)
ACCESS FOR SPLICING-ONLY
NO CHANGE TO FIBER

 CONTINUE NEW 48 FIBER CABLE FROM HH-818 TO HH-616 IN EXISTING CONDUIT.



CUSTOMER INFORMATION
NAME: THE BUCKLE INC
ADDRESS: 3500 S MERIDIAN, UNIT 640
CITY, STATE: PUYALLUP, WA
ZIP CODE: 98373
CLLI: PYLPWA01


ENGINEERING CONTACT
NAME: JEREMIAH SCHERER
PHONE: 702-395-2776
 **CenturyLink**

CONTRACT ENGINEER
NAME: LAKEN HUNTER
PHONE: 662-871-6309
CYIENT INC




 **CenturyLink**
SECTION: 4
TOWNSHIP: 19N
RANGE: 4E

EXCEPT AS MAY BE OTHERWISE PROVIDED BY CONTRACT, THESE DRAWINGS AND SPECIFICATIONS SHALL REMAIN THE PROPERTY OF CENTURY LINK BEING ISSUED IN STRICT CONFIDENCE
SCALE: 1"=100'
REVISION: 2
JOB: P.058208 DATE: 10/29/2023 SH: 04 OF 10

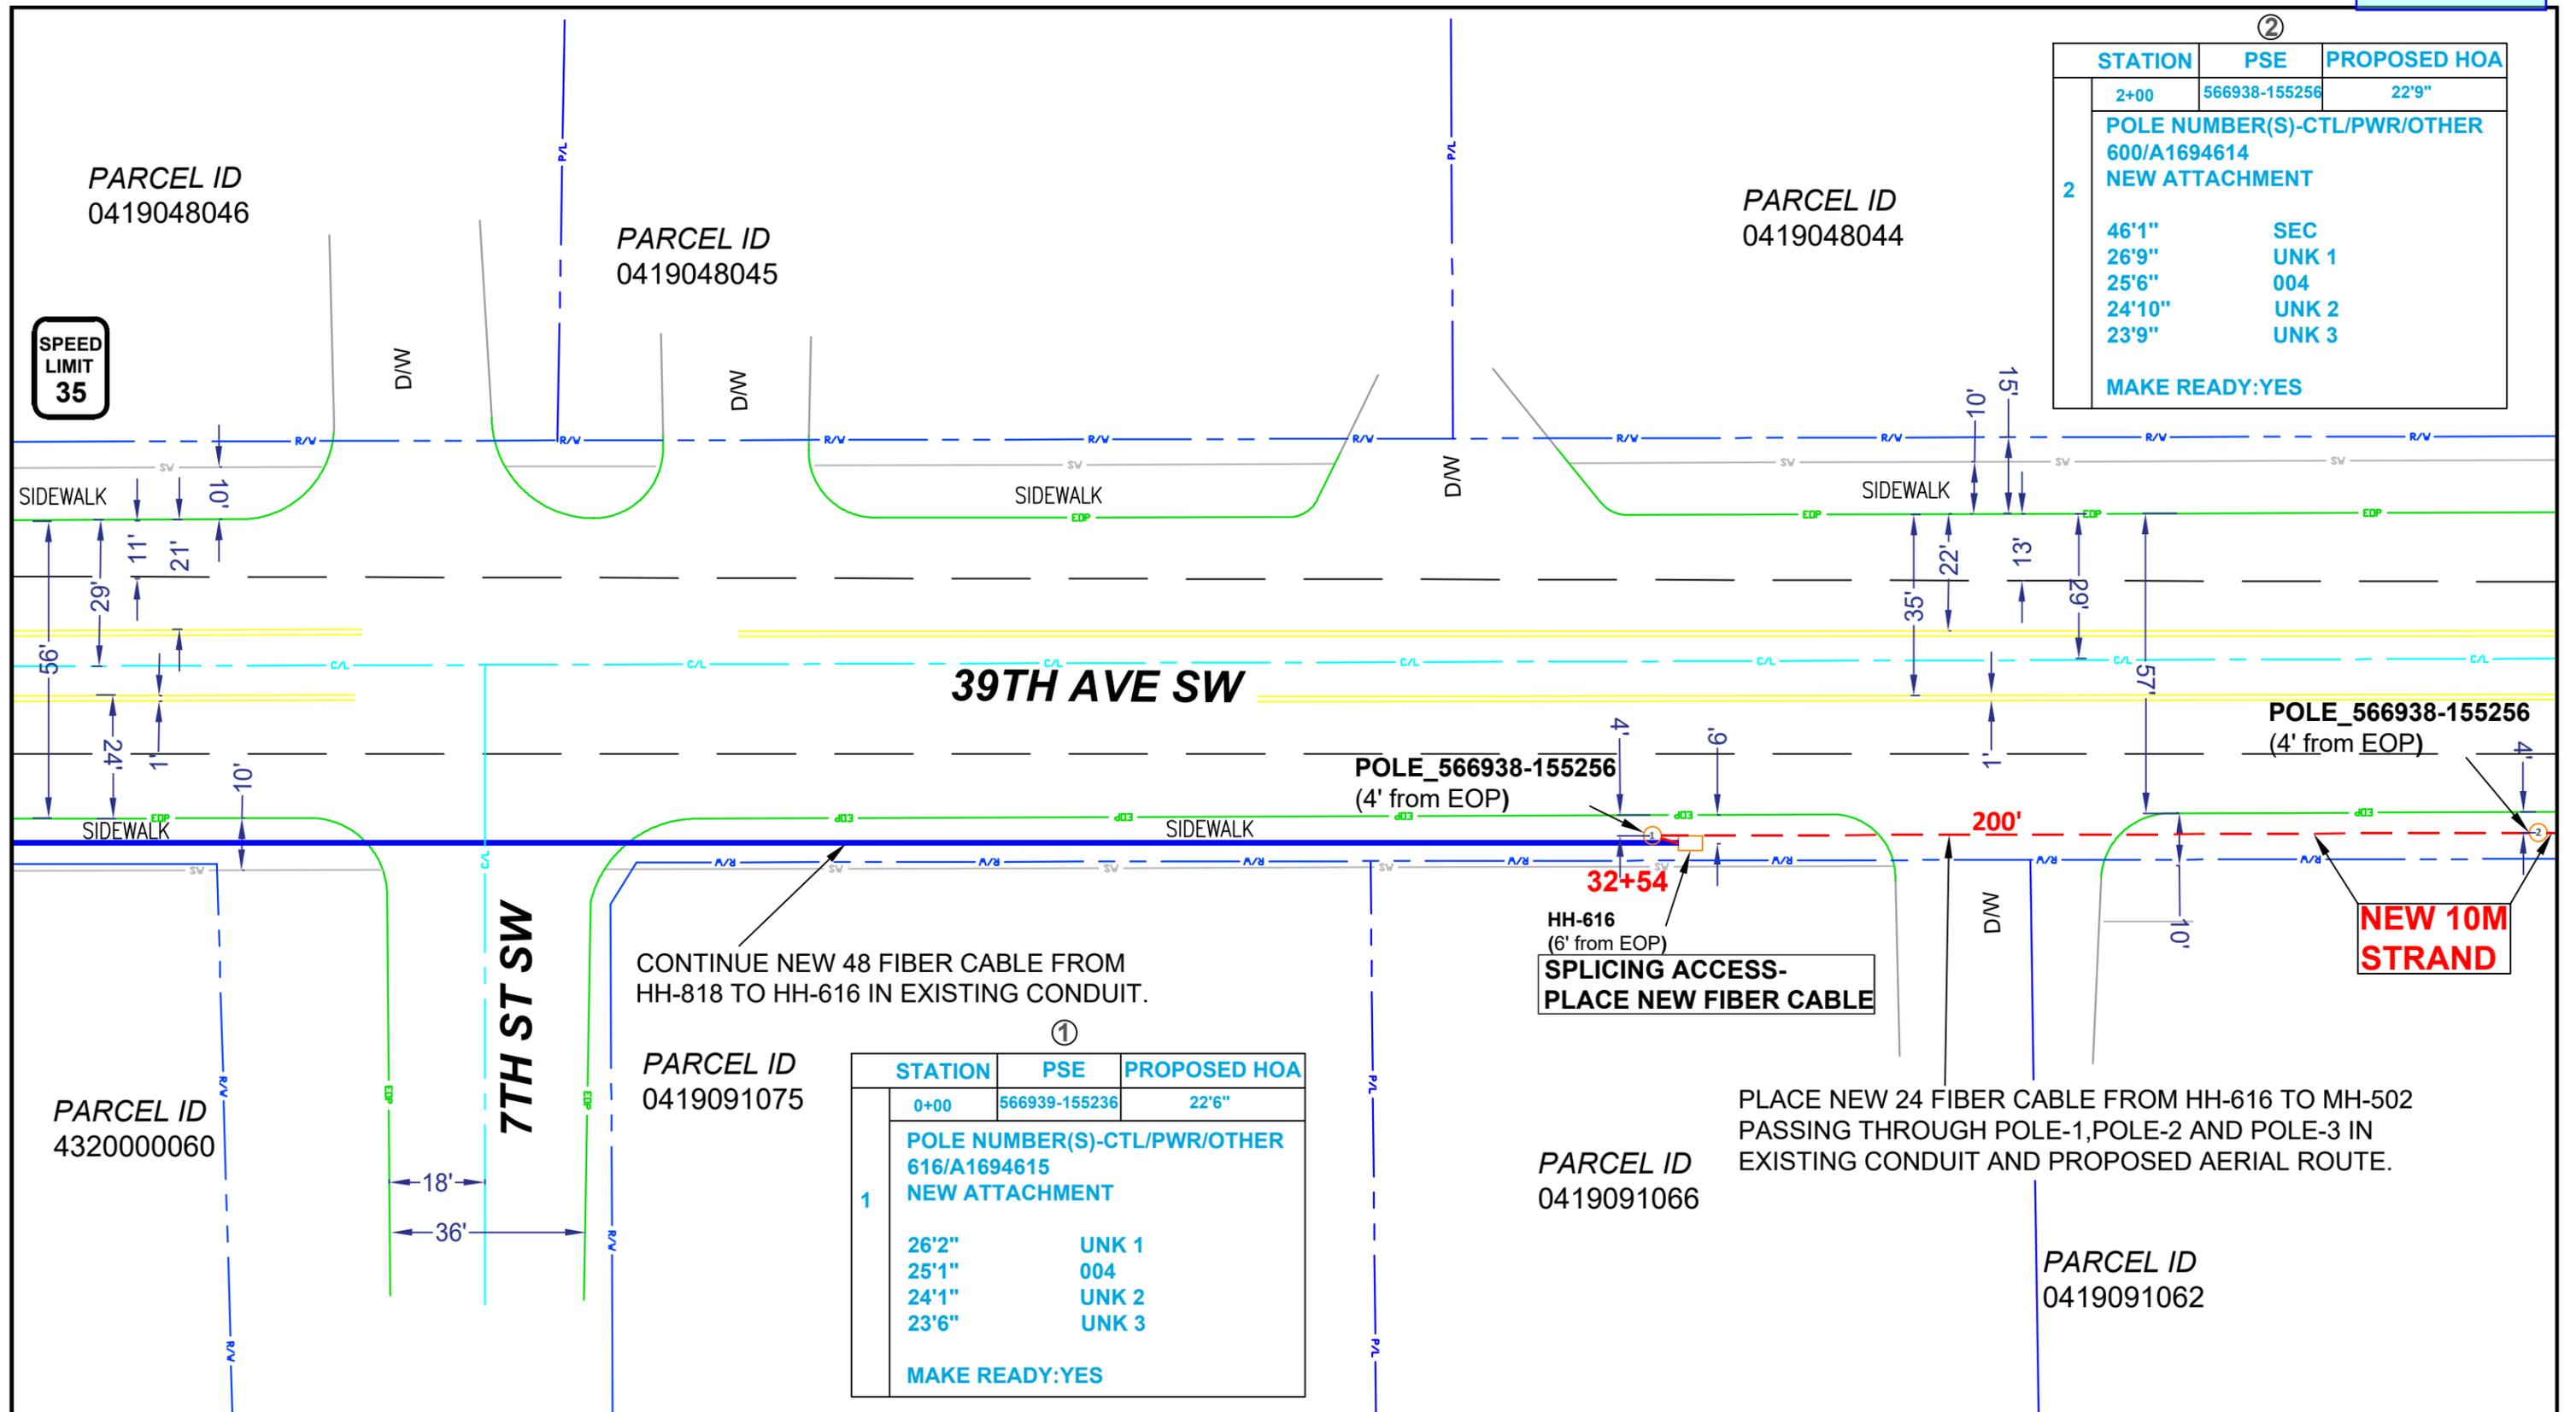

SPEED LIMIT 35

 

CUSTOMER INFORMATION
 NAME: THE BUCKLE INC
 ADDRESS: 3500 S MERIDIAN, UNIT 640
 CITY, STATE: PUYALLUP, WA
 ZIP CODE: 98373
 CLLI: PYLPWA01

ENGINEERING CONTACT
 NAME: JEREMIAH SCHERER
 PHONE: 702-395-2776

CONTRACT ENGINEER
 NAME: LAKEN HUNTER
 PHONE: 662-871-6309

CYIENT INC



SECTION: 4
 TOWNSHIP: 19N
 RANGE: 4E


EXCEPT AS MAY BE OTHERWISE PROVIDED BY CONTRACT, THESE DRAWINGS AND SPECIFICATIONS SHALL REMAIN THE PROPERTY OF CENTURY LINK BEING ISSUED IN STRICT CONFIDENCE

SCALE: 1"=100'
 REVISION: 2
 JOB: P.058208 DATE: 10/29/2023 SH: 05 OF 10

EXISTING 24 FIBER CABLE FROM MH-502 TO MH-MALL5 PASSING THROUGH MH-MALL9, MH-MALL6 IN EXISTING CONDUIT.

③			④			⑤		
STATION	PSE	PROPOSED HOA	STATION	PSE	PROPOSED HOA	STATION	PSE	PROPOSED HOA
4+37	566937-155279	26'8"	6+39	566937-155299	23'8"	8+44	566936-155321	23'8"
POLE NUMBER(S)-CTL/PWR/OTHER 502/A1694613 NEW ATTACHMENT			POLE NUMBER(S)-CTL/PWR/OTHER NA NEW ATTACHMENT			POLE NUMBER(S)-CTL/PWR/OTHER NA NEW ATTACHMENT		
30'4"	UNK 1		25'8"	UNK 1		41'2"	SEC	
29'6"	004		24'8"	004		25'11"	UNK 1	
27'8"	UNK 2					24'8"	004	
MAKE READY: YES			MAKE READY: NO			MAKE READY: YES		

Do not adjust property and right-of-way lines to accommodate utility design. The northern property line of tax parcel 0419095006 was depicted correctly on the last submittal and has since been incorrectly redrawn without the support of a survey. Please depict the right-of-way line in its true location or provide a survey to support the right-of-way line adjustment and anchor placement. [SITE PLAN, sheet 6 of 10]


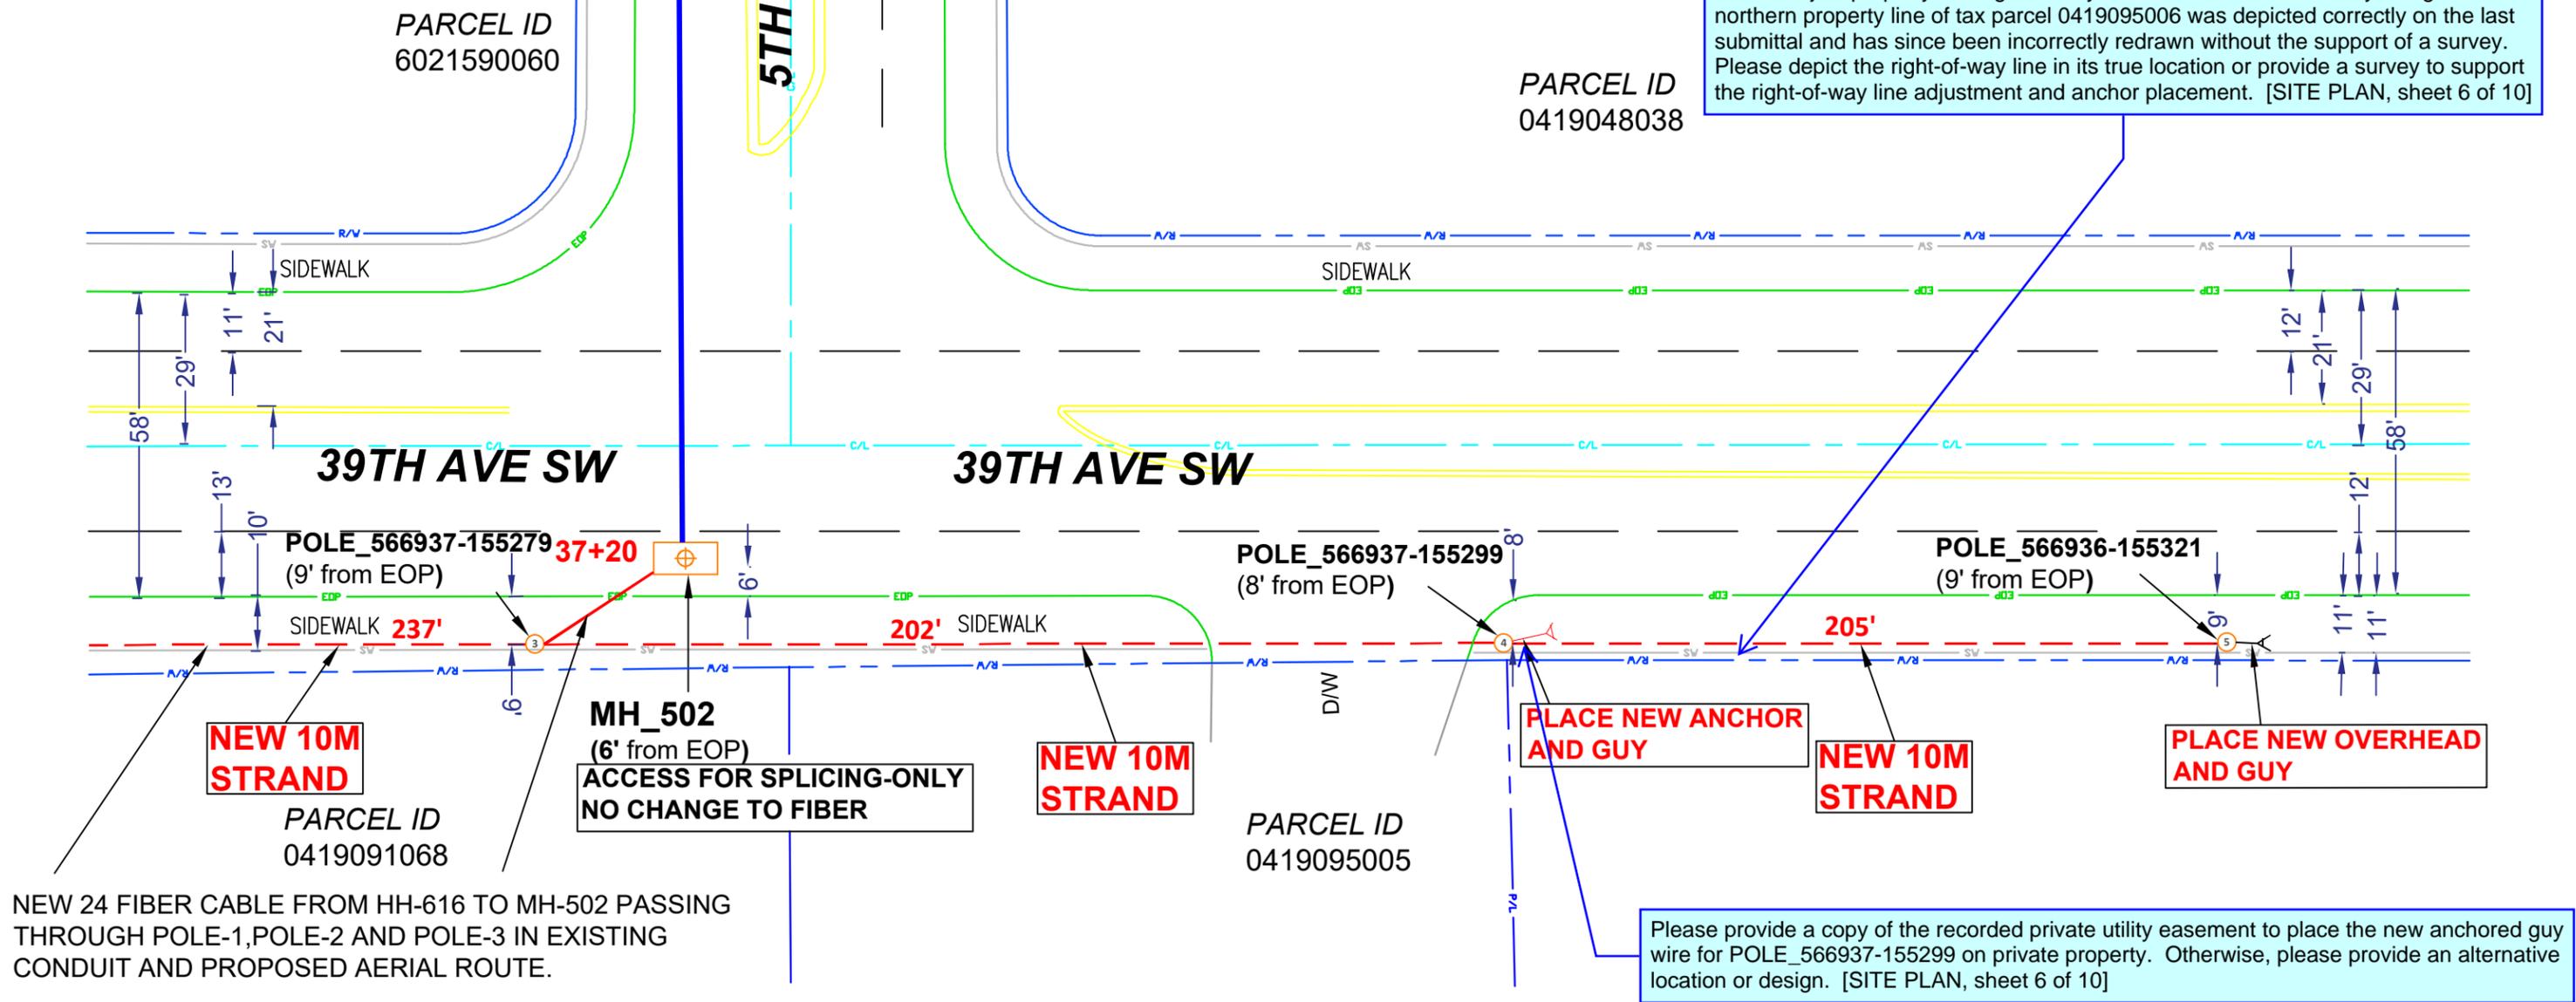


NEW 24 FIBER CABLE FROM HH-616 TO MH-502 PASSING THROUGH POLE-1, POLE-2 AND POLE-3 IN EXISTING CONDUIT AND PROPOSED AERIAL ROUTE.

Please provide a copy of the recorded private utility easement to place the new anchored guy wire for POLE_566937-155299 on private property. Otherwise, please provide an alternative location or design. [SITE PLAN, sheet 6 of 10]

	CUSTOMER INFORMATION	ENGINEERING CONTACT	CONTRACT ENGINEER		EXCEPT AS MAY BE OTHERWISE PROVIDED BY CONTRACT, THESE DRAWINGS AND SPECIFICATIONS SHALL REMAIN THE PROPERTY OF CENTURY LINK BEING ISSUED IN STRICT CONFIDENCE		
	NAME: THE BUCKLE INC	NAME: JEREMIAH SCHERER	NAME: LAKEN HUNTER		SECTION: 4	REVISION: 2	
	ADDRESS: 3500 S MERIDIAN, UNIT 640	PHONE: 702-395-2776	PHONE: 662-871-6309		TOWNSHIP: 19N	SCALE: 1"=100'	JOB: P.058208
	CITY, STATE: PUYALLUP, WA				RANGE: 4E	DATE: 10/29/2023	SH: 06 OF 10
ZIP CODE: 98373							
CLLI: PYLPWA01							



 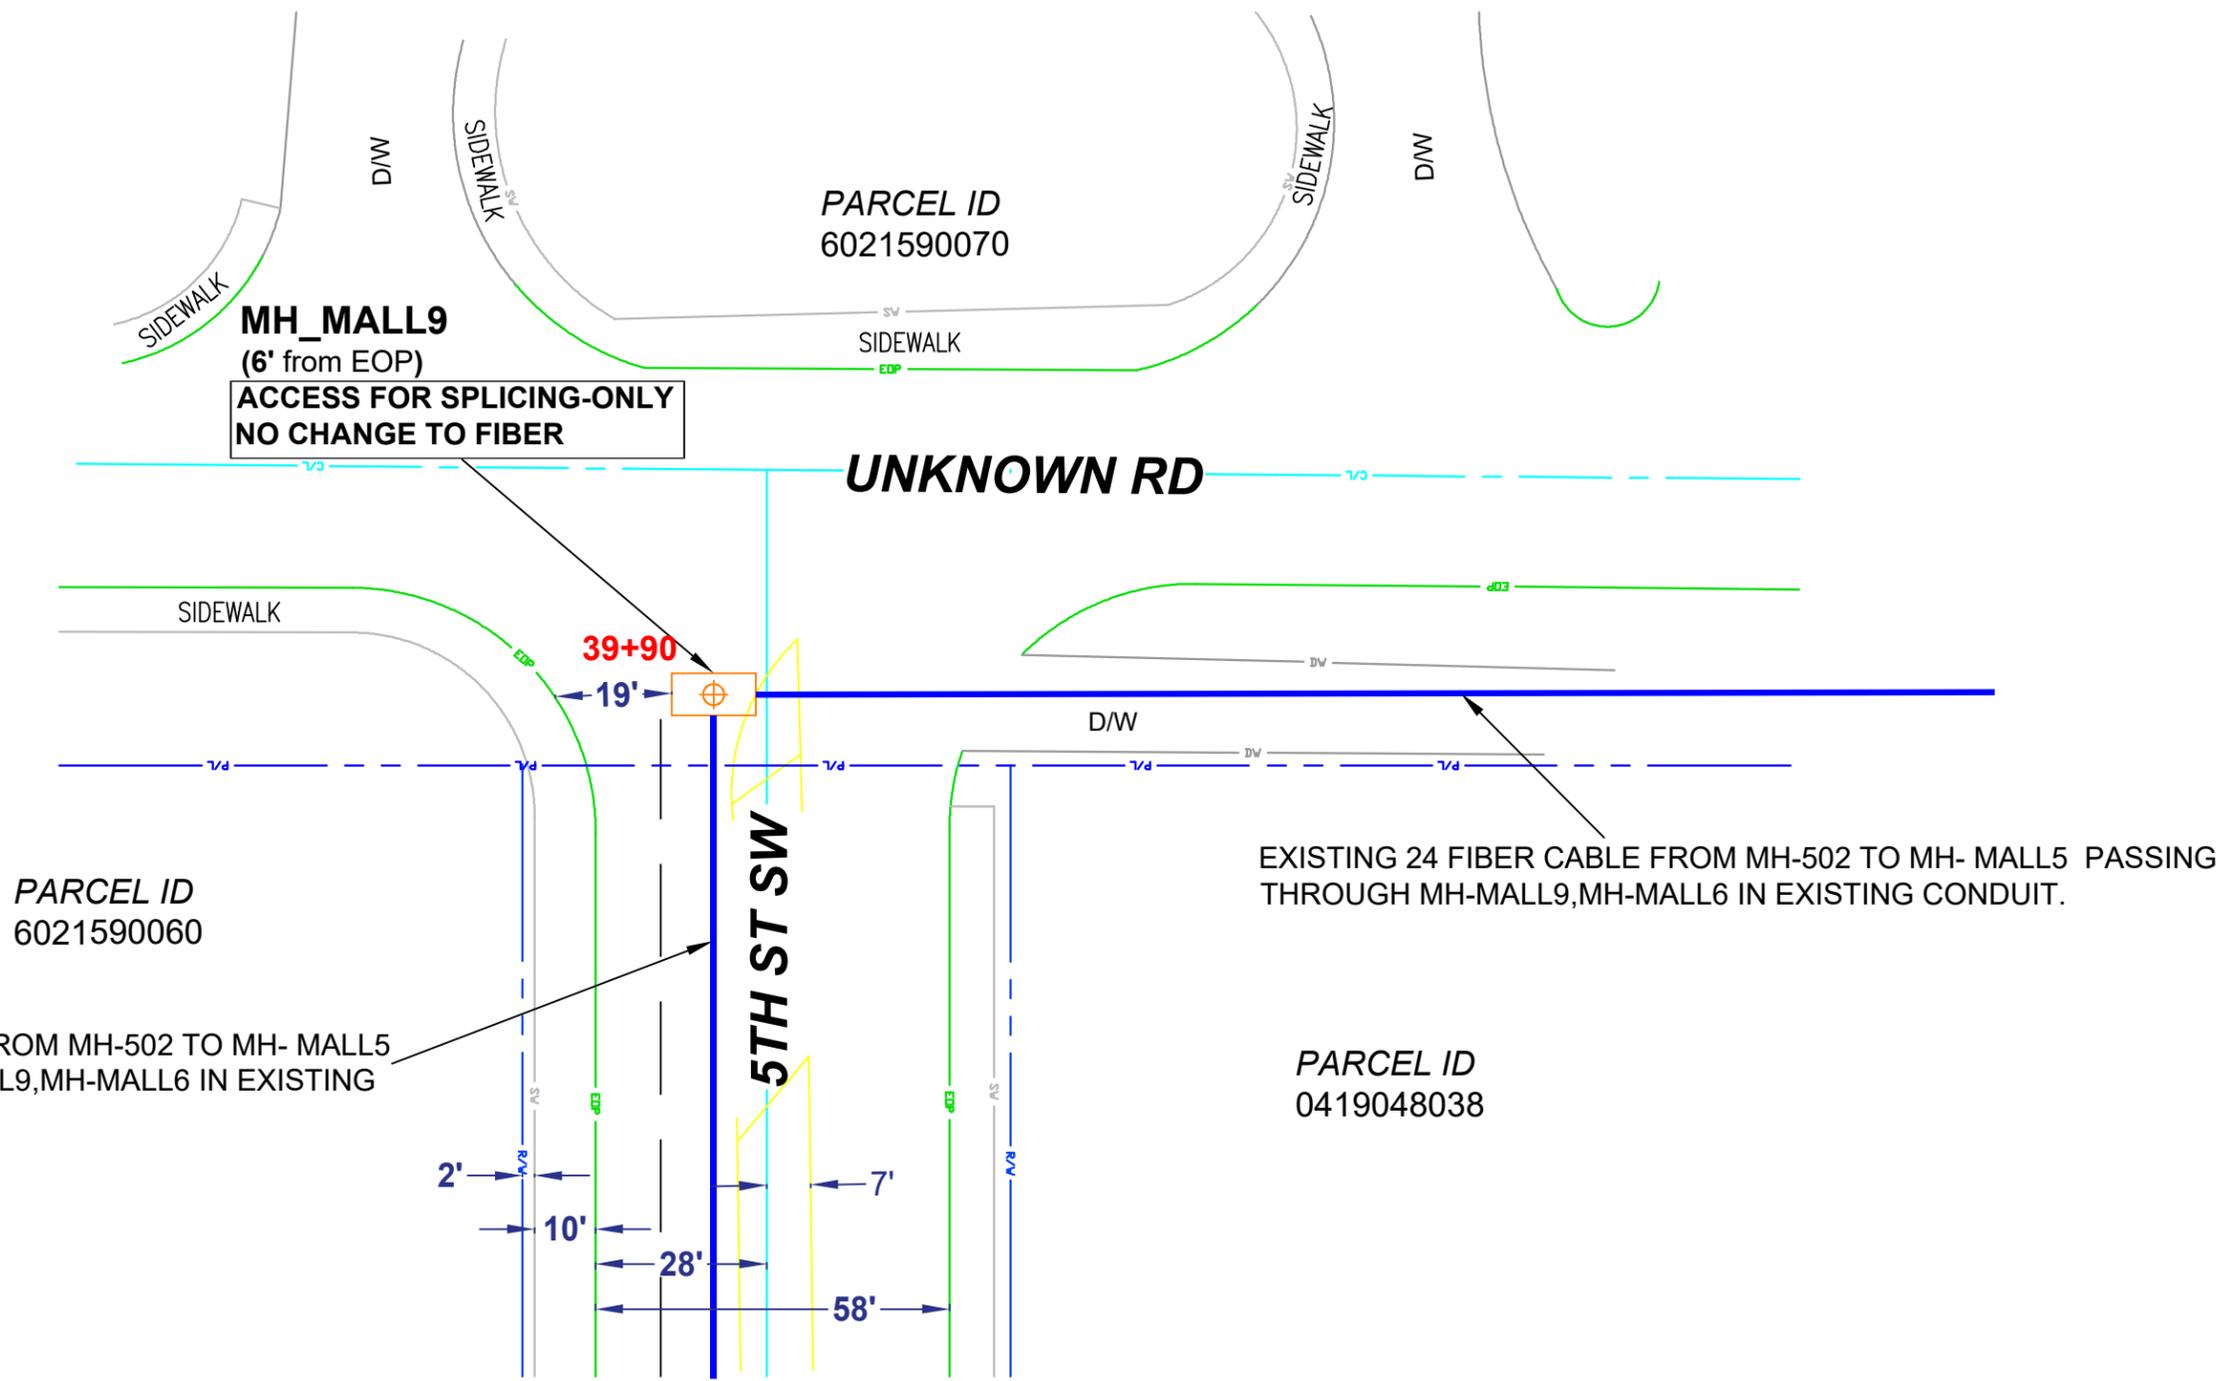

CUSTOMER INFORMATION
 NAME: THE BUCKLE INC
 ADDRESS: 3500 S MERIDIAN,UNIT 640
 CITY, STATE: PUYALLUP,WA
 ZIP CODE: 98373
 CLLI:PYLPWA01

ENGINEERING CONTACT
 NAME:JEREMIAH SCHERER
 PHONE: 702-395-2776



CONTRACT ENGINEER
 NAME: LAKEN HUNTER
 PHONE: 662-871-6309
CYIENT INC




 SECTION: 4
 TOWNSHIP: 19N
 RANGE: 4E


EXCEPT AS MAY BE OTHERWISE PROVIDED BY CONTRACT. THESE DRAWINGS AND SPECIFICATIONS SHALL REMAIN THE PROPERTY OF CENTURY LINK BEING ISSUED IN STRICT CONFIDENCE

SCALE: 1"=100' REVISION: 2
 JOB: P.058208 DATE: 10/29/2023 SH: 07 OF 10

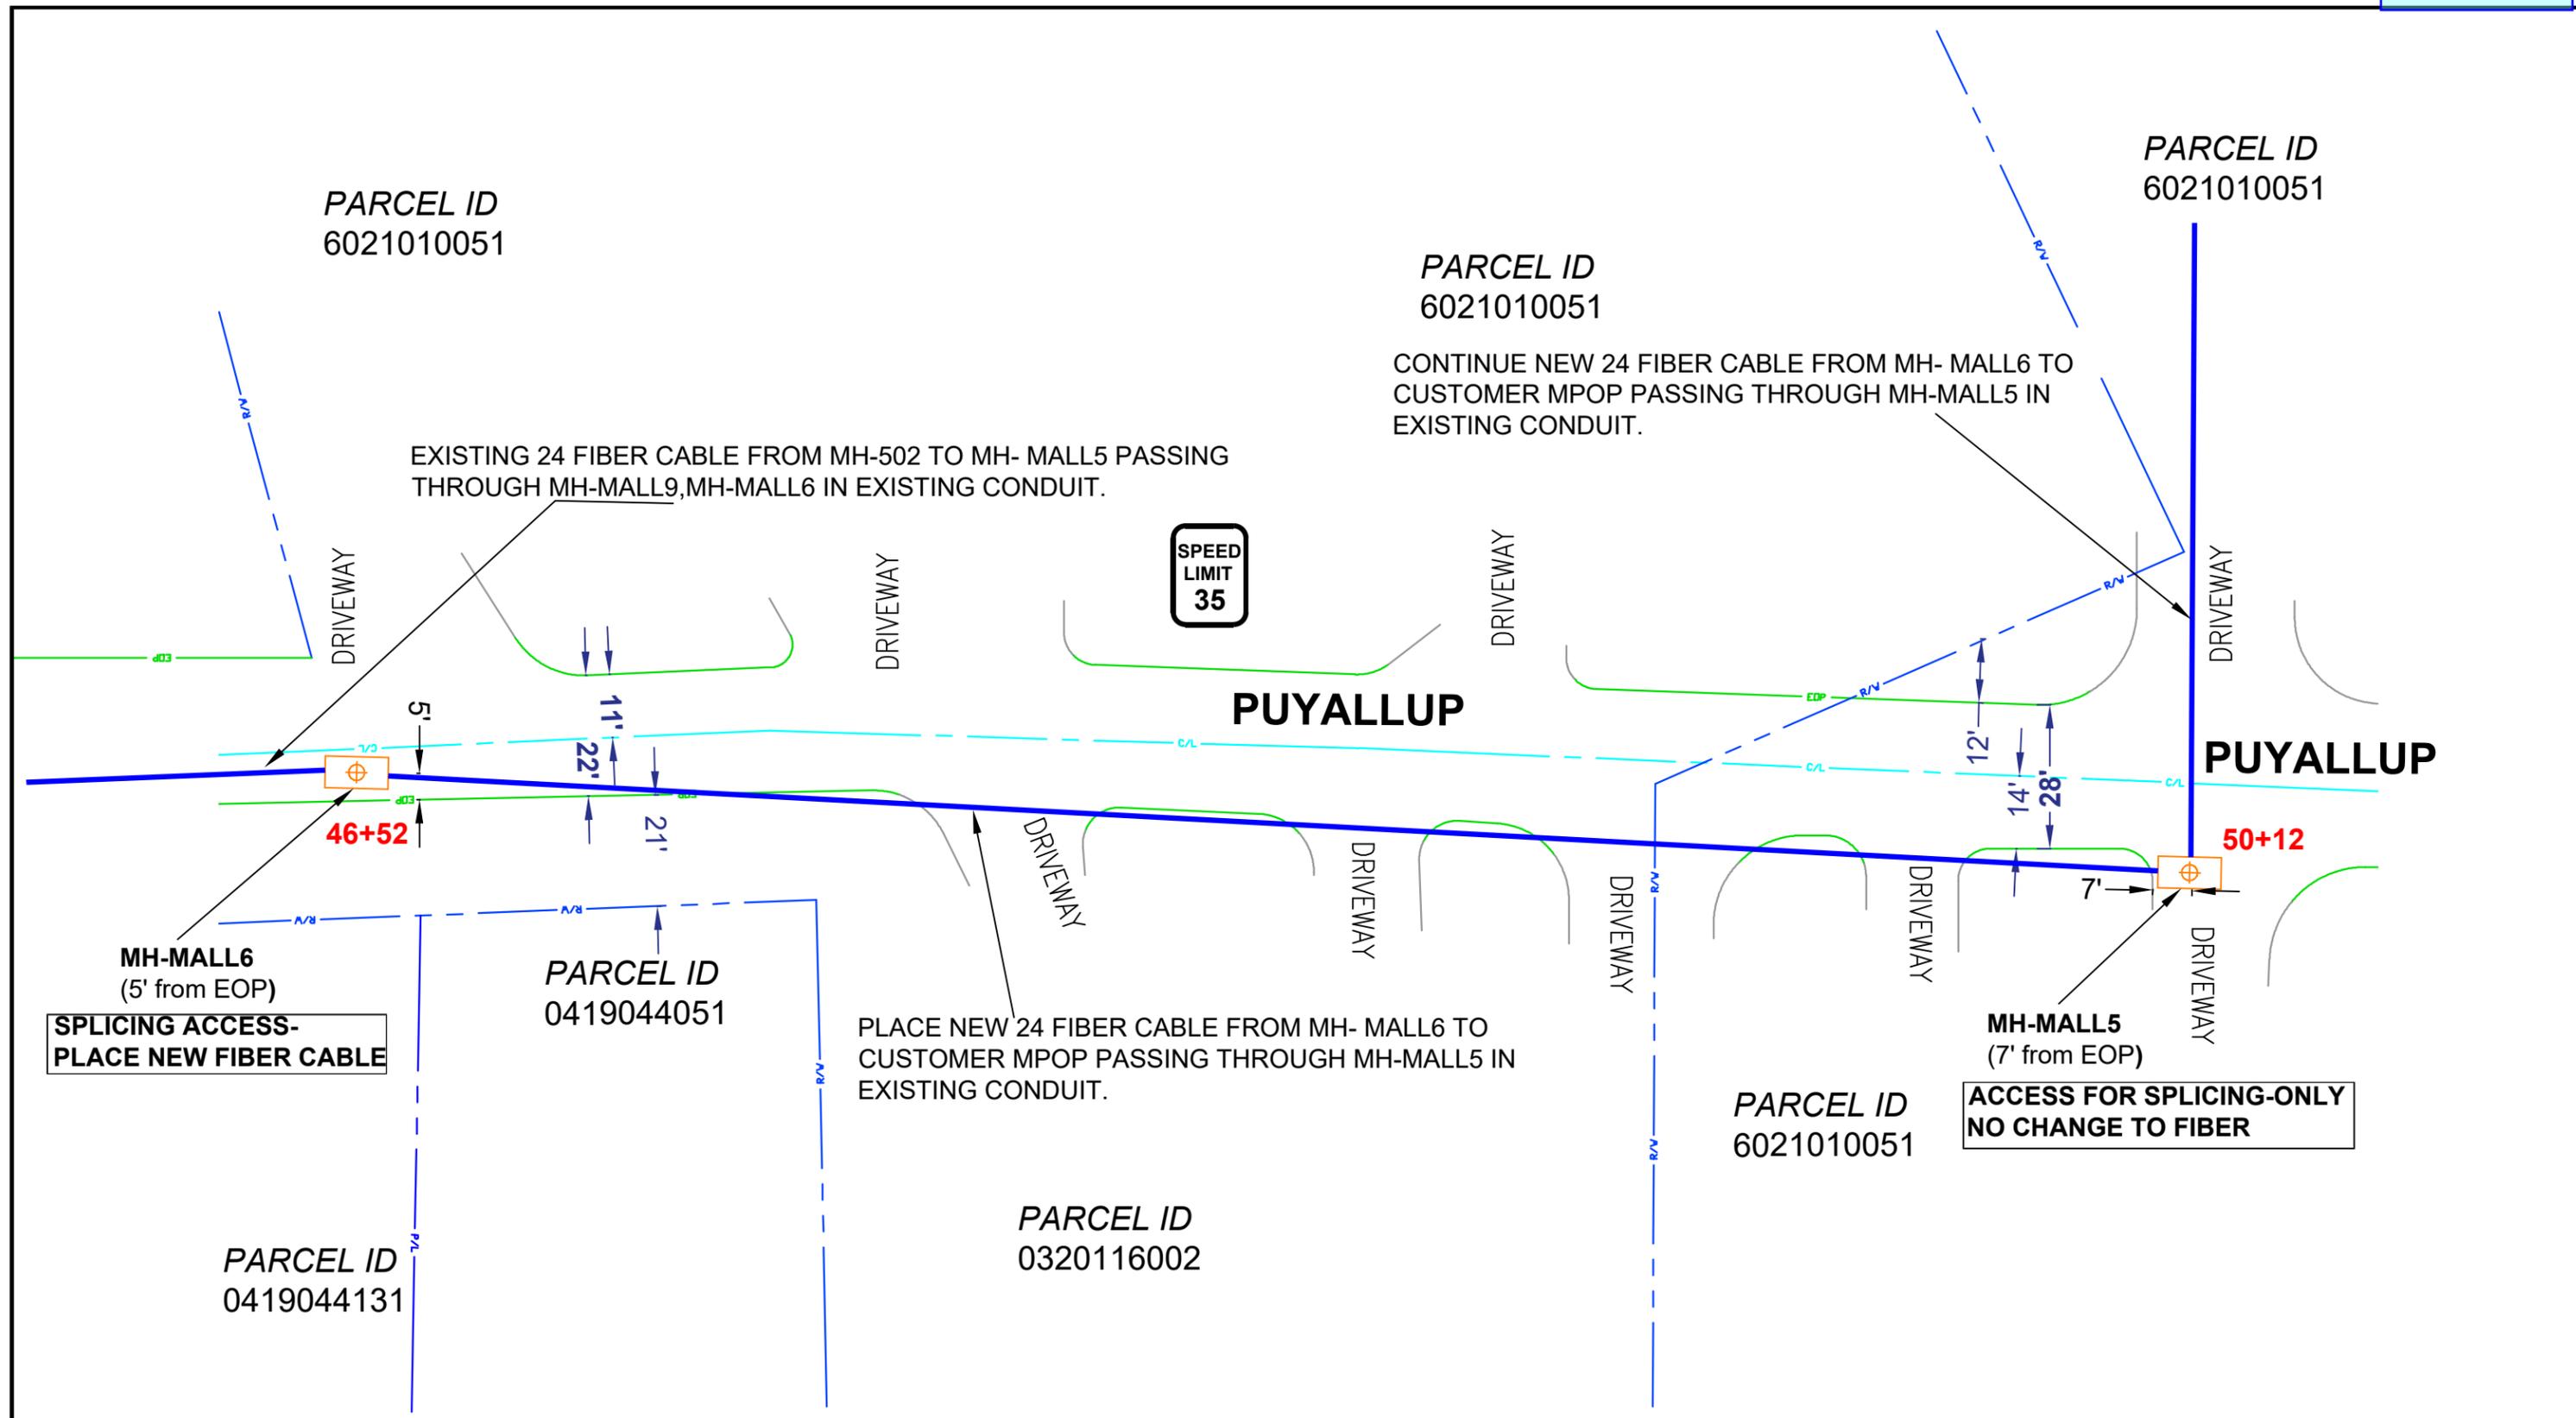

	CUSTOMER INFORMATION NAME: THE BUCKLE INC ADDRESS: 3500 S MERIDIAN, UNIT 640 CITY, STATE: PUYALLUP, WA ZIP CODE: 98373 CLLI: PYLPWA01	ENGINEERING CONTACT NAME: JEREMIAH SCHERER PHONE: 702-395-2776 	CONTRACT ENGINEER NAME: LAKEN HUNTER PHONE: 662-871-6309 CYIENT INC	CALL TWO WORKING DAYS BEFORE YOU DIG 		EXCEPT AS MAY BE OTHERWISE PROVIDED BY CONTRACT, THESE DRAWINGS AND SPECIFICATIONS SHALL REMAIN THE PROPERTY OF CENTURY LINK BEING ISSUED IN STRICT CONFIDENCE	
					SECTION: 4 TOWNSHIP: 19N RANGE: 4E		

**CUSTOMER LOCATION
3500 S MERIDIAN UNIT 640**

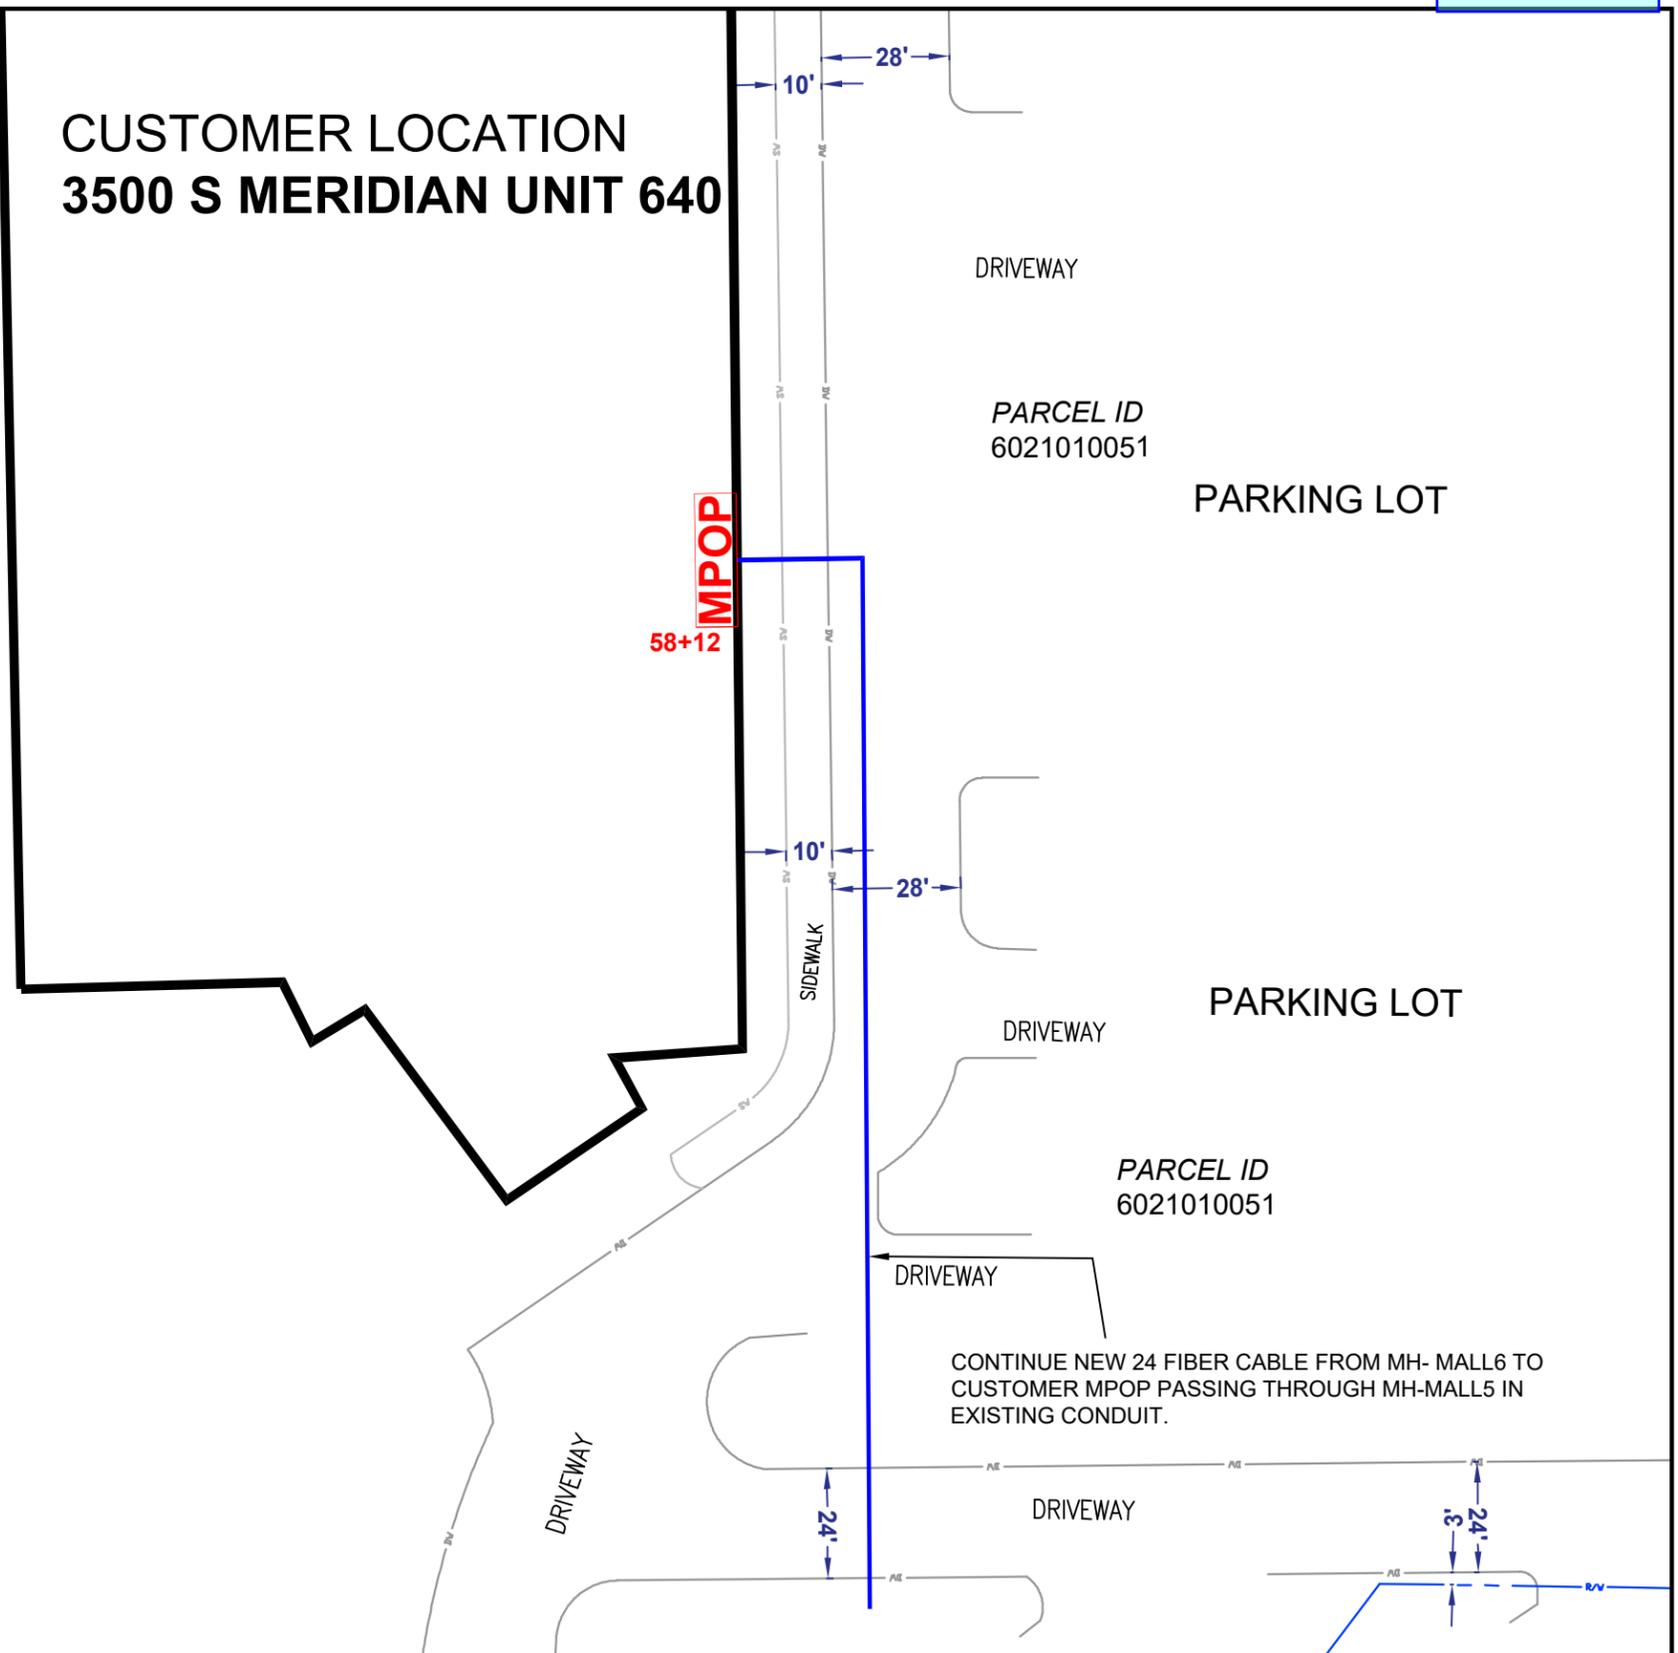

	CUSTOMER INFORMATION		ENGINEERING CONTACT		CONTRACT ENGINEER			EXCEPT AS MAY BE OTHERWISE PROVIDED BY CONTRACT, THESE DRAWINGS AND SPECIFICATIONS SHALL REMAIN THE PROPERTY OF CENTURY LINK BEING ISSUED IN STRICT CONFIDENCE	
	NAME: THE BUCKLE INC ADDRESS: 3500 S MERIDIAN, UNIT 640 CITY, STATE: PUYALLUP, WA ZIP CODE: 98373 CLLI: PYLPWA01		NAME: JEREMIAH SCHERER PHONE: 702-395-2776 		NAME: LAKEN HUNTER PHONE: 662-871-6309 CYIENT INC				
				SECTION: 4 TOWNSHIP: 19N RANGE: 4E		SCALE: 1"=100' JOB: P.058208 DATE: 10/29/2023		REVISION: 2 SH: 09 OF 10	



	CUSTOMER INFORMATION		ENGINEERING CONTACT	CONTRACT ENGINEER		EXCEPT AS MAY BE OTHERWISE PROVIDED BY CONTRACT, THESE DRAWINGS AND SPECIFICATIONS SHALL REMAIN THE PROPERTY OF CENTURY LINK BEING ISSUED IN STRICT CONFIDENCE	
	NAME: THE BUCKLE INC ADDRESS: 3500 S MERIDIAN, UNIT 640 CITY, STATE: PUYALLUP, WA ZIP CODE: 98373 CLLI: PYLPWA01		NAME: JEREMIAH SCHERER PHONE: 702-395-2776 	NAME: LAKEN HUNTER PHONE: 662-871-6309 CYIENT INC			
				<small>CALL TWO WORKING DAYS BEFORE YOU DIG</small> 	SECTION: 4 TOWNSHIP: 19N RANGE: 4E	SCALE: 1"=100' JOB: P.058208 DATE: 10/29/2023	REVISION: 2 SH: 10 OF 10