



STORE # 2403 ALARM PLANS 2025 GENERAL REMODEL SECURITY TECHNOLOGY REVIEW SET DRAWINGS

FACILITY ADDRESS

WALMART STORE #2403 310 31ST AVENUE SE PUYALLUP, WA 98374

APPLICABLE CODES

DESIGNED IN ACCORDANCE WITH THE FOLLOWING STANDARDS

NFPA STANDARDS:

NFPA 72

NEC 70

2019
2020

OTHER STANDARDS:
INTERNATIONAL BUILDING CODE

INTERNATIONAL FIRE CODE

2021

*BUILDING IS EQUIPPED THROUGHOUT WITH AN AUTOMATIC SPRINKLER SYSTEM.

LOCAL CONTACTS

BUILDING OFFICIAL:

BUILDING SERVICES

DAVID DRAKE — FIRE INSPECTOR BUILDING DIVISION

333 S MERIDIAN, 2ND FLOOR

PUYALLUP, WA 98371

253-864-4171

DDRAKE@PUYALLUPWA.GOV

SHEET INDEX

EFPO ALARM COVER PAGE

EFP1 ELECTRONIC FIRE PROTECTION PLAN

EFP2 ELECTRONIC FIRE PROTECTION RISER AND CALCULATIONS

ENGINEER CONSULTANT

PROJECT MANAGER
PROJECT DESIGNER
PHONE NUMBER

PROJECT DESIGNER EMAIL ADDRESS

JOSHUA A. HOUGHTON, C.E.T.

ANNE STURTEVANT

479-636-5004

AHS@TEAMOFCHOICE.COM

BUILDING INFORMATION

*OCCUPANCY CLASSIFICATION: MERCANTILE

*SQUARE FOOTAGE: EXISTING: 197,124 SF
REMODELED: 30,000 SF

*TYPE OF CONSTRUCTION: TYPE VB

*TOTAL OCCUPANT LOAD: 3,129 OCCUPANTS

*NUMBER OF FLOORS: 1

*BUILDING IS EQUIPPED THROUGHOUT WITH AN AUTOMATIC SPRINKLER SYSTEM.

WALMART SECURITY ENGINEER

ASSIGNED WALMART SECURITY ENGINEER
PHONE NUMBER

RICARDO ALVAREZ

479-371-3256

RICARDO.ALVAREZ@WALMART.COM

SECURITY MANAGER

ASSIGNED WALMART SECURITY MANAGER
PHONE NUMBER
EMAIL ADDRESS

EMAIL ADDRESS

EMAIL ADDRESS

1-800-530-9924 #1

CHRISTIAN MULLEN
641-202-0830
CHRISTIAN.MULLEN@WALMART.COM

SECURITY TECHNOLOGY COORDINATOR

ASSIGNED WALMART ALARM COORDINATOR
PHONE NUMBER

STEPHANIE FLANERY

479-204-2731

STEPHANIE.DRAKE@WALMART.COM

MONITORING AGENCY

ALARM SERVICE COMPANY AND SERVICE CENTER:


WAL-MART STORES INC
702 SW 8TH ST
BENTONVILLE, AR 72716

CERTIFICATE OF COMPLIANCE IS ATTACHED IN DATA SHEET SUBMITTAL DOCUMENTS.

Joshua A. Houghton
teamofchoice.com

SUITE 3975
1805 N 2ND ST
1805 N 2ND



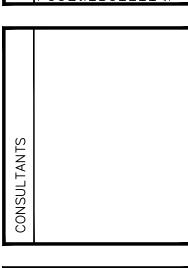



CHECK	BRY	

ISSUE BLOCK

02/05/25 PCC #

CHECKED BY: BRY

DRAWN BY: AHS

PROTO: 192


POSSESSION DATE: 01/13/25


DOCUMENT DATE: 10/21/24





EFPO

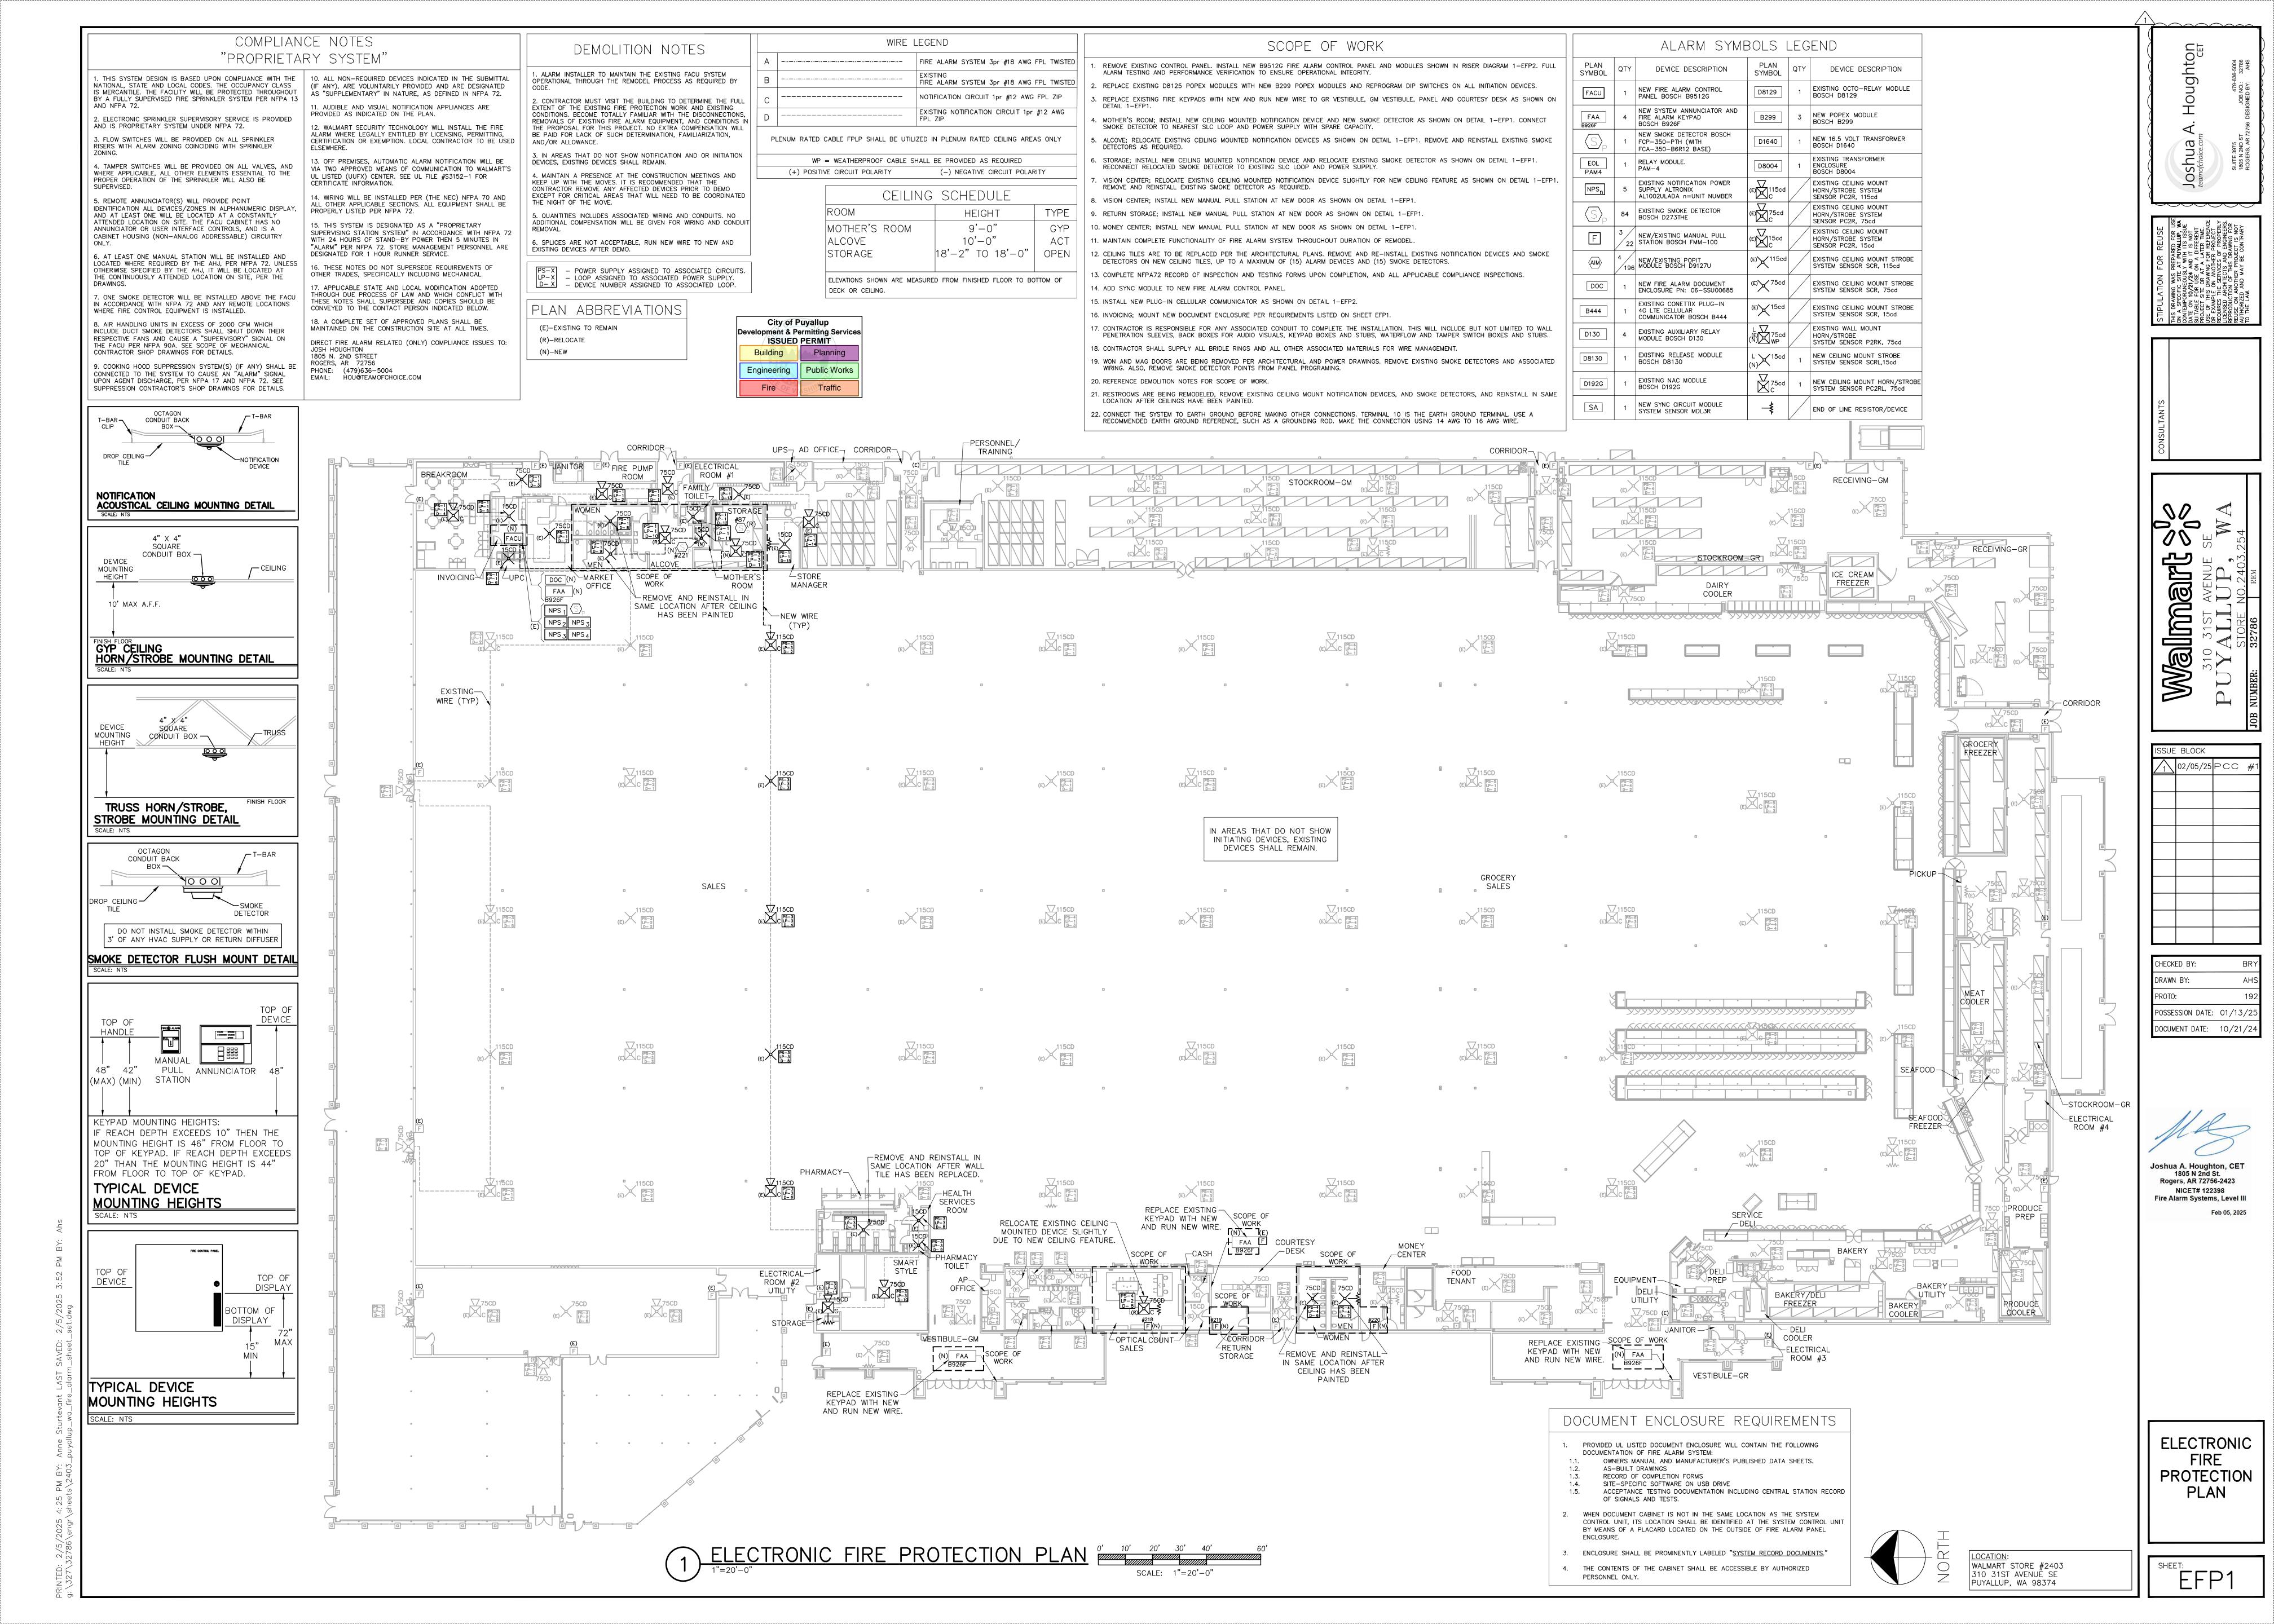

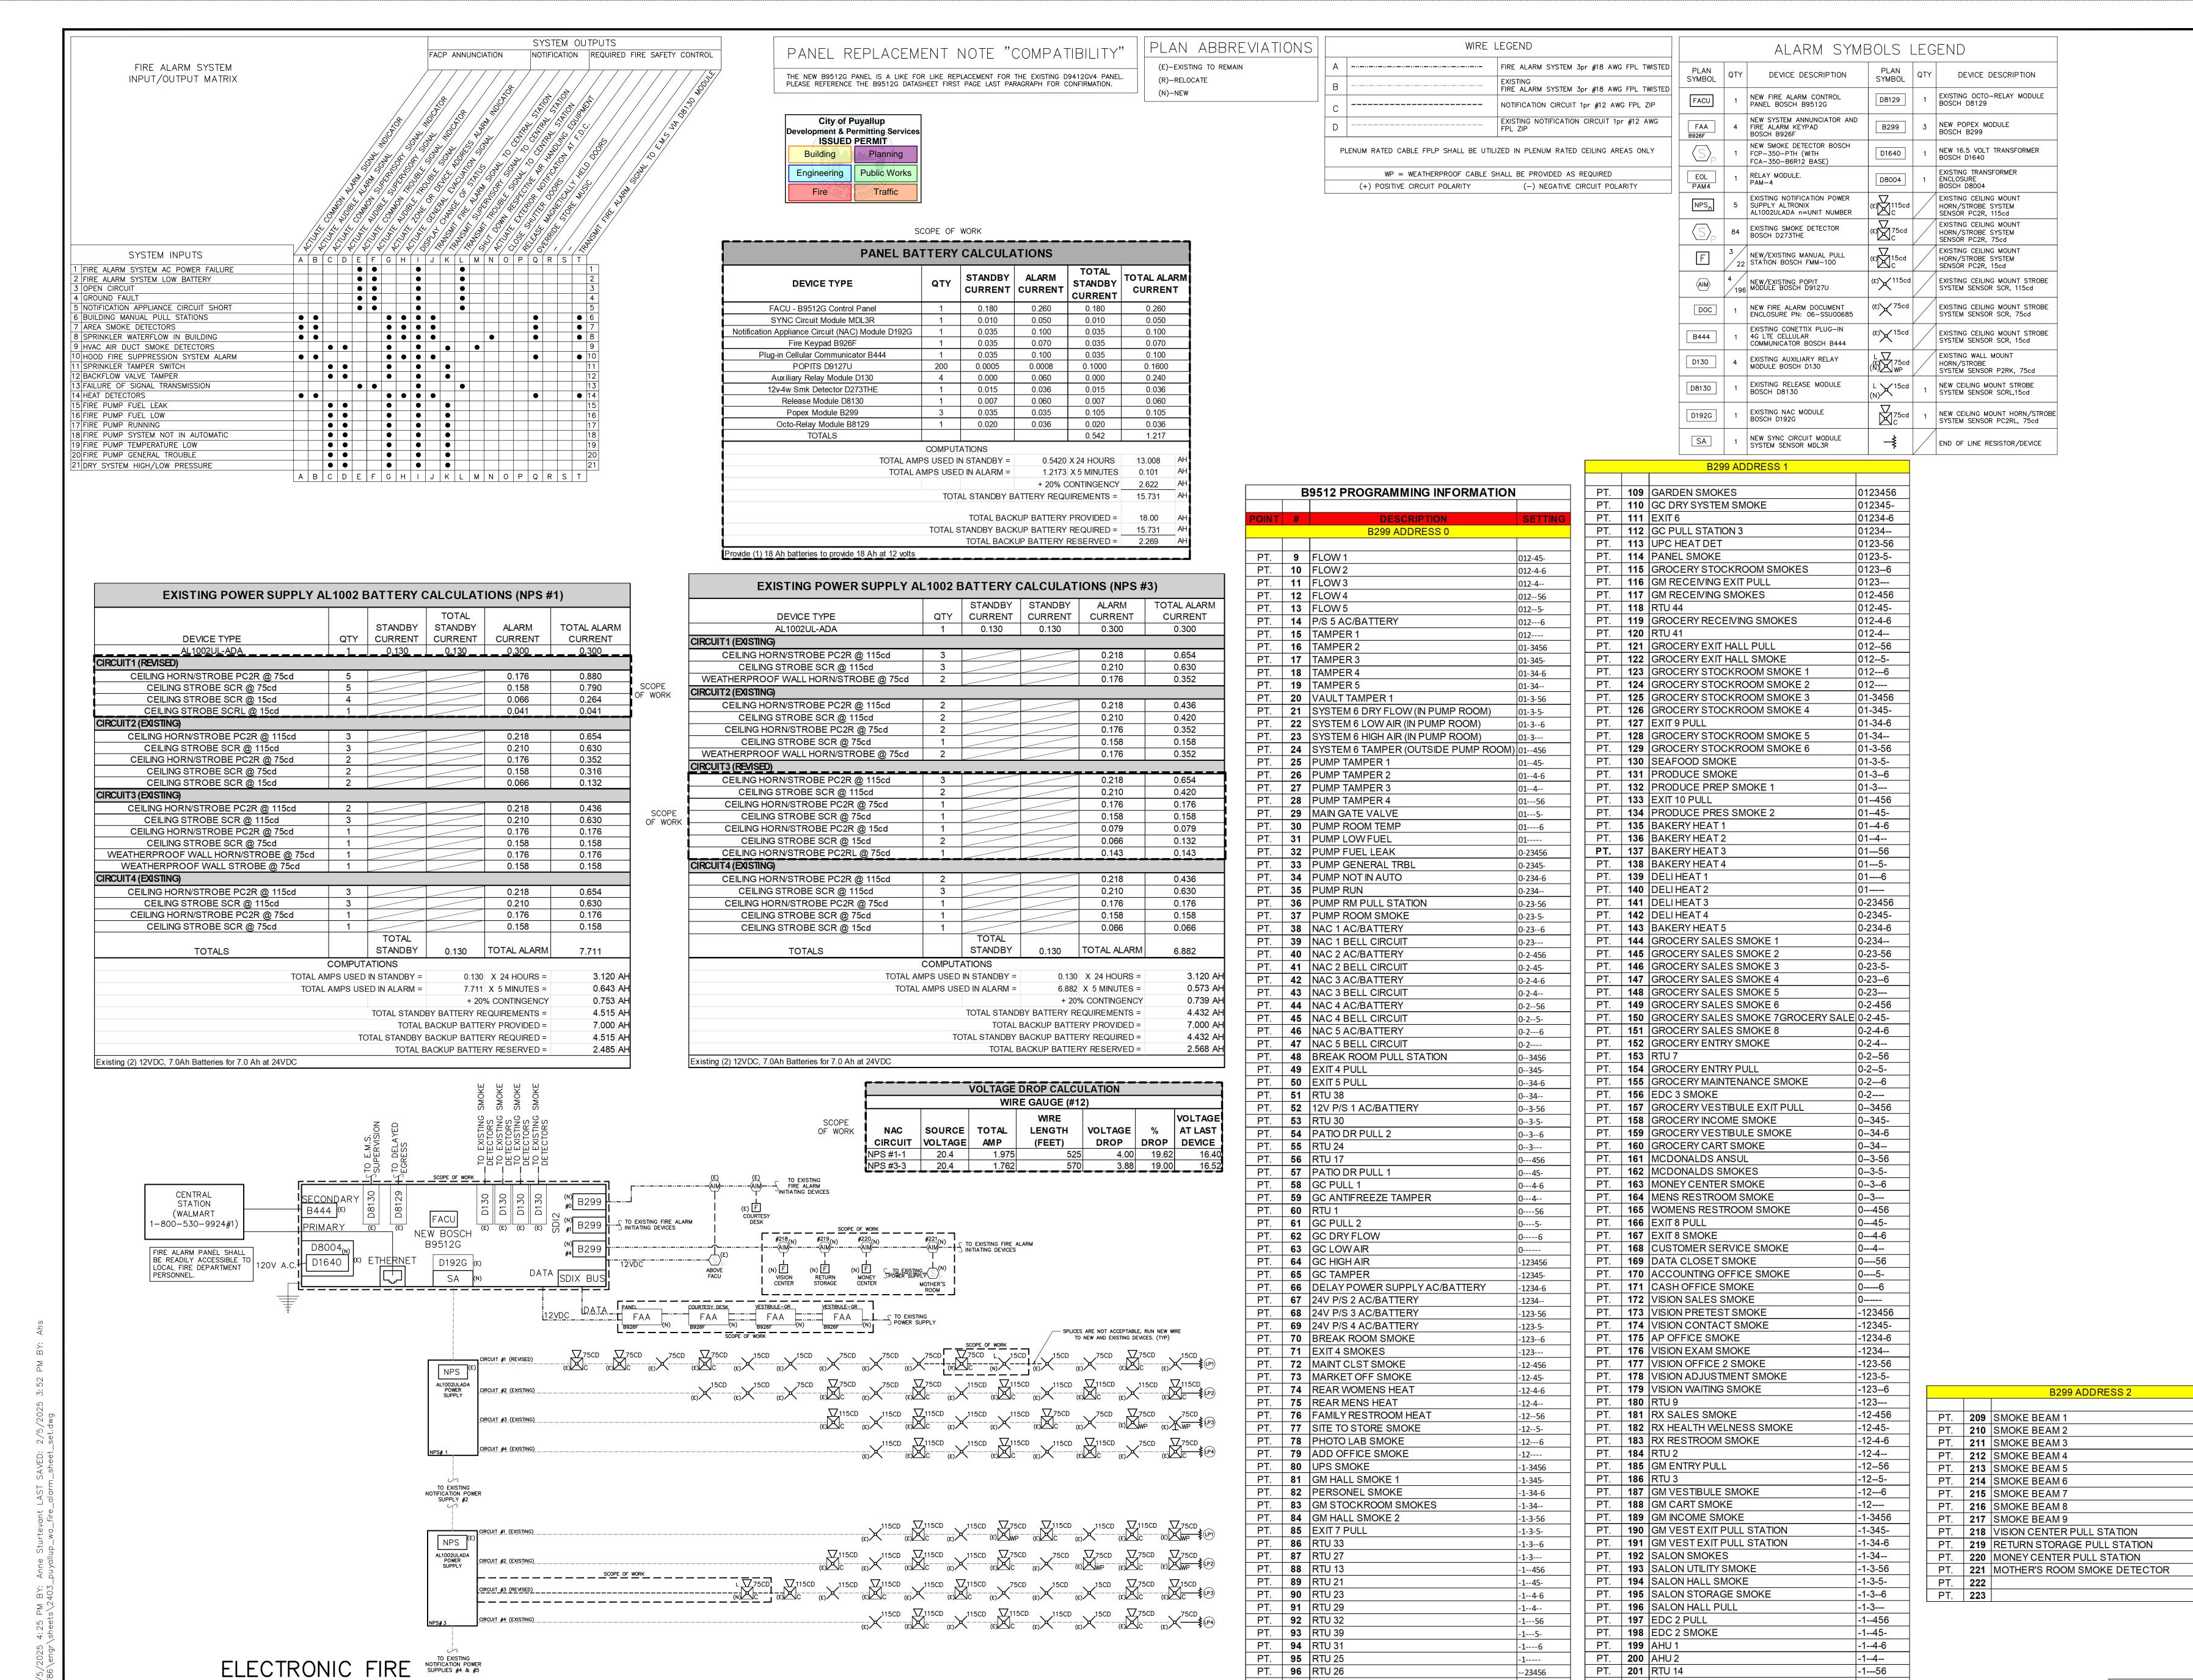

PROTECTION RISER DIAGRAM

PT. **97** RTU 20

PT. | **98** | RTU 19

PT. **99** RTU 18

PT. | 202 | DELIANSUL HOOD

PT. | 204 | VISION OFFICE 1 SMOKE

PT. | 203 | CUSTOMER SERVICE PULL STATION

--2345-

-1---5-

-1----6

-1----

Joshua A. Houghton
teamofchoice.com

Suite 3975
1805 N 2ND ST
ROGERS, AR 72756 DESIGNED BY: AHS

STIPULATION FOR REUSE
THIS DRAWING WAS PREPARED FOR USE
ON A SPECIFIC SITE AT **PUYALLUP, WA**CONTEMPORANEOUSLY WITH ITS ISSUE
DATE ON 10/21/24 AND IT IS NOT
SUITABLE FOR USE ON A DIFFERENT
PROJECT SITE OR AT A LATER TIME.
USE OF THIS DRAWING FOR REFERENCE
OR EXAMPLE ON ANOTHER PROJECT
REQUIRES THE SERVICES OF PROPERLY
LICENSED ARCHITECTS AND ENGINEERS.
REPRODUCTION OF THIS DRAWING FOR
REUSE ON ANOTHER PROJECT IS NOT
AUTHORIZED AND MAY BE CONTRARY

CONSULTANTS

Walmartsology
310 31ST AVENUE SE
PUYALLUP, WA
STORE NO.2403.254

SSUE	BLOCK		
$\overline{1}$	02/05/25	PCC	#1
			-
HECK	FD RY:		BRY
$H \vdash I \ K$	FII HY'		HHY

HECKED BY:	BRY
RAWN BY:	AHS
ROTO:	192
DSSESSION DATE:	01/13/25
DCUMENT DATE:	10/21/24



ELECTRONIC FIRE PROTECTION RISER AND CALCULATIONS

LOCATION:
WALMART STORE #2403
310 31ST AVENUE SE
PUYALLUP, WA 98374

0123456

12345-

1234-6

01234--

0123-5-

0123--6

0123---

012-456

012-45-

012-4-6

012-4--

012--56

012--5-

FFP2