
## CENTERIS DATA CENTER L3

FAS SYSTEM MODIFICATION

1023 39TH AVENUE SOUTH EAST, PUYALLUP, WA 98374

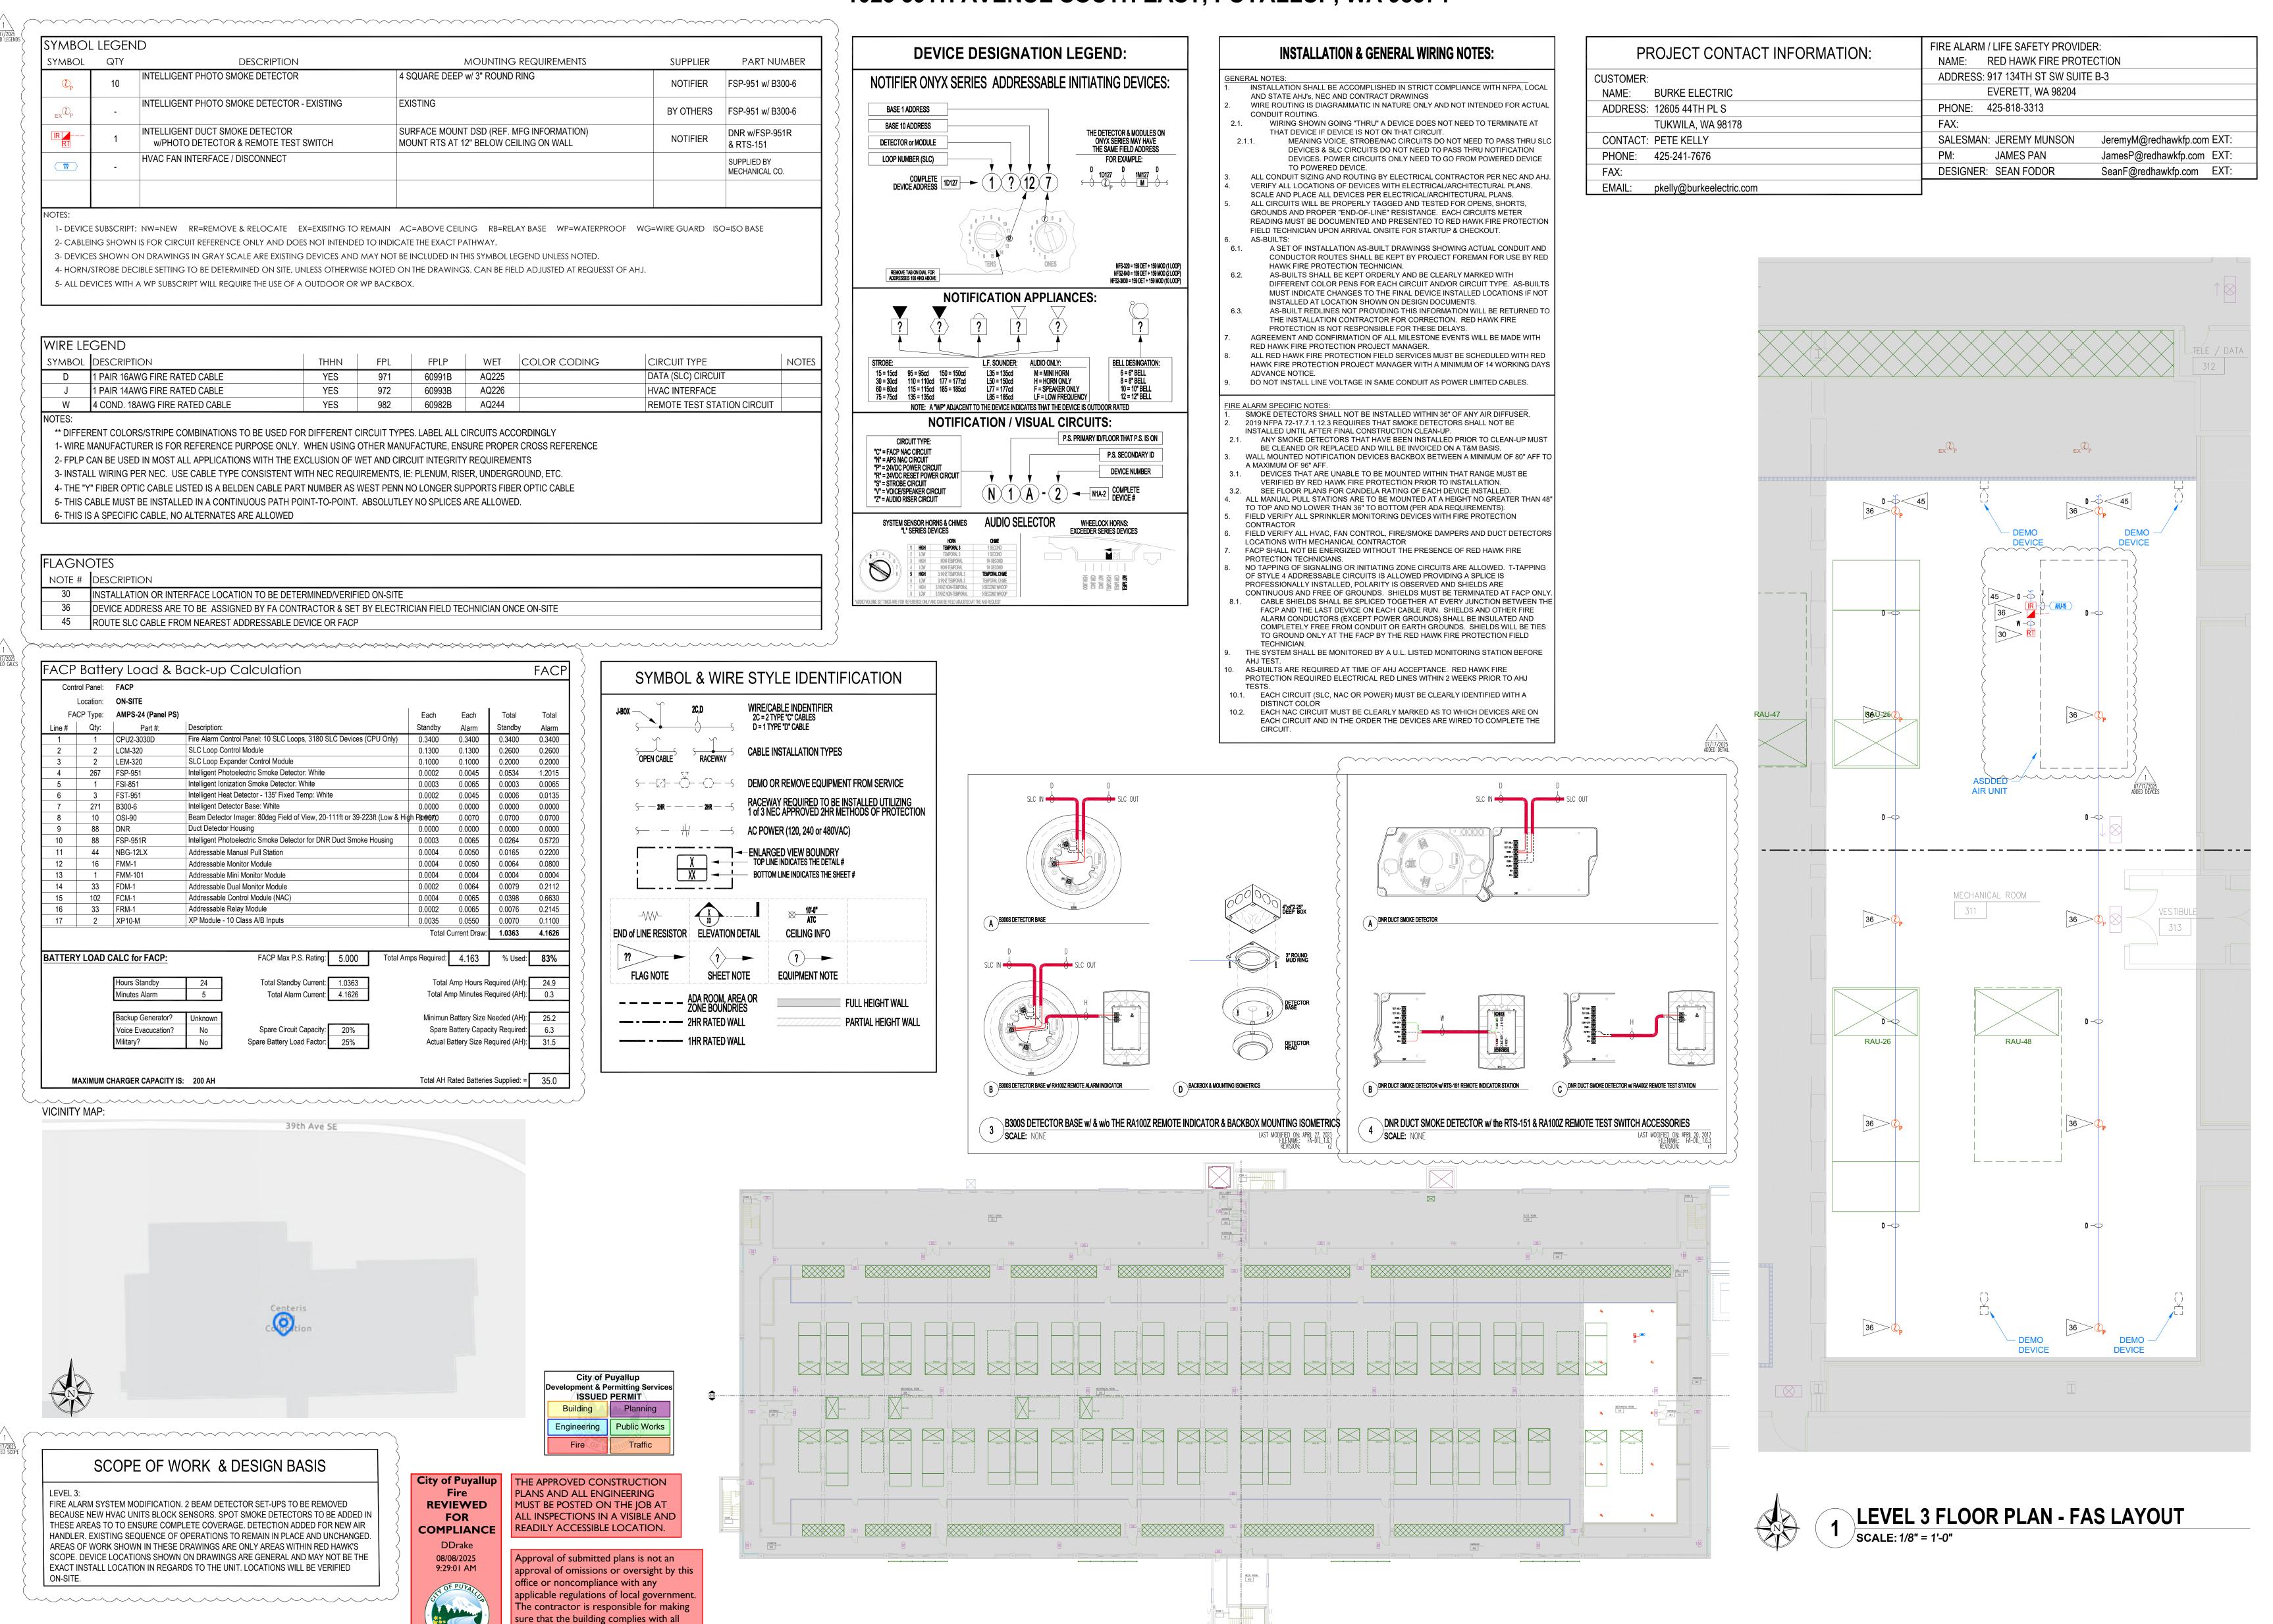

2 LEVEL 3 FLOOR PLAN - OVERALL

applicable building codes and regulations of

the local government.



NICET Stamp

NICET

CERTIFICATION

THESE FIRE ALARM DRAWINGS
HAVE BEEN REVIEWED BY:
MIKE SERESUN
FIRE PROTECTION ENGINEERING
TECHNOLOGY
FIRE ALARM SYSTEMS - LEVEL III
NICET CERTIFICATION # 101668
CERTIFICATION EXPIRES - 11/01/2027

Approvals Required

Revisions

BURKE ELECTRIC

12605 44TH PL S
TUKWILA, WA 98178

05/01/2025 SDF PERMIT SUBMITTAL SET

1023 39TH AVENUE SOUTH EAST PUYALLUP, WA 98374

CENTERIS DATA

CENTER L3

FAS SYSTEM MODIFICATION

PROJECT INFO, FAS LAYOUT, CALCS & DETAILS

Key Plan

Sheet Number

SCALE:  $\frac{1}{8}$ " = 1'-0" 8 6 4 2 0 
 Date:
 05/01/2025

 Job Number:
 390070

 Designer:
 SEAN D. FODOR

FA-0.00 SHEET 1 OF 1