

ELECTRICAL SYMBOL LEGEND

SYMBOL	DESCRIPTION	SYMBOL	DESCRIPTION	SYMBOL	DESCRIPTION	SYMBOL	DESCRIPTION
LIGHTING				POWER			
	BOLLARD LIGHT FIXTURE		TV/RECEPTACLE	FIRE ALARM			
	CEILING FAN		CONNECTION		FIRE ALARM BELL W/ STROBE	SYSTEMS	
	EMERGENCY BATTERY PACK		JUNCTION BOX (CEILING/FLOOR, WALL)		FIRE ALARM BELL		CAMERA
	REMOTE HEADS		POWER POLE		FIRE ALARM BUZZER W/ STROBE		PROX READER
	EXIT SIGN (SOLID FILL INDICATES FACE, ARROW INDICATES DIRECTION)		MOTOR		FIRE ALARM BUZZER		CARD READER
LIGHTING FIXTURES					FIRE ALARM CHIME W/ STROBE		ELECTRIC STRIKE
NOTE:					FIRE ALARM CHIME		MAGNETIC LOCK
REFER TO LIGHTING FIXTURE SCHEDULE SPECIFICATION FOR MODEL NUMBERS AND OPTIONS.					FIRE ALARM HORN W/ STROBE (CEILING, WALL)		DOOR CONTACT
SOLID FILL INDICATES EMERGENCY OR NIGHT EGRESS.					FIRE ALARM HORN (CEILING, WALL)		PUSHBUTTON
SWITCHES					FIRE ALARM STROBE (CEILING, WALL)		KEYPAD
	SINGLE POLE SWITCH		DUPLEX RECEPTACLE		FIRE ALARM SYMBOL (CEILING, WALL)		WALL INTERCOM
	SINGLE POLE DIMMER SWITCH		DUPLEX RECEPTACLE ABOVE COUNTER		FIRE ALARM PULL STATION SYMBOL		CHIME/STROBE
	3-WAY SWITCH		HORIZONTAL DUPLEX RECEPTACLE		FIRE ALARM SPEAKER (CEILING, WALL)	NURSE CALL	
	4-WAY SWITCH		EMERGENCY RECEPTACLE		FIRE ALARM SPEAKER W/ HORN STATION SYMBOL		NURSE CALL DOME LIGHT W/ LIGHT # INDICATED (CEILING, WALL)
	SINGLE POLE SWITCH WITH PILOT LIGHT		SPLIT RECEPTACLE		FIRE ALARM SPEAKER W/ STROBE (CEILING, WALL)		NURSE CALL CODE BLUE STATION
	MULTI-GANGED SWITCH (QUANTITY SHOWN)		GFI RECEPTACLE		SMOKE DETECTOR		NURSE CALL DUTY STATION
	OCCUPANCY SENSOR (CEILING, WALL, DIMMER)		LIT GFI RECEPTACLE		COMBINATION SMOKE/CO DETECTOR		NURSE CALL EMERGENCY STATION
	LIGHT SENSOR		RECEPTACLE FOURPLEX (WALL, FLOOR)		PHOTOELECTRIC DETECTOR		NURSE CALL HELP STATION
	PHOTO CELL		SURGE SUPPRESSION RECEPTACLE		DIALING TERMINAL		NURSE CALL MASTER STATION
	TIME CLOCK		SPECIAL RECEPTACLE (CEILING, WALL, FLOOR)		DUCT SMOKE DETECTOR		NURSE CALL PATIENT STATION
EXTERIOR POLE MOUNTED HEAD (HEAD QTY INDICATED)					HEAT DETECTOR		NURSE CALL STAFF STATION
COMMUNICATIONS					DOOR HOLDER		NURSE CALL WANDERGUARD STATION
ANNOTATIONS					BREAK	NOT ALL SYMBOLS APPEAR ON DRAWINGS	
NOT ALL SYMBOLS APPEAR ON DRAWINGS					KITCHEN EQUIP		
					MECHANICAL EQUIP		
					PANEL/CIRCUIT		
					KEY NOTE		
					REVISION		

Puyallup Fire Prevention:
Separate permit is required for fire alarm.


ELECTRICAL ABBREVIATIONS LIST

1P	1 POLE (2P, 3P, 4P, ETC.)	DCP	DOMESTIC WATER CIRCULATING PUMP	HT	HEIGHT HEATING	NEMA	NATIONAL ELECTRICAL MANUFACTURER'S ASSOCIATION	SWBD	SWITCHBOARD
A	AMPERE	DEPT	DEPARTMENT	HTG	HEATING	NFDS	NON-FUSED SAFETY DISCONNECT SWITCH	SYM	SYMMETRICAL
AC	ABOVE COUNTER OR AIR CONDITIONER	DET	DETAIL	HV	HIGH VOLTAGE	NL	NOT IN CONTRACT	TEL	TELEPHONE
ACLO	ABOVE CEILING	DISC	DISCONNECT	HVAC	HEATING, VENTILATING AND AIR CONDITIONING	NLS	NIGHT LIGHT	TEL/DATA	TELEPHONE/DATA
ADO	AUTOMATIC DOOR OPENER	DIST	DISTRIBUTION	HWP	HYDRO-PNEUMATIC WATER PUMP	NLS	NIGHT LIGHT	TERM	TERMINAL
AF	AFRAME	DN	DOWN	IC	INTER interrupting CAPACITY	NLS	NIGHT LIGHT	TR	TAMPER RESISTANT
AFB	ABOVE FINISHED FLOOR	DPR	DAMPER	IG	ISOLATED GROUND	NLS	NIGHT LIGHT	T-STAT	THERMOSTAT
AFG	ABOVE FINISHED GRADE	DS	DOUBLE THROW	IMC	INTERMEDIATE METAL CONDUIT	NLS	NIGHT LIGHT	TTC	TELEPHONE TERMINAL
ARC	ARC FAULT CIRCUIT INTERRUPTER	DWG	DRAWING	INC	INCANDESCENT	NLS	NIGHT LIGHT	TVTC	TELEVISION TERMINAL
AHU	AIR HANDLING UNIT	EC	ELECTRICAL CONTRACTOR	IR	INFRARED	NLS	NIGHT LIGHT	TYP	TYPICAL
AL	ALUMINUM	ELEC	ELECTRIC, ELECTRICAL	IW	INTERLOCK WITH	NLS	NIGHT LIGHT	UC	UNDER COUNTER
ALT	ALTERNATE	ELEV	ELEVATOR	J-BOX	JUNCTION BOX	NLS	NIGHT LIGHT	UE	UNDERGROUND ELECTRICAL
AMP	AMPERE	EMS	EMERGENCY MANAGEMENT SYSTEM	KV	KILOVOLT	NLS	NIGHT LIGHT	UH	UNIT HEATER
AMPL	AMPLIFIER	EMT	ELECTRIC METALLIC TUBING	KVA	KILOVOLT-AMPERE	NLS	NIGHT LIGHT	UJ	UNDERGROUND JUNCTION
ANNU	ANNUNCIATOR	EP	ELECTRIC PNEUMATIC EQUIPMENT	KVAR	KILOVOLT-AMPERE REACTIVE	NLS	NIGHT LIGHT	UL	UTILITY
APPROX	APPROXIMATELY	EW	ELECTRIC WATER COOLER	KWH	KILOWATT HOUR	NLS	NIGHT LIGHT	UV	UNIT VENTILATOR OR ULTRAVIOLET
AQ-STAT	AQUASTAT	EXP	EXPLOSION PROOF	LOC	LOCATE OR LOCATION	NLS	NIGHT LIGHT	V	VOLT
ARCH	ARCHITECT, ARCHITECTURAL	FA	FIRE ALARM	LT	LIGHTING	NLS	NIGHT LIGHT	VA	VOLT-AMPERES
AS	AMP SWITCH	FABP	FIRE ALARM BOOSTER POWER SUPPLY PANEL	LTNG	LIGHTNING	NLS	NIGHT LIGHT	VDT	VIDEO DISPLAY TERMINAL
AT	AMP TRIP	FCU	FAN COIL UNIT	LV	LOW VOLTAGE	NLS	NIGHT LIGHT	VERT	VERTICAL
ATS	AUTOMATIC TRANSFER SWITCH	FX	FIXTURE	MAX	MAXIMUM	NLS	NIGHT LIGHT	VFD	VARIABLE FREQUENCY DRIVE
AUTO	AUTOMATIC	FLR	FLOOR	MAG.S	MAGNETIC STARTER	NLS	NIGHT LIGHT	VOL	VOLUME
AUX	AUXILIARY	FLU	FLUORESCENT	MOM	MOMENTARY CONTACT	NLS	NIGHT LIGHT	W	WATT
AV	AUDIO VISUAL	FUS	FUSED SAFETY DISCONNECT SWITCH	MDC	MAIN DISTRIBUTION CENTER	NLS	NIGHT LIGHT	W/	WITH
AWG	AMERICAN WIRE GAUGE	GA	GAUGE	MFB	MAIN FUSED DISCONNECT SWITCH	NLS	NIGHT LIGHT	WG	WIRE GUARD
BATT	BATTERY	GALV	GALVANIZED	MFS	MAIN FUSED DISCONNECT SWITCH	NLS	NIGHT LIGHT	WH	WATER HEATER
BD	BOARD	GEN	GENERATOR	MIS	MISCELLANEOUS	NLS	NIGHT LIGHT	W/O	WITHOUT
BLDG	BUILDING	GFI	GROUND FAULT CIRCUIT INTERRUPTER	MISC	MISCELLANEOUS	NLS	NIGHT LIGHT	WP	WEATHERPROOF
BMS	BUILDING MANAGEMENT SYSTEM	GFP	GROUND FAULT PROTECTOR	MMS	MAIN LUGS ONLY	NLS	NIGHT LIGHT	XFMR	TRANSFORMER
C	CONDUIT	GND	GROUND	MTR	MOTOR, MOTORIZED	NLS	NIGHT LIGHT	XFR	TRANSFER
CAB	CABINET	GP	GROUNDING	N	NORMALLY CLOSED	NLS	NIGHT LIGHT		
CAT	CATALOG	GPB	GROUNDING PNEUMATIC BREAKER	NEC	NATIONAL ELECTRICAL CODE	NLS	NIGHT LIGHT		
CATV	CABLE TELEVISION	H	HANDS-OFF-AUTOMATIC SWITCH			NLS	NIGHT LIGHT		
CB	CIRCUIT BREAKER	HOA	HANDS-OFF-AUTOMATIC SWITCH			NLS	NIGHT LIGHT		
CCTV	CLOSED CIRCUIT TELEVISION	HORIZ	HORIZONTAL			NLS	NIGHT LIGHT		
CKT	CIRCUIT	HP	HORSEPOWER			NLS	NIGHT LIGHT		
COMB	COMBINATION	HPF	HIGH POWER FACTOR			NLS	NIGHT LIGHT		
COMP	COMPRESSOR					NLS	NIGHT LIGHT		
CONN	CONNECTION					NLS	NIGHT LIGHT		
CONSTR	CONSTRUCTION					NLS	NIGHT LIGHT		
CONT	CONTINUATION OR CONTINUOUS					NLS	NIGHT LIGHT		
CONTR	CONTRACTOR					NLS	NIGHT LIGHT		
CONV	CONVECTOR					NLS	NIGHT LIGHT		
CR	CIRCUITING PUMP					NLS	NIGHT LIGHT		
CR1	CATHODE-RAY TUBE					NLS	NIGHT LIGHT		
CT	CURRENT TRANSFORMER					NLS	NIGHT LIGHT		
CTR	CENTER					NLS	NIGHT LIGHT		
CU	COPPER					NLS	NIGHT LIGHT		

ELECTRICAL EQUIPMENT NAMING CONVENTION

	PANEL LP01		DISTRIBUTION PANEL DP01
	PANEL HP01		KITCHEN PANEL KP11
	EMERGENCY LIFE SAFETY PANEL ELS01		POOL PANEL PP01
	EMERGENCY LEGALLY REQUIRED PANEL ELS01		CAR CHARGING PANEL EV01
	DISCONNECT DS01		ELEV DISC ELEV01
	STEP DOWN TRANSFORMER (NON-UTILITY) T01, ELS01, ELS01, ELS01		ELEV DISC LEGALLY REQUIRED ELS01
	MAIN SWITCH BOARD MSB01		
	METER BANK (WITH TAP BOX OR MAIN SWITCH) MB01		
	AUTOMATIC TRANSFER SWITCH ATSO1, ELS01, ELS01, ELS01		
	MANUAL TRANSFER SWITCH MTS01, ELS01, ELS01, ELS01		

- STANDARD IDENTIFICATION RULES
- 120/208V = LP
 - 277/480V = HP
 - FLOOR OR LEVEL, THEN COUNT DESIGNATION = LP01, LP11, LP12, ETC.
 - BASMENT OR LOWER LEVEL OF 9 STORY OR LESS = 01
 - FIRST FLOOR OR FIRST LEVEL OF 10 PLUS STORES = 011
 - WING OR BUILDING DESIGNATION = A01, B01, ETC.
 - ELS = LIFE SAFETY (NEC 701)
 - ELR = LEGALLY REQUIRED (NEC 701)
 - EOS = OPTIONAL, STANDBY (NEC 702)

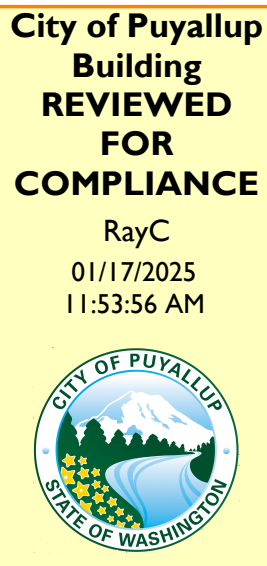

PRCNC20240424

Approval of submitted plans is not an approval of omissions or oversight by this office or non-compliance with any applicable regulations of local government. The contractor is responsible for making sure that the building complies with all applicable building codes and regulations of the local government.

THE APPROVED CONSTRUCTION PLANS AND ALL ENGINEERING MUST BE POSTED ON THE JOB AT ALL INSPECTIONS IN A VISIBLE AND READILY ACCESSIBLE LOCATION. PRINT IN COLOR and to SCALE.

Electrical approval is by WA labor and industries, separate electrical permits are required.

LIGHT FIXTURE SCHEDULE

ID#	FIXTURE TYPE	MOUNTING	LAMPS	LENS, LIVERY, ETC.	MANUFACTURER'S CATALOG NUMBER	NOTES
L1	6" DISK LIGHT (UNIT LIGHT)	RECESSED	10W LED 1200 LUMENS 2700K	WHITE	ELITE: RL643-1000L/1300L-DIMTR/120-DIM/VOLT: 2700K/30K/40K/50K/60K/90-WH OR APPROVED EQUAL	
L2	20" DECORATIVE (UNIT BLD LIGHT)	SEMI-FLUSH	(3) 18W LED 2700K	WESTERN BRONZE & ETCHED GLASS (FROSTED)	QUOZZEL LIGHTING: ASHLAND QF12025W/1 OR APPROVED EQUAL	
L3	28" VANITY (UNIT BATHROOM)	SURFACE	(4) 9W LED 2700K	BRONZE	QUOZZEL LIGHTING: LANCASTER, 2507-4-88 OR APPROVED EQUAL	3
L4	NIGHT LIGHT (UNIT)	WALL	3.5W LED 3000K	WHITE	WAC LIGHTING: WL LED140 OR APPROVED EQUAL	
L5	UNDERCABINET LIGHT	SURFACE	1.5W PER FOOT LED, 3000K	LED TAPE LIGHT	KICHLER: #111085530WH OR APPROVED EQUAL	
L6	HEAT LAMP (UNIT BATHROOM)	RECESSED	250W	WHITE	BROAN: MODEL 161 OR APPROVED EQUAL	
G1	24" PENDANT (LOBBY DAYROOM)	SURFACE	(5) 10W LED 2700K	VERITY FINISH	MARCO CONTRACT: CC-6870 OR APPROVED EQUAL	
G2	18" DECORATIVE (COMMON CORRIDOR)	SURFACE	(4) 10W LED 2700K	OLD BRONZE	QUOZZEL: CDT11900Z OR APPROVED EQUAL	
G3	36" PENDANT (DINING)	CEILING	32.5W LED 2815 LUMENS 3000K	WALNUT FROSTED POLYMER	CERNO: PLURA PENDANT 06-230-36 OR APPROVED EQUAL	
G4	30" FLUSH MOUNT (PARLOR)	SURFACE	32.5W LED 2815 LUMENS 3000K	WALNUT FROSTED POLYMER	CERNO: PLURA FLUSH 06-100-30-W-F-30 OR APPROVED EQUAL	
G5	18" PENDANT (LINK ENTRY)	SURFACE	(5) 10W LED 2700K	DISTRESSED BLACK	KICHLER: ELBUR COLLECTION: #1264DBK OR APPROVED EQUAL	
G6	36" PENDANT (CHAPEL)	SURFACE	(1) 50W LED 3688 LUMENS	VERITY FINISH	LIGHTOLOGY: GRAC TUG313004 OR APPROVED EQUAL	9
G7	23" VANITY (RESTROOM)	WALL	(5) 9W LED 2700K	VINTAGE BRONZE	MINKA LIVERY: 0963-284 OR APPROVED EQUAL	3
G8	GLASS PANEL (CHAPEL)	SURFACE	1.5W PER FOOT LED, 3000K	LED TAPE LIGHT	DSA SIGNAGE: LPS OR APPROVED EQUAL	
G9	LED EYEBALL (LOBBY)	RECESSED	10.0W 700 LUM 2700K	WHITE TRIM	HALO: B7C47NS LITHONIA: 401 OR APPROVED EQUAL	
C10	40" FLUSH MOUNT (PARLOR)	SURFACE	32.5W LED 2815 LUMENS 3000K	WALNUT FROSTED POLYMER	CERNO: PLURA FLUSH 06-100-30-W-F-46 OR APPROVED EQUAL	
C13	16" LINEAR PENDANT (CORRIDOR 10107)	SURFACE	120W 3000K	BLACK	AFX LIGHTING: AFX218038S OR APPROVED EQUAL	
C14	4" SCONCE (WELLNESS)	WALL	10W 800 LUMENS 3000K	HAZEL BRONZE	HUNT LIGHTING: CALETTA LED MINI PENDANT #N82150412 OR APPROVED EQUAL	
C15	30"x42" LIGHTED MIRROR (LOCKER RM)	WALL	45W 604 LUMENS 3000K	MIRROR	INTENSITY LIGHTED MIRROR: 30"x42" LIGHTED MIRROR OR APPROVED EQUAL	
C16	TAPE LIGHT (UNIT ENTRY)	SURFACE	TAPE LIGHT IN TRACK	TAPE LIGHT IN TRACK	KICHLER: #111085530WH OR APPROVED EQUAL	
C17	48" LINEAR (CORRIDOR)	RECESSED	15W 3000K 3200 LUMENS	TITANIUM SILVER	LEDALITE: 2901LBQ-4-7-MVOLT-E-T-A48" OR APPROVED EQUAL	
C18	LINEAR (CONF. RM)	SURFACE	45W 3000K 4767 LUMENS	WHITE TRIM	CORLIETT BUDIM: B-WL SERIES OR APPROVED EQUAL	
C19	POOL FIXTURE	PENDANT	TBD	TBD	TBD	
AA	9" EXTERIOR SCONCE (MAIN ENTRIES)	WALL	12W LED BROWN OIL RUBBED FINISH	BROWN OIL RUBBED FINISH	HINKLEY LIGHTING: MANHATTAN 22340Z OR APPROVED EQUAL	
BB	11" EXTERIOR SCONCE (RETAIL)	WALL	(1) 12W LED BROWN OIL RUBBED FINISH	BROWN OIL RUBBED FINISH	HINKLEY LIGHTING: MANHATTAN 22350Z OR APPROVED EQUAL	
CC	6" DOWNLIGHT (CORRIDOR)	RECESSED	16W LED 1234 LUMENS 4000K	WHITE	HALO: SMD6 OR APPROVED EQUAL	
A	2X4 FLAT PANEL (STORAGE)	RECESSED	80W LED 8000 LUMENS 2700K	LENS	EATON: 24P827C9 OR APPROVED EQUAL	
A1	2X4 DIRECT INDIRECT (THEATRE)	RECESSED	45W 8000 LUMENS 2700K	BASKET	EATON: 24C2-3-5 UNV L827-CBLU OR APPROVED EQUAL	
B	2X2 DIRECT INDIRECT (OFFICE)	RECESSED	30W 4400 LUMENS 2700K	BASKET	EATON: 22C2-3-5 UNV L827-CBLU OR APPROVED EQUAL	1
Q	6" DOWNLIGHT (CORRIDOR)	VARIABLE	LED 1000-4000 LUMENS	WHITE FINISH	ELITE: RL643-1000L/1300L-DIMTR/120-DIM/VOLT: 2700K/30K/40K/50K/60K/90-WH OR APPROVED EQUAL	
Q1	4" DOWNLIGHT (UNIT ENTRY)	RECESSED	10W LED 600 LUMENS 2700K	WHITE	ELITE: RS475-SL-CCT OR APPROVED EQUAL	
E	EXIT SINGLE FACE	SURFACE CEILING/WALL	LED INCLUDED	WHITE FINISH & GREEN LETTERS (MATCH EXISTING)	EATON: APK7G OR APPROVED EQUAL	11.12
E1	EXIT DOUBLE FACE	SURFACE CEILING/WALL	LED INCLUDED	WHITE FINISH & GREEN LETTERS (MATCH EXISTING)	EATON: APK7G OR APPROVED EQUAL	11.12
EM1	EMERGENCY LIGHT (BUSINESS)	WALL	LED INCLUDED	WHITE	LITHONIA: EUC-8 OR APPROVED EQUAL	2
H	4" LED STRIP	SURFACE CEILING	40W 4000 LUM 4000K	WHITE FINISH	METALUX: 4572L-4040R OR APPROVED EQUAL	
H1	8" LED STRIP	SURFACE CEILING	75W 9000 LUM 4000K	WHITE FINISH	METALUX: 8572L-4040R OR APPROVED EQUAL	
J	NOT USED					
K	LIGHTBUSH RAIL (POOL)	SUSPENDED	LED 30W	WHITE	LIGHTBUSH RAIL: RL12079 OR APPROVED EQUAL	
M	STAIR LIGHT	SURFACE WALL	54W 4000 LUM 3000K	WHITE FINISH & ACRYLIC LENS	METALUX LIGHTING: FDR102170-40WLED-4000LUM LUM 4000K OR APPROVED EQUAL	3
U	48" ELEVATOR PIT	SURFACE WALL	52W 4000 LUM 3000K	WHITE FINISH, RUBBED FROSTED LENS	EATON: AT45-LDS-4-G UNV L840-CBLU OR APPROVED EQUAL	

GENERAL NOTES:

- CONNECT UNDER COUNTER LIGHTS TO THE NEAREST 120V NORMAL CIRCUIT.
- CONDUIT/FIXTURE FINISHES WITH ARCHITECT PRIOR TO SHOP DRAWING SUBMITTAL.
- ELECTRICAL CONTRACTOR TO VERIFY UNDERCOUNTER LENGTH WITH ARCHITECT & CABINET SUPPLIER.
- DUAL LIGHTING ASSEMBLIES SHALL BE PROVIDED WITH LAMP AND PHOTO MOUNTS TO MATCH THOSE SPECIFIED.
- COORDINATE ALL RECESSED LIGHTING ASSEMBLIES WITH CEILING TYPE, PROVIDE FLANGE BATHS AS REQUIRED.
- ALL LED LAMP WATTS & LUMENS ARE LISTED BASED ON DESIGN REQUIREMENTS.
- ALL LAMPS SHALL BE LED UNLESS SPECIFICALLY NOTED OTHERWISE.
- ASSEMBLIES LISTED WITH MEDIUM BASE SOCKETS SHALL BE PROVIDED WITH A19 SERIES LED LAMPS CRI 90+.
- ELECTRICAL CONTRACTOR SHALL PROVIDE ALL LAMPS FOR EACH LIGHTING ASSEMBLY AS SCHEDULED & SPECIFIED.
- INSTALL CENTER BARNET THERMOSTAT CLAP TO CORRIDOR WALLS, WHEN LOCATED IN CORRIDORS.
- VERIFY EXACT PENDANT LENGTH WITH ARCHITECT PRIOR TO ORDERING.
- FIELD COORDINATE EXACT LOCATION AND MOUNTING HEIGHT PRIOR TO ROUGH-IN.

SPECIFIC NOTES:


- PROVIDE WITH INTEGRAL OCCUPANCY SENSOR TO REDUCE LIGHT TO MINIMUM WHEN UNOCCUPIED.
- PROVIDE ASSEMBLY FOR 1.5 HOUR MINIMUM OPERATION FOR LOAD SERVED.
- PROVIDE ASSEMBLY MOUNTED ABOVE MIRROR WITH SHADES MOUNTED DOWN. VERIFY EXACT LOCATION PRIOR TO ORDERING.
- PROVIDE CONNECTION TO A LIFE SAFETY UNSWITCHED HOT CIRCUIT.


STEEN
ENGINEERING

763-585-6742
763-585-6757 fax
Email: steen@steeneng.com
5430 Douglas Drive North
Minneapolis, MN 55429


in = site
architects

1000 university ave. w. suite 130
st. paul, minnesota 55104
612-252-4820

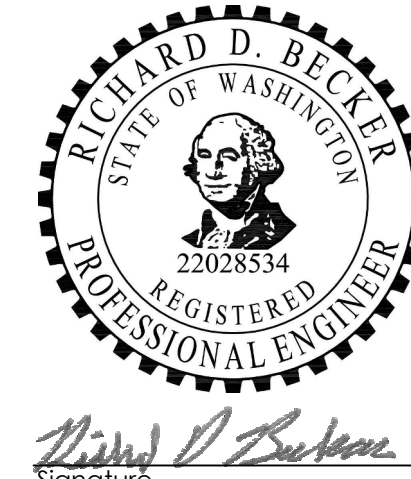

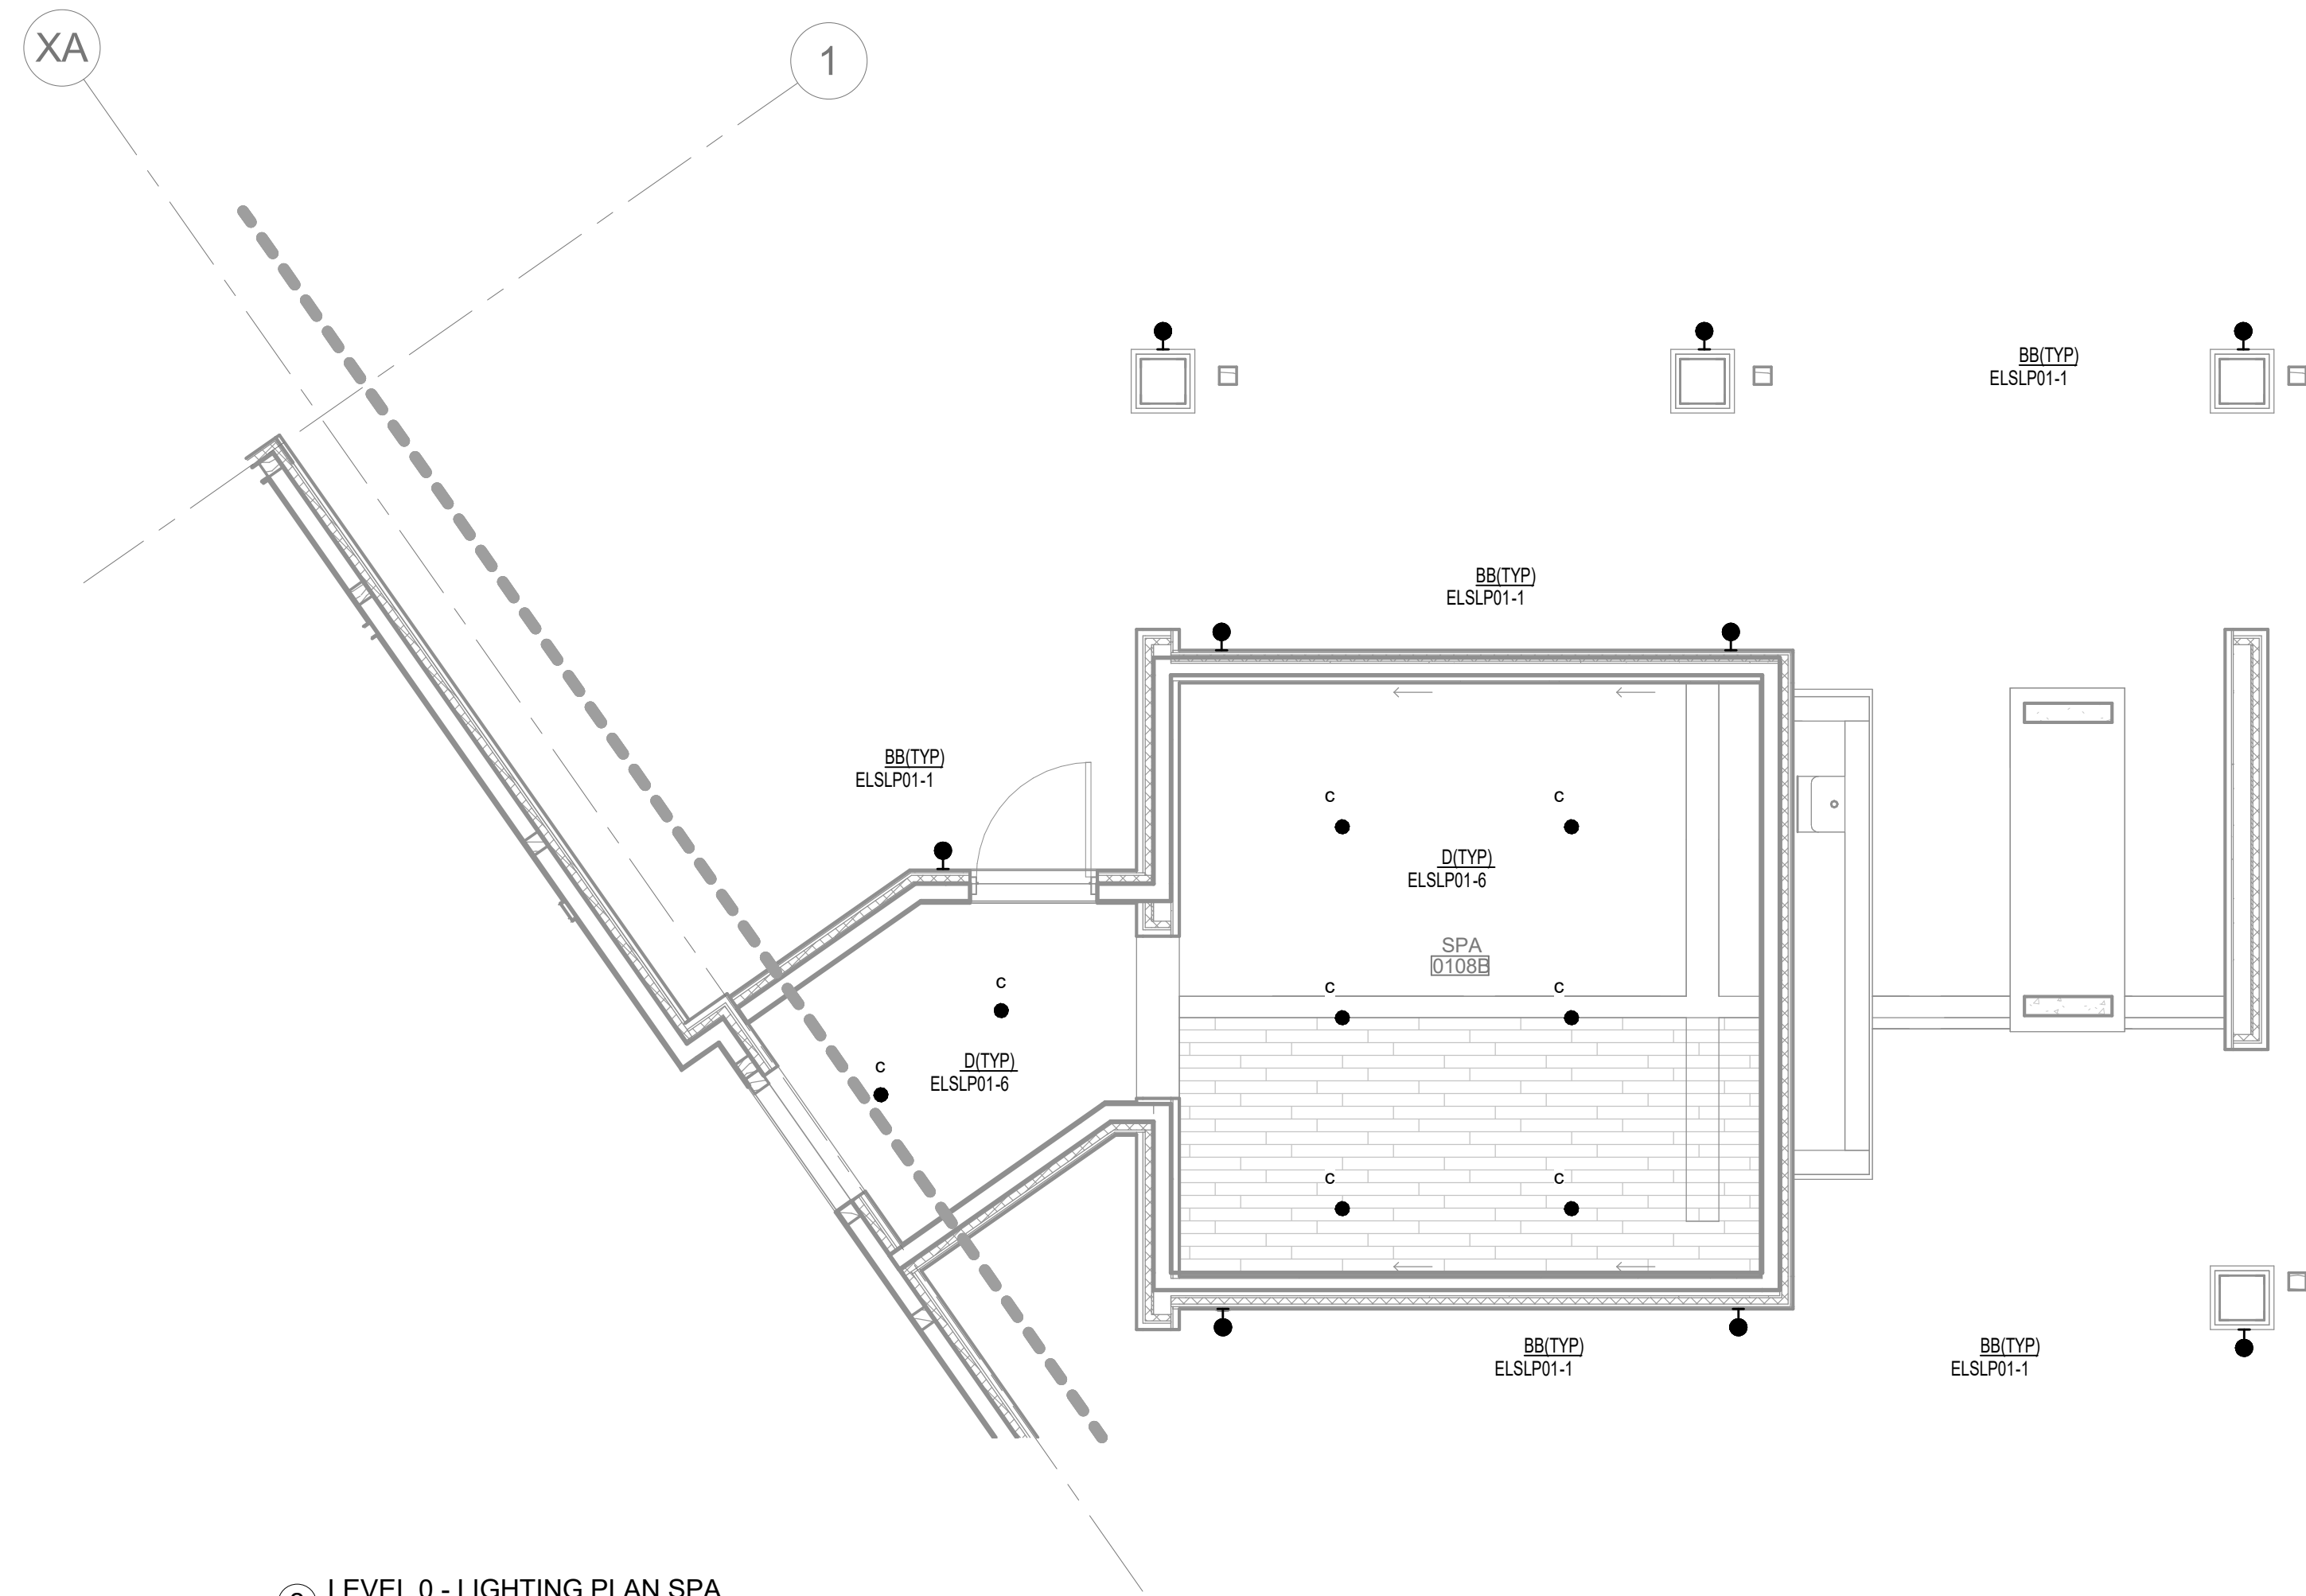

2 LEVEL 0 - LIGHTING PLAN SPA
1/4" = 1'-0"

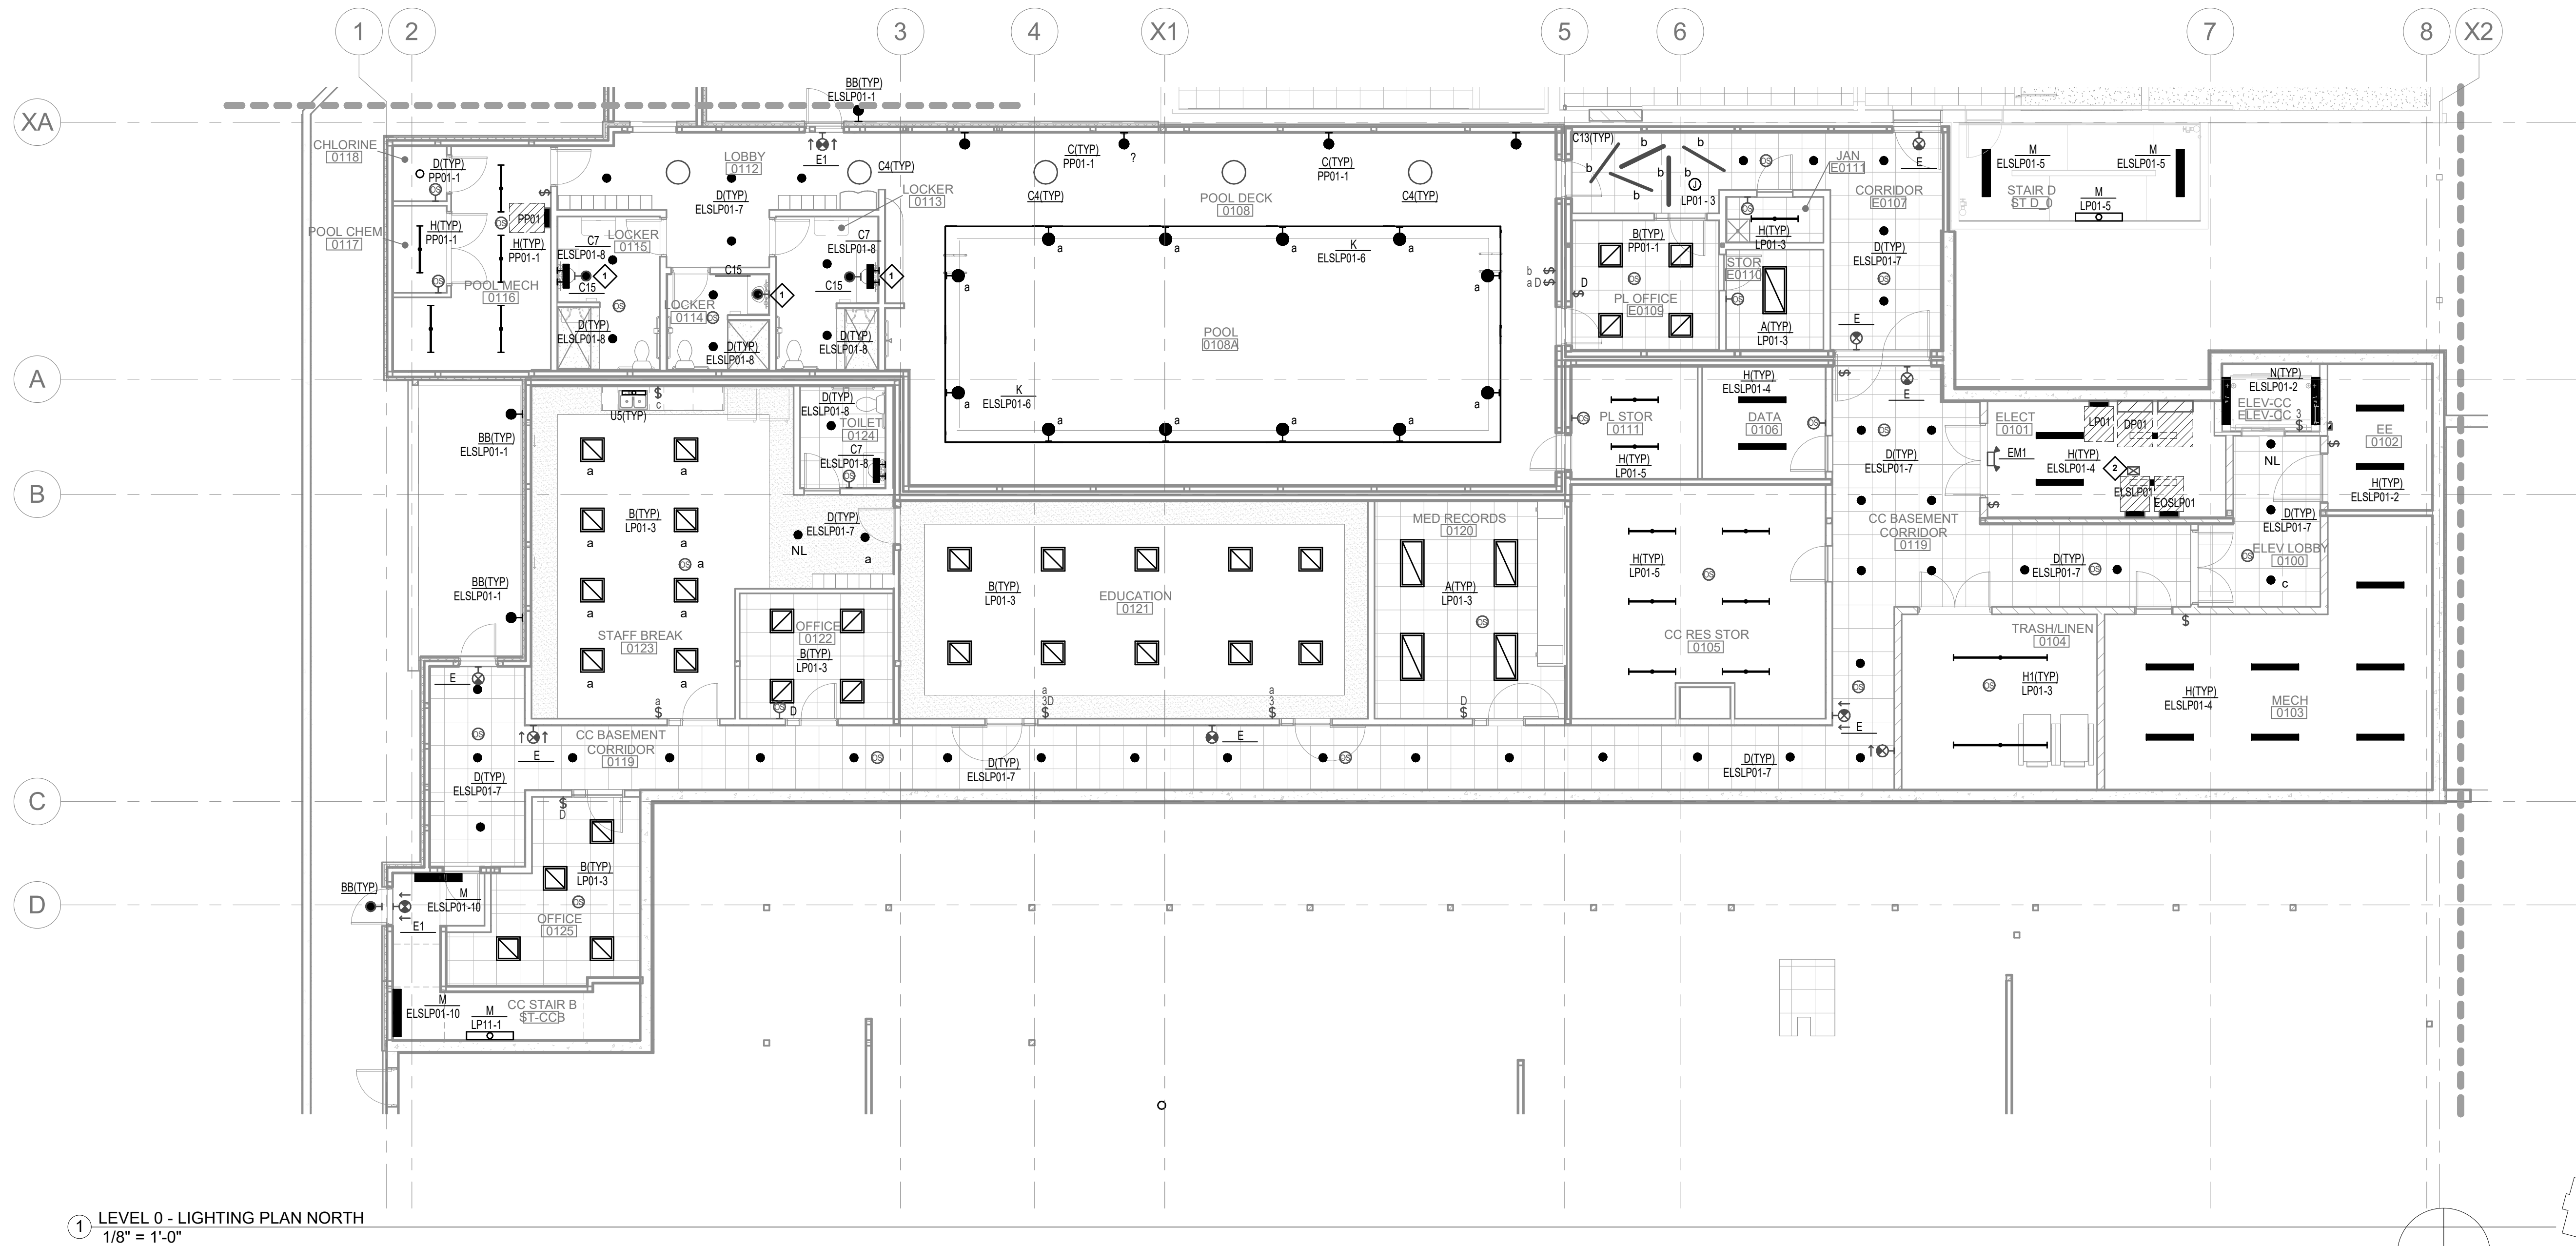

1 LEVEL 0 - LIGHTING PLAN NORTH
1/8" = 1'-0"

GENERAL ELECTRICAL LIGHTING NOTES	
A.	CONTROL CORRIDOR LIGHT FIXTURES VIA LOCAL CONTROL AT NURSE STATION OR AREA'S WITH OCCUPANCY SENSOR UNLESS NOTED OTHERWISE.
B.	CONTROL BUILDING MOUNTED EXTERIOR LIGHT FIXTURES VIA SITE TIME CLOCK, UNLESS NOTED OTHERWISE. ELECTRICAL CONTRACTOR TO COORDINATE COMMON AREA LIGHTING CONTROL LOCATIONS WITH OWNER.
C.	ELECTRICAL CONTRACTOR TO VERIFY LOCATION OF ALL COMMON AREA LIGHTING CONTROL WITH OWNER/ARCHITECT.

SPECIFIC ELECTRICAL LIGHTING NOTES	
1.	PROVIDE FIXTURE C15, LIGHTED MIRROR FIXTURES, CONTROL WITH LOCAL LIGHTING OCCUPANCY SENSOR & CIRCUIT.
2.	PROVIDE PHOTO-CELL FOR CONTROL OF EXTERIOR FIXTURES. PROVIDE 6 POLE LIGHTING CONTACTOR IN ELECTRICAL ROOM.

STEEN
ENGINEERING

763-585-6742
763-585-6757 fax
Email: steen@steeneng.com
5430 Douglas Drive North
Minneapolis, MN 55429

in = site
architects

1000 university ave. w. # suite 130
st. paul, minnesota 55104
612-252-4820




Richard D. Becker
Signature

Richard D. Becker
Typed or Printed Name

Electrical
Discipline

12/02/24
Date

**WESLEY BRADLEY PARK
PHASE 2 - CARE CENTER**
707 39TH AVENUE SE
PUYALLUP, WA 98374

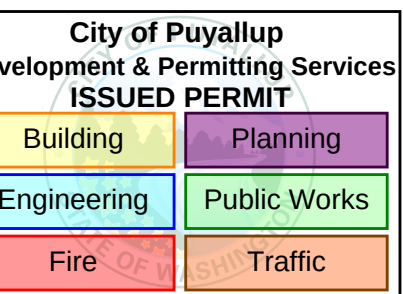

**CARE CENTER
PERMIT SET**
December 2, 2024

REVISIONS

No.	Description	Date
-----	-------------	------

ISA202201
PROJECT NUMBER


DJL JLA
DRAWN BY CHECKED BY

WESLEY BRADLEY PARK
PHASE 2 - CARE CENTER

LEVEL 0 LIGHTING PLAN
NORTH

E1.0A

WESLEY BRADLEY PARK
PHASE 2 - CARE CENTER
707 39TH AVENUE SE
PUYALLUP, WA 98374

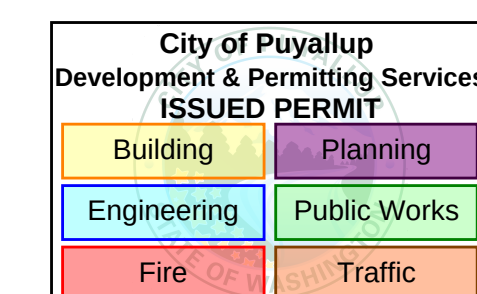

CARE CENTER
PERMIT SET
December 2, 2024

REVISIONS

No.	Description	Date
-----	-------------	------

ISA202201
PROJECT NUMBER

DJL	JLA
DRAWN BY	CHECKED BY



WESLEY BRADLEY PARK
PHASE 2 - CARE CENTER

LEVEL 1 LIGHTING PLAN
NORTH

E1.1A



① LEVEL 1 - LIGHTING PLAN NORTH
1/8" = 1'-0"

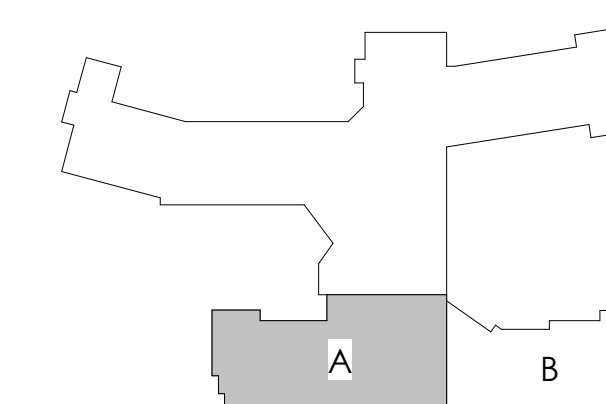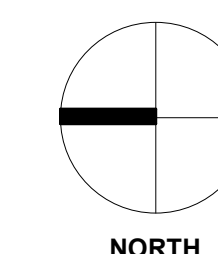

REFER TO SHEET E1.0A FOR NOTES

City of Puyallup Development & Permitting Services ISSUED PERMIT	
Building	Planning
Engineering	Public Works
Fire	Traffic

CARE CENTER
PERMIT SET
December 2, 2024

REVISIONS

No.	Description	Date
-----	-------------	------



ISA202201
PROJECT NUMBER

DJL	JLA
DRAWN BY	CHECKED BY


WESLEY BRADLEY PARK
PHASE 2 - CARE CENTER

LEVEL 1 LIGHTING PLAN
SOUTH


E1.1 B

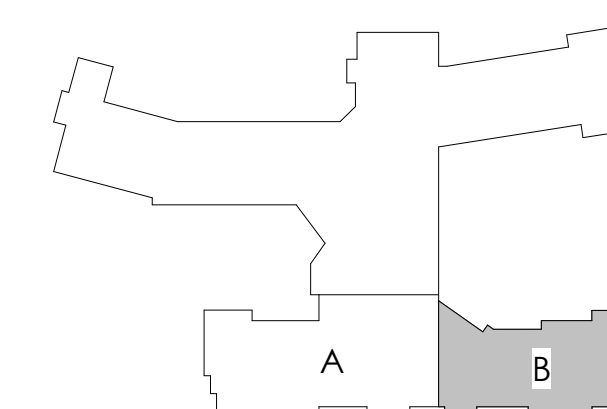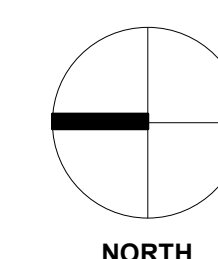

REFER TO SHEET E1.0A FOR NOTES

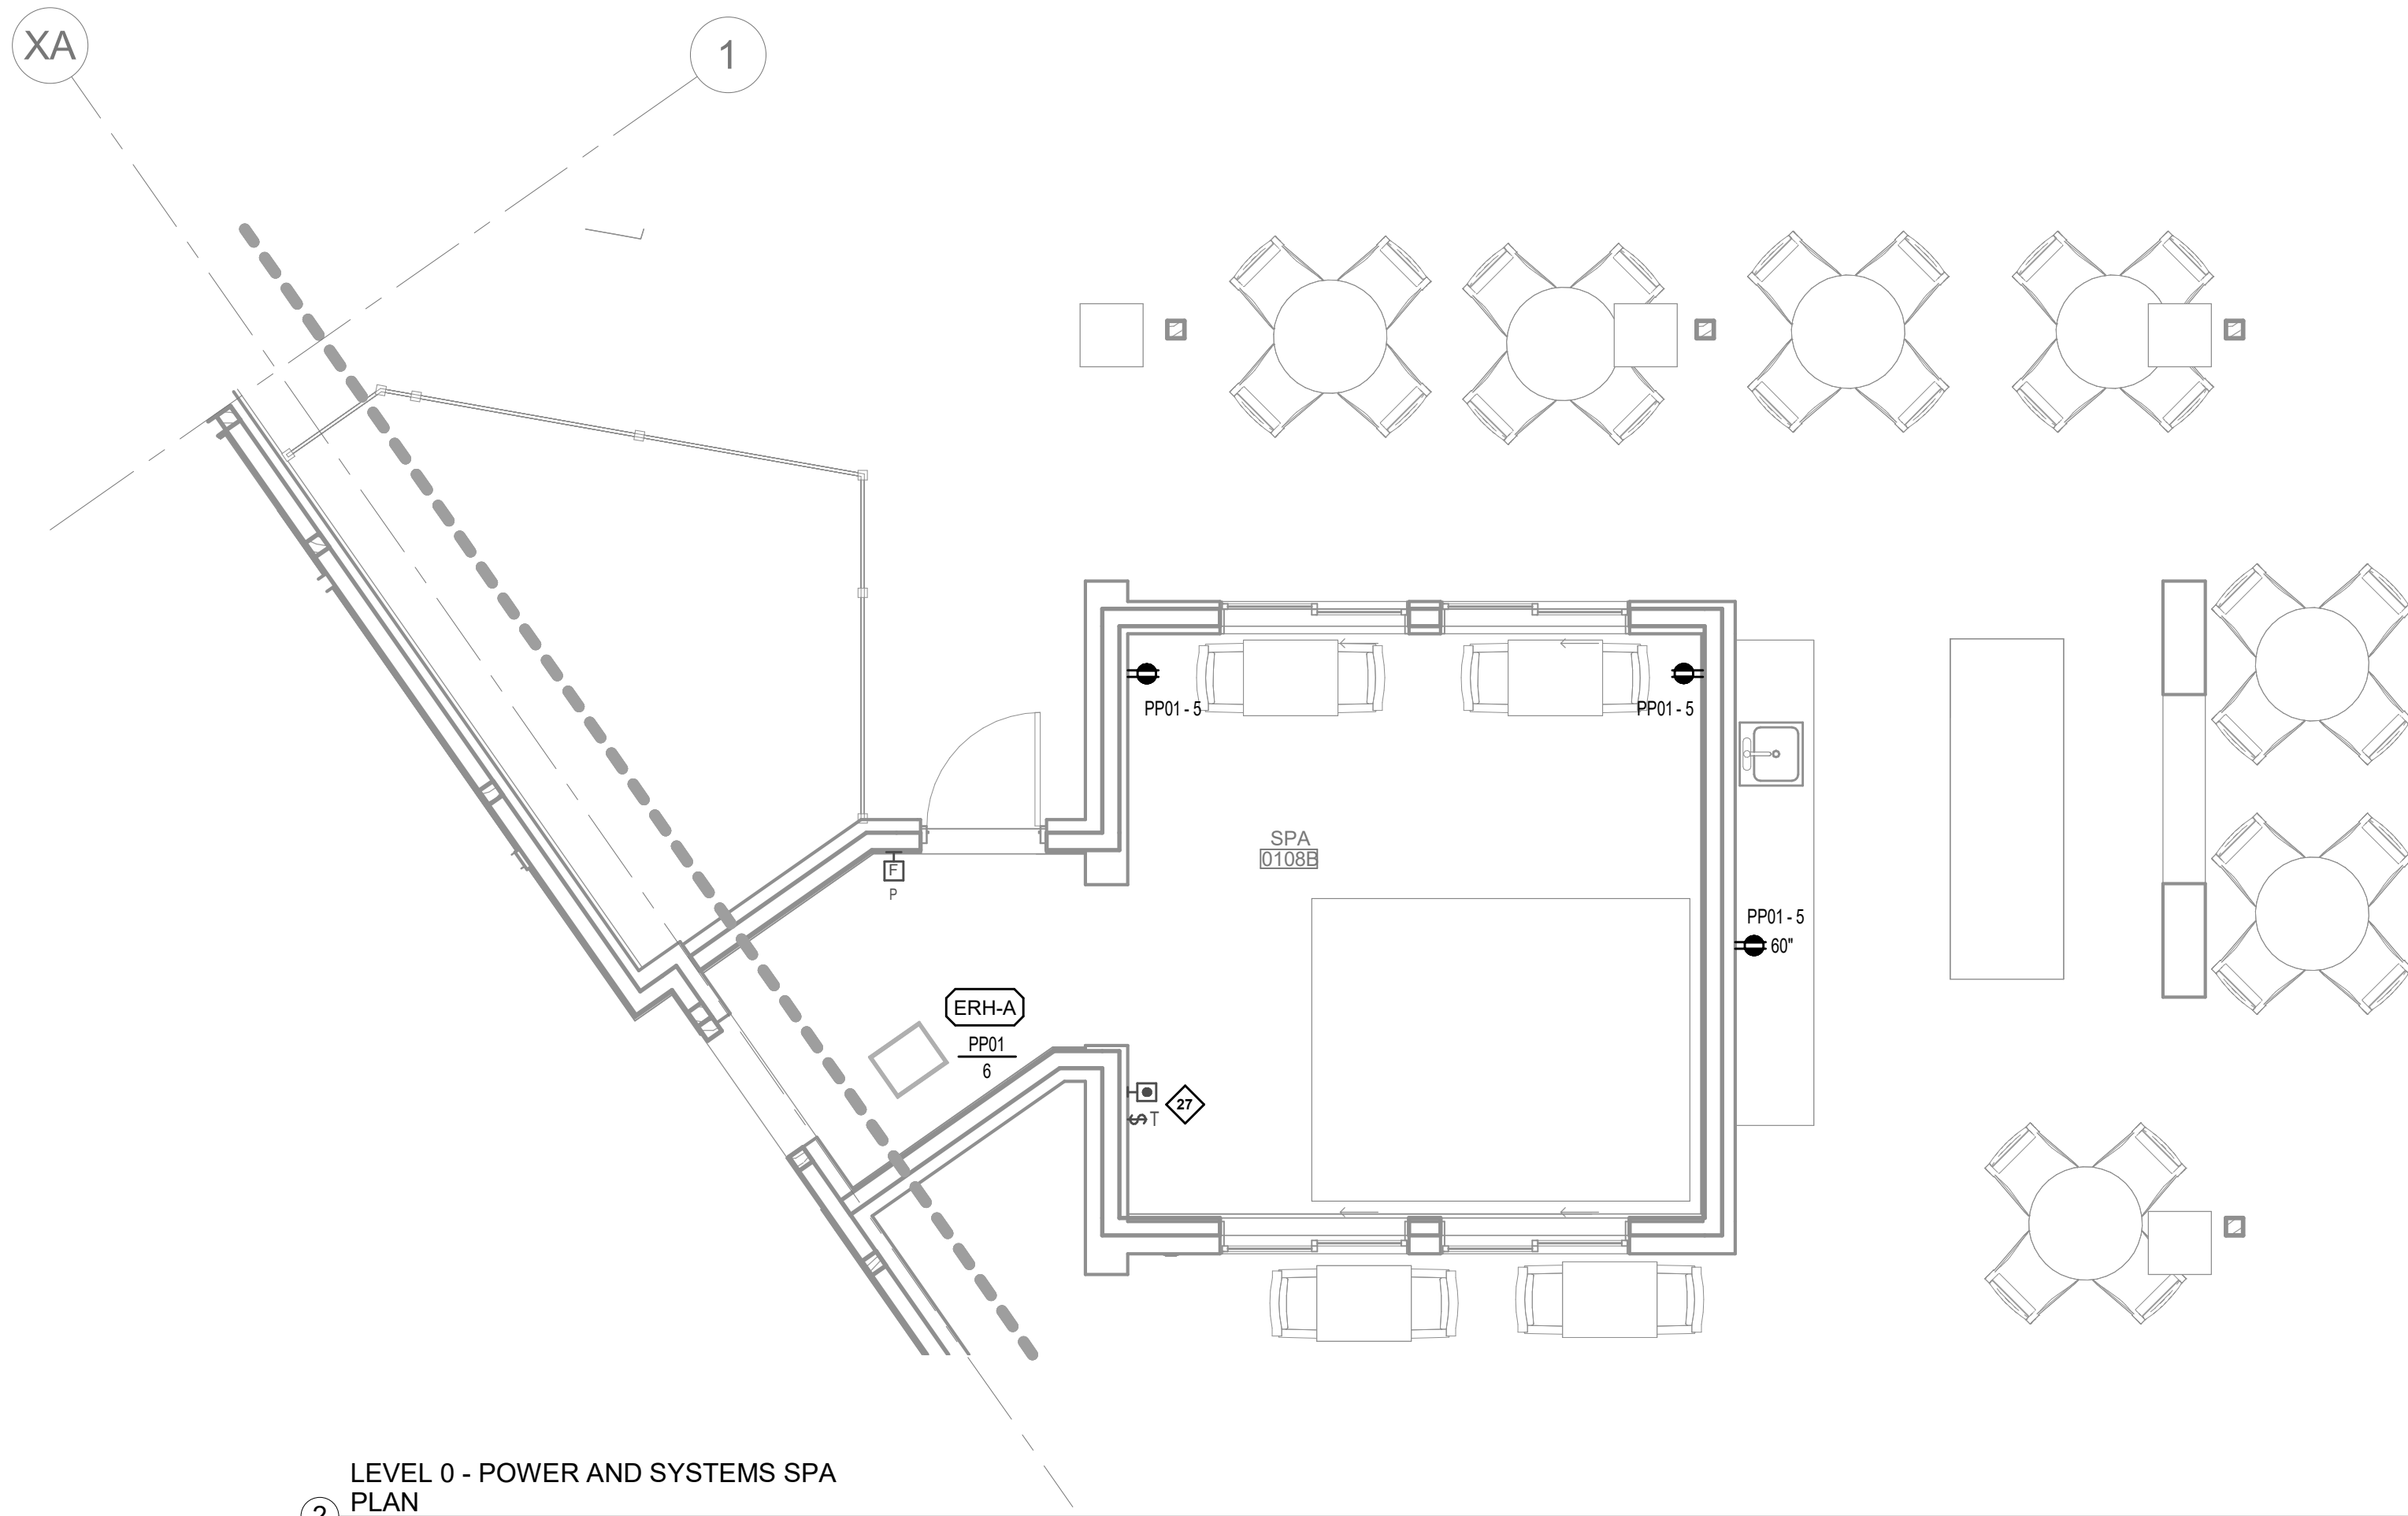

LEVEL 0 - POWER AND SYSTEMS SPA
PLAN
1/4" = 1'-0"

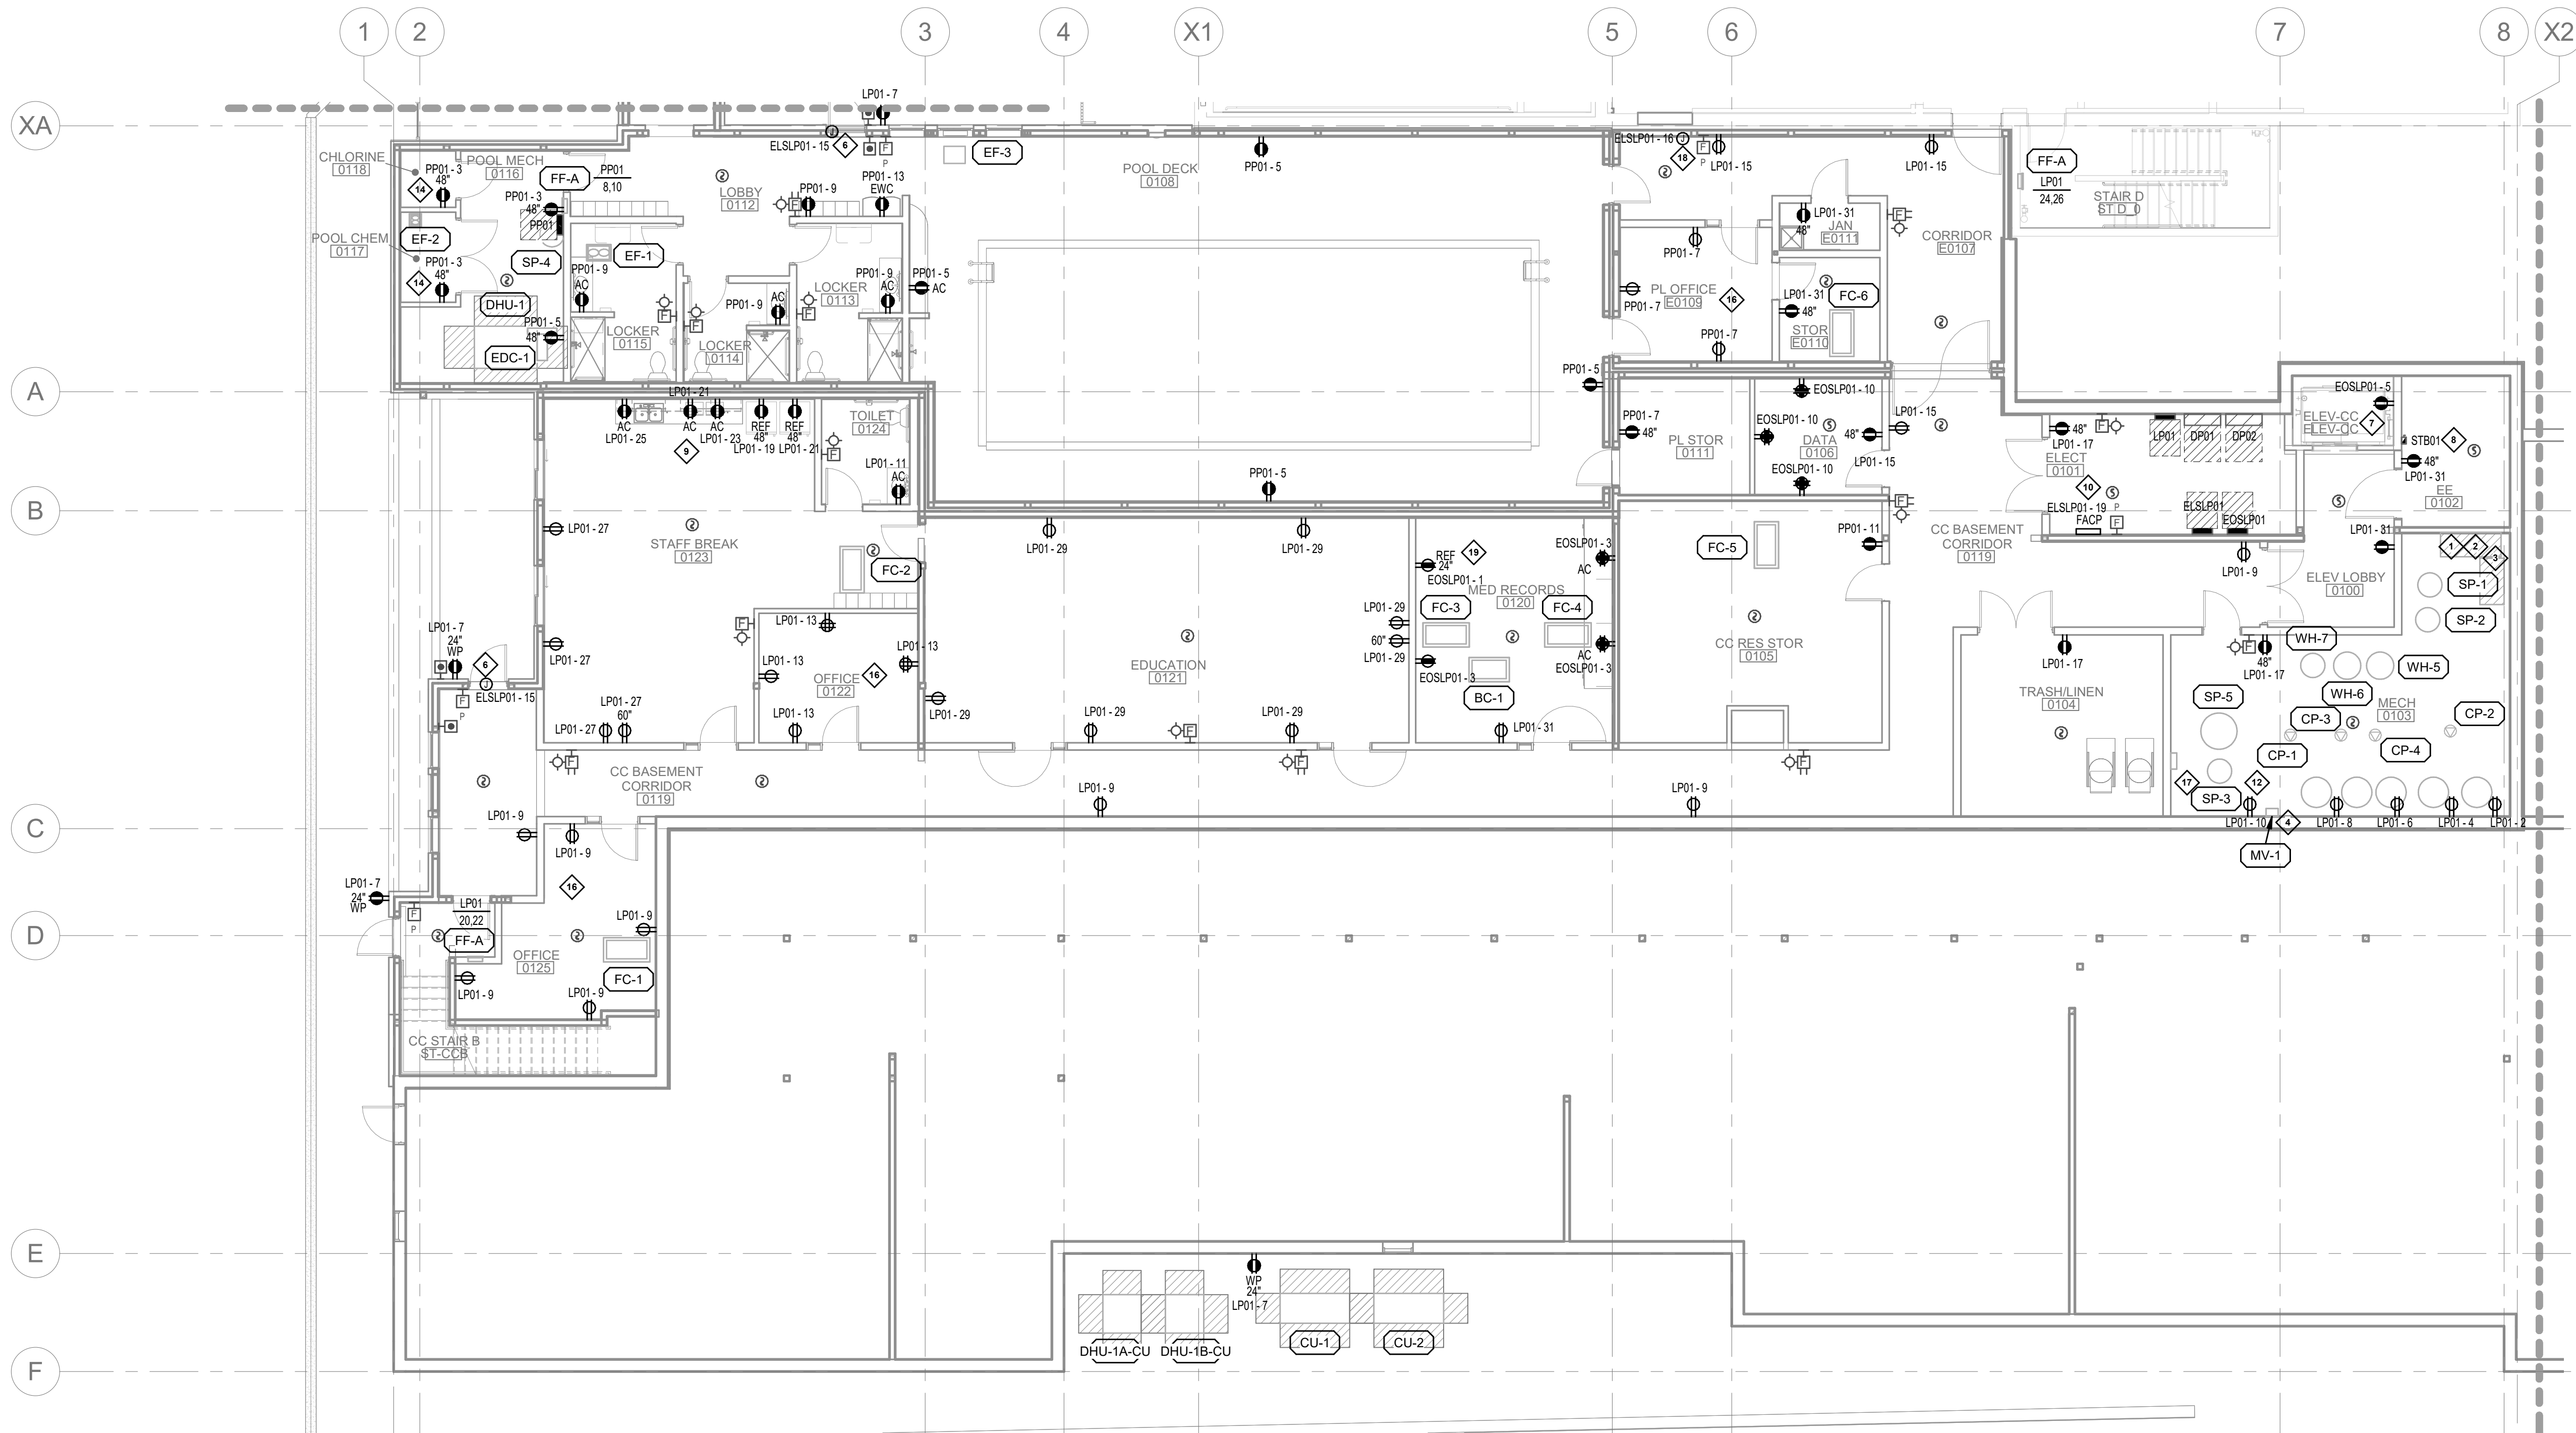

LEVEL 0 - POWER AND SYSTEMS FLOOR
PLAN NORTH
1/8" = 1'-0"

- GENERAL POWER & SYSTEMS NOTES**
- VERIFY LOCATION OF ALL LIGHT FIXTURES & DEVICES WITH ARCHITECT PRIOR TO ROUGH-IN.
 - ELECTRICAL CONTRACTOR TO PROVIDE A LOCAL CODE COMPLIANT FIRE ALARM SYSTEM. TIE SKILLED NURSING SYSTEM IN TO THE LODGE FIRE ALARM SYSTEM. VERIFY MANUFACTURER. DEVICES INDICATED INDICATE A FIRE ALARM SYSTEM. NOT ALL DEVICES SHOWN. PROVIDE DEVICES REQUIRED.
 - PER SPECIFICATIONS, CONTRACTOR SHALL PROVIDE ACOUSTICALLY RATED, FLANGED, AIRTIGHT BOXES IN ALL CORRIDOR WALLS & TOP FLOOR CEILINGS.
 - AT ALL THROUGH PENETRATIONS AT FIRE-RESISTANCE RATING. PROVIDE APPROVED PENETRATION FIRESTOP SYSTEM INSTALLED & TESTED IN ACCORDANCE WITH ASTM E 814 OR UL 1479. INSTALLATION SHALL HAVE AN F & T RATING OF NOT LESS THAN THE ASSEMBLY BEING PROTECTED.
 - AT ALL MEMBRANE PENETRATIONS, ELECTRICAL BOX INSTALLATION SHALL COMPLY WITH IBC 713.3.2.
 - REFER TO UNIT PLANS FOR TYPICAL RESIDENT CONFIGURATIONS. CONTRACTOR SHALL COMPLETE ALL UNITS BASED ON TYPICAL UNITS.
 - POOL GROUNDING BY THE ELECTRICAL CONTRACTOR. COORDINATE WITH POOL CONTRACTOR & AHJ.
 - LOW VOLTAGE SYSTEMS BY OTHERS. COORDINATE ANY & ALL POWER CONNECTIONS WITH LOW VOLTAGE. COORDINATE POWER & SYSTEM DEVICE HEIGHT TO BE THE SAME.
 - PROVIDE POWER FOR ALL CARD READERS. COORDINATE WITH LOW VOLTAGE SUPPLIER EXACT LOCATIONS & REQUIREMENTS OF POWER SUPPLIES.
 - ACCESS CONTROL SHALL BE COMPATIBLE WITH EXISTING SYSTEM. COORDINATE WITH LOW VOLTAGE & OWNER.

- SPECIFIC ELECTRICAL NOTES**
- DEDICATED AREA FOR INCOMING WATER SERVICE SYSTEM. REFER TO MECHANICAL PLANS & SPECIFICATIONS FOR FURTHER INFORMATION.
 - DEDICATED AREA FOR INCOMING SPRINKLER SERVICE SYSTEM. REFER TO MECHANICAL PLANS & SPECIFICATIONS FOR FURTHER INFORMATION.
 - DEDICATED FOR SPRINKLER SYSTEM AIR COMPRESSOR. VERIFY ELECTRICAL REQUIREMENTS WITH SPRINKLER SYSTEM INSTALLER PRIOR TO ROUGH-IN. COORDINATE COMPRESSOR CIRCUITRY WITH FIRE SPRINKLER CONTRACTOR TO THE LIFE SAFETY PANELBOARD.
 - PROVIDE POWER TO MIXING VALVE. COORDINATE EXACT REQUIREMENTS WITH PLUMBING CONTRACTOR TO PANEL LP01.
 - PROVIDE GROUNDING TO GAS METER.
 - PROVIDE POWER & CONTROL CONNECTIONS BETWEEN PUSHBUTTONS, KEYED SWITCH & ACCESS CONTROL SYSTEM AS REQUIRED FOR PROPER OPERATION.
 - PROVIDE DEDICATED CIRCUITS FOR ELEVATOR CAB POWER, LIGHTS & RECEPTACLES. COORDINATE EXACT FIRE ALARM PROVISIONS WITH AHJ & THE FIRE ALARM PROVIDER.
 - COORDINATE LOCATION OF ELEVATOR CONNECTION WITH ELEVATOR INSTALLER PRIOR TO ROUGH-IN. PROVIDE POWER FROM EOSLP01.
 - DEDICATED FOR DISHWASHER. MOUNT BELOW SINK TO ALLOW FOR PLUG CONNECTION. PROVIDE CONNECTION TO KP11 AS REQUIRED.
 - FIRE ALARM CONTROL PANEL.
 - PROVIDE FLOOR BOX WITH COVER & DEVICES SHOWN. WIREMOLD #WMFB SERIES OR EQUAL (Floor Lamps). COORDINATE LOCATION WITH ARCHITECT, INTERIORS & FURNITURE PROVIDER PRIOR TO ROUGH-IN.
 - DEDICATED FOR IRRIGATION SYSTEM. VERIFY ELECTRICAL REQUIREMENTS & LOCATION WITH PROVIDER PRIOR TO ROUGH-IN.
 - PROVIDE MECHANICALLY HELD POWER CONTACTOR WITH NEMA-1 ENCLOSURE & KEYED SWITCH WITH PILOT LIGHT FOR CONTROL OF RANGE POWER. CONNECT SO THAT PILOT LIGHT IS ON WHEN RANGE IS POWERED.
 - CORROSIVE ENVIRONMENT PER 2017 NEC 880.12 AND 880.14. ALL ELECTRICAL CONDUITS, DEVICES, LIGHT FIXTURES, J-BOXES & WIRING METHODS SHALL BE LISTED & IDENTIFIED FOR USE IN THIS AREA.
 - NOT USED.
 - CONNECT HALF OF SPLIT WIRED RECEPTACLES TO OCCUPANCY SENSOR WITHIN ROOM PER ASHRAE 90.1.
 - PROVIDE CONNECTION TO SUMP PUMP CONTROLLER FROM THE NEAREST 120V CIRCUIT.
 - PROVIDE EMERGENCY POWER & FIRE ALARM CONNECTION TO FIRE DOORS ON BOTH SIDES.
 - DEDICATED FOR UNDER CABINET REFRIGERATOR. VERIFY LOCATION & COORDINATE INSTALLATION WITH CABINET PROVIDER PRIOR TO ROUGH-IN.
 - PROVIDE GENERATOR ANNUNCIATOR PANEL. TIE INTO EXISTING LODGE GENERATOR AS REQUIRED.
 - PROVIDE FIRE ALARM ANNUNCIATOR CONNECTION INTO THE LODGE FIRE ALARM PANEL.
 - PROVIDE DEDICATED CIRCUIT PER UNIT FOR GENERAL LIGHTING & RECEPTACLE POWER.
 - PROVIDE EMERGENCY CIRCUIT FOR RECEPTACLES IN UNITS. SHARE CIRCUIT FOR THREE (3) ROOMS.
 - PROVIDE HVAC CIRCUIT FOR UNIT, SHARE CIRCUIT, SEE FLOOR PLANS.
 - PROVIDE GFI CIRCUIT FOR SPA TUB. COORDINATE EXACT CONNECTION WITH SUPPLIER.
 - PROVIDE WIREMOLD RFB4 FLOOR BOX FOR POWER & DATA. VERIFY EXACT LOCATION & SYSTEM REQUIREMENTS WITH LOW VOLTAGE. PROVIDE 2" CONDUIT FOR LOW VOLTAGE FROM FLOOR BOX TO WALL MOUNTED TV. COORDINATE.
 - PROVIDE CONNECTION TO SPA TIMER SWITCH & EMERGENCY SHUT-OFF EPO SWITCH, COORDINATE WITH POOL SUPPLIER & AHJ.
 - PROVIDE CONNECTION TO RANGE HOOD. COORDINATE WITH KITCHEN SUPPLIER EXACT REQUIREMENTS.
 - PROVIDE CEILING RECEPTACLE FOR EMERGENCY CALL REPEATERS. COORDINATE EXACT REQUIREMENTS WITH OWNERS SUPPLIER.
 - PROVIDE CORRIDOR RECEPTACLE @ 56" FOR TOUCH PANELS. COORDINATE EXACT LOCATION WITH OWNER. SEE DETAIL 6/A103.

STEEN
ENGINEERING

763-585-6742
763-585-6757 fax
Email: steen@steeneng.com
5430 Douglas Drive North
Minneapolis, MN 55429

in = site
architects

1000 university ave. w. # suite 130
st. paul, minnesota 55104
612-252-4820




Richard D. Becker
Signature

Richard D. Becker
Typed or Printed Name

Electrical Discipline 12/02/24 Date

**WESLEY BRADLEY PARK
PHASE 2 - CARE CENTER**
707 39TH AVENUE SE
PUYALLUP, WA 98374

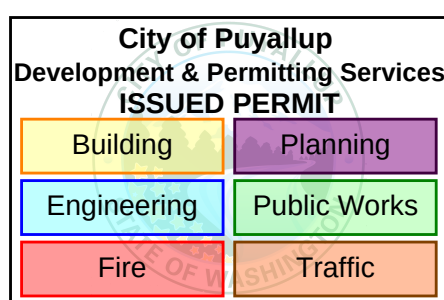

**CARE CENTER
PERMIT SET**
December 2, 2024

REVISIONS

No.	Description	Date
-----	-------------	------

ISA202201
PROJECT NUMBER

DJL	JLA
DRAWN BY	CHECKED BY

WESLEY BRADLEY PARK
PHASE 2 - CARE CENTER

LEVEL 0 POWER &
SYSTEMS PLAN NORTH

E2.0A




Richard D. Becker
Signature

Richard D. Becker
Typed or Printed Name

Electrical
Discipline 12/02/24
Date

WESLEY BRADLEY PARK
PHASE 2 - CARE CENTER
707 39TH AVENUE SE
PUYALLUP, WA 98374

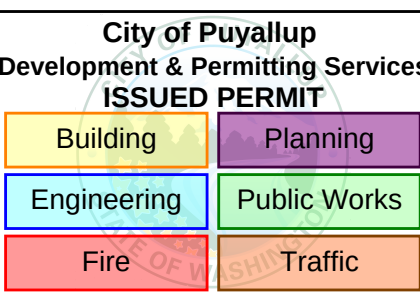

CARE CENTER
PERMIT SET
December 2, 2024

REVISIONS

No.	Description	Date
-----	-------------	------

ISA202201

PROJECT NUMBER

DJL

DRAWN BY


JLA

CHECKED BY



WESLEY BRADLEY PARK
PHASE 2 - CARE CENTER

LEVEL 1 POWER &
SYSTEMS PLAN NORTH

E2.1A

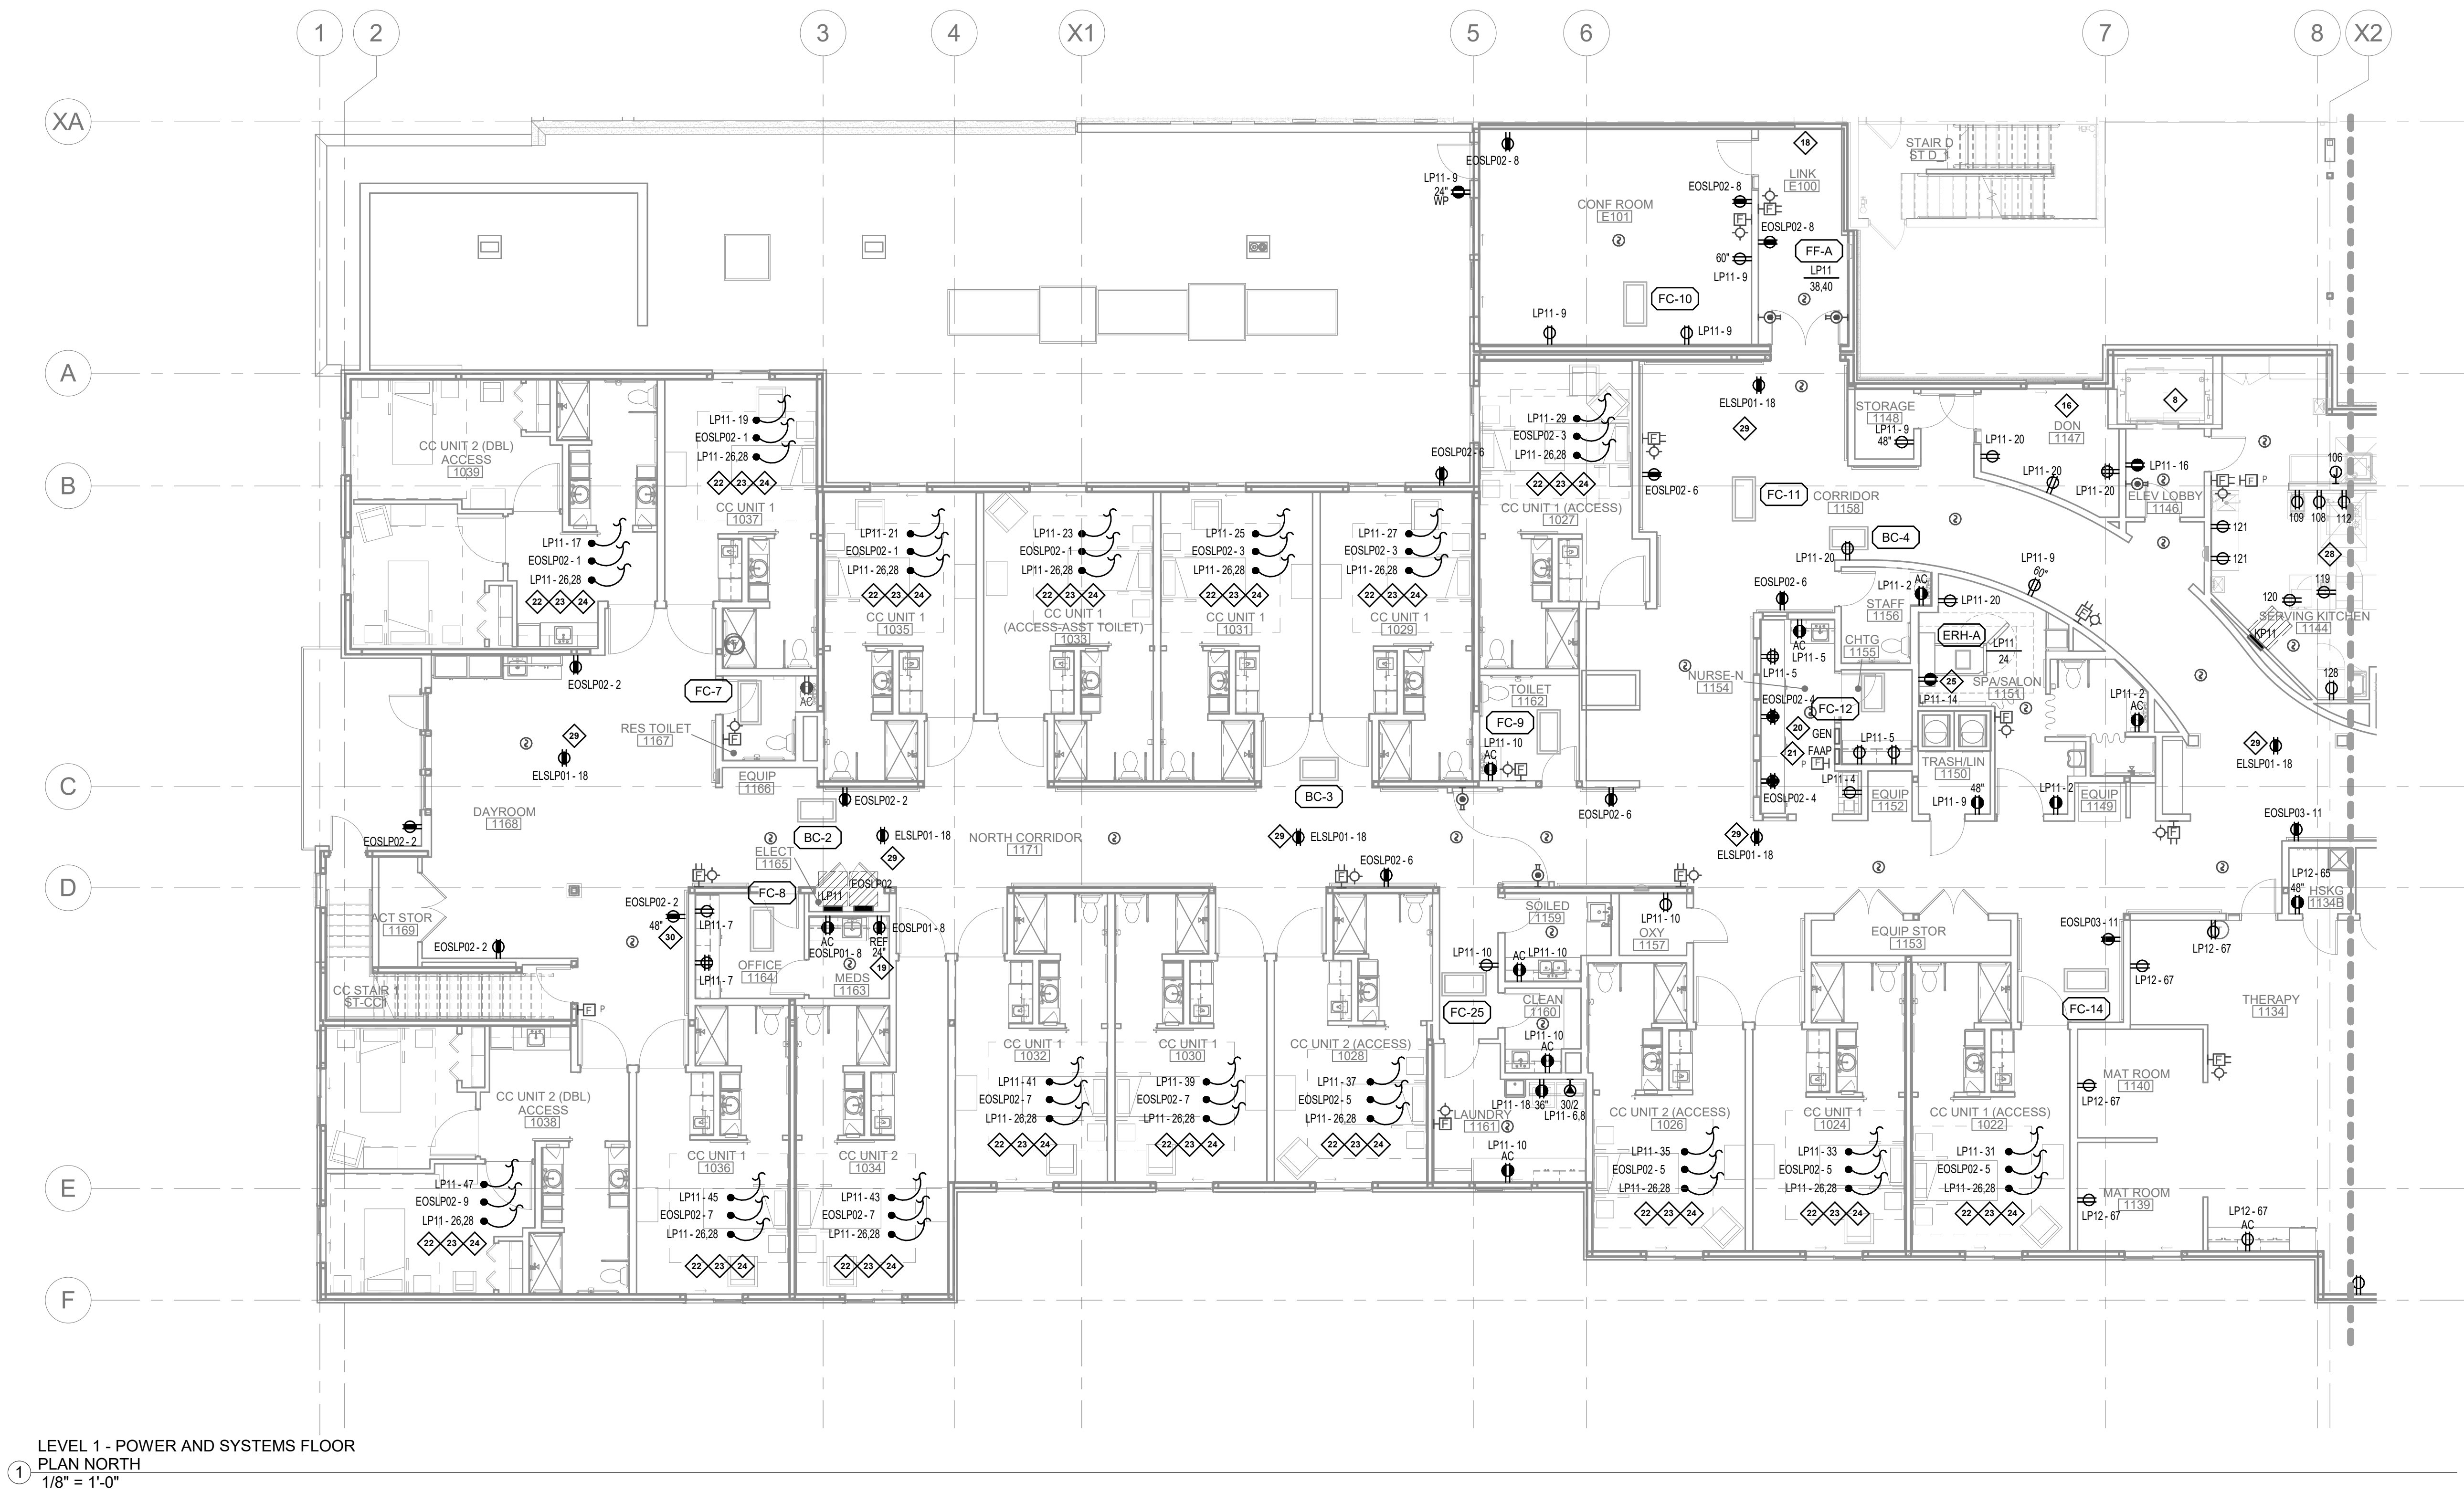

LEVEL 1 - POWER AND SYSTEMS FLOOR
PLAN NORTH
1/8" = 1'-0"

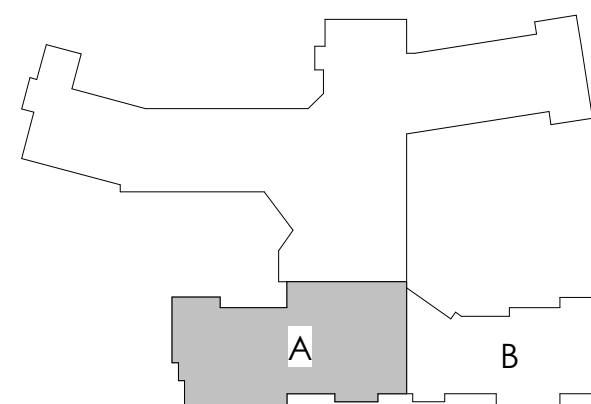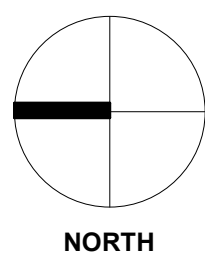

REFER TO SHEET E2.0A FOR NOTES




Richard D. Becker
Signature

Richard D. Becker
Typed or Printed Name

Electrical 12/02/24
Discipline Date

WESLEY BRADLEY PARK
PHASE 2 - CARE CENTER
707 39TH AVENUE SE
PUYALLUP, WA 98374

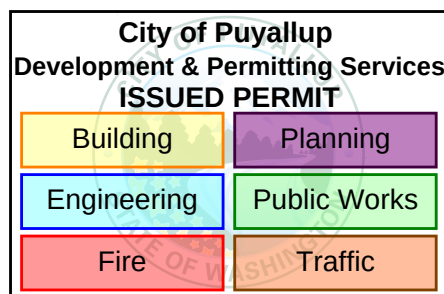

CARE CENTER
PERMIT SET
December 2, 2024

REVISIONS

No.	Description	Date
-----	-------------	------

ISA202201

PROJECT NUMBER


DJL JLA

DRAWN BY CHECKED BY

WESLEY BRADLEY PARK
PHASE 2 - CARE CENTER

LEVEL 1 POWER &
SYSTEMS PLAN SOUTH

E2.1B

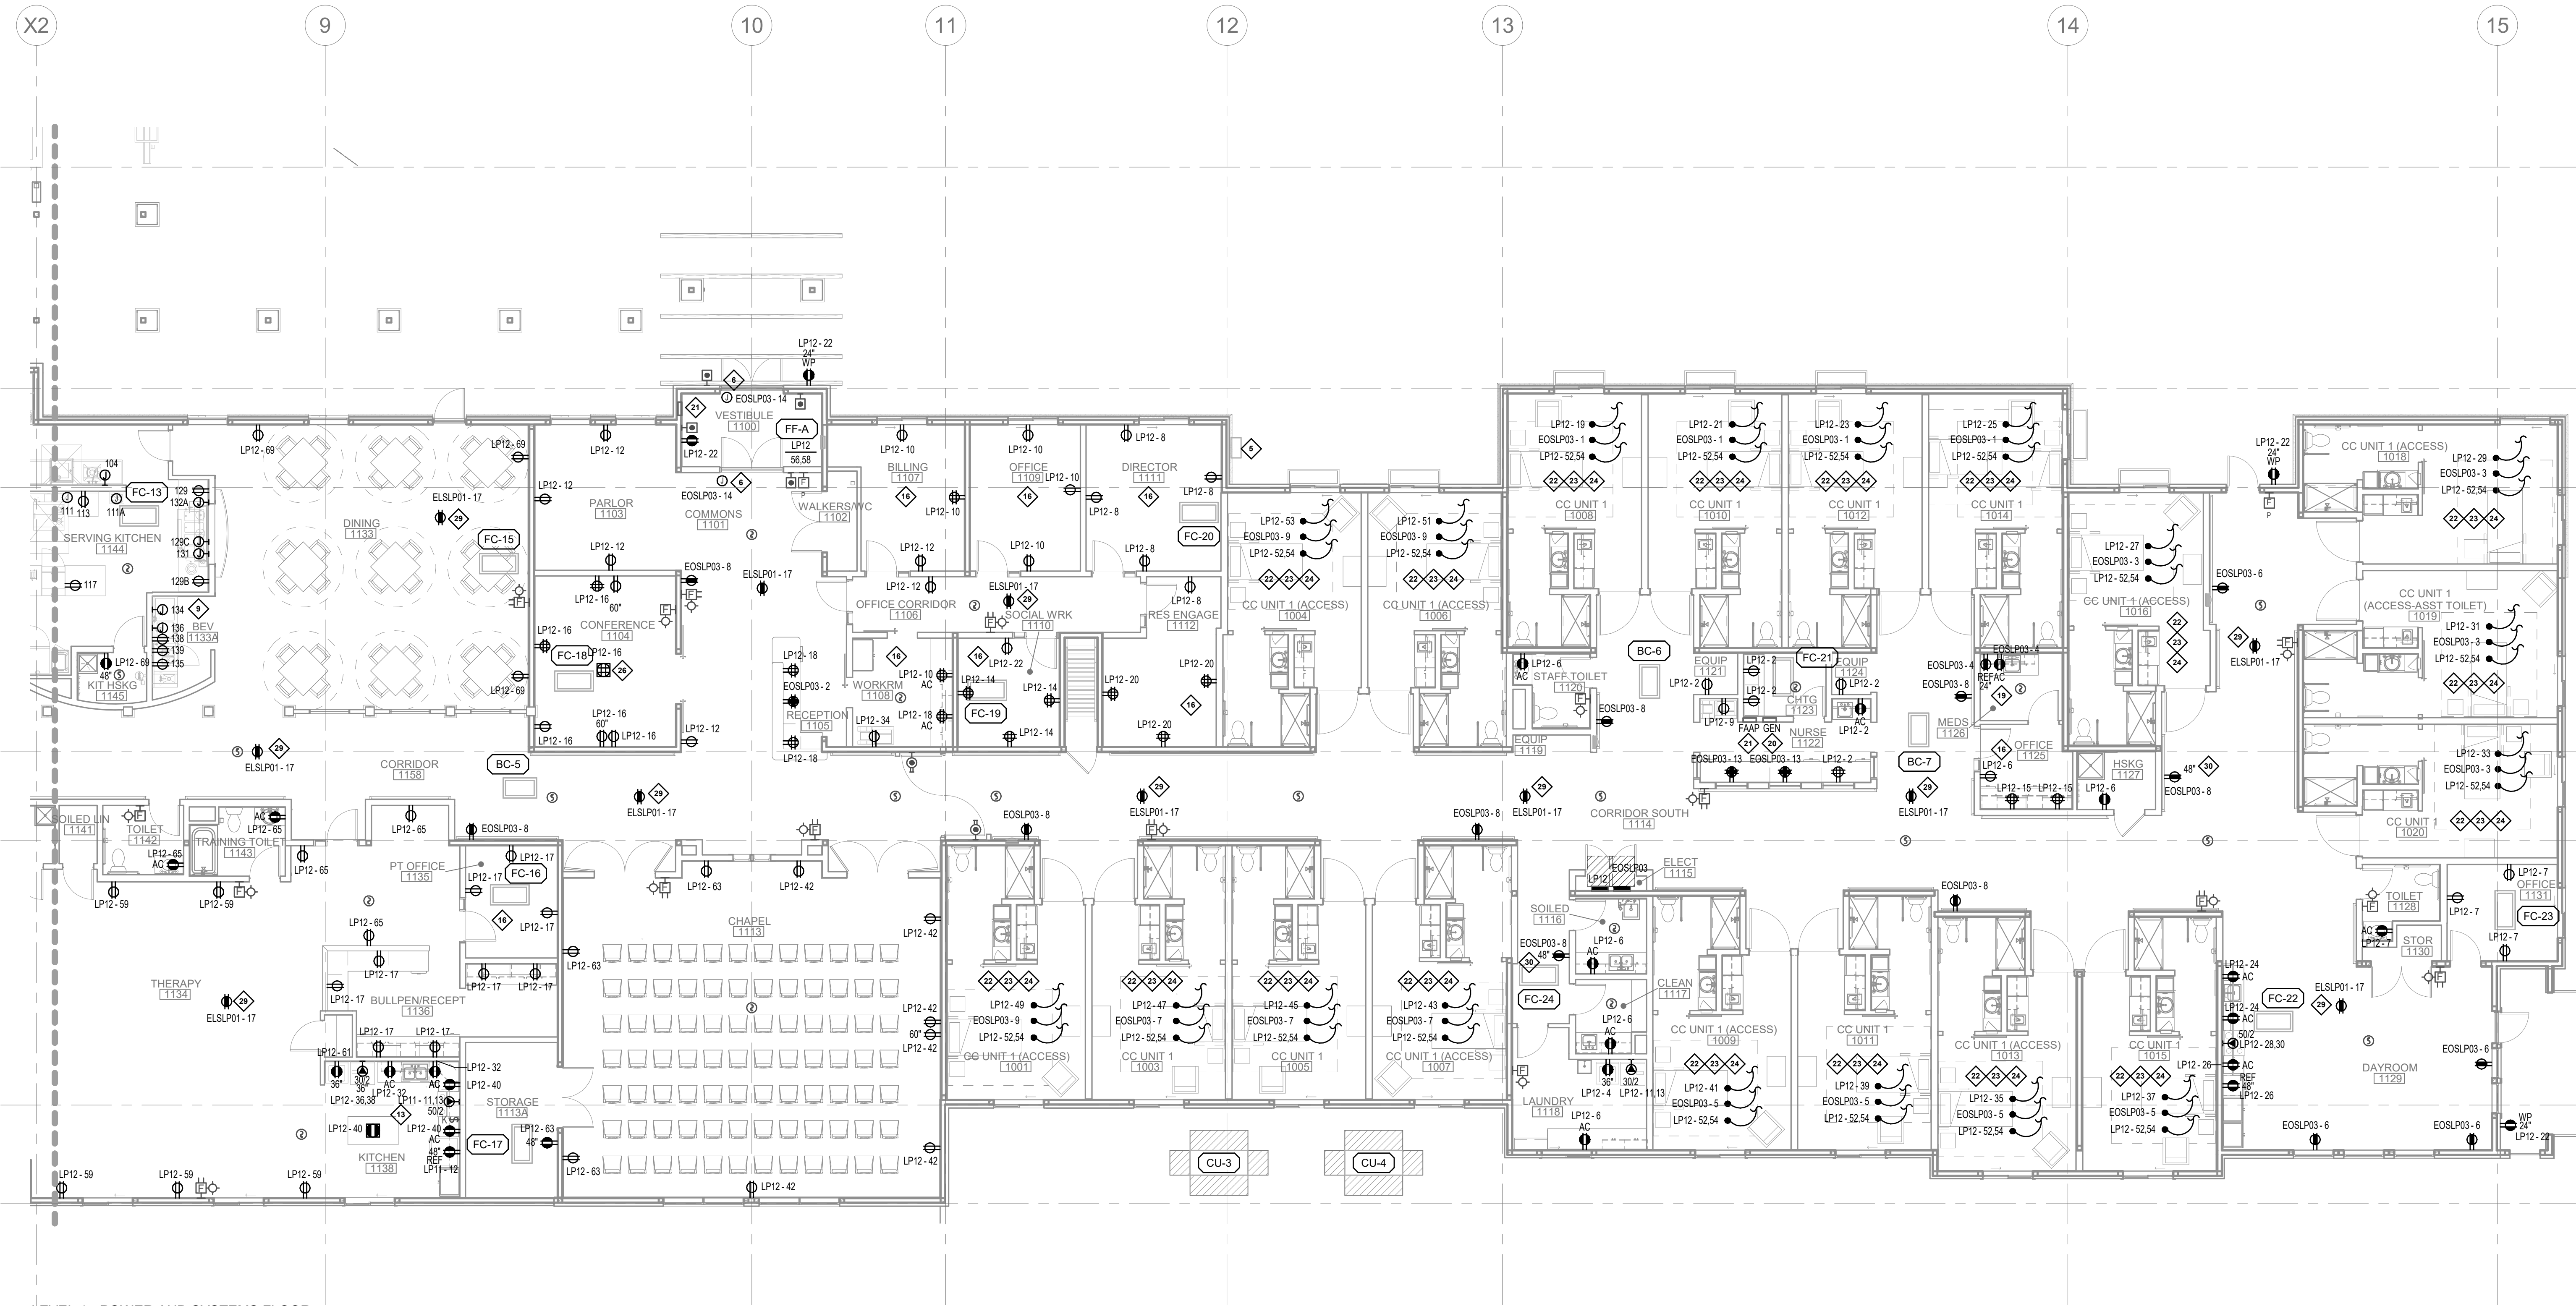




Richard D. Becker
Signature

Richard D. Becker
Typed or Printed Name

Electrical Discipline 12/02/24 Date

WESLEY BRADLEY PARK
PHASE 2 - CARE CENTER
707 39TH AVENUE SE
PUYALLUP, WA 98374

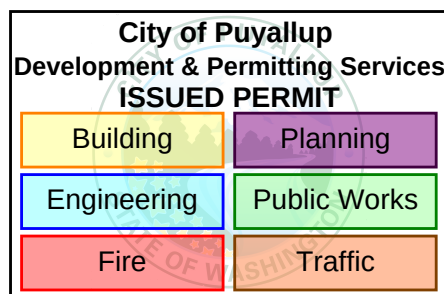

CARE CENTER
PERMIT SET
December 2, 2024

REVISIONS

No.	Description	Date
-----	-------------	------

ISA202201
PROJECT NUMBER

DJL JLA
DRAWN BY CHECKED BY



WESLEY BRADLEY PARK
PHASE 2 - CARE CENTER

ELECTRICAL ROOF PLAN
NORTH

E2.2A



1 ELECTRICAL ROOF PLAN NORTH
1/8" = 1'-0"

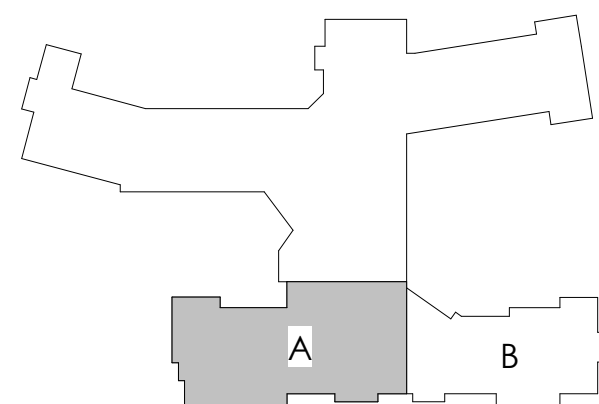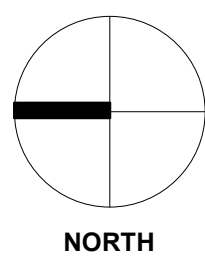

REFER TO SHEET E2.0A FOR NOTES




Richard D. Becker
Signature

Richard D. Becker
Typed or Printed Name

Electrical
Discipline

12/02/24
Date

WESLEY BRADLEY PARK
PHASE 2 - CARE CENTER
707 39TH AVENUE SE
PUYALLUP, WA 98374

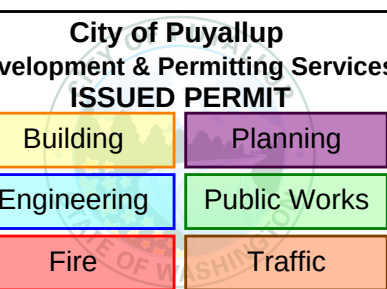

CARE CENTER
PERMIT SET
December 2, 2024

REVISIONS

No.	Description	Date
-----	-------------	------


ISA202201
PROJECT NUMBER

DJL JLA
DRAWN BY CHECKED BY



WESLEY BRADLEY PARK
PHASE 2 - CARE CENTER

ELECTRICAL ROOF PLAN
SOUTH

E2.2B

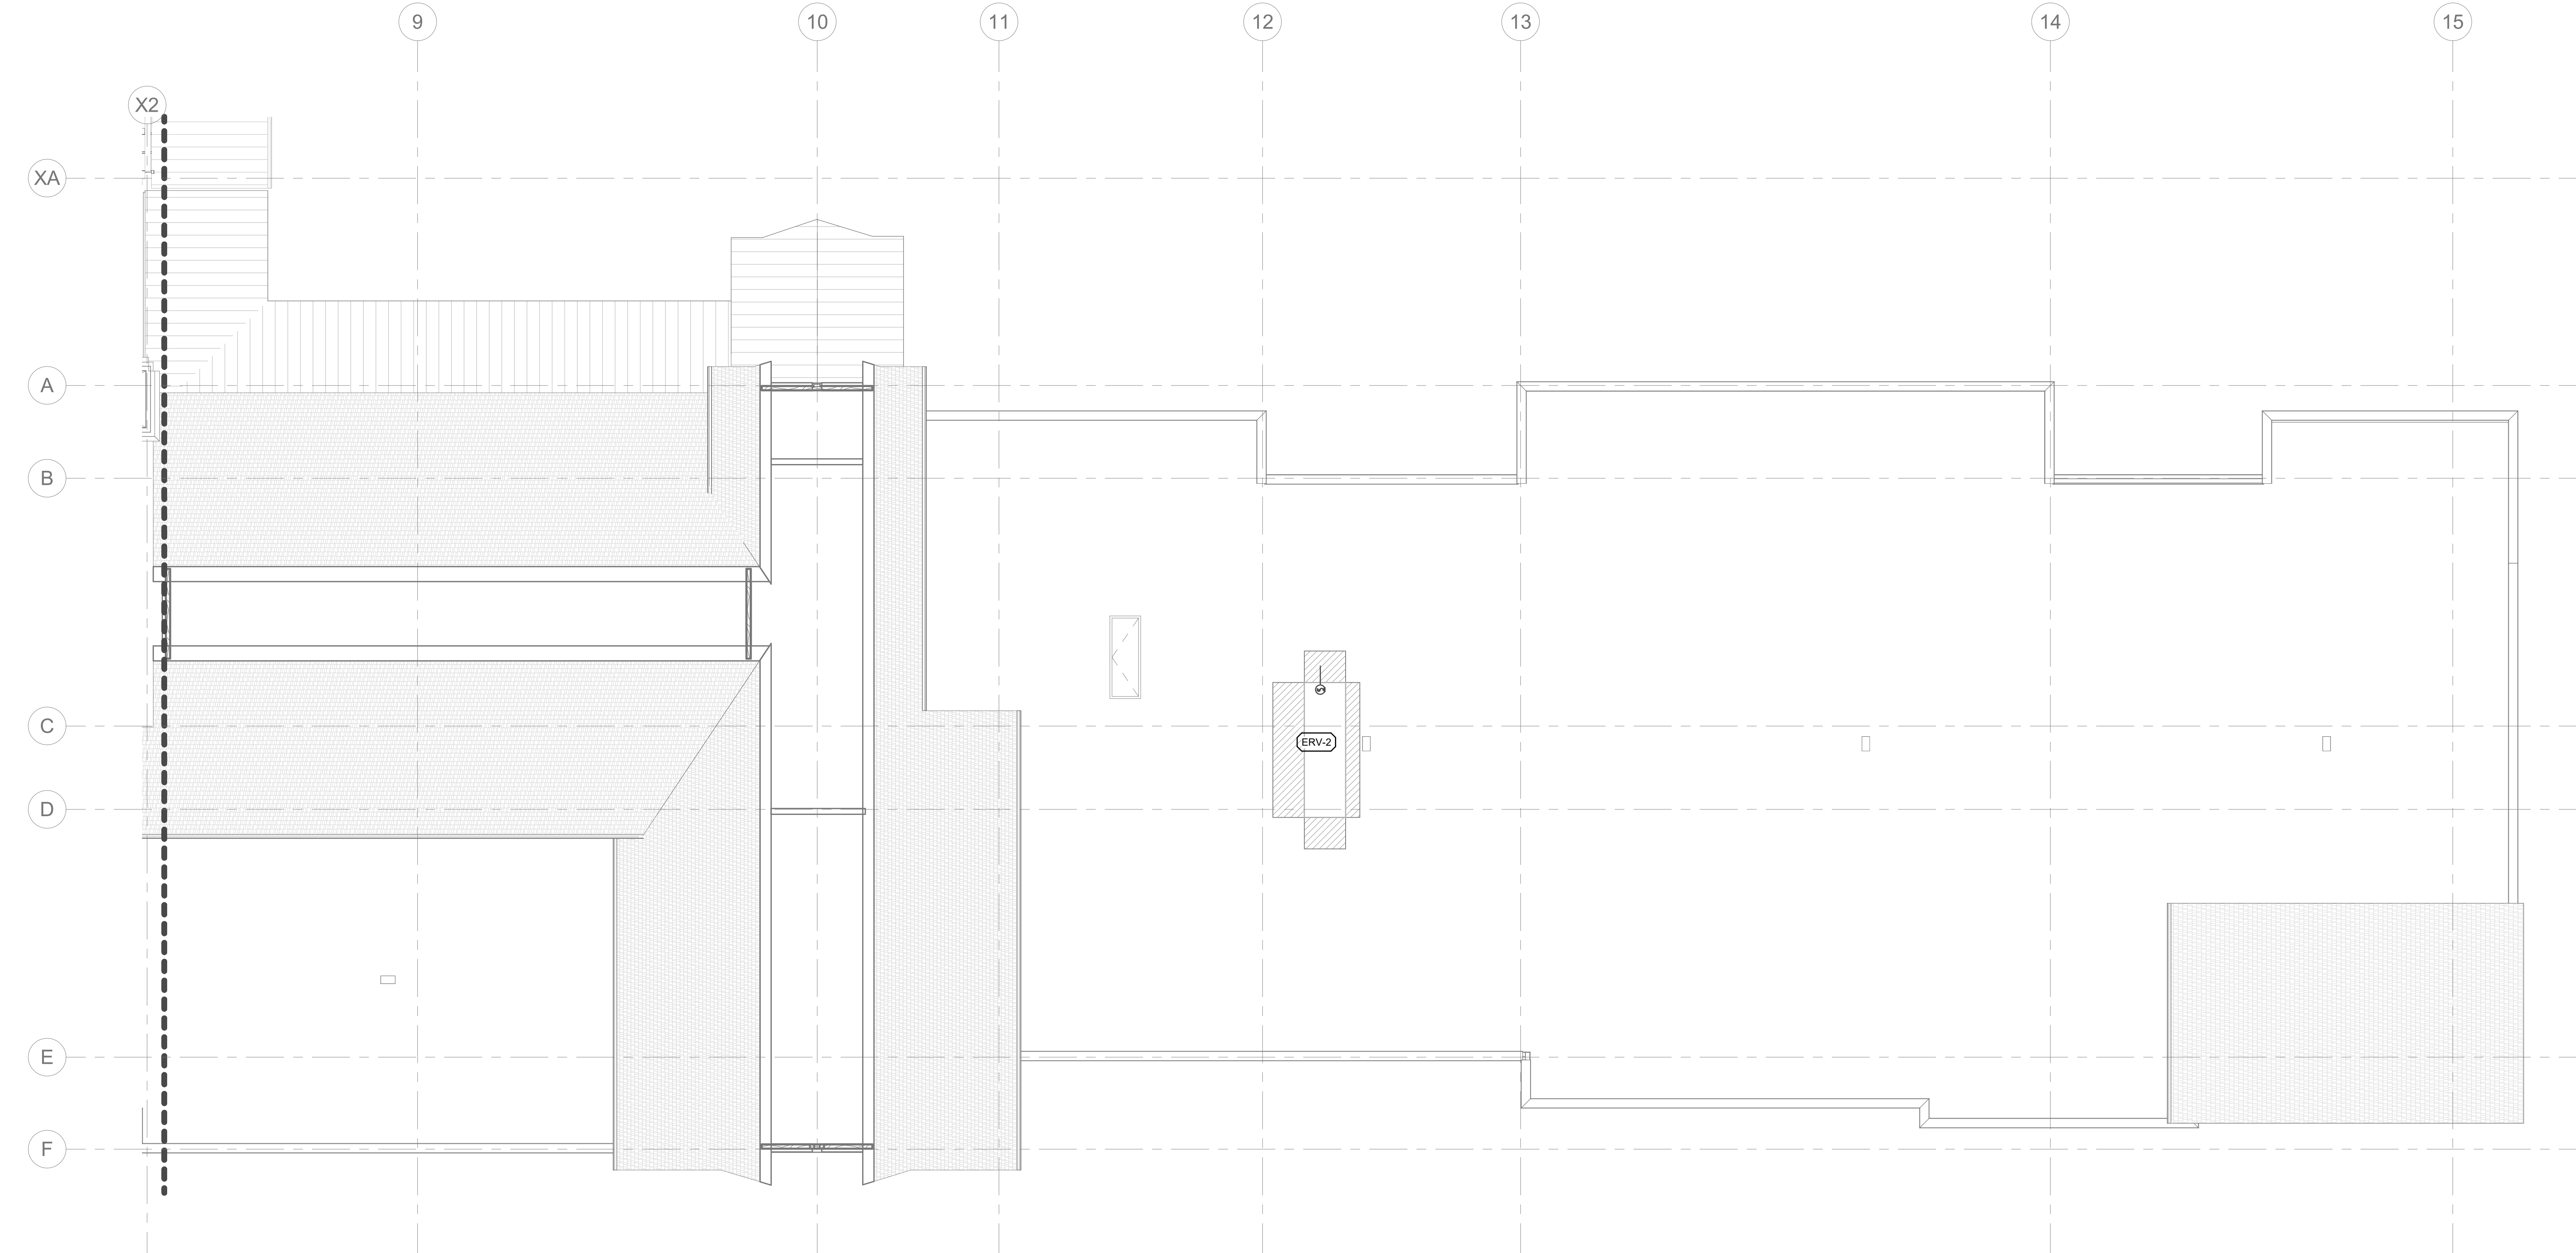

1 ELECTRICAL ROOF PLAN SOUTH
1/8" = 1'-0"

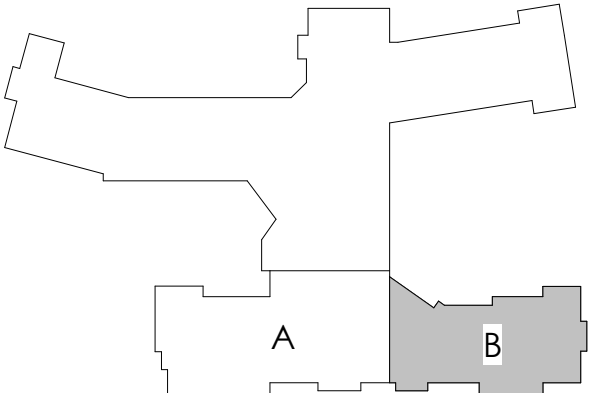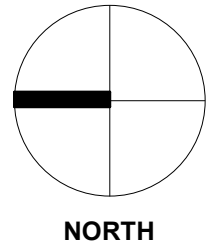




Richard D. Becker
Signature

Richard D. Becker
Typed or Printed Name

Electrical 12/02/24
Discipline Date

WESLEY BRADLEY PARK
PHASE 2 - CARE CENTER
707 39TH AVENUE SE
PUYALLUP, WA 98374

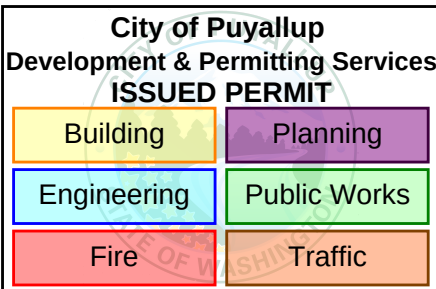

CARE CENTER
PERMIT SET
December 2, 2024

REVISIONS

No.	Description	Date
-----	-------------	------


ISA202201
PROJECT NUMBER

DJL JLA
DRAWN BY CHECKED BY


WESLEY BRADLEY PARK
PHASE 2 - CARE CENTER

ELECTRICAL UNITS

E3.0

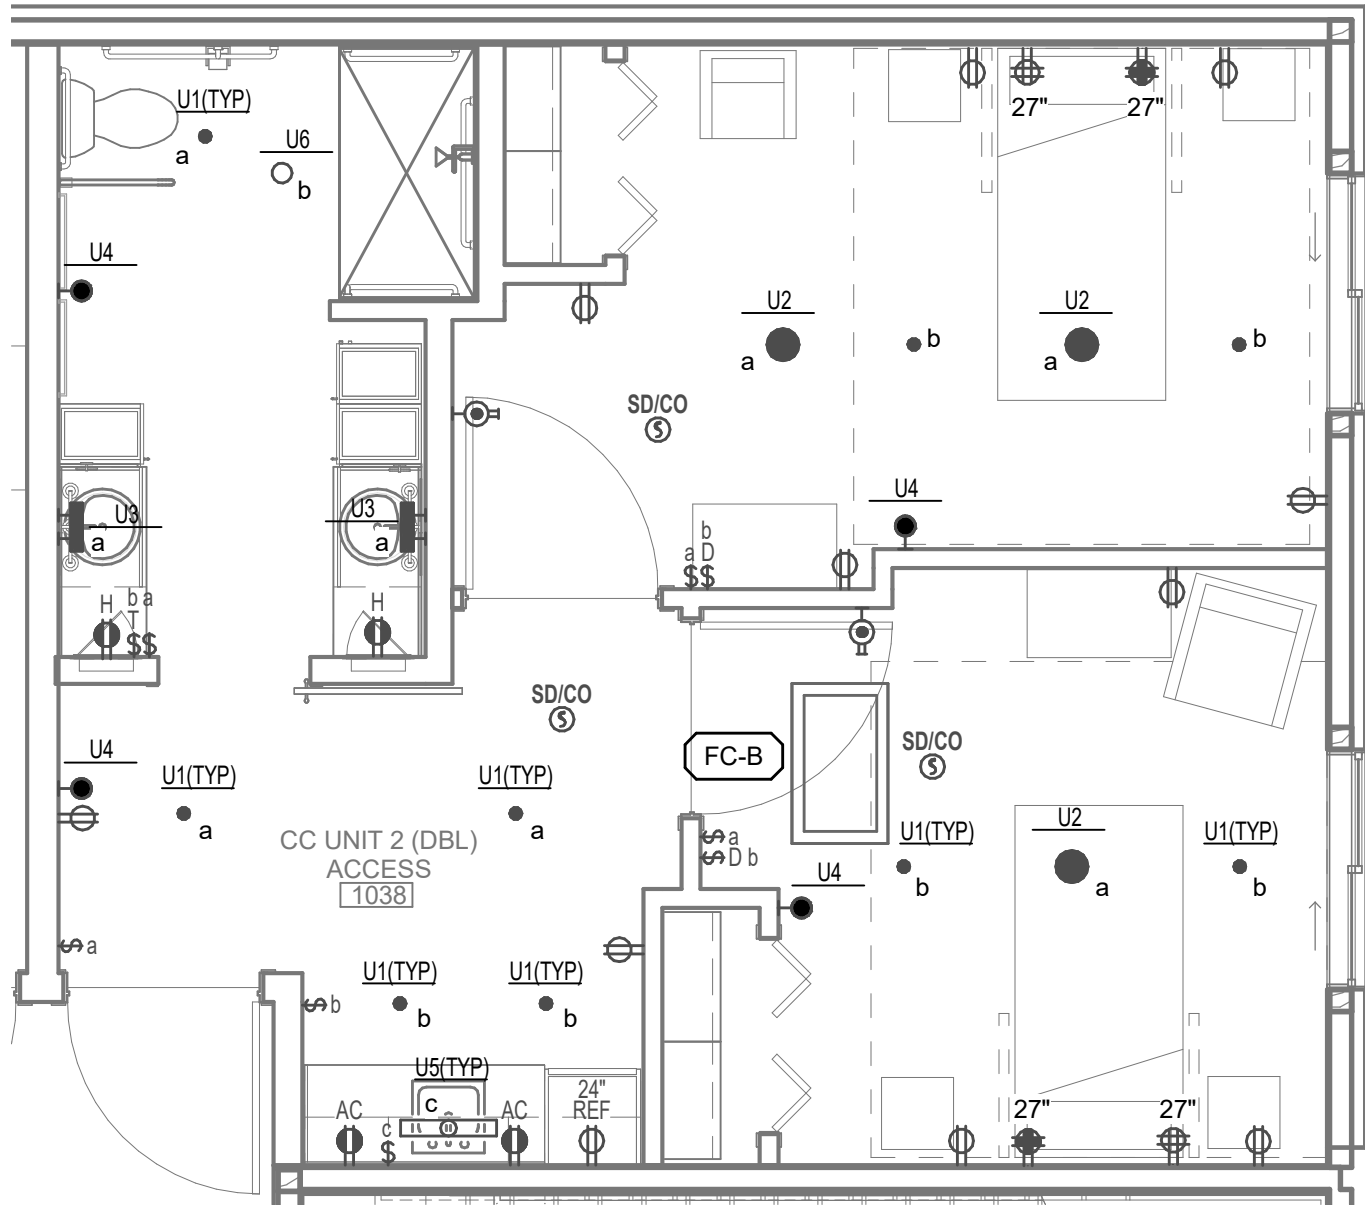


② CC UNIT 2 (DBL) ELECTRICAL PLAN
1/4" = 1'-0"

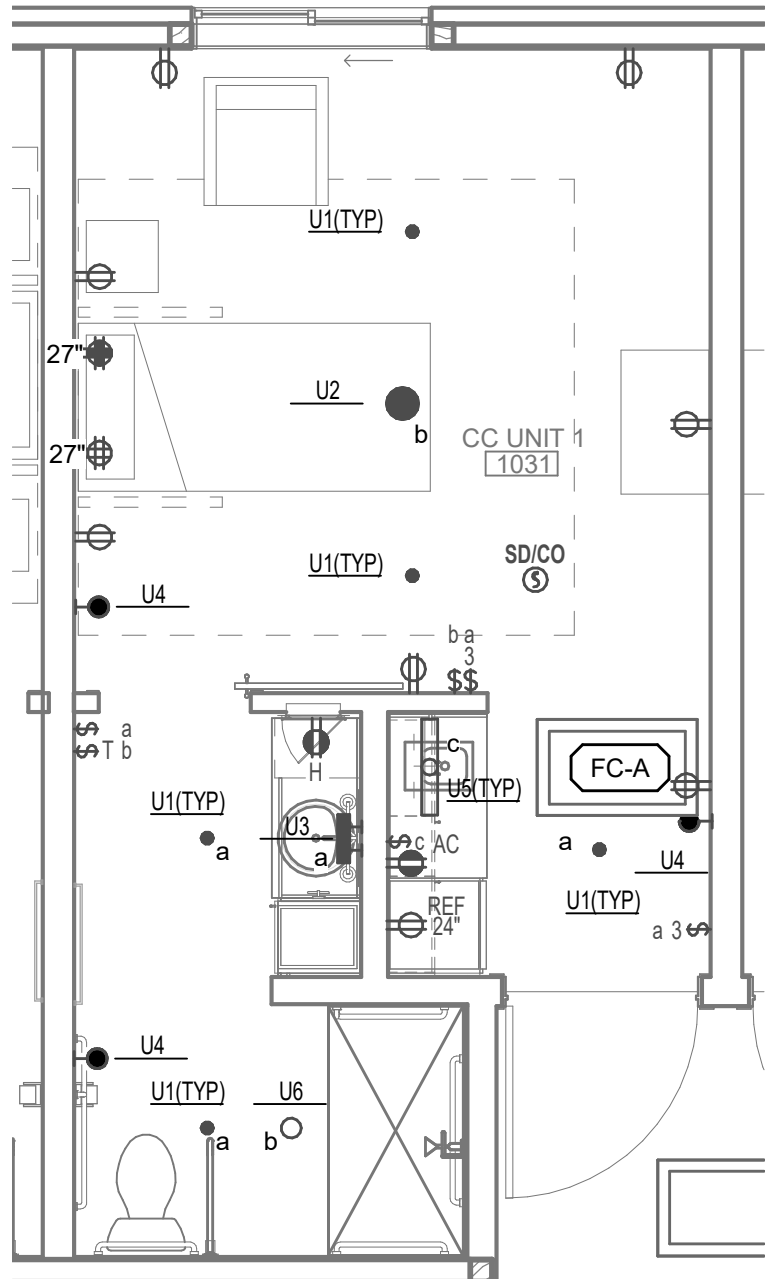

① CC UNIT 1 ELECTRICAL PLAN
1/4" = 1'-0"

GENERAL ELECTRICAL UNIT NOTES

- CONTRACTOR SHALL COMPLETE ALL UNITS BASED ON TYPICAL UNIT DESIGNS. COORDINATE DEVICE LOCATION BASED ON UNIT MOCK-UP.
- CONTRACTOR SHALL COMPARE TYPICAL UNIT DESIGNS WITH ARCHITECTURAL REFLECTED CEILING PLANS PRIOR TO BID. THE QUANTITY & CONDITION OF LIGHT FIXTURES MOST FAVORABLE TO THE OWNER SHALL BE BID.
- PER SPECIFICATIONS, CONTRACTOR SHALL PROVIDE ACOUSTICALLY RATED, FLANGED, AIRTIGHT BOXES IN ALL UNIT CORRIDOR WALLS, ALL UNIT PARTY WALLS, ALL UNIT TOP FLOOR CEILINGS, UNIT EXTERIOR WALLS & ALL UNIT FLOOR/CEILING ASSEMBLIES.
- AT ALL THROUGH PENETRATIONS AT FIRE-RESISTANCE RATING, PROVIDE APPROVED PENETRATION FIRESTOP SYSTEM INSTALLED AND TESTED IN ACCORDANCE WITH ASTM E 814 OR UL 1479. INSTALLATION SHALL HAVE AN F & T RATING OF NOT LESS THAN THE ASSEMBLY BEING PROTECTED.
- AT ALL MEMBRANE PENETRATIONS, ELECTRICAL BOX INSTALLATION SHALL COMPLY WITH IBC 713.3.2.
- PROVIDE SYSTEM DUAL RELAY SMOKE DETECTORS WITHIN UNITS. PROVIDE CONNECTION BETWEEN SMOKE DETECTOR & NURSE CALL SYSTEM. ACTIVATION SHALL ANNUNCIATE AT THE FAAP & NURSE CALL SYSTEM. REFER TO FIRE ALARM SPECIFICATIONS.
- PROVIDE HOSPITAL GRADE RECEPTACLES IN SKILLED NURSING ROOMS.
- PROVIDE ARC FAULT/GFCI BREAKERS FOR ALL CIRCUITRY.
- SKILLED NURSING ROOMS SHALL HAVE A DUAL RELAY SMOKE DETECTOR. PROVIDE WIRING TO THE NURSE CALL DOME LIGHT AS REQUIRED FOR PROPER OPERATION. COORDINATE WITH WIRELESS NURSE CALL PROVIDER.
- COORDINATE TV RECEPTACLE HEIGHT WITH ARCHITECT.
- PROVIDE RED RECEPTACLES FOR EMERGENCY POWER CIRCUITS. ELECTRICAL CONTRACTOR TO VERIFY WITH ARCHITECT OR OWNER ALL MOUNTING HEIGHTS.

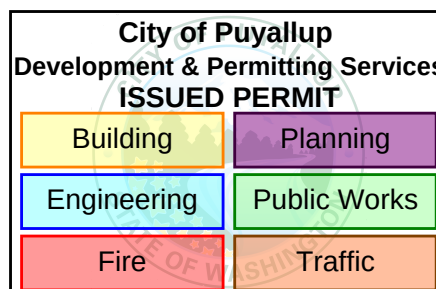Richard D. Becker
Typed or Printed NameElectrical
Discipline
12/02/24
DateWESLEY BRADLEY PARK
PHASE 2 - CARE CENTER
707 39TH AVENUE SE
PUYALLUP, WA 98374CARE CENTER
PERMIT SET
December 2, 2024

REVISIONS

No. Description Date

ISA202201

PROJECT NUMBER

DJL JLA

DRAWN BY CHECKED BY

WESLEY BRADLEY PARK
PHASE 2 - CARE CENTER

ELECTRICAL RISERS



E4.0

GENERAL ELECTRICAL RISER NOTES:

- ELECTRICAL CONTRACTOR TO COORDINATE WITH ELEVATOR MANUFACTURER.
- COMMUNICATION CONDUIT RUNS SHALL CONTAIN SWEEPS. 90 DEGREE BENDS ARE NOT ALLOWED.
- ALL CONDUIT SLEEVE SIZES & LOCATIONS TO BE VERIFIED WITH LOW VOLTAGE SUPPLIERS.
- ELECTRICAL CONTRACTOR TO COORDINATE LOW VOLTAGE CONDUITS WITH SUPPLIER. PROVIDE RACEWAYS AS REQUIRED.
- PROVIDE TWO (3") CONDUITS FOR FUTURE PV SYSTEM FROM ELECTRICAL ROOM TO ROOF. COORDINATE EXACT REQUIREMENTS WITH PV INSTALLER.

SPECIFIC ELECTRICAL RISER NOTES:

- EXISTING LODGE SWITCHBOARD.
- PROVIDE 603P SHUNT-TRIP CIRCUIT BREAKER FOR ELEVATOR. VERIFY WITH ELEVATOR MANUFACTURER EXACT LOCATION & SIZE.
- EXISTING LIFE SAFETY PANELBOARD FROM THE LODGE ELECTRICAL ROOM. FIELD VERIFY. PROVIDE A 100A/3PH FEEDER & CIRCUIT BREAKER FROM PANEL 2LS TO ELSLP01.
- EXISTING OPTIONAL PANELBOARD FROM THE LODGE ELECTRICAL ROOM. FIELD VERIFY. PROVIDE A 400A/3PH FEEDER & CIRCUIT BREAKER FROM PANEL 2SB TO EOSLP01.
- EXISTING 800A C.B. TO FEED NEW SKILLED NURSING HOME DISTRIBUTION BOARD DP02 TO FEED NEW WATER HEATERS.
- PROVIDE NEW 1200 C.B. TO FEED DP01 IN NEW SKILLED NURSING FACILITY. COORDINATE EXACT REQUIREMENTS ON SITE.

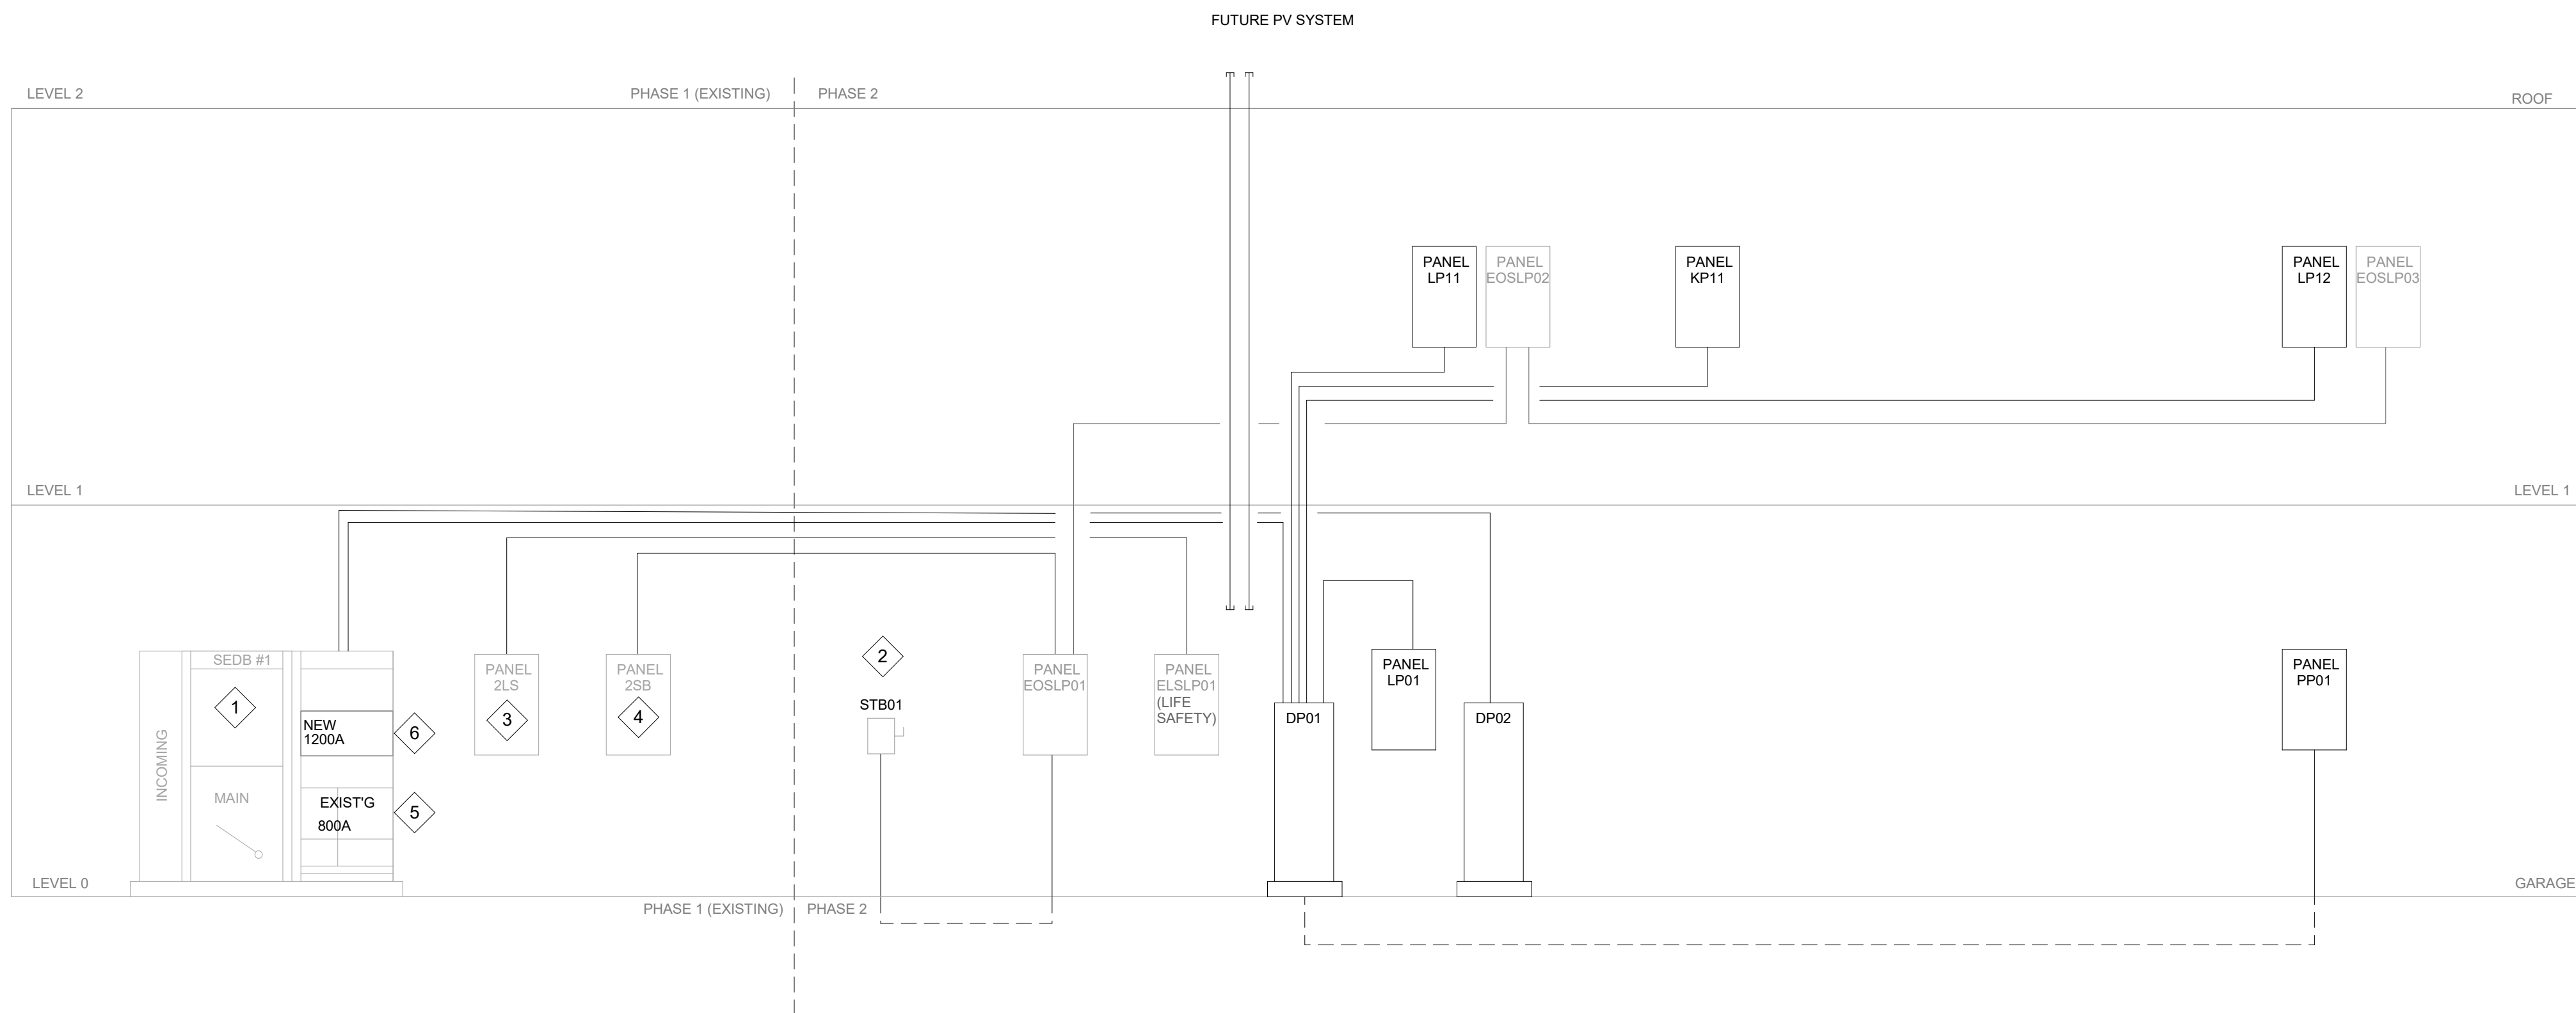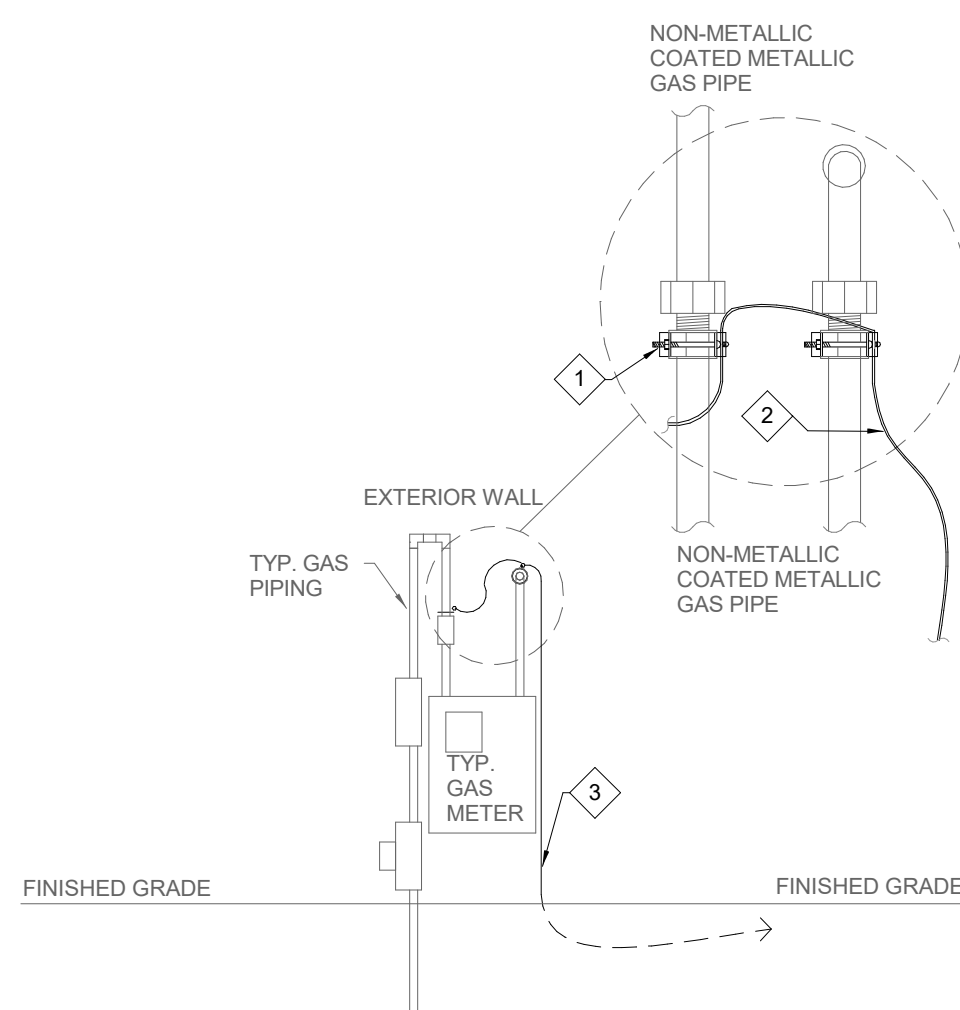1 ELECTRICAL RISER DIAGRAM
NOT TO SCALE2 SINGLE METER GAS PIPING BONDING DETAIL
NO SCALE

SINGLE METER GAS PIPING BONDING GENERAL NOTES

- COMPLETE BONDING INSTALLATION SHALL CONFORM TO NFPA-70, NEC-250 AND UL467.
- CLAMPS SHALL NOT BE INSTALLED ON NON-METALLIC COATED GAS PIPING.
- THE #6 BONDING CONDUCTOR SHALL BE ONE CONTINUOUS PIECE WITH NO SPLICES.

SINGLE METER GAS PIPING BONDING SPECIFIC NOTES

- PROVIDE BONDING CLAMPS FOR GAS PIPE FITTING. INSTALL ON METALLIC NUT OF CONNECTOR AFTER PIPE CONNECTIONS HAVE BEEN MADE & TESTED. CLAMP SHALL BE COMPATIBLE WITH METAL NUT TO PREVENT CORROSION & SHALL ACCEPT A MINIMUM #6 COPPER BONDING CONDUCTOR. STORM COPPER COMPONENTS CO. #14ED-LPC-GVM-JR3 OR EQUAL. TYPICAL.
- PROVIDE MINIMUM #6 BARE COPPER BONDING CONDUCTOR.
- ROUTE BONDING CONDUCTOR FROM MANIFOLD SIDE OF METER DIRECT BURIED TO BUILDING SERVICE GROUND ROD & CLAMP. FIELD VERIFY EXACT ROUTING & LOCATION OF SERVICE GROUND ROD(S).

DISTRIBUTION EQUIPMENT SCHEDULE


PANEL NO.	VOLTAGE	MOUNTING	AIC	MAIN / RATING	# OF CCTS	BREAKERS DISC REQUIRED	FEEDER FROM	NOTES
EXISTING SWBD (SEDB #1)	120/208V 3PH, 4W	FLOOR	65K	4000A	-	-	-	-
EOSLP01 (OPTIONAL)	120/208V 3PH, 4W	SURFACE	22K	400A	SEE SCHEDULES	SEE SCHEDULES	3-1/2" C. 4#500 & #3 GRD. FROM 2SB	1
ELSLP01 (LIFE SAFETY)	120/208V 3PH, 4W	SURFACE	10K	100A	SEE SCHEDULES	SEE SCHEDULES	1-1/2" C. 4#2 & #6 GRD. FROM 2LS	1
STB01	208V 3PH, 3W	SURFACE	5K	603 SHUNT-TRIP	-	603P	1" C. 3#6 & #10 GRD. FROM EOSLP01	2,4
DP01	120/208V 3PH, 4W	SURFACE	42K	1200A	SEE SCHEDULES	SEE SCHEDULES	(4) 3" C. 4#350 & 3/0 GND. FROM SEDB #1	
DP02	120/208V 3PH, 4W	SURFACE	42K	800A	SEE SCHEDULES	SEE SCHEDULES	(2) 3" C. 4#500 & 1/0 GND. FROM SEDB #1	
KP11	120/208V 3PH, 4W	RECESSED	10K	200A MLO	SEE SCHEDULES	SEE SCHEDULES	2" C. 4#30 & 1#6 GND. FROM DP01	1
LP01	120/208V 3PH, 4W	SURFACE	10K	200A MLO	SEE SCHEDULES	SEE SCHEDULES	2" C. 4#30 & #6 GND. FROM DP01	1
PP01	120/208V 3PH, 4W	SURFACE	10K	200A MLO	SEE SCHEDULES	SEE SCHEDULES	2" C. 4#30 & #6 GND. FROM DP01	1
LP11	120/208V 3PH, 4W	SURFACE	10K	200A	SEE SCHEDULES	SEE SCHEDULES	2" C. 4#30 & #6 GRD. FROM DP01	1
LP12	120/208V 3PH, 4W	SURFACE	10K	200A	SEE SCHEDULES	SEE SCHEDULES	2" C. 4#30 & #6 GRD. FROM DP01	1
EOSLP02	120/208V 3PH, 4W	SURFACE	10K	100A	SEE SCHEDULES	SEE SCHEDULES	1 1/4" C. 4#3 & #8 GRD. FROM EOSLP01	1,3
EOSLP03	120/208V 3PH, 4W	SURFACE	10K	100A	SEE SCHEDULES	SEE SCHEDULES	1 1/4" C. 4#3 & #8 GRD. FROM EOSLP02	1

DISTRIBUTION SCHEDULE NOTES

- FILL REMAINDER OF PANEL WITH 201" POLE BREAKERS.
- MAKE CONNECTION TO ELEVATOR EQUIPMENT. COORDINATE LOCATION.
- PROVIDE FEED THRU LUGS.
- PROVIDE CONNECTION TO ELEVATOR SHUNT-TRIP. COORDINATE WITH MANUFACTURER.

Richard D. Becker
SignatureRichard D. Becker
Typed or Printed Name

Electrical Discipline 12/02/24 Date

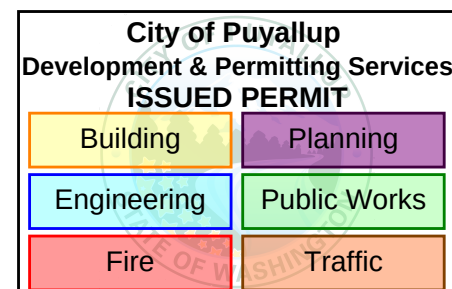WESLEY BRADLEY PARK
PHASE 2 - CARE CENTER
707 39TH AVENUE SE
PUYALLUP, WA 98374CARE CENTER
PERMIT SET
December 2, 2024

REVISIONS

No. Description Date

ISA202201

PROJECT NUMBER

DJL

JLA

DRAWN BY

CHECKED BY

WESLEY BRADLEY PARK
PHASE 2 - CARE CENTERELECTRICAL PANEL
SCHEDULES

E5.0

PANELBOARD: ELSLP01

LOCATION: ELECT 0101 VOLTAGE: 120/208 Wye V, 3 ø 4 W.
MOUNTING: SURFACE NEMA1 A.I.C. RATING: 10,000 AMPS SYMMETRICAL
MAIN DEVICE: 100 A MLO SPECIAL:
BUS AMPS: 100 AMPS

LOAD DESCRIPTION	BKR	POLES	CKT	PHASE A kVA	PHASE B kVA	PHASE C kVA	CKT	POLES	BKR	LOAD DESCRIPTION
LITES - EXTERIOR	20 A	1	1	0.5	0.3		2	1	20 A	LITES - ELEVATOR
LITES - STAIR ST-CC	20 A	1	3		0.1	0.6	4	1	20 A	LITES - GARAGE LEVEL
LITES - STAIR D	20 A	1	5		0.2	0.7	6	1	20 A	LITES - POOL AREA
LITES - LV0 CORRIDORS	20 A	1	7	0.7	0.2		8	1	20 A	LITES - LV0
LITES - LV1 CORRIDORS	20 A	1	9		1.1	0.1	10	1	20 A	LITES - STAIR B
LITES - LV1	20 A	1	11		0.6	0.7	12	1	20 A	LITES - LV1
LITES - LV1	20 A	1	13	1.0	1.1		14	1	20 A	LITES - LV1 CORRIDORS
Other	20 A	1	15		0.0	0.8	16	1	20 A	UC REFRIGERATOR
RCPT - NURSE CALL	20 A	1	17		2.2	1.1	18	1	20 A	RCPT - NURSE CALL
FACP RM 0101	20 A	1	19	1.0			20			
			21				22			
			23				24			
			25				26			
			27				28			
			29				30			
			31				32			
			33				34			
			35				36			
			37				38			
			39				40			
			41				42			
TOTAL LOAD:				5 kVA	3 kVA	5 kVA				
TOTAL AMPS:				43 A	23 A	48 A				
PANEL TOTALS					PANEL TOTALS					
CONNECTED LOAD:					13037 VA	CONNECTED LOAD:				13037 VA
ESTIMATED DEMAND:					14421 VA	ESTIMATED DEMAND:				14421 VA
CONNECTED CURRENT:					36 A	CONNECTED CURRENT:				36 A
EST. DEMAND CURRENT:					40 A	EST. DEMAND CURRENT:				40 A

NOTES:

PANELBOARD: EOSLP01

LOCATION: ELECT 0101 VOLTAGE: 120/208 Wye V, 3 ø 4 W.
MOUNTING: SURFACE NEMA1 A.I.C. RATING: 10,000 AMPS SYMMETRICAL
MAIN DEVICE: 400 A MLO SPECIAL:
BUS AMPS: 400 AMPS

LOAD DESCRIPTION	BKR	POLES	CKT	PHASE A kVA	PHASE B kVA	PHASE C kVA	CKT	POLES	BKR	LOAD DESCRIPTION
RCPT - FRIDGE RM 0102	20 A	1	1	0.6	5.0		2	3	60 A	STB01
RCPT - RM 0102	20 A	1	3		0.9	5.0	4	--	--	--
RCPT - EVEV-CC	20 A	1	5			0.2	5.0	6	--	--
CU-2 EXTERIOR	60 A	3	7	5.5	0.8		8	1	20 A	RCPT - RM 1103
--	--	--	9		5.5	0.5	10	1	20 A	RCPT
--	--	--	11		5.5	0.1	12	2	15 A	BC-1 RM 0120
EOSLP02, EOSLP03	100 A	3	13	1...	0.1		14	--	--	--
			15		6.3		16			
			17			4.9	18			
			19				20			
			21				22			
			23				24			
			25				26			
			27				28			
			29				30			
			31				32			
			33				34			
			35				36			
			37				38			
			39				40			
			41				42			
TOTAL LOAD:				23 kVA	18 kVA	16 kVA				
TOTAL AMPS:				197 A	155 A	130 A				
PANEL TOTALS					PANEL TOTALS					
CONNECTED LOAD:					57109 VA	CONNECTED LOAD:				57109 VA
ESTIMATED DEMAND:					45282 VA	ESTIMATED DEMAND:				45282 VA
CONNECTED CURRENT:					159 A	CONNECTED CURRENT:				159 A
EST. DEMAND CURRENT:					126 A	EST. DEMAND CURRENT:				126 A

NOTES:

PANELBOARD: EOSLP02

LOCATION: ELECT 1165 VOLTAGE: 120/208 Wye V, 3 ø 4 W.
MOUNTING: SURFACE NEMA1 A.I.C. RATING: 10,000 AMPS SYMMETRICAL
MAIN DEVICE: 100 A MLO SPECIAL:
BUS AMPS: 100 AMPS

LOAD DESCRIPTION	BKR	POLES	CKT	PHASE A kVA	PHASE B kVA	PHASE C kVA	CKT	POLES	BKR	LOAD DESCRIPTION	
UNITS 1031,1033,1035, 1037	20 A	1	1	1.2	0.9		2	1	20 A	1114 & CORR RCPT	
UNITS 1023, 1025, 1029	20 A	1	3		0.9	0.7	4	1	20 A	RCPT - RM 1109	
UNITS 1020,1022,1024,1026	20 A	1	5			1.2	0.9	6	1	20 A	CORR & DINING RCPT
UNITS 1028,1030,1032, 1034	20 A	1	7	1.2	0.5		8	1	20 A	RCPT	
UNITS 1036,1038	20 A	1	9		0.6	0.3	10	2	15 A	BC's	
			11				0.3	12	--	--	
			13	1.0				14	2	15 A	FC's
			15		1.0			16	--	--	
			17					18	--	--	
			19					20	--	--	
			21					22	--	--	
			23					24	--	--	
			25					26	--	--	
			27					28	--	--	
			29					30	--	--	
			31					32	--	--	
			33					34	--	--	
			35					36	--	--	
			37					38	--	--	
			39					40	--	--	
			41					42	--	--	
TOTAL LOAD:				11 kVA	6 kVA	5 kVA					
TOTAL AMPS:				96 A	54 A	41 A					
PANEL TOTALS							PANEL TOTALS				
CONNECTED LOAD:							22526 VA	CONNECTED LOAD: 22526 VA			
ESTIMATED DEMAND:							18694 VA	ESTIMATED DEMAND: 18694 VA			
CONNECTED CURRENT:							63 A	CONNECTED CURRENT: 63 A			
EST. DEMAND CURRENT:							52 A	EST. DEMAND CURRENT: 52 A			

NOTES:

PANELBOARD: EOSLP03

LOCATION: ELECT 1115 VOLTAGE: 120/208 Wye V, 3 ø 4 W.
MOUNTING: SURFACE NEMA1 A.I.C. RATING: 10,000 AMPS SYMMETRICAL
MAIN DEVICE: 100 A MLO SPECIAL:
BUS AMPS: 100 AMPS

LOAD DESCRIPTION	BKR	POLES	CKT	PHASE A kVA	PHASE B kVA	PHASE C kVA	CKT	POLES	BKR	LOAD DESCRIPTION	
UNITS 1002,1004,1006,1010	20 A	1	1	1.2	0.4		2	1	20 A	RCPT - RM 1054	
UNITS 1012,1014,1016,1018	20 A	1	3		1.2	0.4	4	1	20 A	1085 FRIDGE	
UNITS 1013...	20 A	1	5			1.2	0.7	6	1	20 A	CORR RCPT
UNITS 1007,1009,1011	20 A	1	7	0.9	1.6		8	1	20 A	1087	
UNITS 1001,1003,1005	20 A	1	9		0.9	0.3	10	2	15 A	BC's	
RCPT - RM 1074A	20 A	1	11			0.4	0.3	12	--	--	
RCPT - RM 122	20 A	1	13	0.7	1.7		14	1	20 A	DOOR OPS. RM 1050	
			15				16				
			17				18				
			19				20				
			21				22				
			23				24				
			25				26				
			27				28				
			29				30				
			31				32				
			33				34				
			35				36				
			37				38				
			39				40				
			41				42				
TOTAL LOAD:				6 kVA	3 kVA	3 kVA					
TOTAL AMPS:				54 A	23 A	21 A					
PANEL TOTALS							PANEL TOTALS				
CONNECTED LOAD:							11745 VA	CONNECTED LOAD: 11745 VA			
ESTIMATED DEMAND:							9844 VA	ESTIMATED DEMAND: 9844 VA			
CONNECTED CURRENT:							33 A	CONNECTED CURRENT: 33 A			
EST. DEMAND CURRENT:							27 A	EST. DEMAND CURRENT: 27 A			

NOTES:
FEED-THROUGH FROM EOSLP02

PANELBOARD: LP11

LOCATION: ELECT 1165 VOLTAGE: 120/208 Wye V, 3 ø 4 W.
MOUNTING: SURFACE NEMA1 A.I.C. RATING: 10,000 AMPS SYMMETRICAL
MAIN DEVICE: 200 A MLO SPECIAL:
BUS AMPS: 200 AMPS

LOAD DESCRIPTION	BKR	POLES	CKT	A	B	C	CKT	POLES	BKR	LOAD DESCRIPTION	
LITES - LV1	20 A	1	1	0.7	0.5		2	1	20 A	RCPT	
LITES - LV1	20 A	1	3		0.9	1.2		4	1	20 A	PRINTER
CHTG RCPT	20 A	1	5			0.9	2.1	6	2	30 A	DRYER
RCPT	20 A	1	7	0.5	2.1		8	--	--	--	
RCPT	20 A	1	9		1.3	2.1	10	1	20 A	RCPT	
RANGE	50 A	2	11			2.8	0.2	12	1	20 A	RCPT
--	--	--	13	2.8	0.2		14	1	20 A	RCPT	
			15			0.2	16	1	20 A	RCPT	
UNIT 1037	20 A	1	17			1.2	0.2	18	1	20 A	RCPT
UNIT 1035	20 A	1	19	1.2	1.1		20	1	20 A	RCPT	
UNIT 1033	20 A	1	21		1.2	0.2	22	1	15 A	EF-4 ROOF	
UNIT 1031	20 A	1	23			1.2	0.8	24	1	15 A	ERH-A
UNIT 1029	20 A	1	25	1.2	0.4		26	2	15 A	UNIT FC's	
UNIT 1025	20 A	1	27		1	0.4	--	--	--	--	
UNIT 1023	20 A	1	29			1.2	0.5	30	2	20 A	FAN COILS LV1
UNIT 1020	20 A	1	31	1.2	0.5		32	--	--	--	
UNIT 1022	20 A	1	33		1.2	0.5	34	2	20 A	FAN COILS LV1	
UNIT 1024	20 A	1	35			1.2	0.5	36	--	--	
UNIT 1026	20 A	1	37	1.2	1.5		38	2	20 A	FF-A RM E100	
UNIT 1028	20 A	1	39		1.2	1.5	40	--	--	--	
UNIT 1030	20 A	1	41			1.2	3.7	42	3	40 A	ERV-1 ROOF
UNIT 1032	20 A	1	43	1.2	3.7		44	--	--	--	
UNIT 1034	20 A	1	45		1.2	3.7	46	--	--	--	
UNIT 1036	20 A	1	47			1.2	48	--	--	--	
			49				50				
			51				52				
			53				54				
			55				56				
			57				58				
			59				60				
			61								
			62								
			63								
			239								




Richard D. Becker
Signature

Richard D. Becker
Typed or Printed Name

Electrical 12/02/24
Discipline Date

WESLEY BRADLEY PARK
PHASE 2 - CARE CENTER
707 39TH AVENUE SE
PUYALLUP, WA 98374

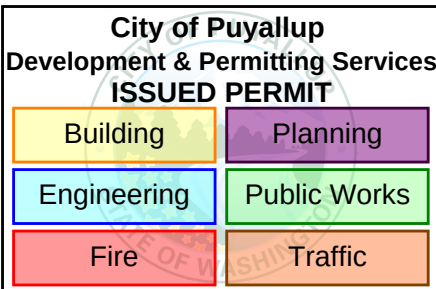

CARE CENTER
PERMIT SET
December 2, 2024

REVISIONS

No. Description Date

ISA202201
PROJECT NUMBER

DJL JLA
DRAWN BY CHECKED BY

WESLEY BRADLEY PARK
PHASE 2 - CARE CENTER

ELECTRICAL PANEL
SCHEDULES

E5.1

PANELBOARD: KP11

LOCATION: SERVING KITCHEN 1144 VOLTAGE: 120/208 Wye V, 3 ø 4 W.
MOUNTING: RECESSED NEMA1 A.I.C. RATING: 10,000 AMP'S SYMMETRICAL
MAIN DEVICE: 200 A MLO SPECIAL:
BUS AMPS: 200 AMPS

LOAD DESCRIPTION	BKR	POLES	CKT	PHASE A kVA	PHASE B kVA	PHASE C kVA	CKT	POLES	BKR	LOAD DESCRIPTION
LITES - RM 1064	20 A	1	1	0.6	5.6		2	3	60 A	106 - DISHWASHER
104 - DISPOSAL	15 A	3	3		0.6	5.6	4	--	--	
--	--	--	5				6	--	--	
--	--	--	7	0.6	0.7		8	1	20 A	108-121 - CONVENIENCE
111A - FIRE PROTECTION	20 A	1	9		0.2	1.8	10	1	20 A	109 - PANINI GRILL
112 - BURNER	20 A	1	11		0.7	0.5	12	1	20 A	133, 117 - CONVENIENCE
111 - EXHAUST HOOD	20 A	1	13	1.2	1.6		14	1	20 A	120 - MICROWAVE
119 - TOASTER	25 A	1	15		2.2	2.5	16	2	30 A	129C - HOT WELLS
129B - HEATED DISH	20 A	1	17		0.5	2.5	18	--	--	
131 - HEAT LAMPS	20 A	1	19	1.2	0.5		20	1	20 A	128,139 - REFRIGERATORS
132A,B LIGHTS	20 A	1	21		0.4	0.5	22	3	15 A	KMUA-1 ROOF
134 ICE DISPENSER	20 A	1	23		1.2	0.5	24	--	--	
135 JUICE MACHINE	15 A	1	25	1.2	0.5		26	--	--	
136 COFFEE BREWER	30 A	2	27		2.5	0.7	28	1	15 A	KEF-1 ROOF
--	--	--	29		2.5	0.9	30	1	15 A	KEF-2 ROOF
138 TEA BREWER	15 A	1	31	1.2			32			
--	--	--	33				34			
--	--	--	35				36			
--	--	--	37				38			
--	--	--	39				40			
--	--	--	41				42			
TOTAL LOAD:				15 kVA	17 kVA	15 kVA				
TOTAL AMPS:				123 A	141 A	128 A				
PANEL TOTALS							PANEL TOTALS			
CONNECTED LOAD:				46884 VA			CONNECTED LOAD: 46884 VA			
ESTIMATED DEMAND:				37755 VA			ESTIMATED DEMAND: 37755 VA			
CONNECTED CURRENT:				130 A			CONNECTED CURRENT: 130 A			
EST. DEMAND CURRENT:				105 A			EST. DEMAND CURRENT: 105 A			

NOTES:

PANELBOARD: LP01

LOCATION: ELECT 0101 VOLTAGE: 120/208 Wye V, 3 ø 4 W.
MOUNTING: SURFACE NEMA1 A.I.C. RATING: 10,000 AMP'S SYMMETRICAL
MAIN DEVICE: 200 A MLO SPECIAL:
BUS AMPS: 200 AMPS

LOAD DESCRIPTION	BKR	POLES	CKT	A	B	C	CKT	POLES	BKR	LOAD DESCRIPTION	
LITES - LV0	20 A	1	1	0.0	0.0		2	1	20 A	WH-1 RM 0103	
LITES - LV0	20 A	1	3		1.5	0.0		4	1	20 A WH-2 RM 0103	
LITES - LV0	20 A	1	5			0.5	0.0	6	1	20 A WH-3 RM 0103	
RCPT - EXTERIOR	20 A	1	7	0.7	0.0		8	1	20 A	WH-4 RM 0103	
RCPT - PT/OT AREA	20 A	1	9		1.4	0.2		10	1	20 A RCPT - IRRIGATION RM...	
RCPT -	20 A	1	11			0.2	1.2	12	1	20 A SP-1 RM 0103	
RCPT -	20 A	1	13	1.1	0.9			14	1	15 A SP-2 RM 0103	
RCPT -	20 A	1	15		0.7	1.2		16	1	20 A SP-3 RM 0103	
RCPT -	20 A	1	17			0.7	1.2	18	1	20 A SP-5 RM 0103	
RCPT -	20 A	1	19	0.8	1.5			20	2	20 A FF-A STAIR B	
RCPT -	20 A	1	21		1.0	1.5		22	--	--	
RCPT - MICRO	20 A	1	23			1.8	1.5	24	2	20 A FF-A STAIR D	
RCPT - MICRO	20 A	1	25	1.8	1.5			26	--	--	
RCPT -	20 A	1	27		0.7	1.4		28	2	20 A LV0 FC'S	
RCPT -	20 A	1	29				1.3	1.4	30	--	--
RCPT - LV0 COMMON	20 A	1	31	0.9	1.2			32	1	20 A CP-1 RM 0103	
MV-1 RM 0103	20 A	1	33		1.0	0.7		34	1	20 A CP-2 RM 0103	
			35					36	3	75 A CU-1 EXTERIOR	
			37	7.0				38	--	--	
			39		7.0			40	--	--	
			41					42			
			43					44			
			45					46			
			47					48			
			49					50			
			51					52			
			53					54			
			55					56			
			57					58			
			59					60			
TOTAL LOAD:				17 kVA	18 kVA	17 kVA					
TOTAL AMPS:				146 A	154 A	140 A					
PANEL TOTALS							PANEL TOTALS				
CONNECTED LOAD:				52667 VA			CONNECTED LOAD: 52667 VA				
ESTIMATED DEMAND:				42751 VA			ESTIMATED DEMAND: 42751 VA				
CONNECTED CURRENT:				146 A			CONNECTED CURRENT: 146 A				
EST. DEMAND CURRENT:				119 A			EST. DEMAND CURRENT: 119 A				

NOTES:

PANELBOARD: PP01

LOCATION: POOL MECH 0116 VOLTAGE: 120/208 Wye V, 3 ø 4 W.
MOUNTING: SURFACE NEMA1 A.I.C. RATING: 10,000 AMP'S SYMMETRICAL
MAIN DEVICE: 200 A MLO SPECIAL:
BUS AMPS: 200 AMPS

LOAD DESCRIPTION	BKR	POLES	CKT	PHASE A kVA	PHASE B kVA	PHASE C kVA	CKT	POLES	BKR	LOAD DESCRIPTION
LITES -	20 A	1	1	0.5	0.7		2	1	15 A	EF-3
RCPT -	20 A	1	3		0.6	1.2		4	1	20 A SP-4
RCPT -	20 A	1	5			1.4	0.8	6	1	15 A ERHA
RCPT -	20 A	1	7	0.7	1.5			8	2	20 A FF-A RM 0116
RCPT -	20 A	1	9		0.7	1.5		10	--	--
RCPT -	20 A	1	11			0.2	1.0	12	3	20 A DHU-CU's EXTERIOR
RCPT - EWC	20 A	1	13	1.2	1.0			14	--	--
--	--	--	15		1.0			16	--	--
--	--	--	17			5.4		18	3	60 A DHU-1
--	--	--	19	5.4				20	--	--
--	--	--	21		5.4			22	--	--
--	--	--	23					24	--	--
--	--	--	25					26		
--	--	--	27					28		
--	--	--	29					30		
--	--	--	31					32		
--	--	--	33					34		
--	--	--	35					36		
--	--	--	37					38		
--	--	--	39					40		
--	--	--	41					42		
TOTAL LOAD:				11 kVA	10 kVA	9 kVA				
TOTAL AMPS:				93 A	88 A	75 A				
PANEL TOTALS							PANEL TOTALS			
CONNECTED LOAD:				29954 VA			CONNECTED LOAD: 29954 VA			
ESTIMATED DEMAND:				23898 VA			ESTIMATED DEMAND: 23898 VA			
CONNECTED CURRENT:				83 A			CONNECTED CURRENT: 83 A			
EST. DEMAND CURRENT:				66 A			EST. DEMAND CURRENT: 66 A			

NOTES:

12/6/2024 9:12:10 AM

MECHANICAL SYMBOL SCHEDULE					
SYMBOL	DESCRIPTION	SYMBOL	DESCRIPTION	SYMBOL	DESCRIPTION
MISCELLANEOUS		VALVES AND PIPE FITTINGS		HEATING	
	CONNECT TO EXISTING		SHUT-OFF VALVE		HWS HOT WATER SUPPLY
	FLOOR ELEVATION POINT		BUTTERFLY VALVE		HWR HOT WATER RETURN
	KEY NOTE		CHECK VALVE		HWRR HOT WATER REVERSE RETURN
	PLUMBING FIXTURE ID		DOUBLE CHECK VALVE OR RPZ		GWS GLYCOL WATER SUPPLY
	DOM. WATER RISER SYMBOL		FLOW FITTING		GWR GLYCOL WATER RETURN
	WASTE RISER SYMBOL		DOMESTIC RECIRCULATING HOT WATER BALANCING ASSEMBLY	AIR CONDITIONING	
	HYDRONIC RISER SYMBOL		CHECK VALVE		CHWS CHILLED WATER SUPPLY
	MECHANICAL EQUIPMENT		BALANCING FULL PORT BALL VALVE		CHWR CHILLED WATER RETURN
	EQUIPMENT BY OTHERS		VALVE IN VERTICAL		CWS CONDENSER WATER SUPPLY
	IN-LINE PUMP		BALL/BALANCING VALVE		CWR CONDENSER WATER RETURN
	REVISION		HOSE BIB OR WALL HYDRANT		CD CONDENSATE DRAIN PIPE
ABBREVIATIONS			ELBOW UP	TEMPERATURE CONTROL AND SENSORS	
AFF	ABOVE FINISHED FLOOR		ELBOW DOWN		T THERMOSTAT
AFG	ABOVE FINISHED GRADE		TEE UP		H HUMIDISTAT
BCW	BOOSTED COLD WATER		TEE DOWN		S SPACE TEMPERATURE SENSOR
BHW	BOOSTED HOT WATER		PIPE CAP		CO CARBON MONOXIDE SENSOR
BOB	BOTTOM OF BEAM		UNION		CO NO2 CARBON MONOXIDE & NITROGEN DIOXIDE SENSOR
BOF	BOTTOM OF PIPE		STRAINER		CO2 CARBON DIOXIDE SENSOR
BOFA	BOTTOM OF FLOOR ABOVE		PIPE ANCHOR		PS PRESSURE SENSOR
CA	COMBUSTION AIR		EXPANSION JOINT		T THERMOMETER
CONT	CONTINUATION		PIPE GUIDE	SHEET METAL	
CO	CLEAN OUT		FLOOR CLEAN OUT		AIR SUPPLY
CS	COUNTER SINK		WALL CLEAN OUT		RETURN OR EXHAUST AIR
CW	COLD WATER		GAS PRESSURE REGULATOR		DUCT, WIDTH/DEPTH
CWB	CONDENSATE WALL BOX		WATER PRESSURE REGULATOR		DUCT, DIAMETER
DN	DOWN		FLOW DIRECTION		DUCT, FLEXIBLE TO RIGID
DIA	DIAMETER		CONTROL VALVE		DUCT AIR SUPPLY, UP
DSN	DOWN SPOUT NOZZLE		3 WAY CONTROL VALVE		DUCT AIR RETURN OR EXHAUST, UP
DTL	DETAIL		SOLENOID VALVE		DUCT AIR SUPPLY, DOWN
EA	EXHAUST AIR		INCREASER OR REDUCER		DUCT AIR RETURN OR EXHAUST, DOWN
ECM	ELECTRONICALLY COMMUTATED MOTOR		WATER OR GAS METER		DUCT BREAK
FSEC	FOOD SERVICE EQUIP. CONTR.	PLUMBING AND PIPE LABELS			CEILING DIFFUSER
FFE	FINISHED FLOOR ELEVATION		ROOF DRAIN (CONTROL FLOW)		LINEAR DIFFUSER
FCW	FILTERED COLD WATER		OVERFLOW DRAIN		WALL/SOFFIT REGISTER
FU	FIXTURE UNITS		DOWNSPOUT DISCHARGE		RETURN/EXHAUST AIR GRILLE
GC	GENERAL CONTRACTOR		FLOOR DRAIN		FIRE/SMOKE DAMPER
HW	HOT WATER		FLOOR SINK		SMOKE DAMPER
HCW	HARD COLD WATER		BACK WATER CHECK VALVE		FIRE DAMPER
KS	KITCHEN SINK		SHOCK ARRESTOR		CEILING RADIATION DAMPER
LAV	LAVATORY		PIPE BREAK		GRAVITY BACKDRAFT DAMPER
INV	INVERT ELEVATION		SAN SEWER-ABOVE GRADE		MOTORIZED DAMPER
MS	MOP SINK		SAN SEWER-BELOW GRADE		BALANCING DAMPER
NIC	NOT IN CONTRACT		GREASE WASTE		FLEXIBLE CONNECTION
NP	NON-POTABLE		FLAMMABLE WASTE		REGISTER/DIFFUSER A (TYPE) 24/12 (SIZE) 250 (CFM)
OA	OUTSIDE AIR		FLAMMABLE WASTE VENT		DIFFUSER H (TYPE) 10"(NECK DIA.) 400 (CFM)
RA	RETURN AIR		SANITARY VENT		RETURN AIR GRILLE C (TYPE) 24/24 (SIZE)
SA	SUPPLY AIR		DOMESTIC COLD WATER		LINEAR DIFFUSER C1 (TYPE) 2 (# SLOTS) 10" (NECK DIA.) 250 (CFM)
SD	STORM DRAINAGE SYSTEM		HARD COLD WATER		
SF	SQUARE FEET		DOMESTIC HOT WATER		
SHR	SHOWER		DOMESTIC RECIRCULATING HOT WATER		
SS	SANITARY SEWER SYSTEM		DOMESTIC HOT WATER 180°F		
SV	STACK VENT		OXYGEN		
TTFD	TELL-TALE FLOOR DRAIN		MEDICAL VAC		
UNO	UNLESS NOTED OTHERWISE		NATURAL INTERRUPTABLE GAS		
V	VENT		NATURAL FIRM GAS		
VFD	VARIABLE FREQUENCY DRIVE		NATURAL GAS - HOUSE METER		
VS	VENT STACK		PROPANE GAS		
VTR	VENT THRU ROOF		BUILDING DRAIN TILE		
WC	WATER CLOSET		STORM DRAIN - ABOVE GRADE		
WCO	WALL CLEAN OUT		STORM DRAIN - BELOW GRADE		
WS	SANITARY WASTE STACK		OVERFLOW STORM DRAIN -ABOVE GRADE		
			RADON VENT		

NOTE: NOT ALL SYMBOLS MAY APPEAR ON DRAWINGS.

F:\LIB\SCHEDULESECHSYMSCH.DWG 3/8/19

Provide trap seal protection per mechanical engineer. Trap primers or other UPC approved trap seals.

Provide cross connection protection in the form of air gaps, double

MECHANICAL SHEET INDEX	
SHEET	DESCRIPTION
M0.0	MECHANICAL TITLE SHEET
M1.0A	LEVEL 0 WASTE & VENT PLAN NORTH
M1.0AB	LEVEL 0 WASTE & VENT PLAN SOUTH
M1.0BA	LEVEL 0 WATER & GAS PLAN NORTH
M1.0BB	LEVEL 0 WATER & GAS PLAN SOUTH
M1.1A	LEVEL 1 PLUMBING PLAN NORTH
M1.1B	LEVEL 1 PLUMBING PLAN SOUTH
M2.0A	LEVEL 0 HVAC PLAN NORTH
M2.1A	LEVEL 1 HVAC PLAN NORTH
M2.1B	LEVEL 1 HVAC PLAN SOUTH
M2.2A	MECHANICAL ROOF PLAN NORTH
M2.2B	MECHANICAL ROOF PLAN SOUTH
M3.0	HVAC UNITS
M3.1	ENLARGED PLAN
M3.2	ENLARGED PLAN
M4.0	PLUMBING RISERS
M4.1	PLUMBING RISERS
M4.2	PLUMBING RISERS
M4.3	PLUMBING RISERS
M5.0	MECHANICAL DETAILS
M5.1	MECHANICAL DETAILS
M5.2	MECHANICAL DETAILS
M5.3	MECHANICAL DETAILS
ME1.0	MECHANICAL EQUIPMENT SCHEDULES
ME1.1	MECHANICAL EQUIPMENT SCHEDULES

Provide plumbing equipment schedule for review.

STEENENGINEERING

763-585-6742
763-585-6757 fax
Email: steen@steeneng.com
5430 Douglas Drive North
Minneapolis, MN 55429

Please see M2.0A and other applicable locations for duct openings in rated assembly.

GENERAL HVAC NOTES	
A.	DRAWINGS ARE DIAGRAMMATIC AND ARE INTENDED TO SHOW APPROXIMATE LOCATIONS ONLY. THE CONTRACTOR SHALL THOROUGHLY REVIEW ALL ARCHITECTURAL, STRUCTURAL, PLUMBING, AND ELECTRICAL PLANS AND SPECIFICATIONS. PLACEMENT OF EQUIPMENT AND DEVICES SHALL NOT INTERFERE WITH LOCATIONS OR CLEARANCES OF OTHER TRADE'S MATERIALS OR EQUIPMENT.
B.	ALL SYSTEMS, MATERIAL AND INSTALLATION SHALL MEET STATE AND LOCAL CODES.
C.	CONTRACTOR SHALL PROVIDE PIPE AND DUCT OFFSETS AND TRANSITIONS AS REQUIRED TO ACCOMMODATE STRUCTURE AND ARCHITECTURE.
D.	RETURN GRILLES SHALL BE PROVIDED WITH LINED BOOT AND ELBOW FITTINGS.
E.	FLOOR MOUNTED HVAC EQUIPMENT SHALL BE PROVIDED WITH A 4" HIGH CONCRETE PAD THAT EXTENDS A MINIMUM 2" BEYOND EDGE OF EQUIPMENT. PADS SHALL BE PROVIDED BY THIS CONTRACTOR.
F.	DUCT SIZES SHOWN ARE FREE AREA. INCREASE DUCT SIZE AS REQUIRED TO ACCOMMODATE INTERNAL INSULATION.
G.	KITCHEN HOODS ARE FURNISHED BY OTHERS AND INSTALLED BY MECHANICAL CONTRACTOR. VERIFY EXACT NECK SIZES AND MAKE ALL NECESSARY CONNECTIONS TO HOOD(S) AS SHOWN.
H.	PROVIDE 3/4" CONDENSATE RUNOUT FOR EACH FAN COIL SHOWN. PITCH PIPING 1/8" PER FOOT. SEE HVAC PLANS AND RISERS FOR ROUTING AND ADDITIONAL SIZING.
I.	COORDINATE SPACE SENSOR/THERMOSTAT LOCATIONS WITH OTHER TRADES AND ARCHITECT PRIOR TO ROUGH-IN AND INSTALLATION.
J.	TAKE-OFFS TO ALL SUPPLY DIFFUSERS AND GRILLES SHALL HAVE MANUAL BALANCING DAMPERS.
K.	DUCT RUNOUTS ARE EQUAL TO GRILLE AND DIFFUSER NECK SIZES SHOWN UNLESS INDICATED OTHERWISE.
L.	PROVIDE ISOLATION VALVES AT EACH PIECE OF EQUIPMENT AND AT EACH BRANCH TAKE OFF FROM PIPING MAINS.
M.	THE MECHANICAL CONTRACTOR SHALL PROVIDE ALL CONTROL DEVICES AS WELL AS ALL LINE VOLTAGE AND LOW VOLTAGE WIRING NECESSARY TO INSTALL AND MAKE FULLY OPERATIONAL SPECIFIED CONTROL SYSTEMS, UNLESS NOTED OTHERWISE.

GENERAL PLUMBING KITCHEN NOTES	
A.	THIS CONTRACTOR SHALL REFER TO THE KITCHEN CONSULTANTS PLAN FOR CLARIFICATION AND ADDITIONAL WORK REQUIRED.
B.	ALL PLUMBING IN MAIN KITCHEN TO BE ENCLOSED IN A WALL OR FLOOR AND EXPOSED PIPING RUNS BE AS SHORT AS POSSIBLE. EXPOSED HORIZONTAL PIPING MUST BE 6" A.F.F. AND MIN. 1" OFF THE WALL. ALL EXPOSED PIPING MUST BE CHROME PLATED.
C.	ALL INDIRECT WASTES FOR FOOD SERVICE EQUIPMENT SHALL BE EXTENDED TO FLOOR DRAIN BY DIV. 22, UNLESS NOTED OTHERWISE.

Separate Permits are required for hoods and ducts.

GENERAL PLUMBING NOTES	
A.	CONTRACTORS SHALL FAMILIARIZE THEMSELVES WITH THE MECHANICAL AND PLUMBING DRAWINGS AND SPECIFICATIONS. NEITHER THE DRAWINGS NOR THE SPECIFICATIONS SHALL BE COMPLETE WITHOUT THE OTHER.
B.	DRAWINGS ARE DIAGRAMMATIC AND ARE INTENDED TO SHOW APPROXIMATE LOCATIONS ONLY. THE CONTRACTOR SHALL THOROUGHLY REVIEW ALL ARCHITECTURAL, STRUCTURAL, MECHANICAL AND ELECTRICAL DRAWINGS AND SPECIFICATIONS.
C.	PLACEMENT OF EQUIPMENT AND DEVICES SHALL NOT INTERFERE WITH LOCATION NOR CLEARANCES OF OTHER TRADE'S MATERIALS OR EQUIPMENT.
D.	CONTRACTOR SHALL PROVIDE PIPE OFFSETS AND TRANSITIONS AS REQUIRED TO ACCOMMODATE STRUCTURE AND ARCHITECTURE.
E.	COORDINATE LOCATION AND ELEVATION OF ALL EXTERIOR WALL AND ROOF PENETRATIONS WITH ARCHITECT.
F.	PRIOR TO INSTALLING PLUMBING VENTS THRU ROOF, COORDINATE WITH ARCHITECT TO MEET APPEARANCE REQUIREMENTS.
G.	ALL BRANCH TAKE-OFFS SHALL HAVE ISOLATION SHUT-OFF VALVES.
H.	PROVIDE A PLASTIC FLOOR DRAIN IN AREAS WHERE CONDENSATE DISCHARGES FROM HIGH EFFICIENCY EQUIPMENT, SUCH AS SEALED COMBUSTION WATER HEATERS.
I.	THIS CONTRACTOR TO PROVIDE COMBINATION HOT AND COLD FAUCETS THAT HAVE THREADED OUTLETS WITH INTERNAL CHECK VALVES OR IN-LINE CHECK VALVES INSTALLED UPSTREAM IN THE BRANCH LINES SERVING THIS TYPE OF FAUCET. THIS INCLUDES THE COMBINATION FAUCETS SUPPLIED BY FOOD SERVICE EQUIPMENT SUPPLIERS.
J.	ALL FLOOR DRAINS AND PLUMBING FIXTURES LOCATED BELOW STREET CURB ELEVATION AT SANITARY SEWER EXIT LOCATION SHALL HAVE BACKWATER CHECK VALVES.
K.	ALL DOMESTIC HOT AND COLD WATER PEX PIPING SHALL MAINTAIN A 2" SPACING AND HAVE INDIVIDUAL FLOOR AND WALL PENETRATIONS.
L.	FLOOR MOUNTED PLUMBING EQUIPMENT SHALL BE PROVIDED WITH A 4" HIGH CONCRETE PAD BY THIS CONTRACTOR. EXTEND A MINIMUM OF 2" BEYOND THE EDGE OF THE EQUIPMENT.
M.	THE MECHANICAL CONTRACTOR SHALL PROVIDE ALL CONTROL DEVICES AS WELL AS ALL LINE VOLTAGE AND LOW VOLTAGE WIRING NECESSARY TO INSTALL AND MAKE FULLY OPERATIONAL SPECIFIED CONTROL SYSTEMS, UNLESS NOTED OTHERWISE.
N.	ADJUST ALL DOMESTIC RECIRCULATION BALANCING VALVES TO 0.5 GPM UNLESS NOTED OTHERWISE.

in = sitearchitects

1000 university ave. w. # suite 130
st. paul, minnesota 55104
612-252-4820

MARK R. BRENNAN
STATE OF WASHINGTON
REGISTERED
PROFESSIONAL ENGINEER
45586

Mark R. Brennan
Typed or Printed Name
12/02/24
Discipline Date

WESLEY BRADLEY PARK
PHASE 2 - CARE CENTER
707 39TH AVENUE SE
PUYALLUP, WA 98374

City of Puyallup
Development & Permitting Services
ISSUED PERMIT
Building Planning
Engineering Public Works
Fire Traffic

CARE CENTER
PERMIT SET
December 2, 2024

REVISIONS
No. Description Date

ISA202201
PROJECT NUMBER
RDB/DCA MRB/RDB
DRAWN BY CHECKED BY
WESLEY BRADLEY PARK
PHASE 2 - CARE CENTER
MECHANICAL TITLE SHEET
M0.0




Mark R. Breneman
Signature

Mark R. Breneman
Typed or Printed Name

Mechanical 12/02/24
Discipline Date

WESLEY BRADLEY PARK
PHASE 2 - CARE CENTER
707 39TH AVENUE SE
PUYALLUP, WA 98374

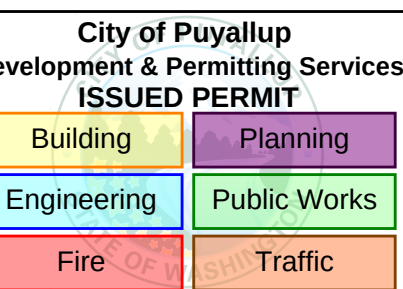

CARE CENTER
PERMIT SET
December 2, 2024

REVISIONS

No.	Description	Date
-----	-------------	------

ISA202201

PROJECT NUMBER

RDB

DRAWN BY

RDB



CHECKED BY

WESLEY BRADLEY PARK
PHASE 2 - CARE CENTER

LEVEL 0 WASTE & VENT
PLAN NORTH

M1.0AA

LEVEL 0 - WASTE AND VENT FLOOR
PLAN NORTH
1/8" = 1'-0"

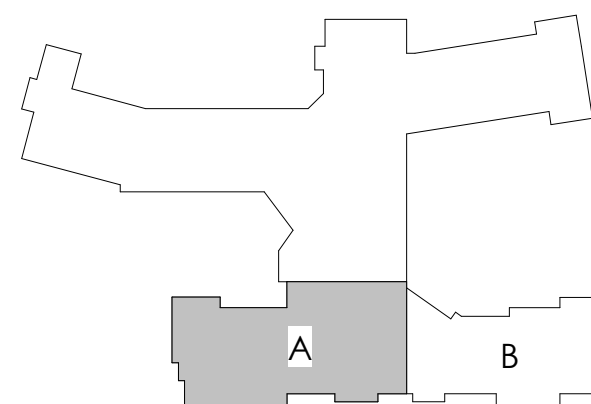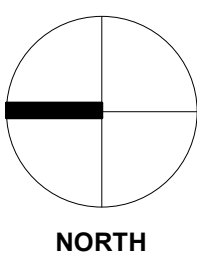

REFER TO SHEET M0.0 FOR NOTES




Mark R. Breneman
Signature

Mark R. Breneman
Typed or Printed Name

Mechanical 12/02/24
Discipline Date

WESLEY BRADLEY PARK
PHASE 2 - CARE CENTER
707 39TH AVENUE SE
PUYALLUP, WA 98374

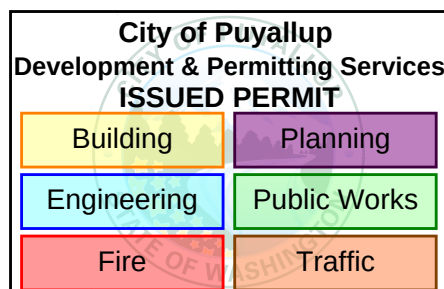

CARE CENTER
PERMIT SET
December 2, 2024

REVISIONS

No.	Description	Date
1	PERMIT RESUBMIT	4/14/25

ISA202201

PROJECT NUMBER


RDB RDB

DRAWN BY CHECKED BY



WESLEY BRADLEY PARK
PHASE 2 - CARE CENTER

LEVEL 0 WASTE & VENT
PLAN SOUTH


M1.0AB

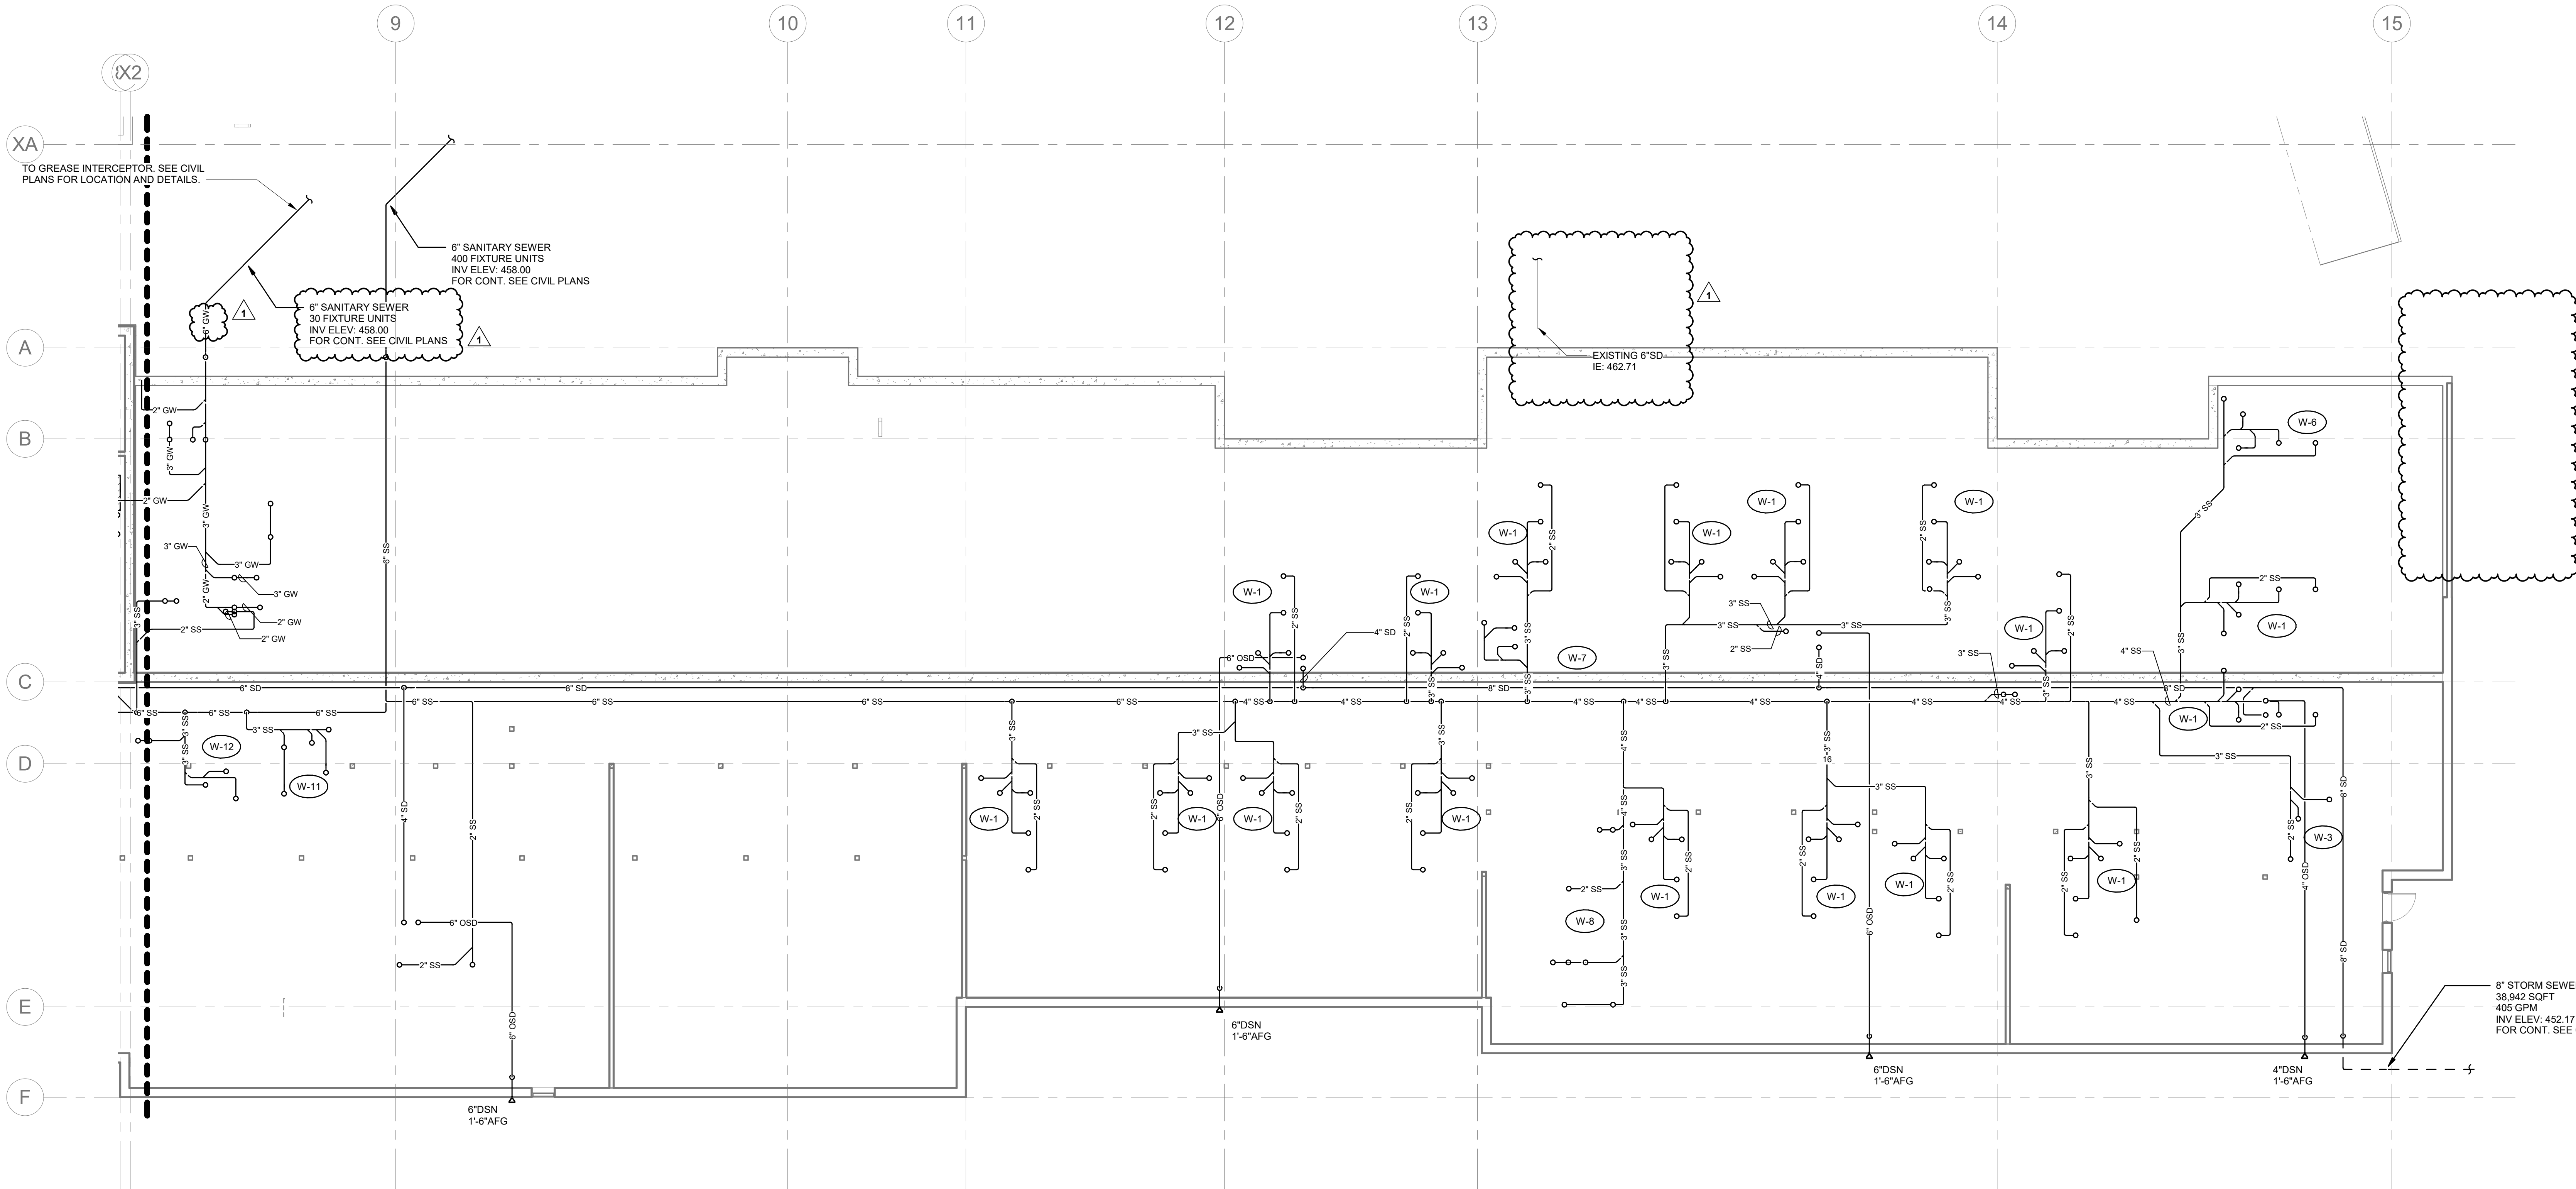

LEVEL 0 - WASTE AND VENT FLOOR
PLAN SOUTH
1/8" = 1'-0"

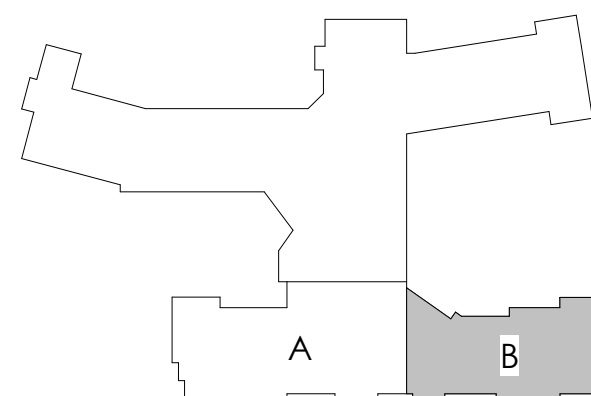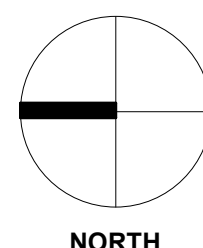

REFER TO SHEET M0.0 FOR NOTES

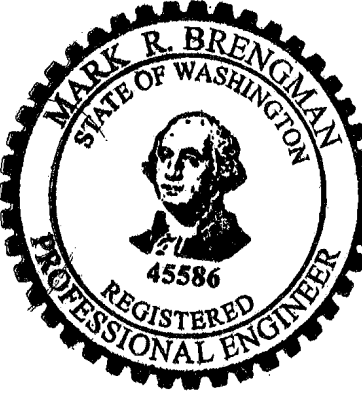


Mark R. Breneman
Signature

Mark R. Breneman
Typed or Printed Name

Mechanical
Discipline

12/02/24
Date

WESLEY BRADLEY PARK
PHASE 2 - CARE CENTER
707 39TH AVENUE SE
PUYALLUP, WA 98374

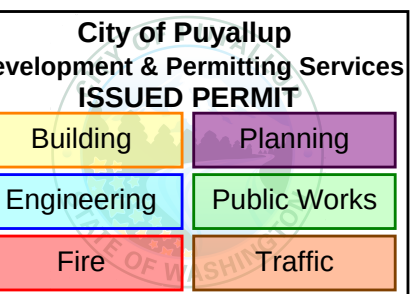

CARE CENTER
PERMIT SET
December 2, 2024

REVISIONS

No.	Description	Date
-----	-------------	------

ISA202201

PROJECT NUMBER

RDB

DRAWN BY


RDB

CHECKED BY



WESLEY BRADLEY PARK
PHASE 2 - CARE CENTER

LEVEL 0 WATER & GAS
PLAN NORTH

M1.0BA

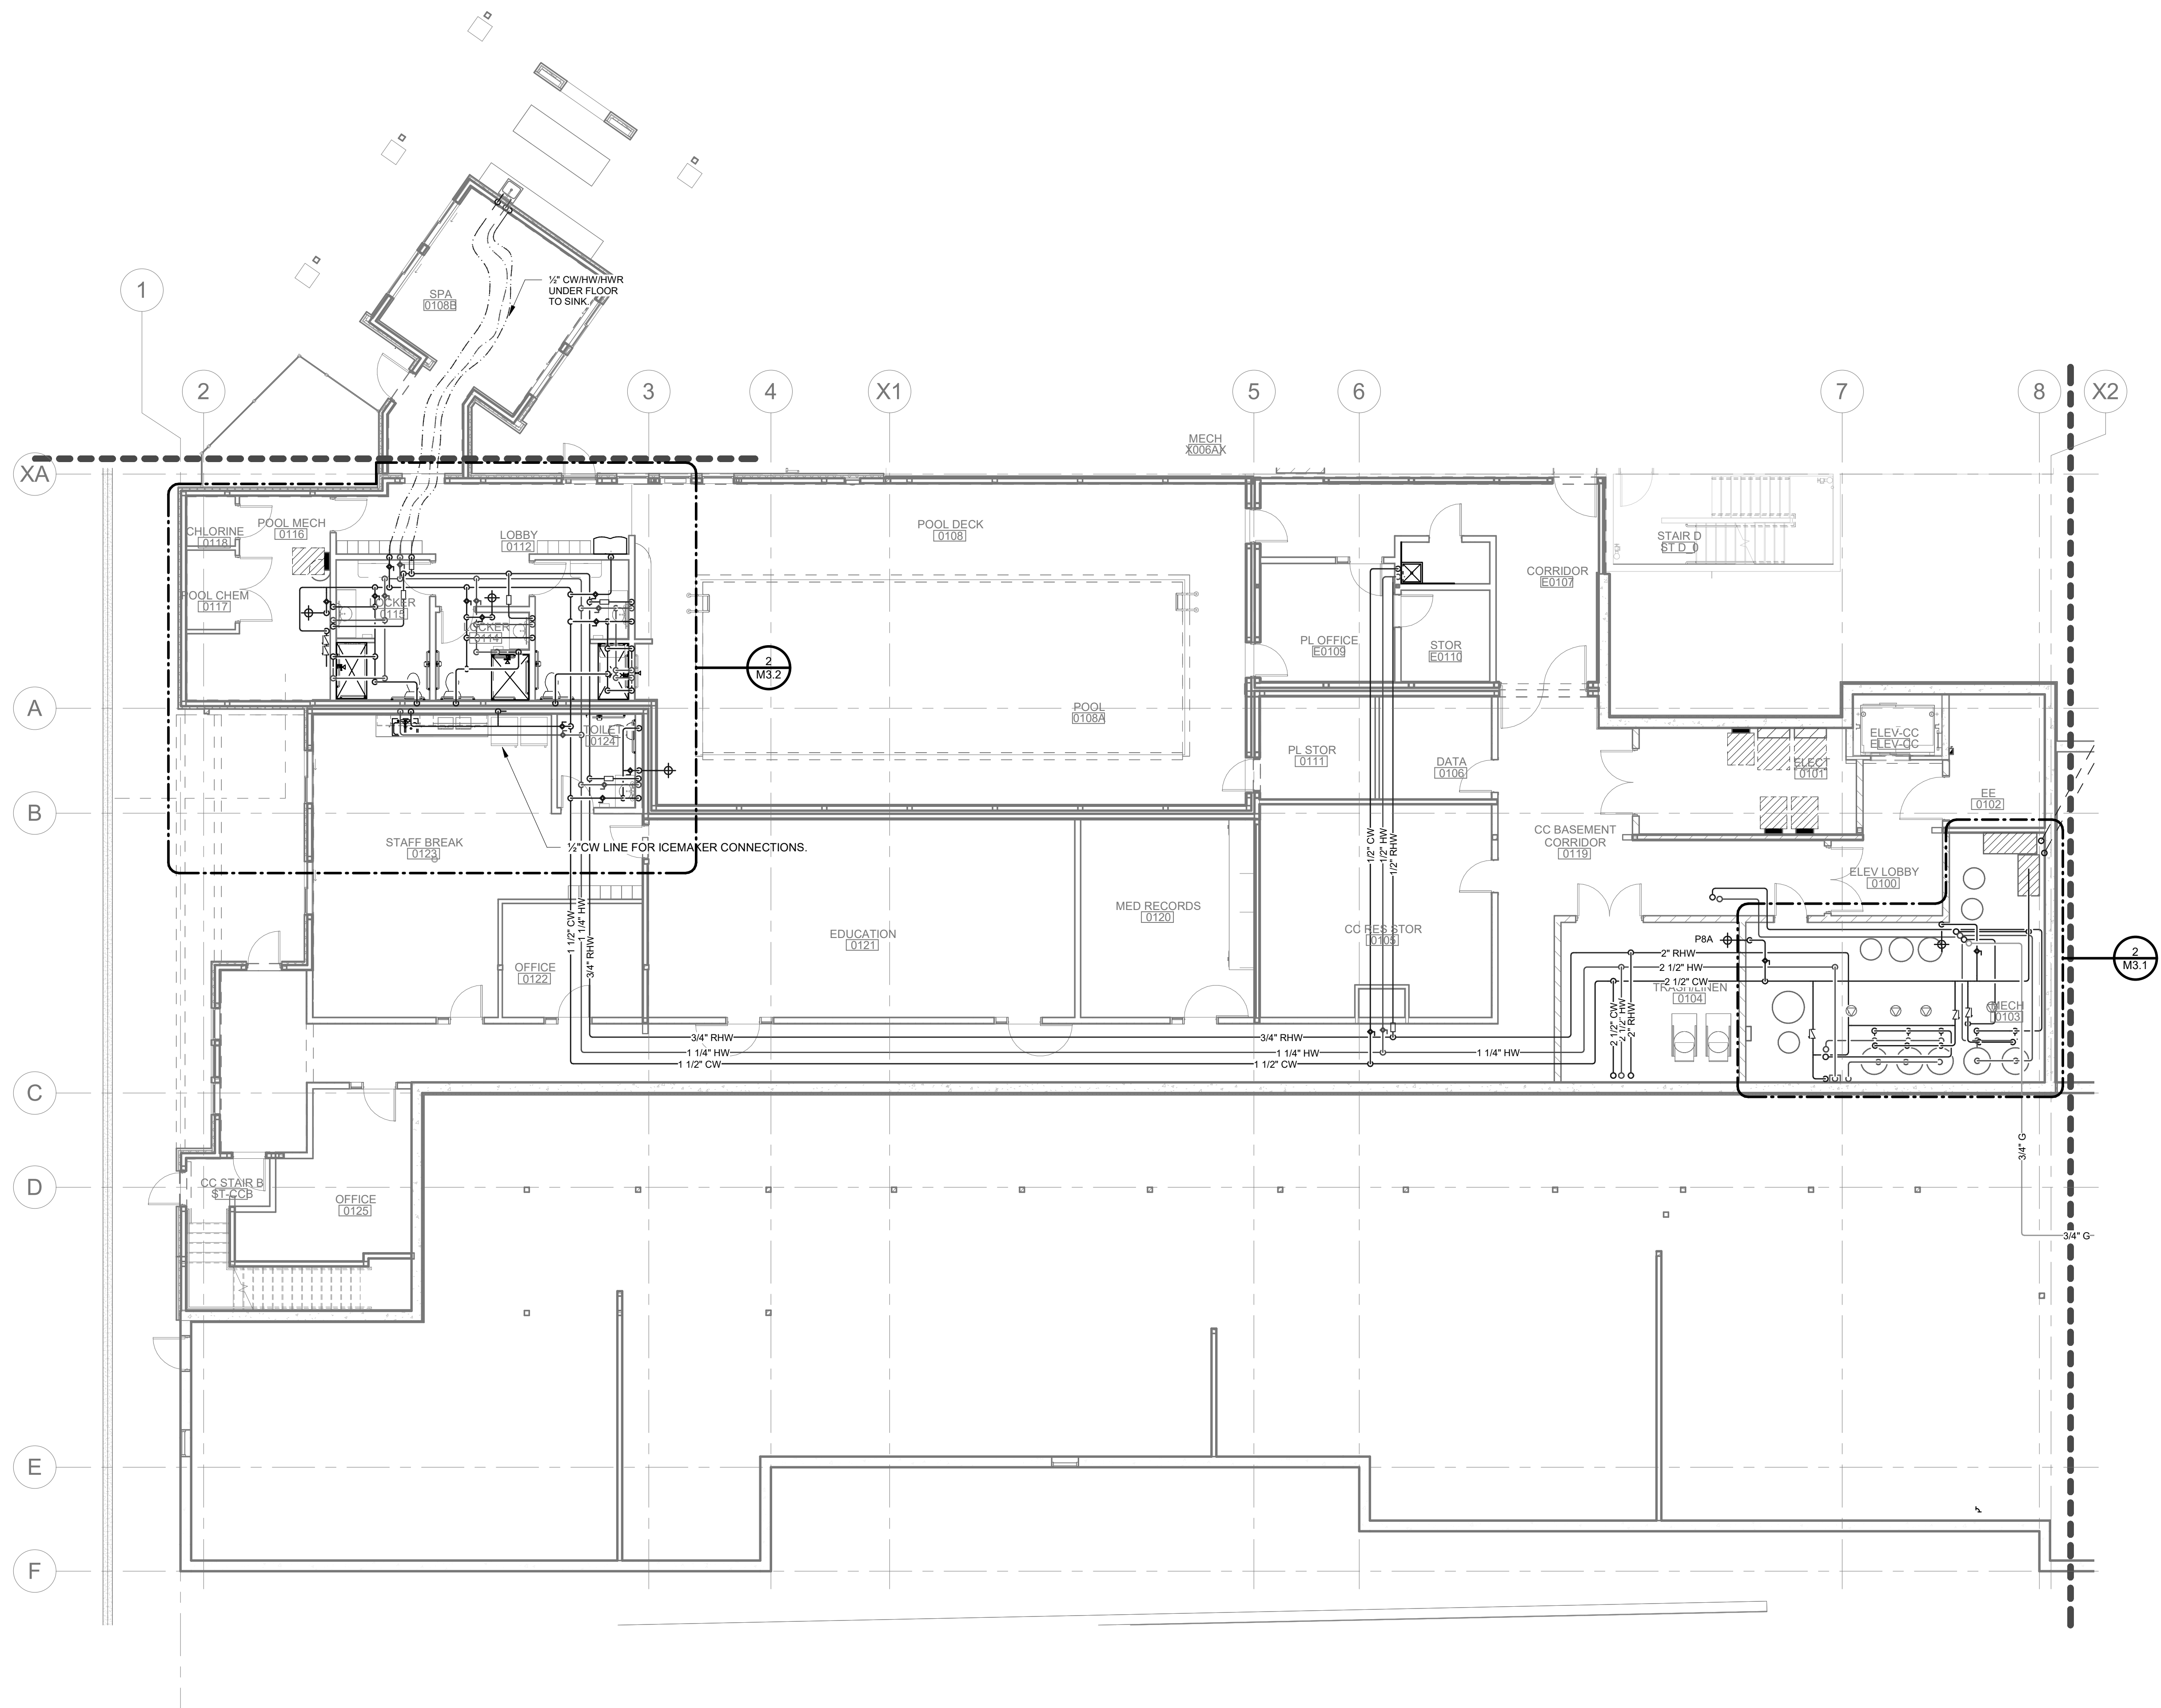

LEVEL 0 - WATER AND GAS FLOOR
PLAN NORTH
1/8" = 1'-0"

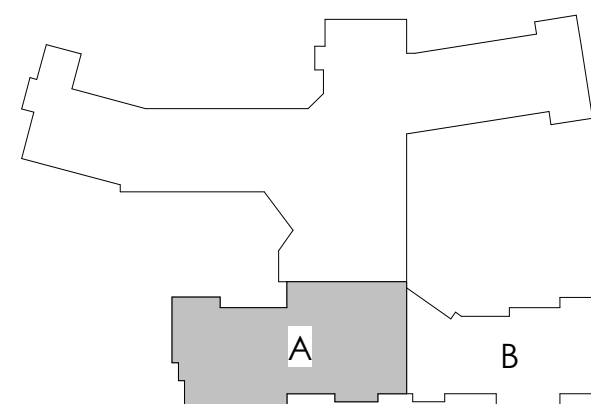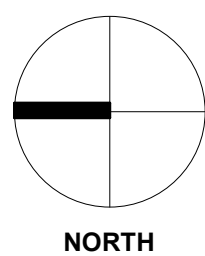

REFER TO SHEET M0.0 FOR NOTES




Mark R. Breneman
Signature

Mark R. Breneman
Typed or Printed Name

Mechanical
Discipline

12/02/24
Date

WESLEY BRADLEY PARK
PHASE 2 - CARE CENTER
707 39TH AVENUE SE
PUYALLUP, WA 98374

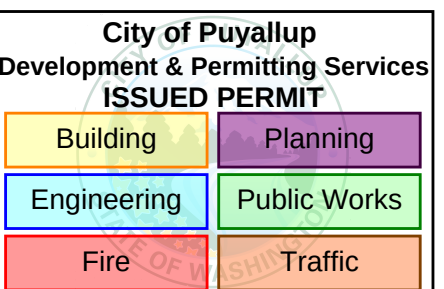

CARE CENTER
PERMIT SET
December 2, 2024

REVISIONS		
No.	Description	Date
1	PERMIT RESUBMIT	4/14/25


ISA202201
PROJECT NUMBER

RDB RDB
DRAWN BY CHECKED BY



WESLEY BRADLEY PARK
PHASE 2 - CARE CENTER

LEVEL 0 WATER & GAS
PLAN SOUTH

M1.0BB

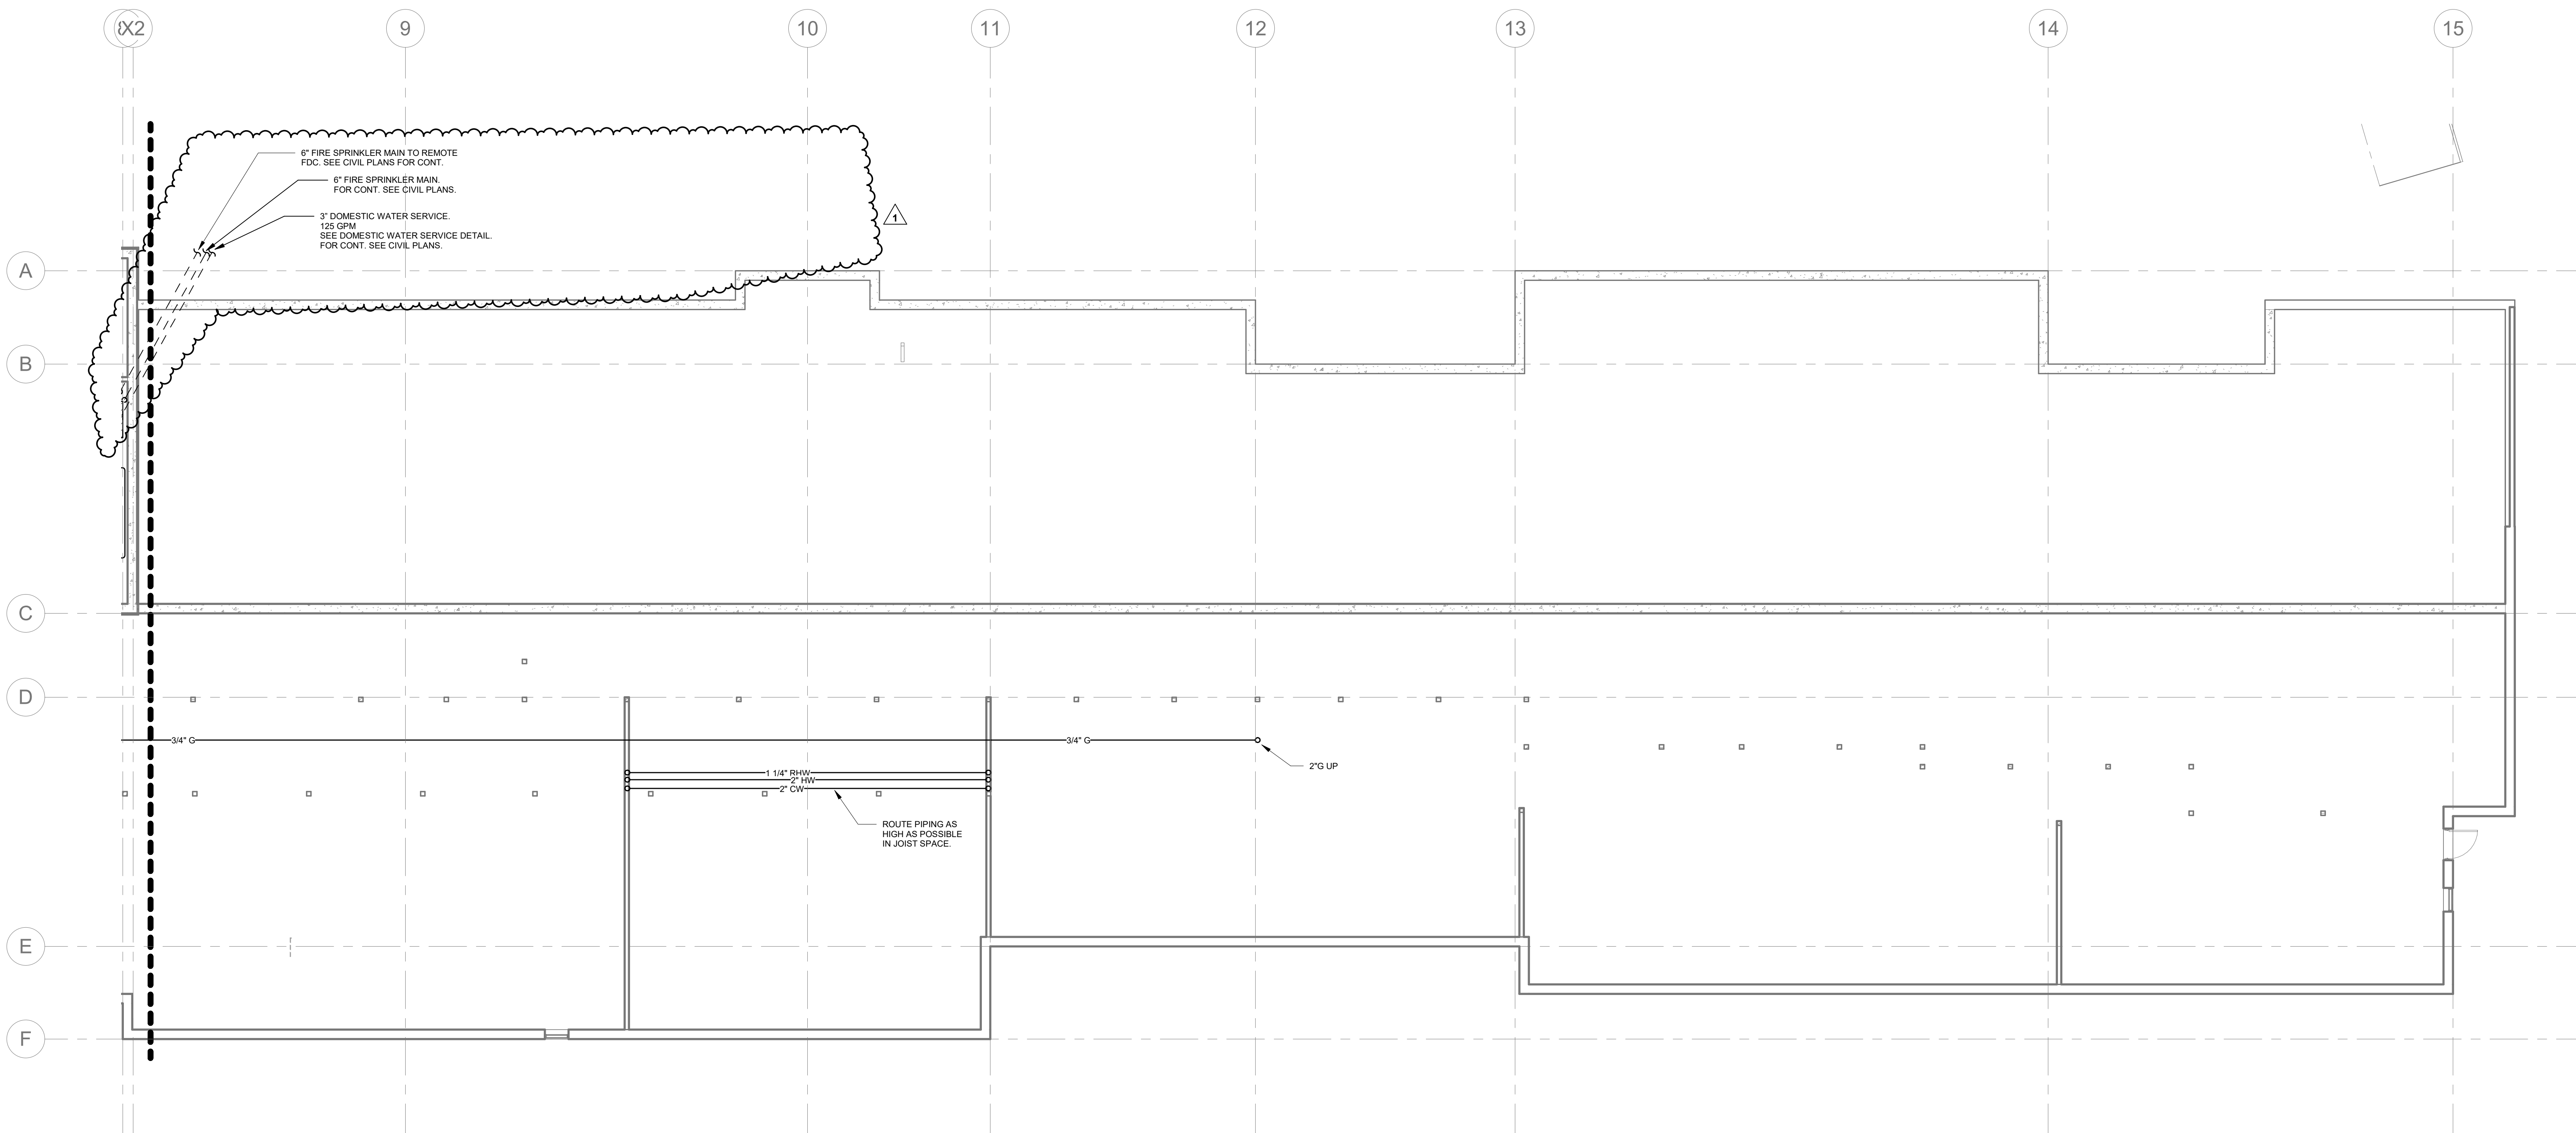

LEVEL 0 - WATER AND GAS FLOOR
PLAN SOUTH
1/8" = 1'-0"

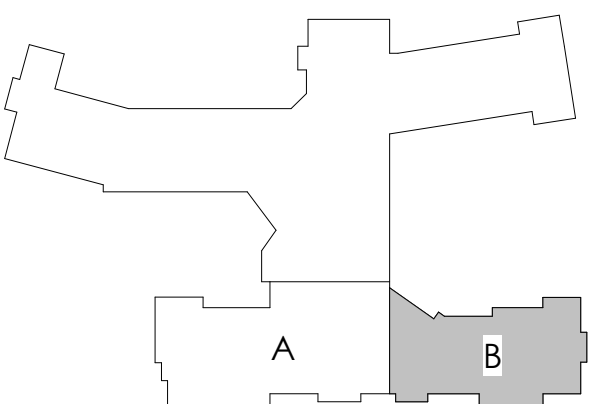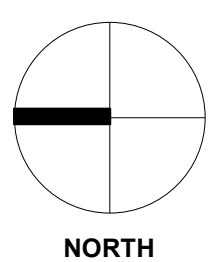

REFER TO SHEET M0.0 FOR NOTES




Mark R. Breneman
Typed or Printed Name

Discipline Date

12/02/24
Date

WESLEY BRADLEY PARK
PHASE 2 - CARE CENTER
707 39TH AVENUE SE
PUYALLUP, WA 98374

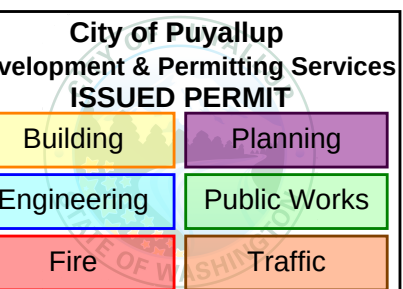

CARE CENTER
PERMIT SET
December 2, 2024

REVISIONS
No. Description Date


ISA202201
PROJECT NUMBER

RDB RDB
DRAWN BY CHECKED BY



WESLEY BRADLEY PARK
PHASE 2 - CARE CENTER

LEVEL 1 PLUMBING PLAN
NORTH

M1.1A

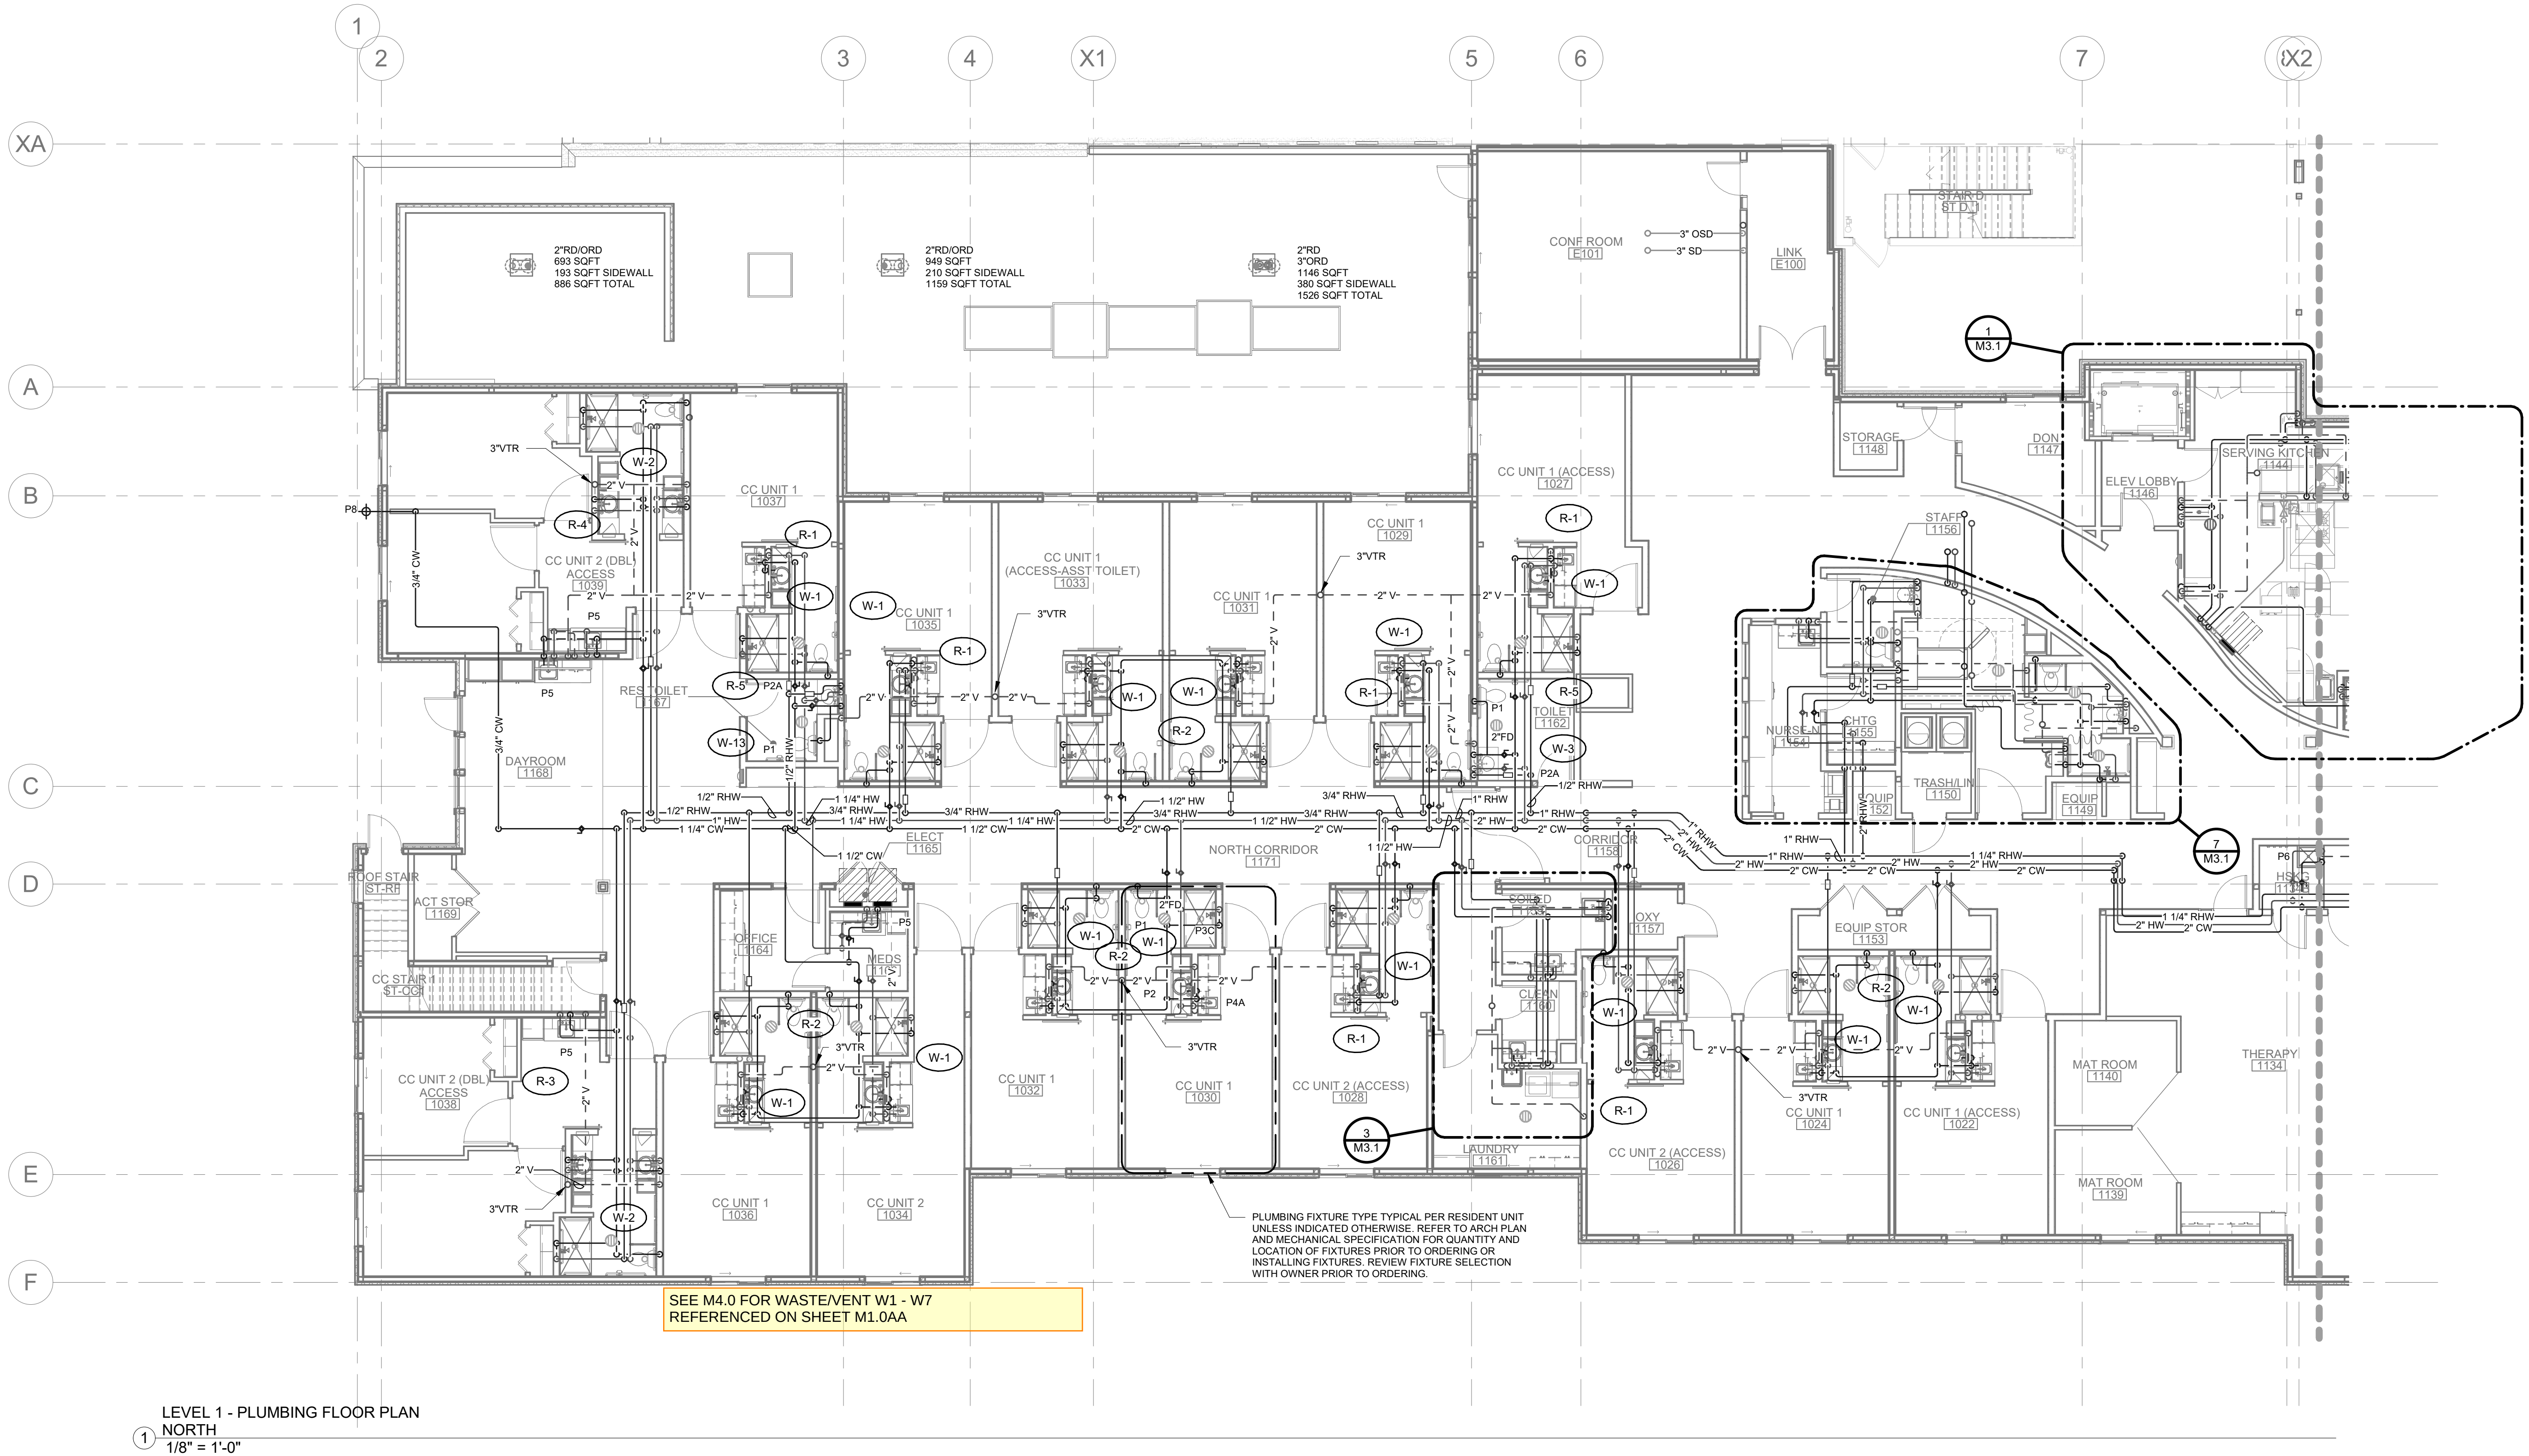

LEVEL 1 - PLUMBING FLOOR PLAN
NORTH
1/8" = 1'-0"

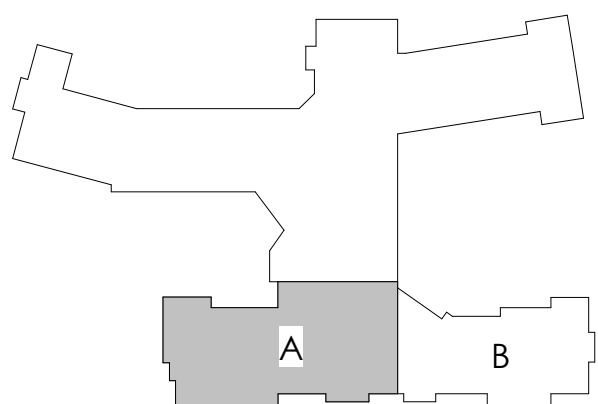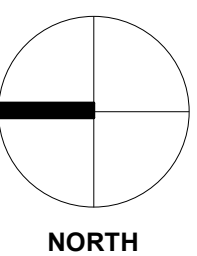


REFER TO SHEET M0.0 FOR NOTES



Mark R. Breneman
Typed or Printed Name

Mechanical 12/02/24
Discipline Date

WESLEY BRADLEY PARK
PHASE 2 - CARE CENTER
707 39TH AVENUE SE
PUYALLUP, WA 98374

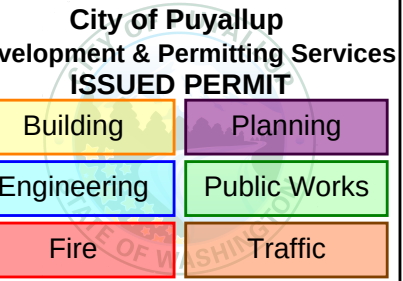

CARE CENTER
PERMIT SET
December 2, 2024

REVISIONS		
No.	Description	Date


ISA202201
PROJECT NUMBER

RDB RDB
DRAWN BY CHECKED BY

WESLEY BRADLEY PARK
PHASE 2 - CARE CENTER

LEVEL 1 PLUMBING PLAN
SOUTH

M1.1B

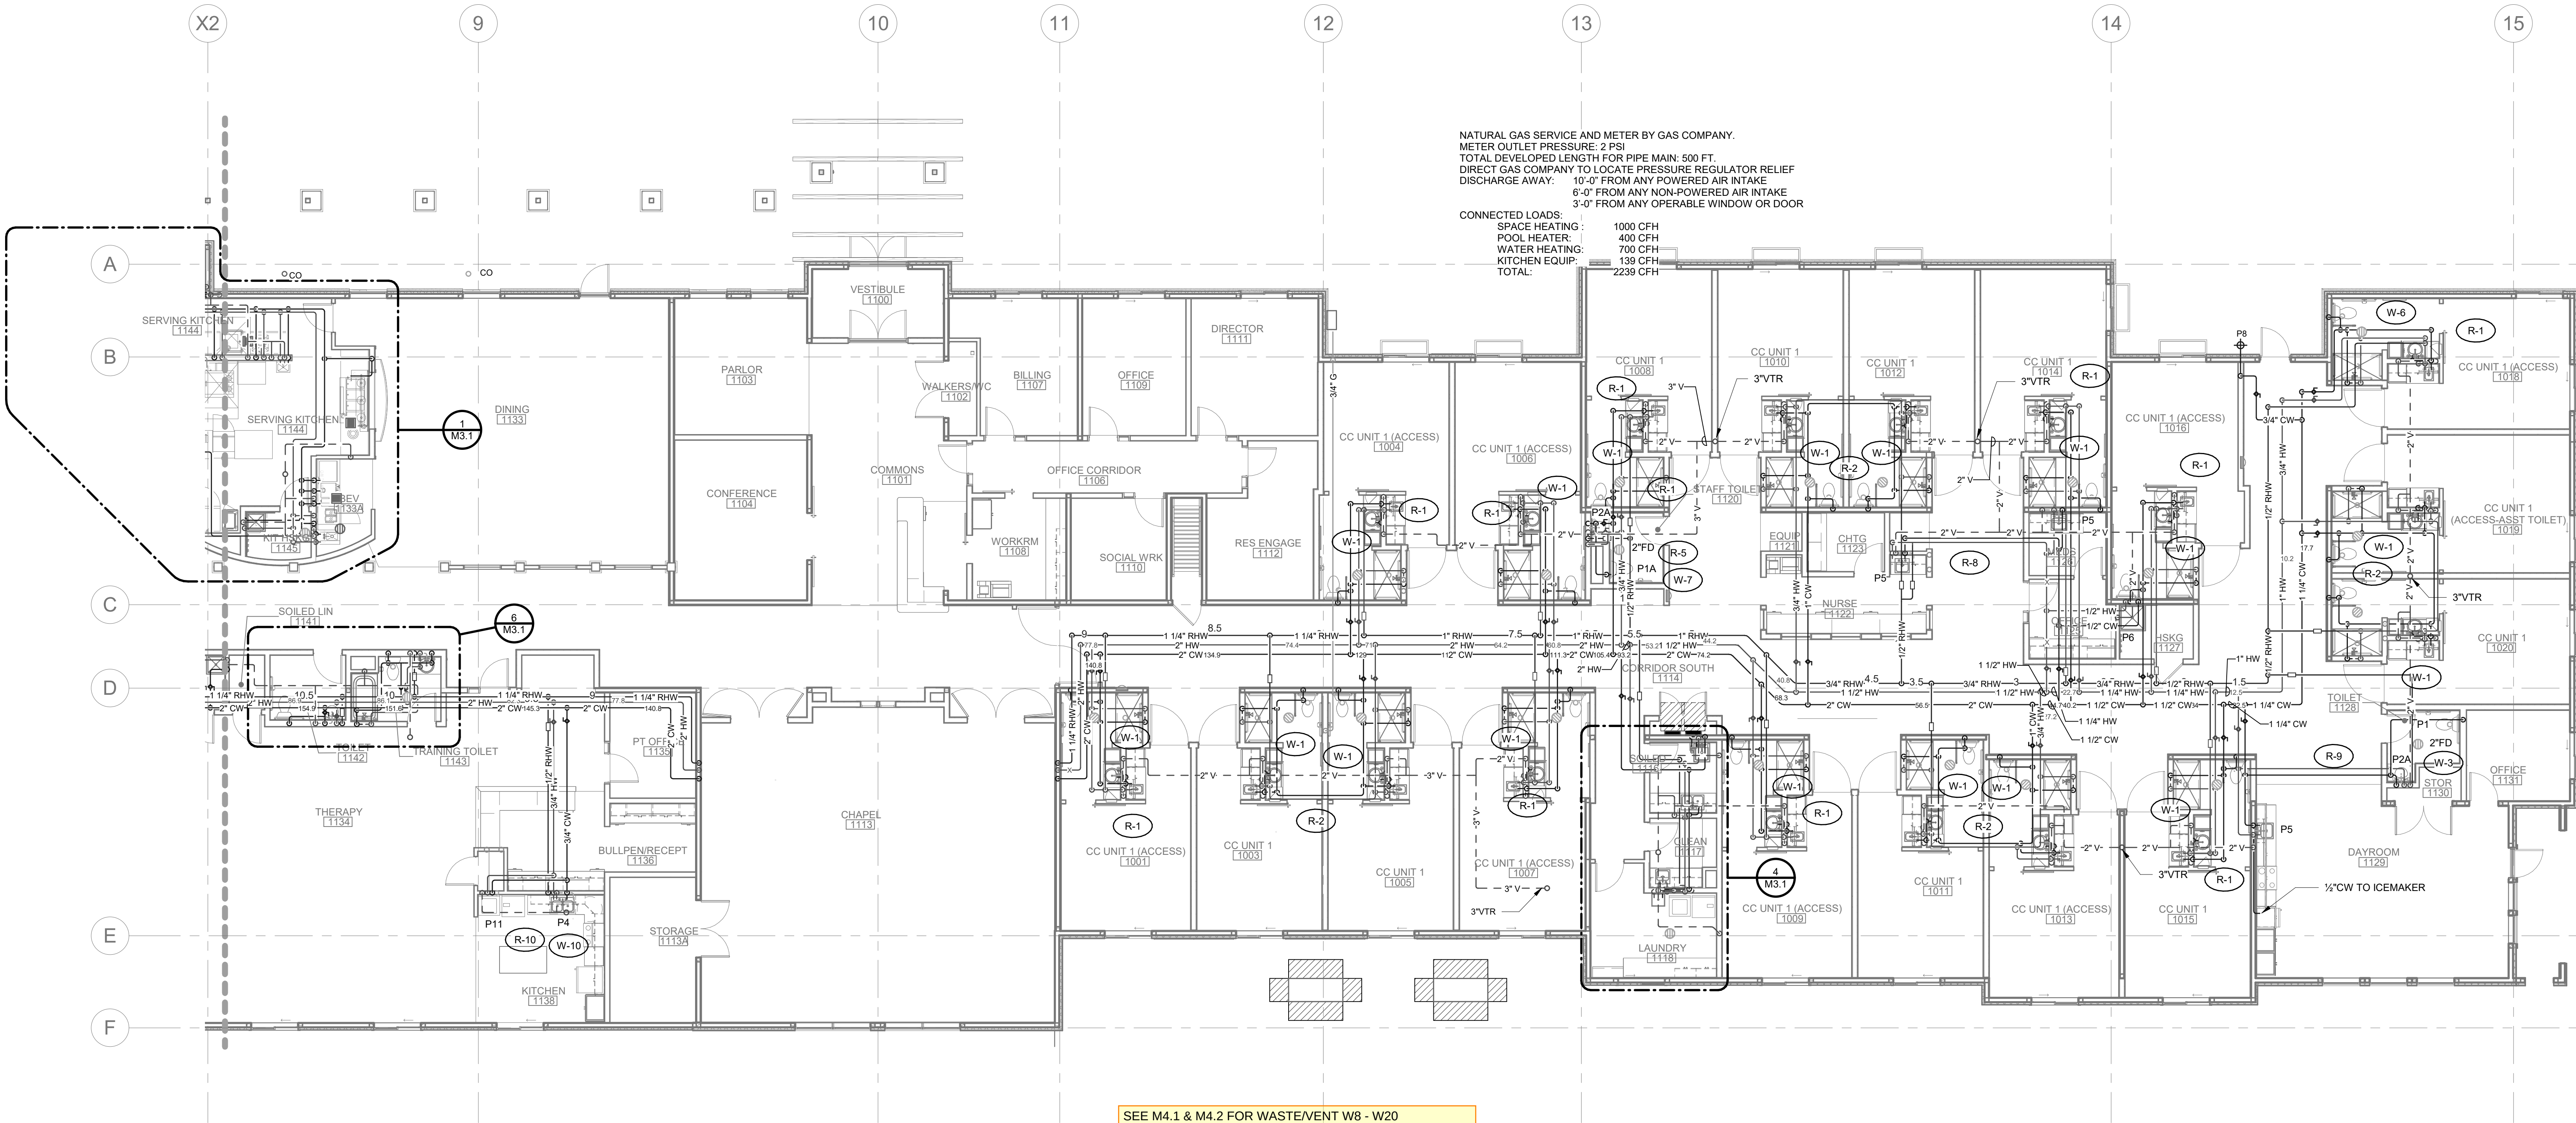




Mark R. Breneman
Typed or Printed Name

Mechanical 12/02/24
Discipline Date

WESLEY BRADLEY PARK
PHASE 2 - CARE CENTER
707 39TH AVENUE SE
PUYALLUP, WA 98374

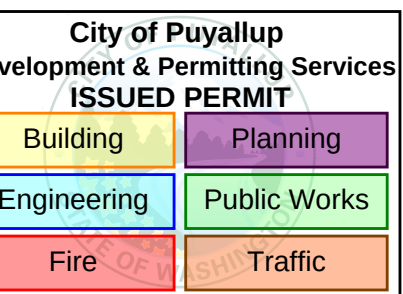


CARE CENTER
PERMIT SET
December 2, 2024

REVISIONS
No. Description Date

ISA202201
PROJECT NUMBER
DCA MRB
DRAWN BY CHECKED BY
WESLEY BRADLEY PARK
PHASE 2 - CARE CENTER

LEVEL 0 HVAC PLAN
NORTH

M2.0A

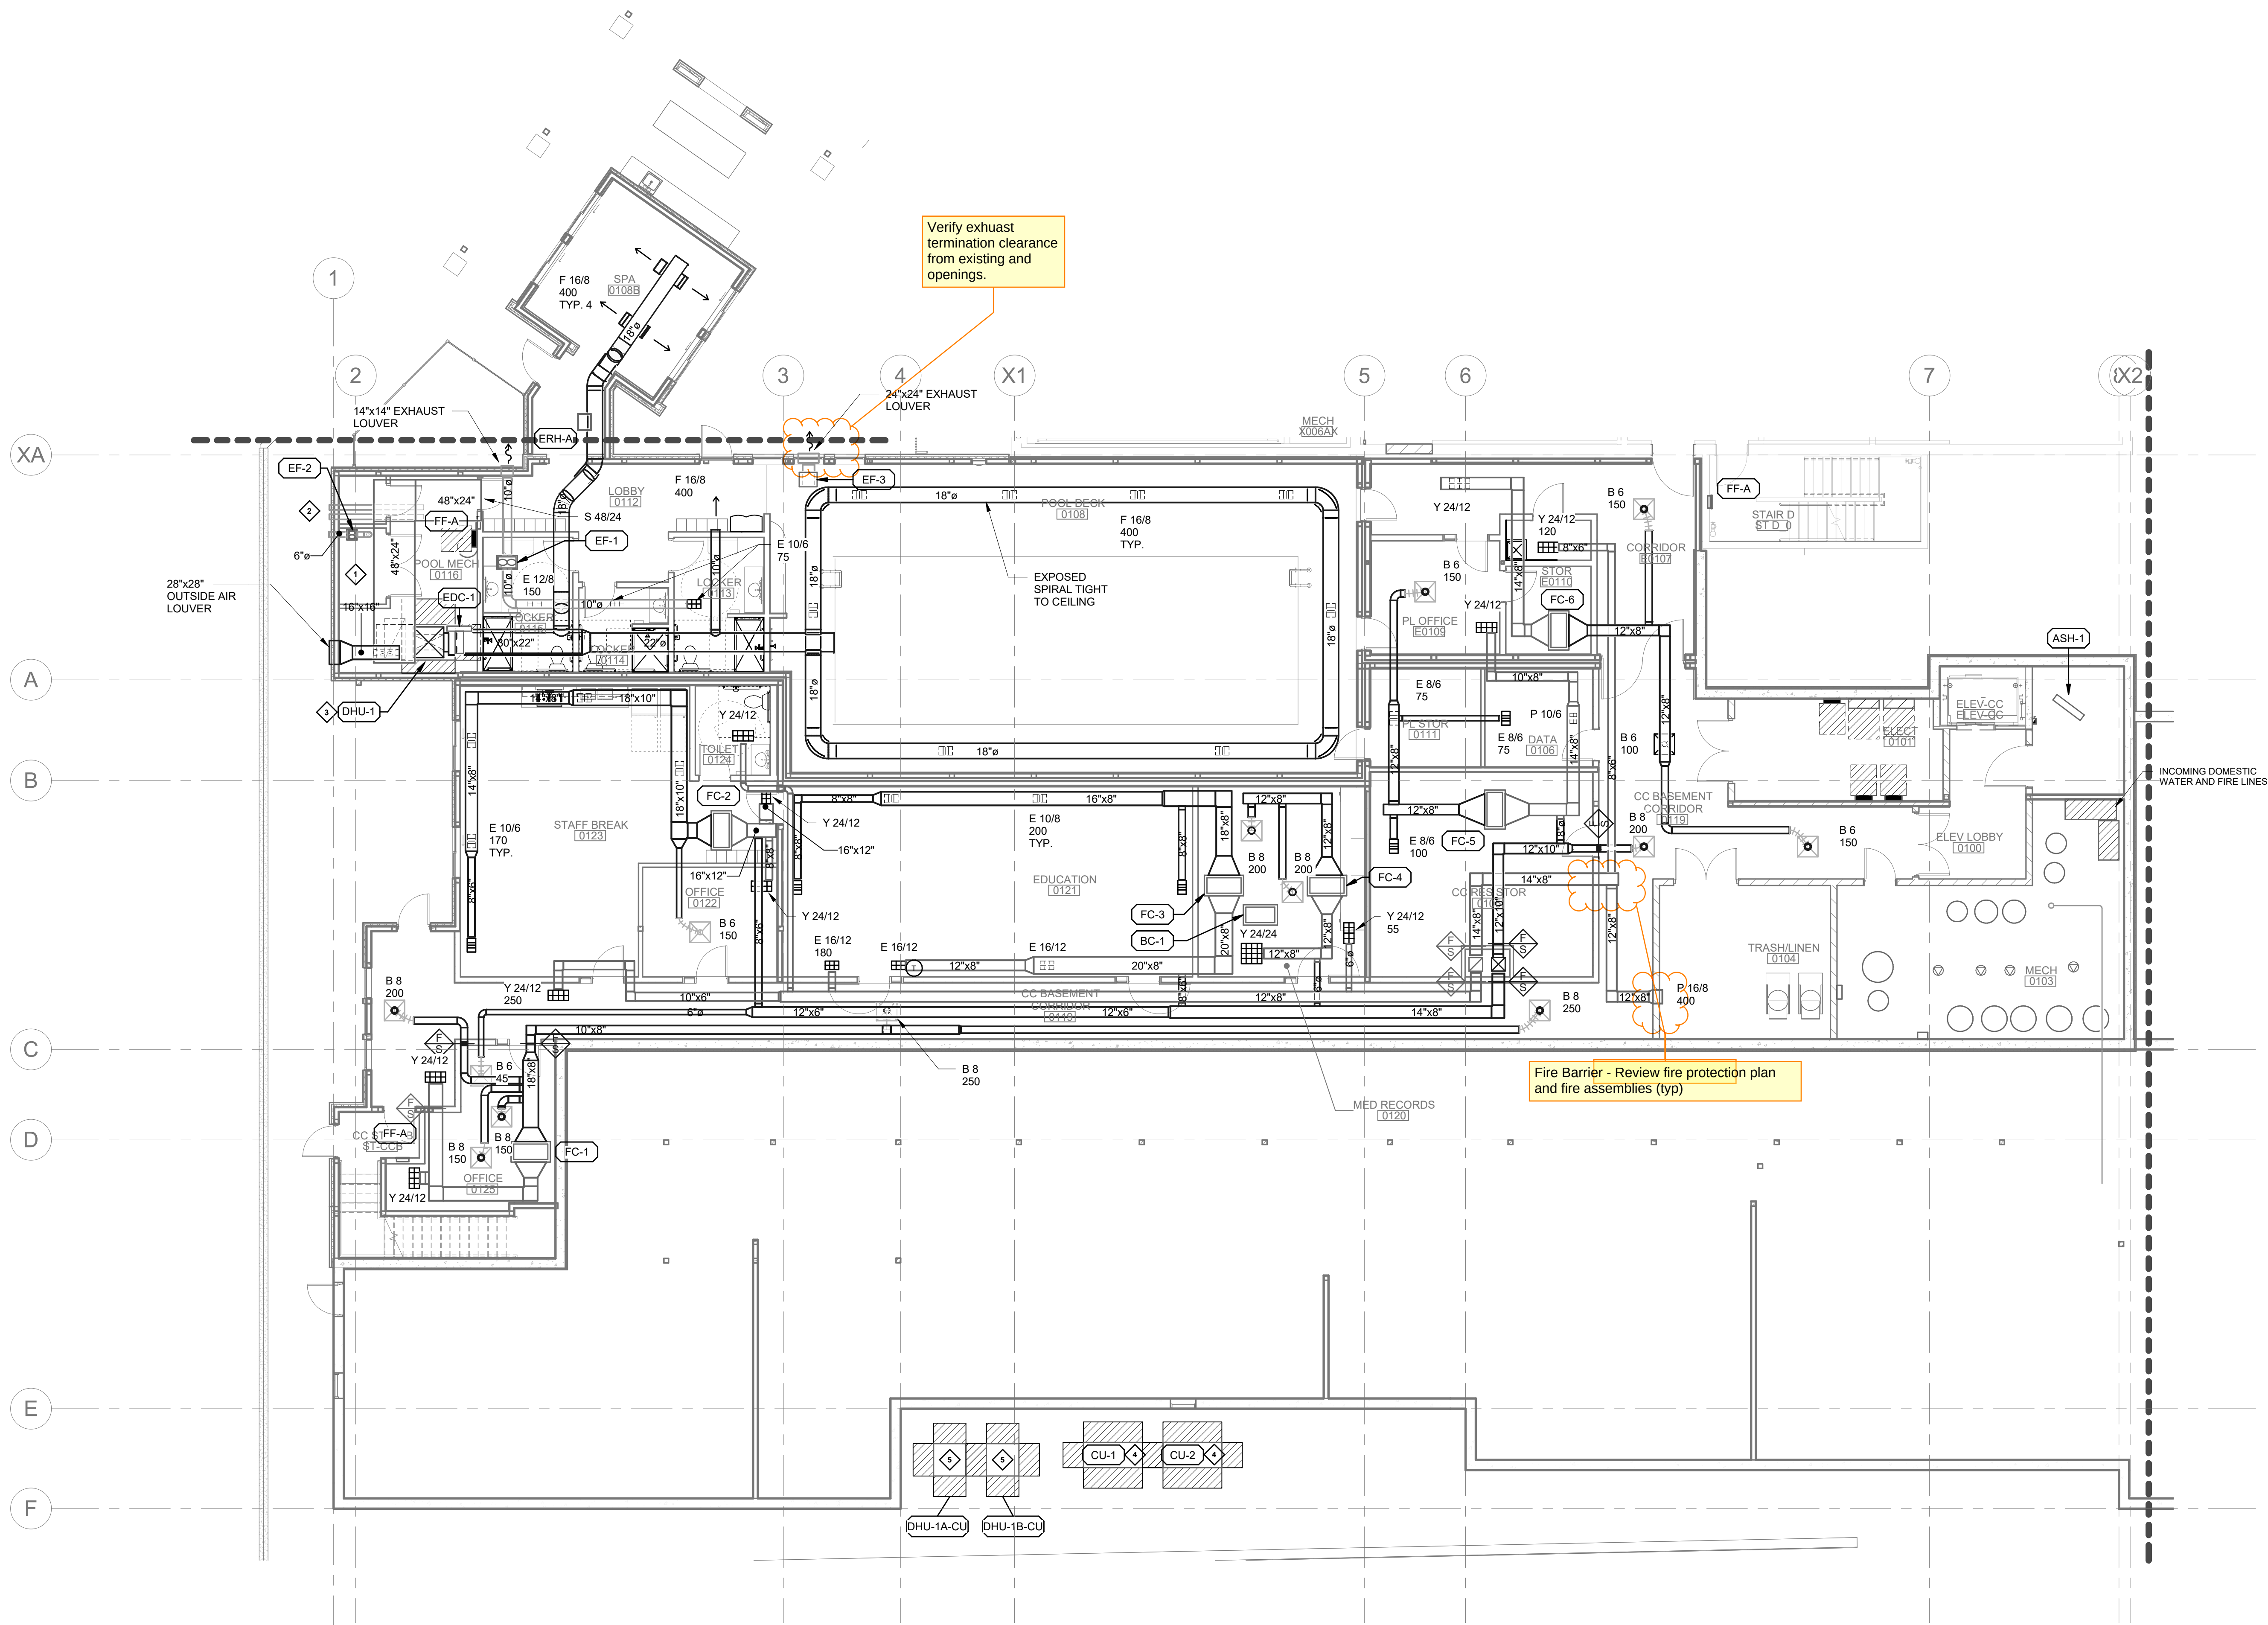



1 LEVEL 0 - HVAC FLOOR PLAN NORTH
1/8" = 1'-0"

KEY NOTES:

- POOL AND SPA EQUIPMENT (PROVIDED BY OTHERS).
- HORIZONTAL FLUE VENT HOOD. INSTALL EXHAUST MINIMUM 10' FROM OPERABLE OPENINGS AND MECHANICAL AIR INTAKES.
- POOL DEHUMIDIFICATION UNIT SHALL BE INSTALLED ON 4" CONCRETE PAD OR APPROVED HOUSEKEEPING PAD EQUIVALENT.
- VRF OUTDOOR CONDENSING UNIT. INSTALL ON LEVEL CONCRETE PAD OR APPROVED HOUSEKEEPING PAD.
- POOL REMOTE AIR-COOLED CONDENSER UNIT. INSTALL ON LEVEL CONCRETE PAD OR APPROVED HOUSEKEEPING PAD.

SHEET NOTES:

1. VRF EQUIPMENT (BC/SUB-BC CONTROLLERS, OUTDOOR CONDENSING UNITS, INDOOR FAN COIL UNITS) ARE SHOWN ON FLOOR PLANS. REFER TO VRF PIPING DIAGRAMS ON M5.1 & M5.2 FOR ADDITIONAL INFORMATION.

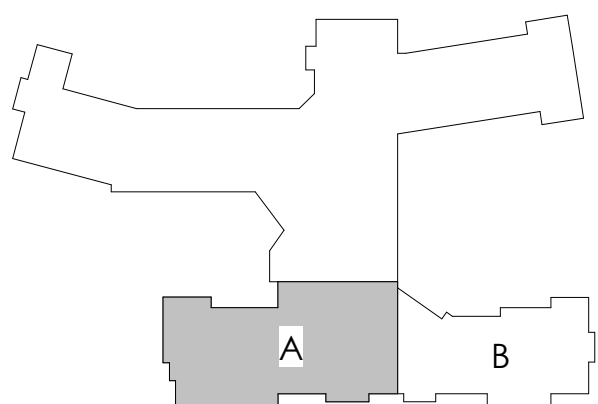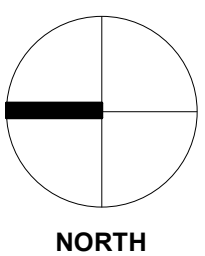

REFER TO SHEET M0.0 FOR NOTES




Mark R. Breneman
Signature

Mark R. Breneman
Typed or Printed Name

Mechanical 12/02/24
Discipline Date

WESLEY BRADLEY PARK
PHASE 2 - CARE CENTER
707 39TH AVENUE SE
PUYALLUP, WA 98374

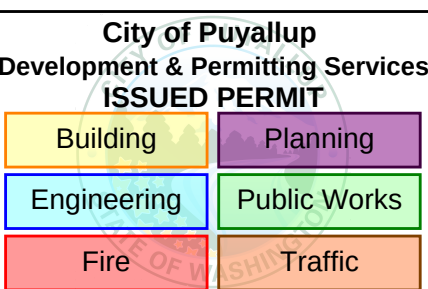

CARE CENTER
PERMIT SET
December 2, 2024

REVISIONS

No.	Description	Date
-----	-------------	------


ISA202201
PROJECT NUMBER

DCA MRB
DRAWN BY CHECKED BY

WESLEY BRADLEY PARK
PHASE 2 - CARE CENTER

LEVEL 1 HVAC PLAN
NORTH

M2.1A

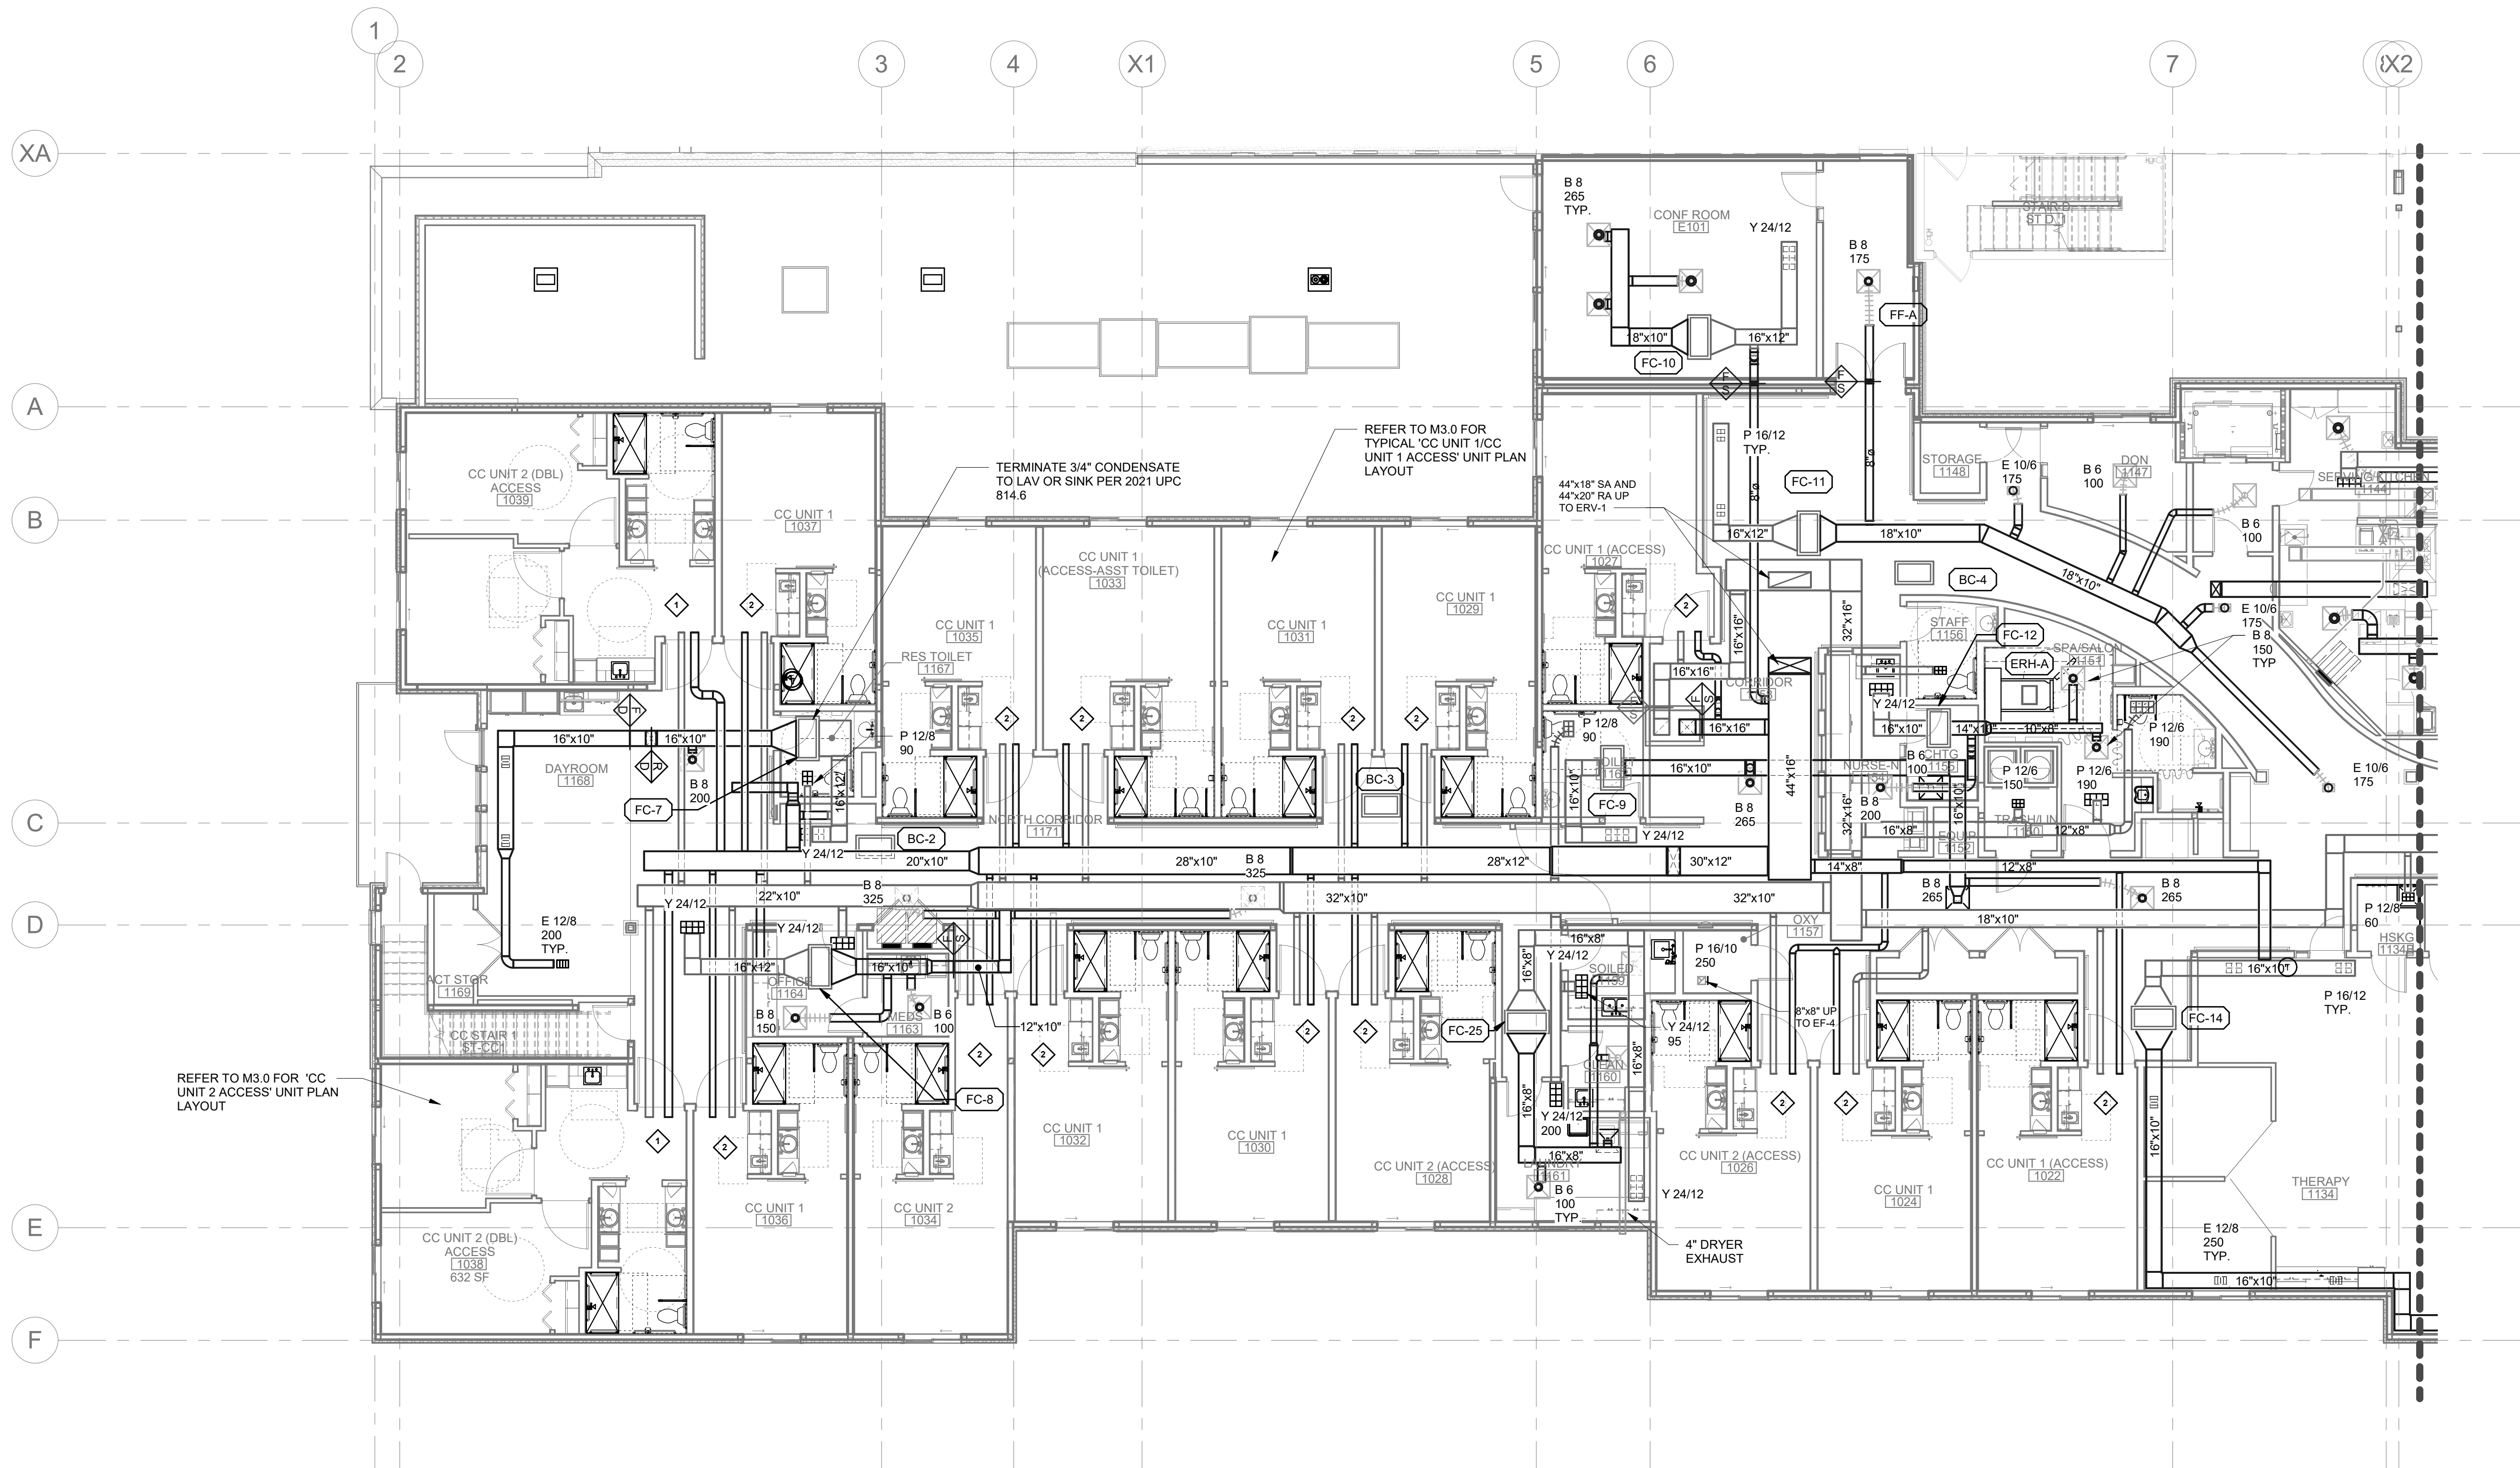



1 LEVEL 1 - HVAC FLOOR PLAN NORTH
1/8" = 1'-0"

KEY NOTES:

- 6" DIA. OUTSIDE AIR AND EXHAUST DUCT SERVING BATHROOM. REFER TO TYPICAL UNIT PLAN 'CC UNIT 2' ON M3.0 FOR CONTINUATION.
- 6" DIA. OUTSIDE AIR AND EXHAUST DUCT FROM CORRIDOR. REFER TO TYPICAL UNIT PLAN 'CC UNIT 1' ON M3.0 FOR CONTINUATION.

SHEET NOTES:

- 1. VRF EQUIPMENT (BC/SUB-BC CONTROLLERS, OUTDOOR CONDENSING UNITS, INDOOR FAN COIL UNITS) ARE SHOWN ON FLOOR PLANS. REFER TO VRF PIPING DIAGRAMS ON M5.1 & M5.2 FOR ADDITIONAL INFORMATION.

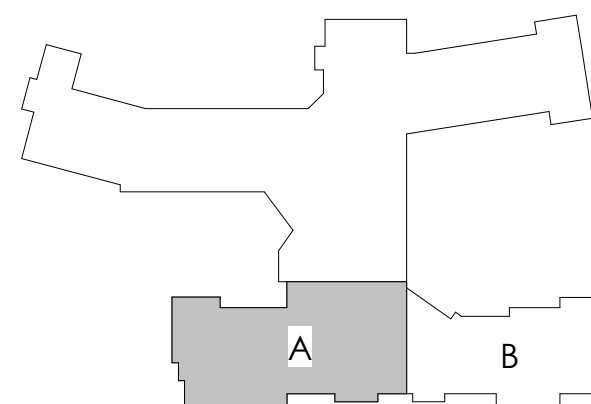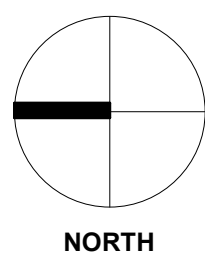

REFER TO SHEET M0.0 FOR NOTES




Signature

Mark R. Brenqman
Typed or Printed Name

Mechanical	12/02/24
Discipline	Date

WESLEY BRADLEY PARK
PHASE 2 - CARE CENTER
707 39TH AVENUE SE
PUYALLUP, WA 98374

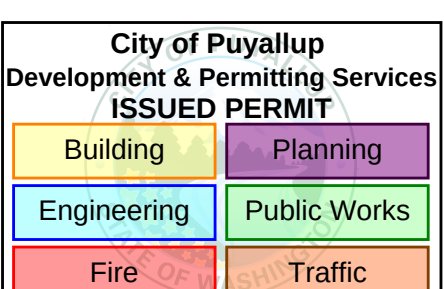

CARE CENTER
PERMIT SET
December 2, 2024

REVISIONS

Description	Date
-------------	------


A202201
PROJECT NUMBER

CA MRB
 DRAWN BY CHECKED BY

ESLEY BRADLEY PARK
PHASE 2 - CARE CENTER

LEVEL 1 HVAC PLAN
OUTH

M2.1 B

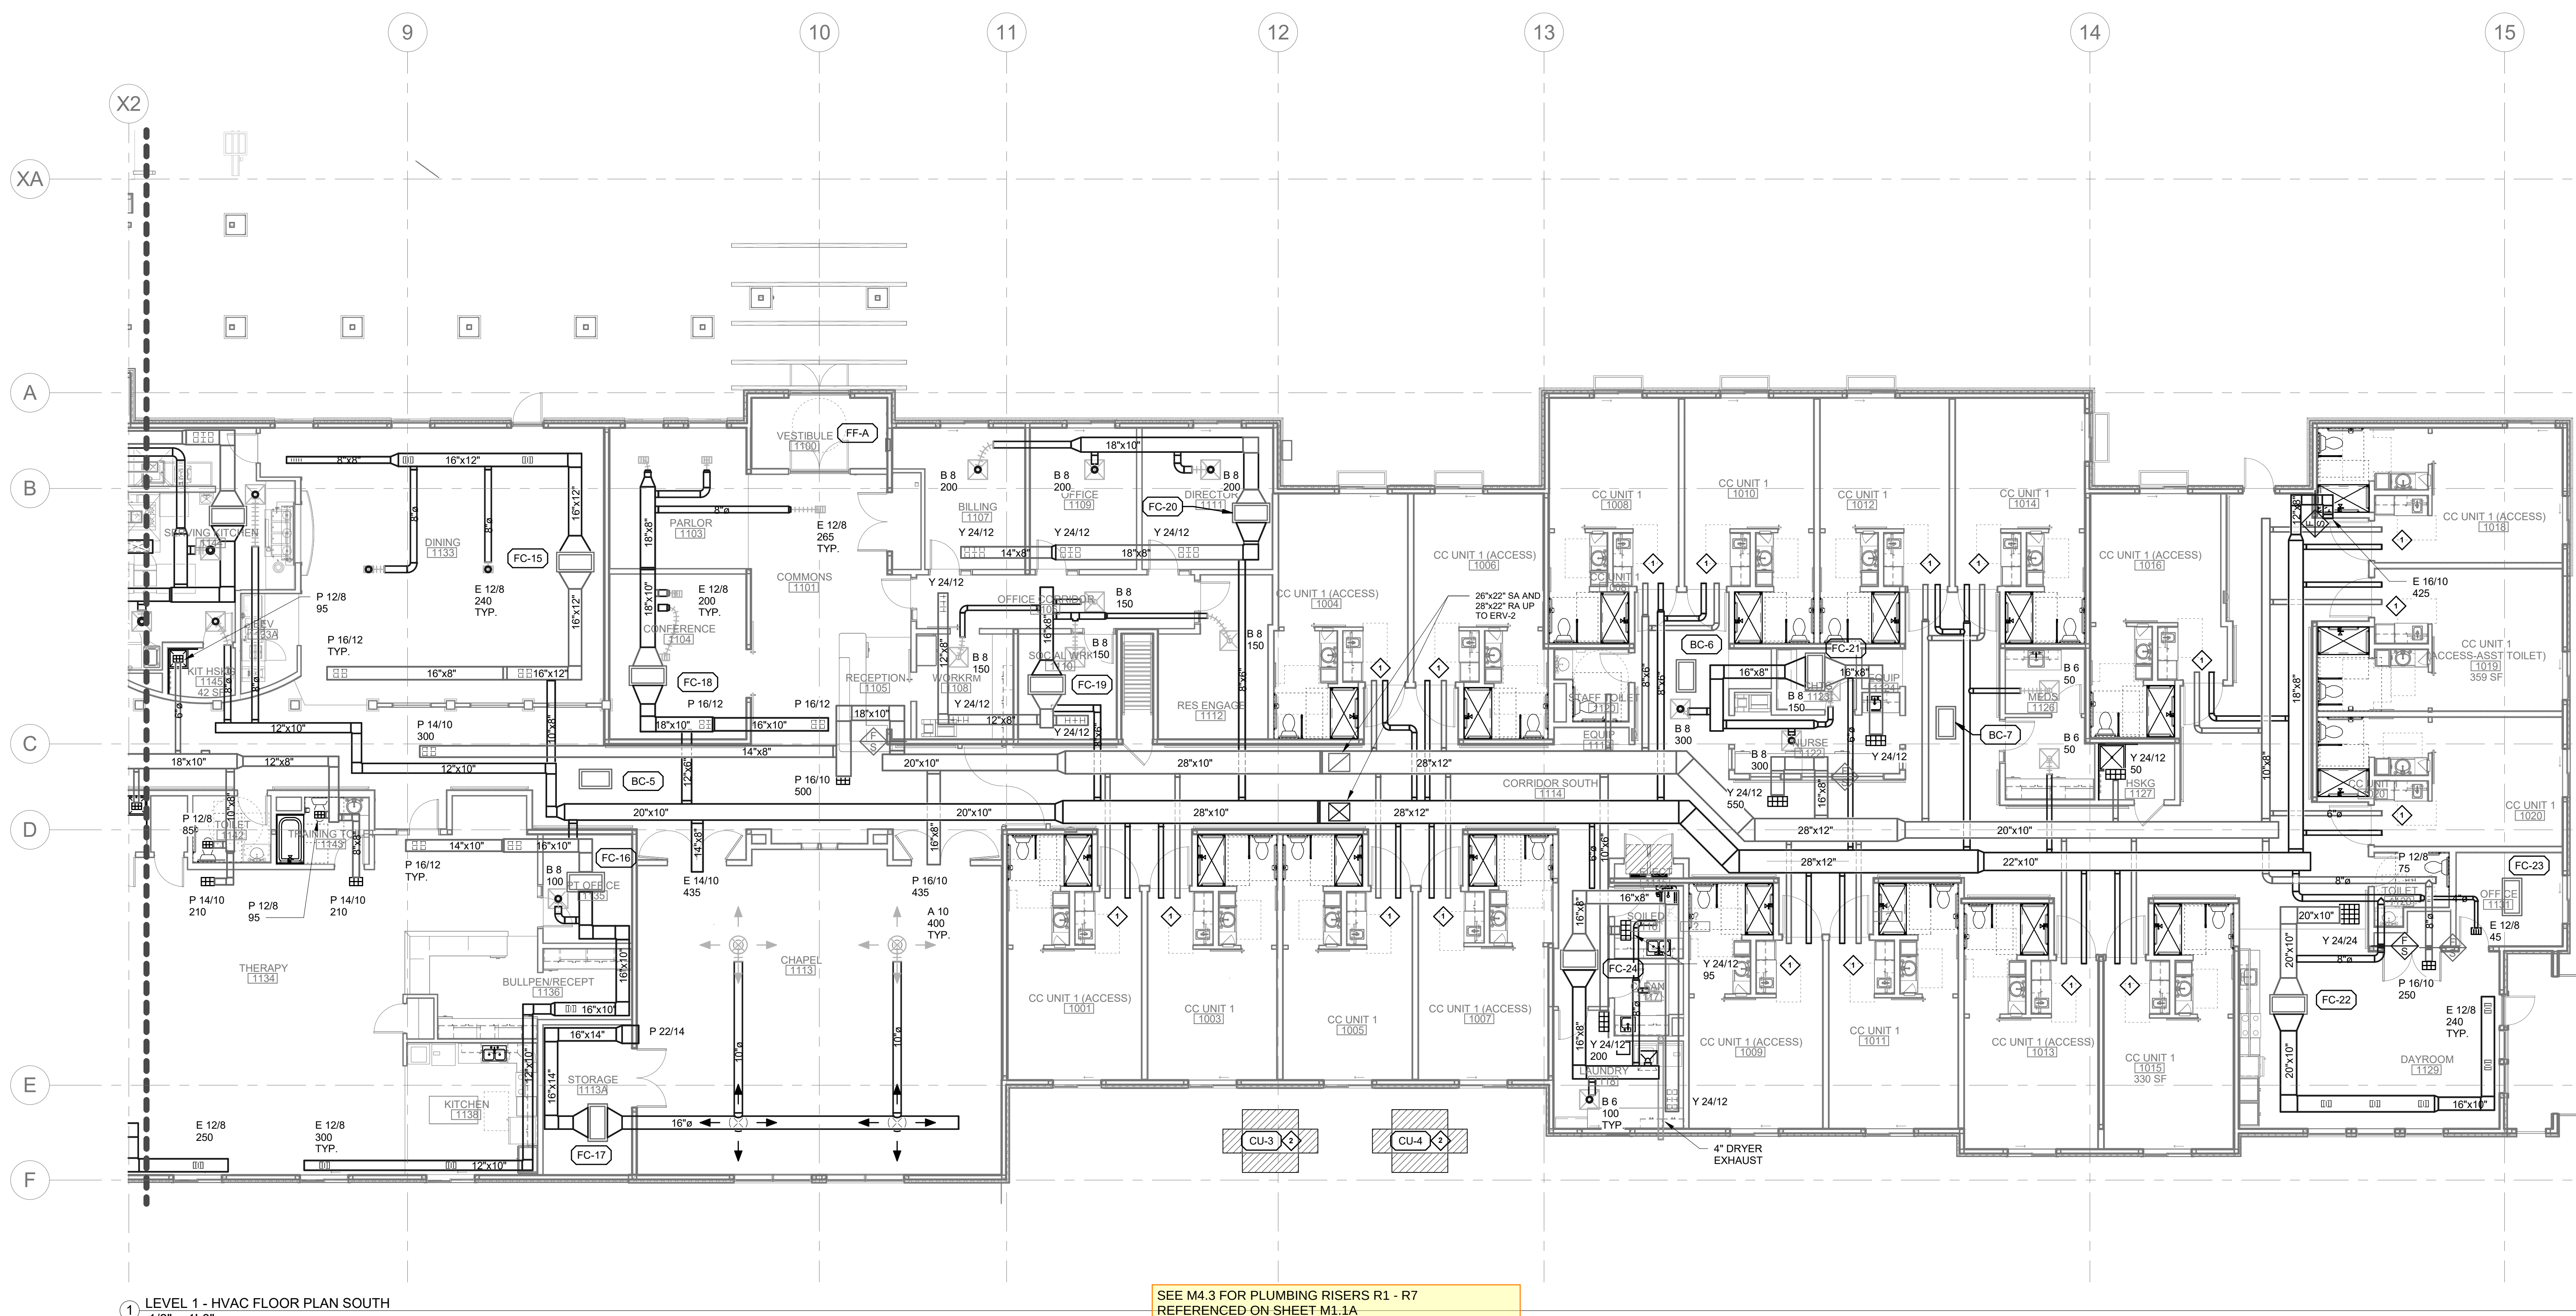



SEE M4.3 FOR PLUMBING RISERS R1 - R7
REFERENCED ON SHEET M1-1A

KEY NOTES:

- 1 6" DIA. OUTSIDE AIR AND EXHAUST DUCT FROM CORRIDOR. REFER TO TYPICAL UNIT PLAN 'CC UNIT 1' ON M3.0 FOR CONTINUATION.
- 2 VRF OUTDOOR CONDENSING UNIT. INSTALL ON LEVEL CONCRETE PAD OR APPROVED HOUSEKEEPING PAD.

SHEET NOTES:

1. VRF EQUIPMENT (BC/SUB-BC CONTROLLERS, OUTDOOR CONDENSING UNITS, INDOOR FAN COIL UNITS) ARE SHOWN ON FLOOR PLANS. REFER TO VRF PIPING DIAGRAMS ON M5.1 & M5.2 FOR ADDITIONAL INFORMATION.

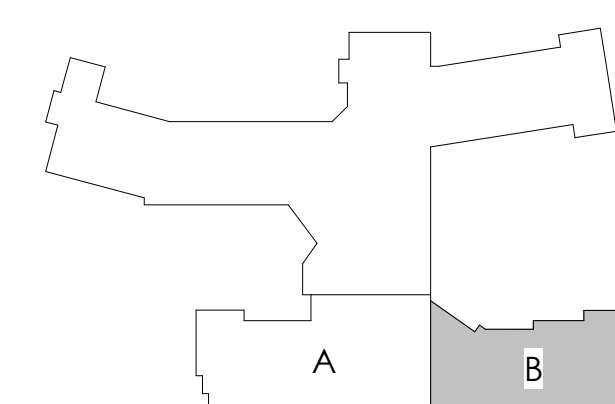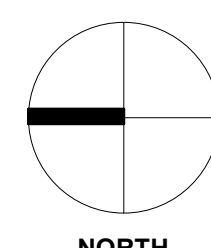

REFER TO SHEET M0.0 FOR NOTES




Mark R. Breneman
Signature

Mark R. Breneman
Typed or Printed Name

Mechanical
Discipline

12/02/24
Date

WESLEY BRADLEY PARK
PHASE 2 - CARE CENTER
707 39TH AVENUE SE
PUYALLUP, WA 98374

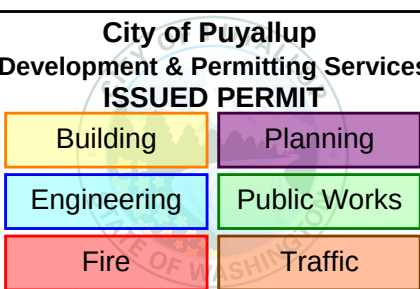

CARE CENTER
PERMIT SET
December 2, 2024

REVISIONS

No.	Description	Date
-----	-------------	------


ISA202201
PROJECT NUMBER

RDB/DCA RDB/MRB
DRAWN BY CHECKED BY

WESLEY BRADLEY PARK
PHASE 2 - CARE CENTER

MECHANICAL ROOF
PLAN NORTH



M2.2A

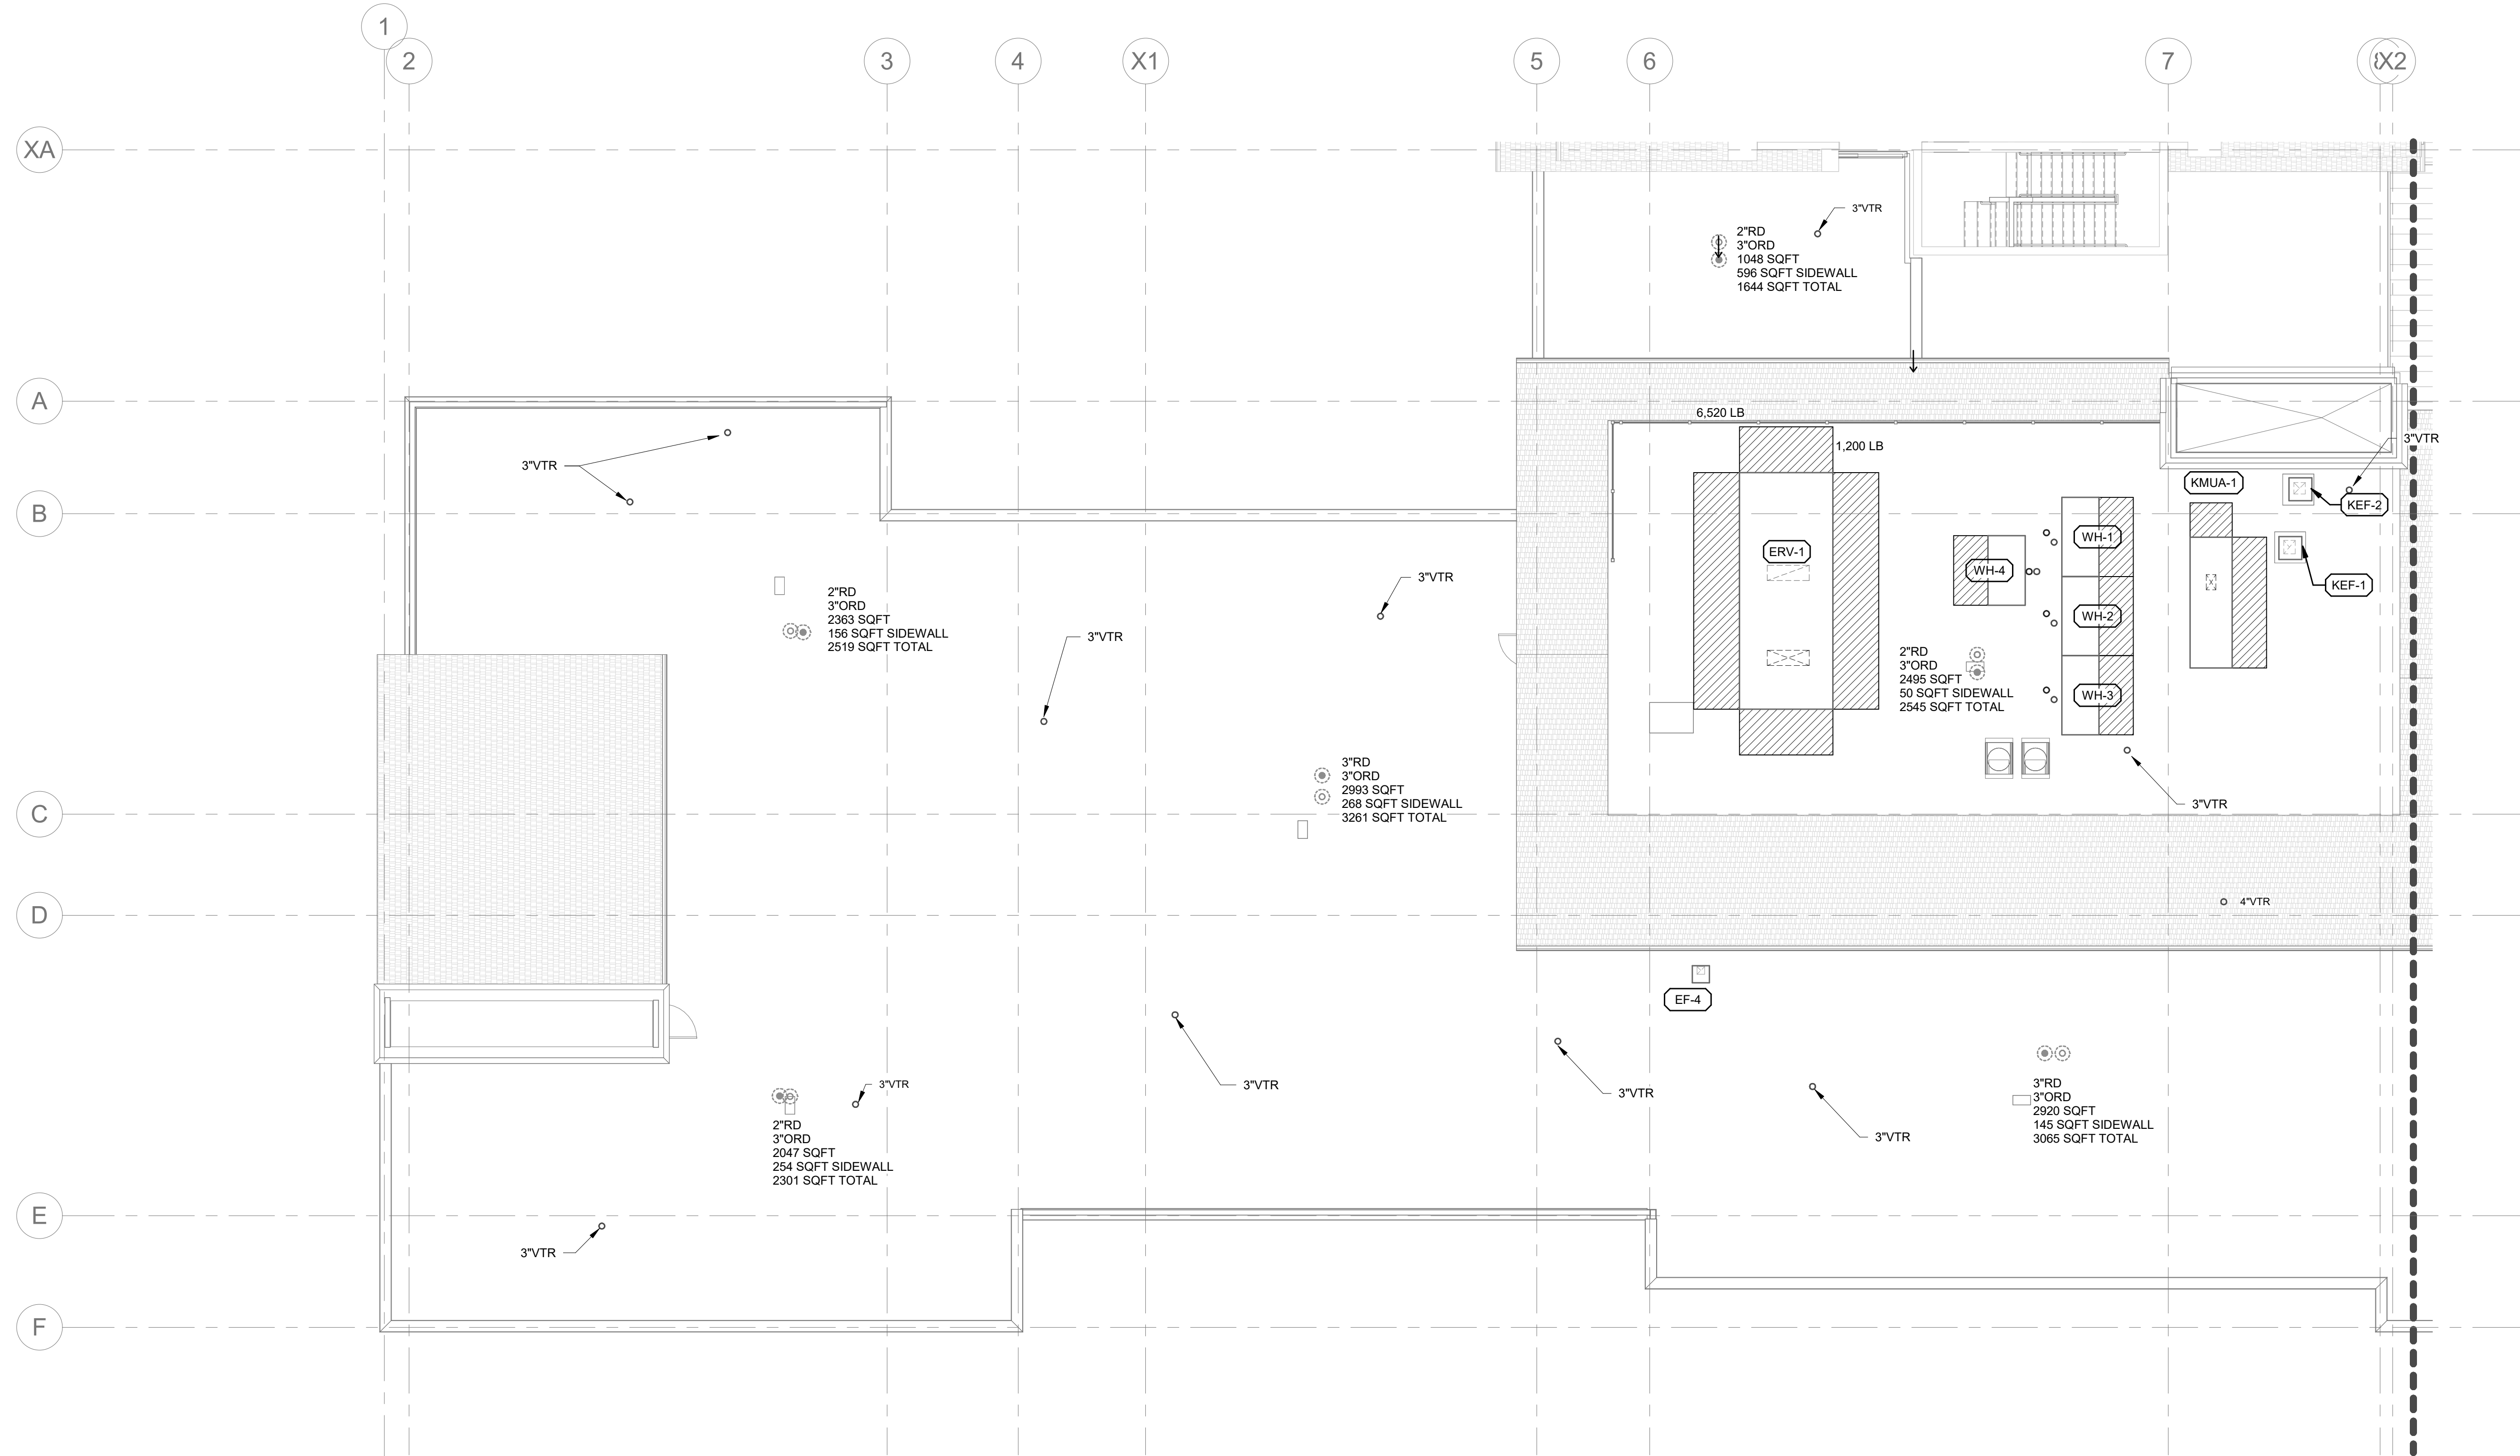

1 MECHANICAL ROOF PLAN NORTH
1/8" = 1'-0"


SHEET NOTES:
1. EXHAUST VENTS/OUTLETS SHALL BE
LOCATED 10'-0" CLEAR OF MECHANICAL
AIR INTAKES.

SEE M4.4 & M4.5 FOR PLUMBING RISERS R8 - R15
REFERENCED ON SHEET M1.1A

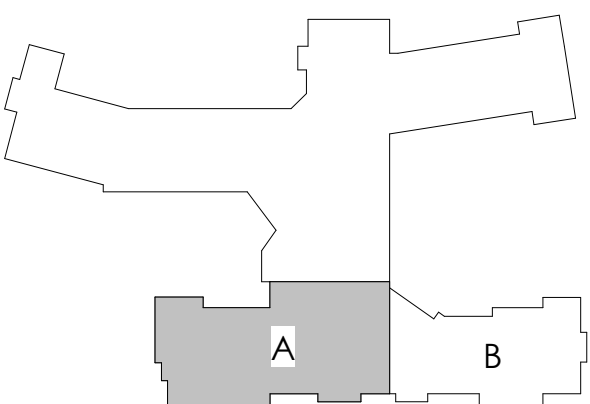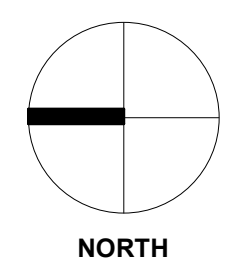

REFER TO SHEET M0.0 FOR NOTES

WESLEY BRADLEY PARK
PHASE 2 - CARE CENTER
707 39TH AVENUE SE
PUYALLUP, WA 98374

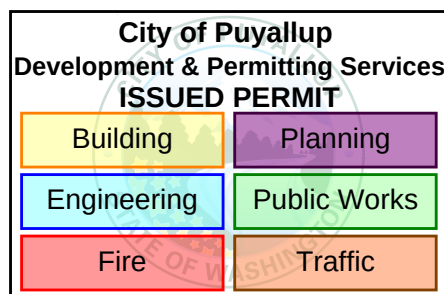

CARE CENTER
PERMIT SET
December 2, 2024

REVISIONS

No.	Description	Date
-----	-------------	------

ISA202201

PROJECT NUMBER


RDB/DCR RDB/MRB

DRAWN BY CHECKED BY

WESLEY BRADLEY PARK
PHASE 2 - CARE CENTER

MECHANICAL ROOF
PLAN SOUTH



M2.2B

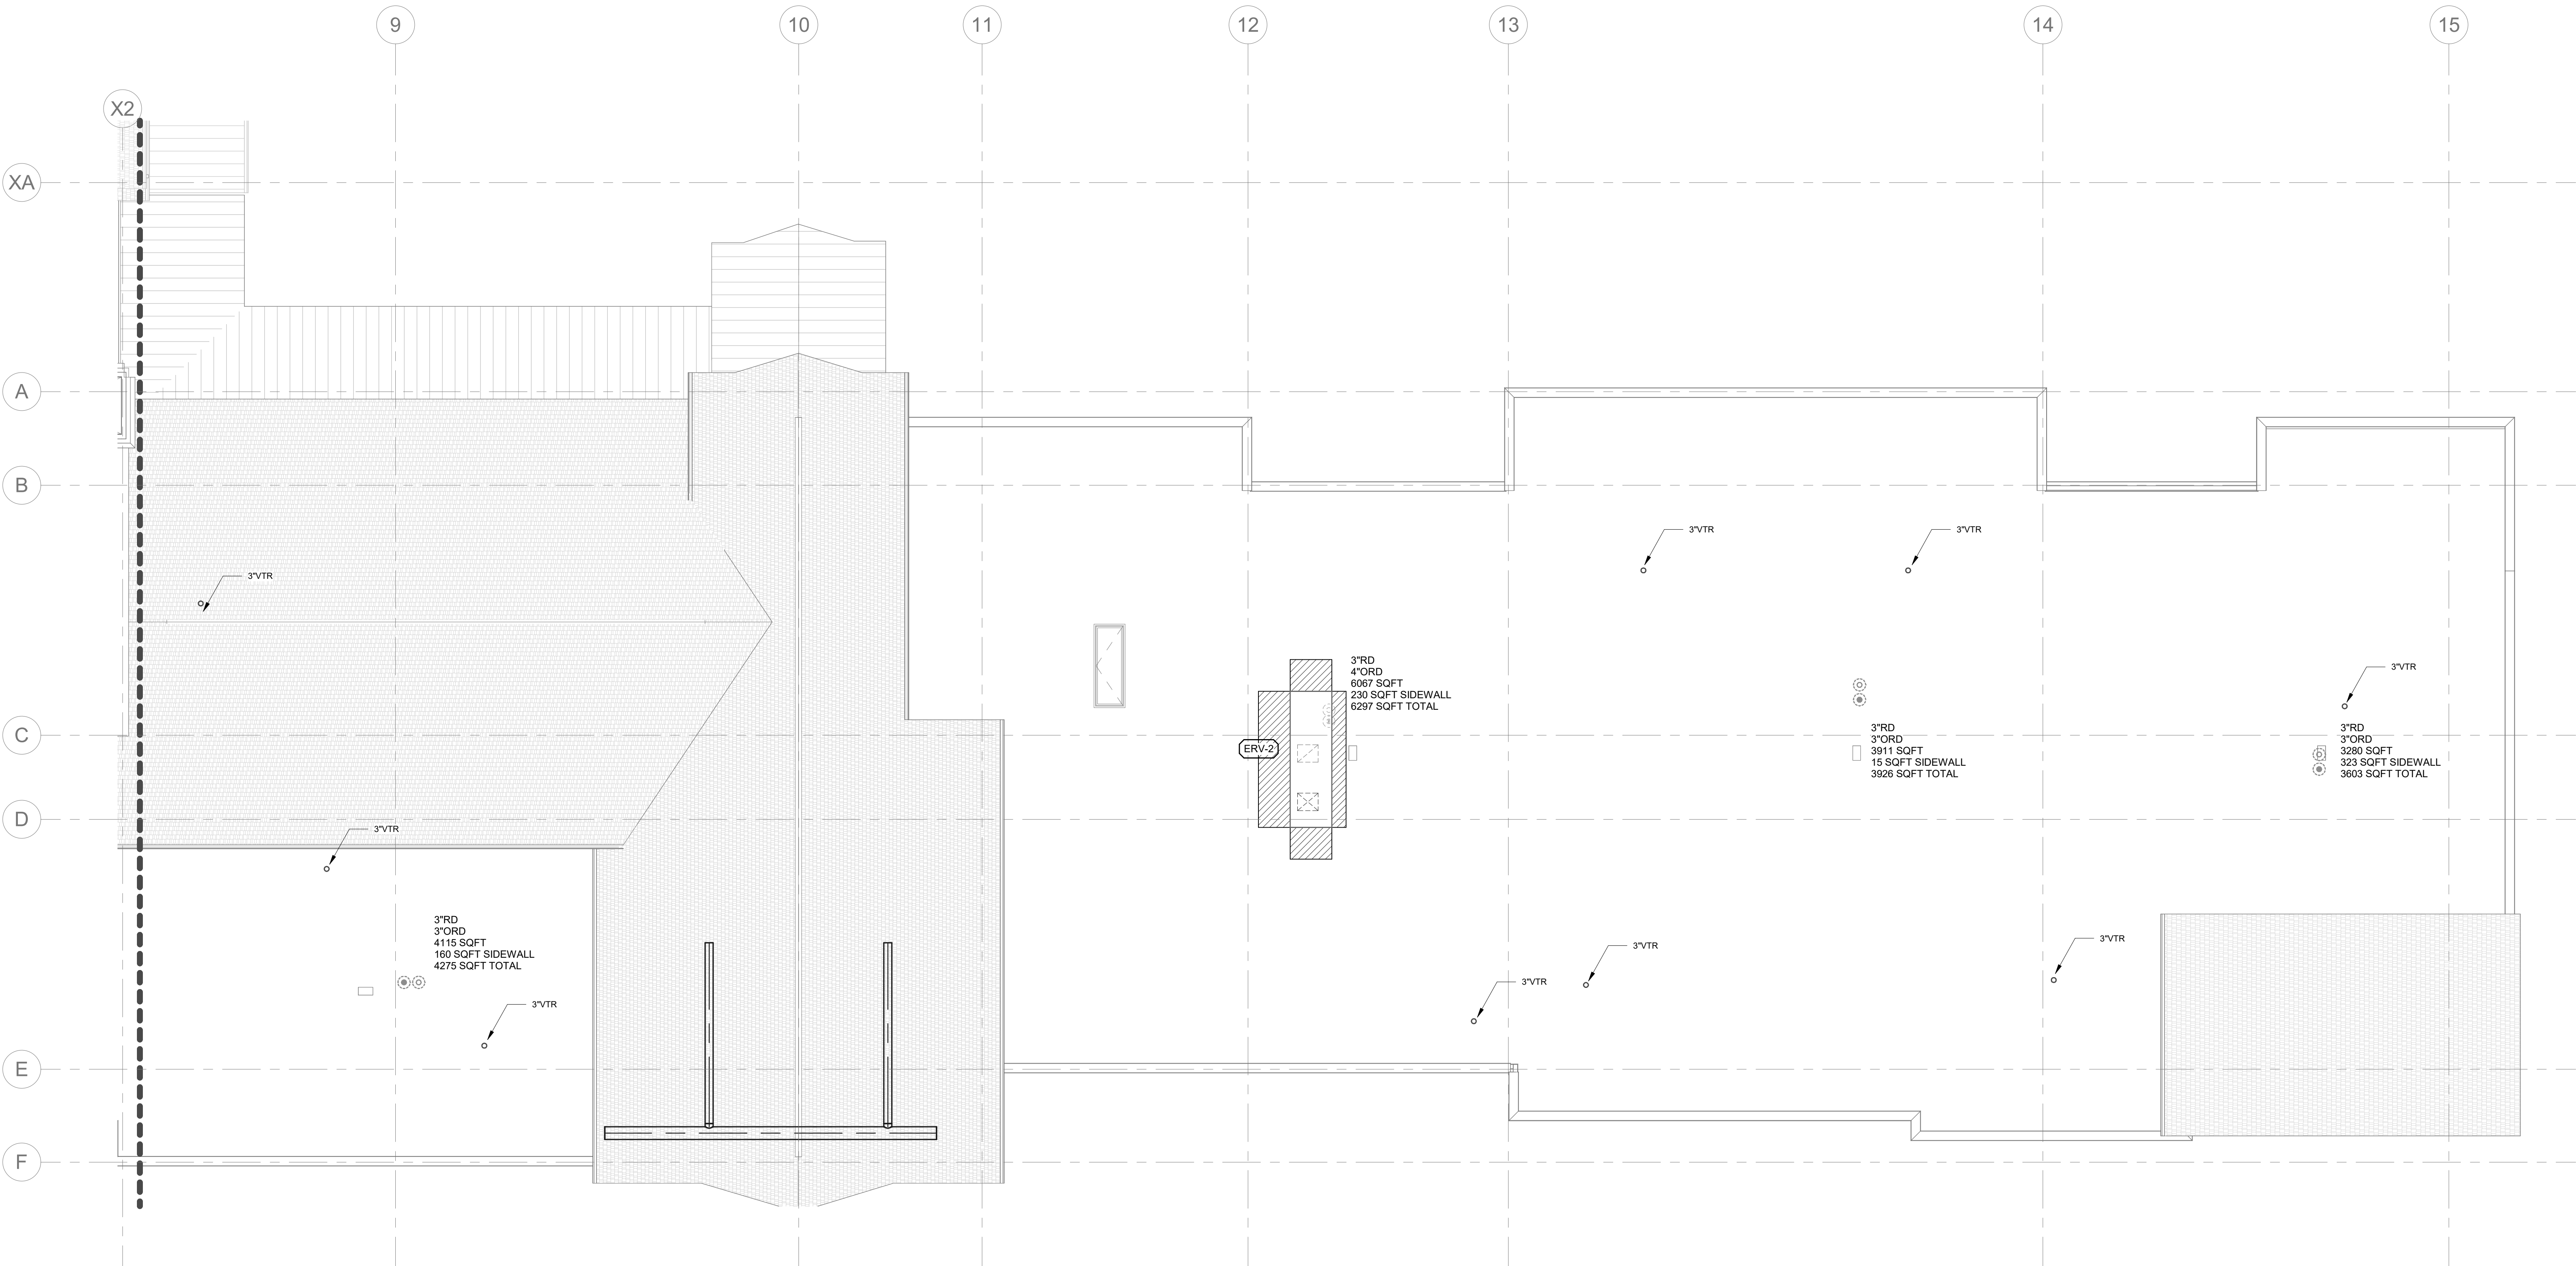

1 MECHANICAL ROOF PLAN SOUTH
1/8" = 1'-0"

SHEET NOTES:

1. EXHAUST VENTS/OUTLETS SHALL BE
LOCATED 10'-0" CLEAR OF MECHANICAL
AIR INTAKES.

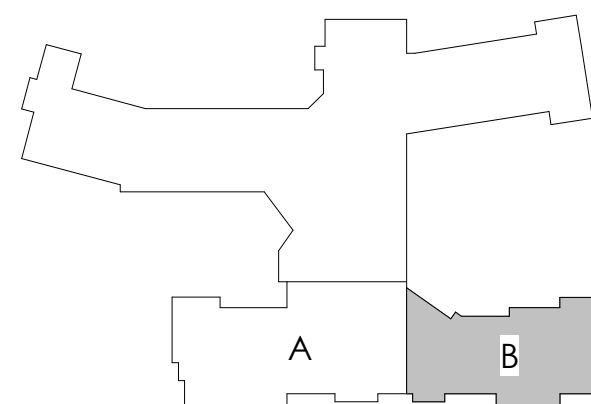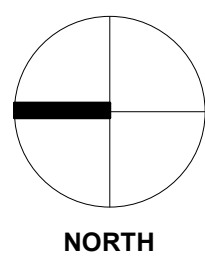

REFER TO SHEET M0.0 FOR NOTES




Mark R. Breneman
signature

Mark R. Breneman
Typed or Printed Name

Mechanical 12/02/24
Discipline Date

WESLEY BRADLEY PARK
PHASE 2 - CARE CENTER
707 39TH AVENUE SE
PUYALLUP, WA 98374

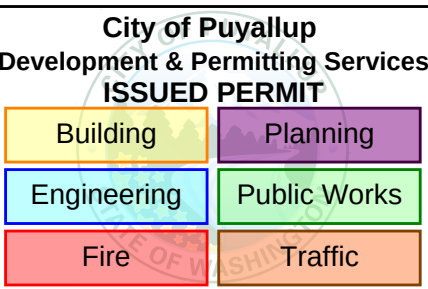

CARE CENTER
PERMIT SET
December 2, 2024

REVISIONS

No.	Description	Date
-----	-------------	------


ISA202201
PROJECT NUMBER

DCA MRB
DRAWN BY CHECKED BY


WESLEY BRADLEY PARK
PHASE 2 - CARE CENTER

HVAC UNITS

M3.0

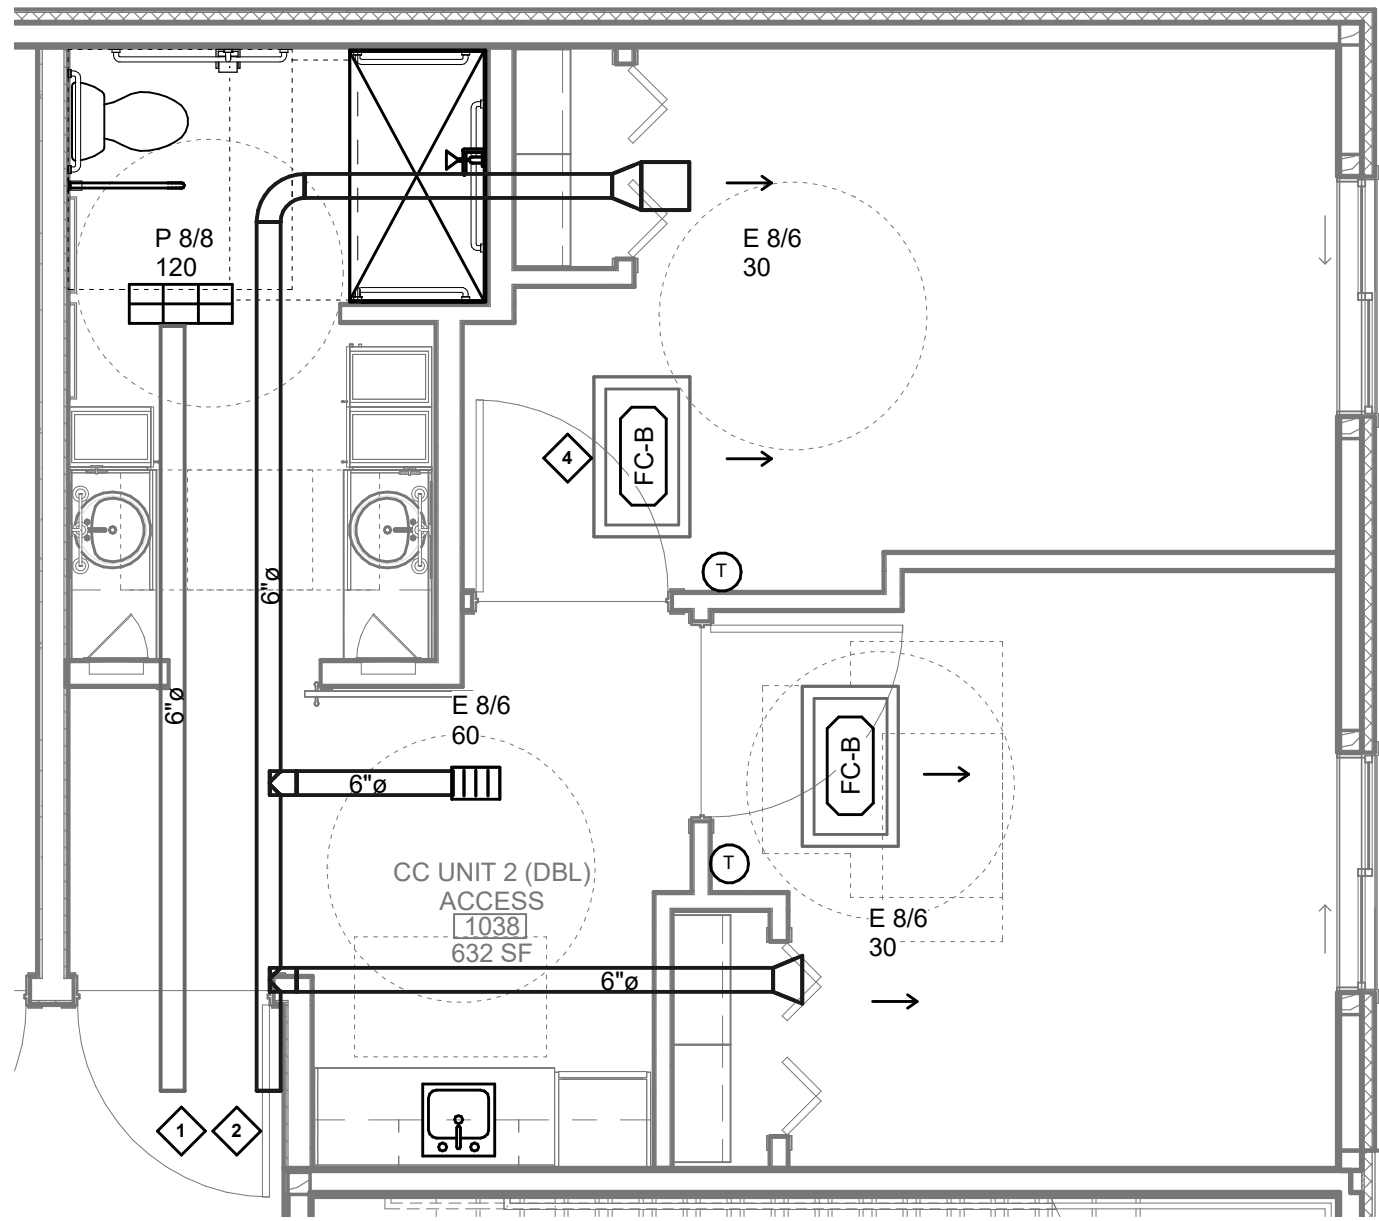

② CC UNIT 2 (DBL) HVAC PLAN
1/4" = 1'-0"

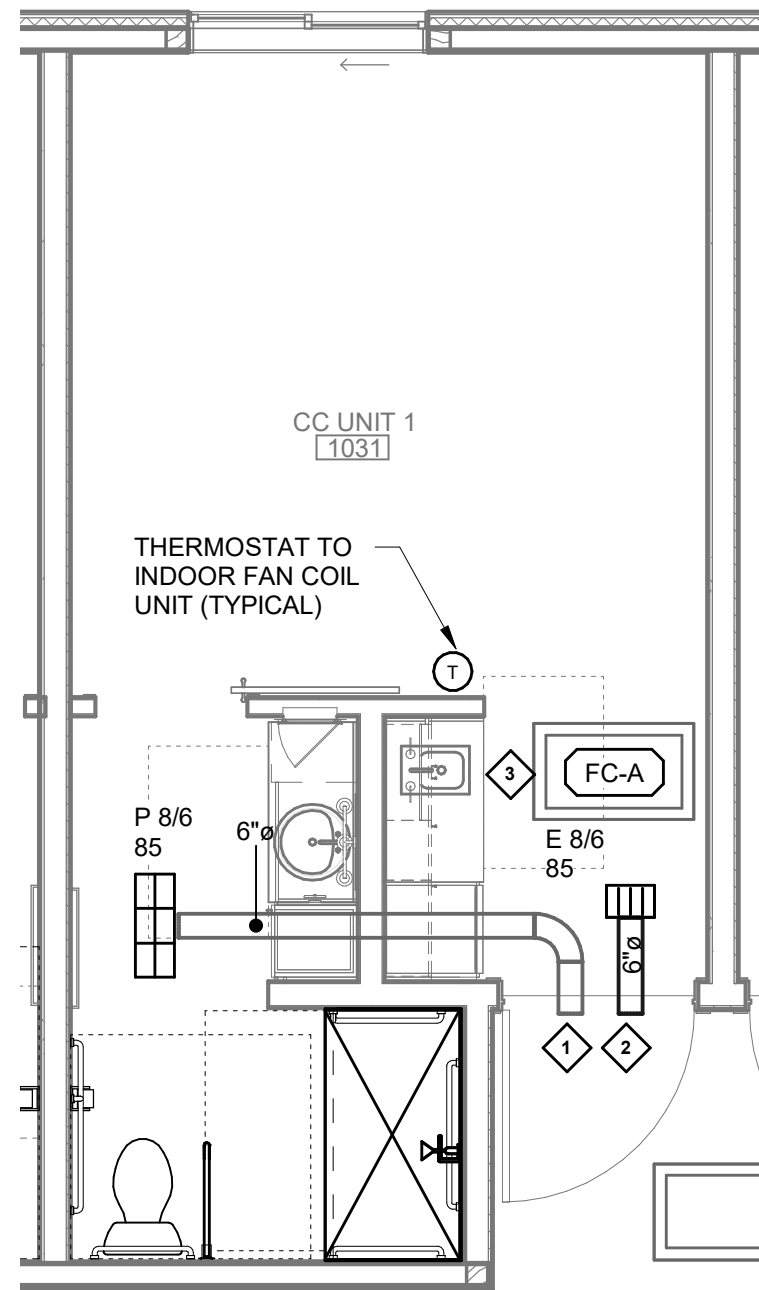

① CC UNIT 1 HVAC PLAN
1/4" = 1'-0"


KEY NOTES:

- MECHANICAL EXHAUST DUCT. REFER TO FLOOR PLANS FOR CONTINUATION.
- MECHANICAL OUTSIDE AIR DUCT. REFER TO FLOOR PLANS FOR CONTINUATION.
- TERMINATE CONDENSATE TO KITCHEN TAILPIECE
- TERMINATE CONDENSATE TO BATHROOM LAVATORY

GENERAL HVAC UNIT NOTES

- A. PROVIDE WALL THERMOSTAT. COORDINATE EXACT LOCATION AND MOUNTING HEIGHT WITH OWNER AND ARCHITECT.

WESLEY BRADLEY PARK
PHASE 2 - CARE CENTER
707 39TH AVENUE SE
PUYALLUP, WA 98374

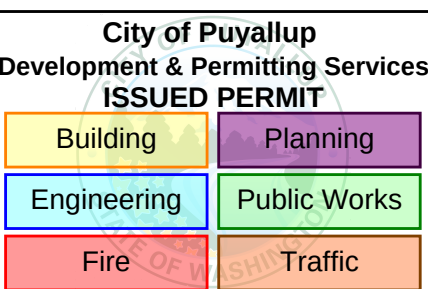

CARE CENTER
PERMIT SET
December 2, 2024

REVISIONS

No.	Description	Date
-----	-------------	------

ISA202201

PROJECT NUMBER


RDB RDB

DRAWN BY CHECKED BY


WESLEY BRADLEY PARK
PHASE 2 - CARE CENTER

ENLARGED PLAN


M3.1

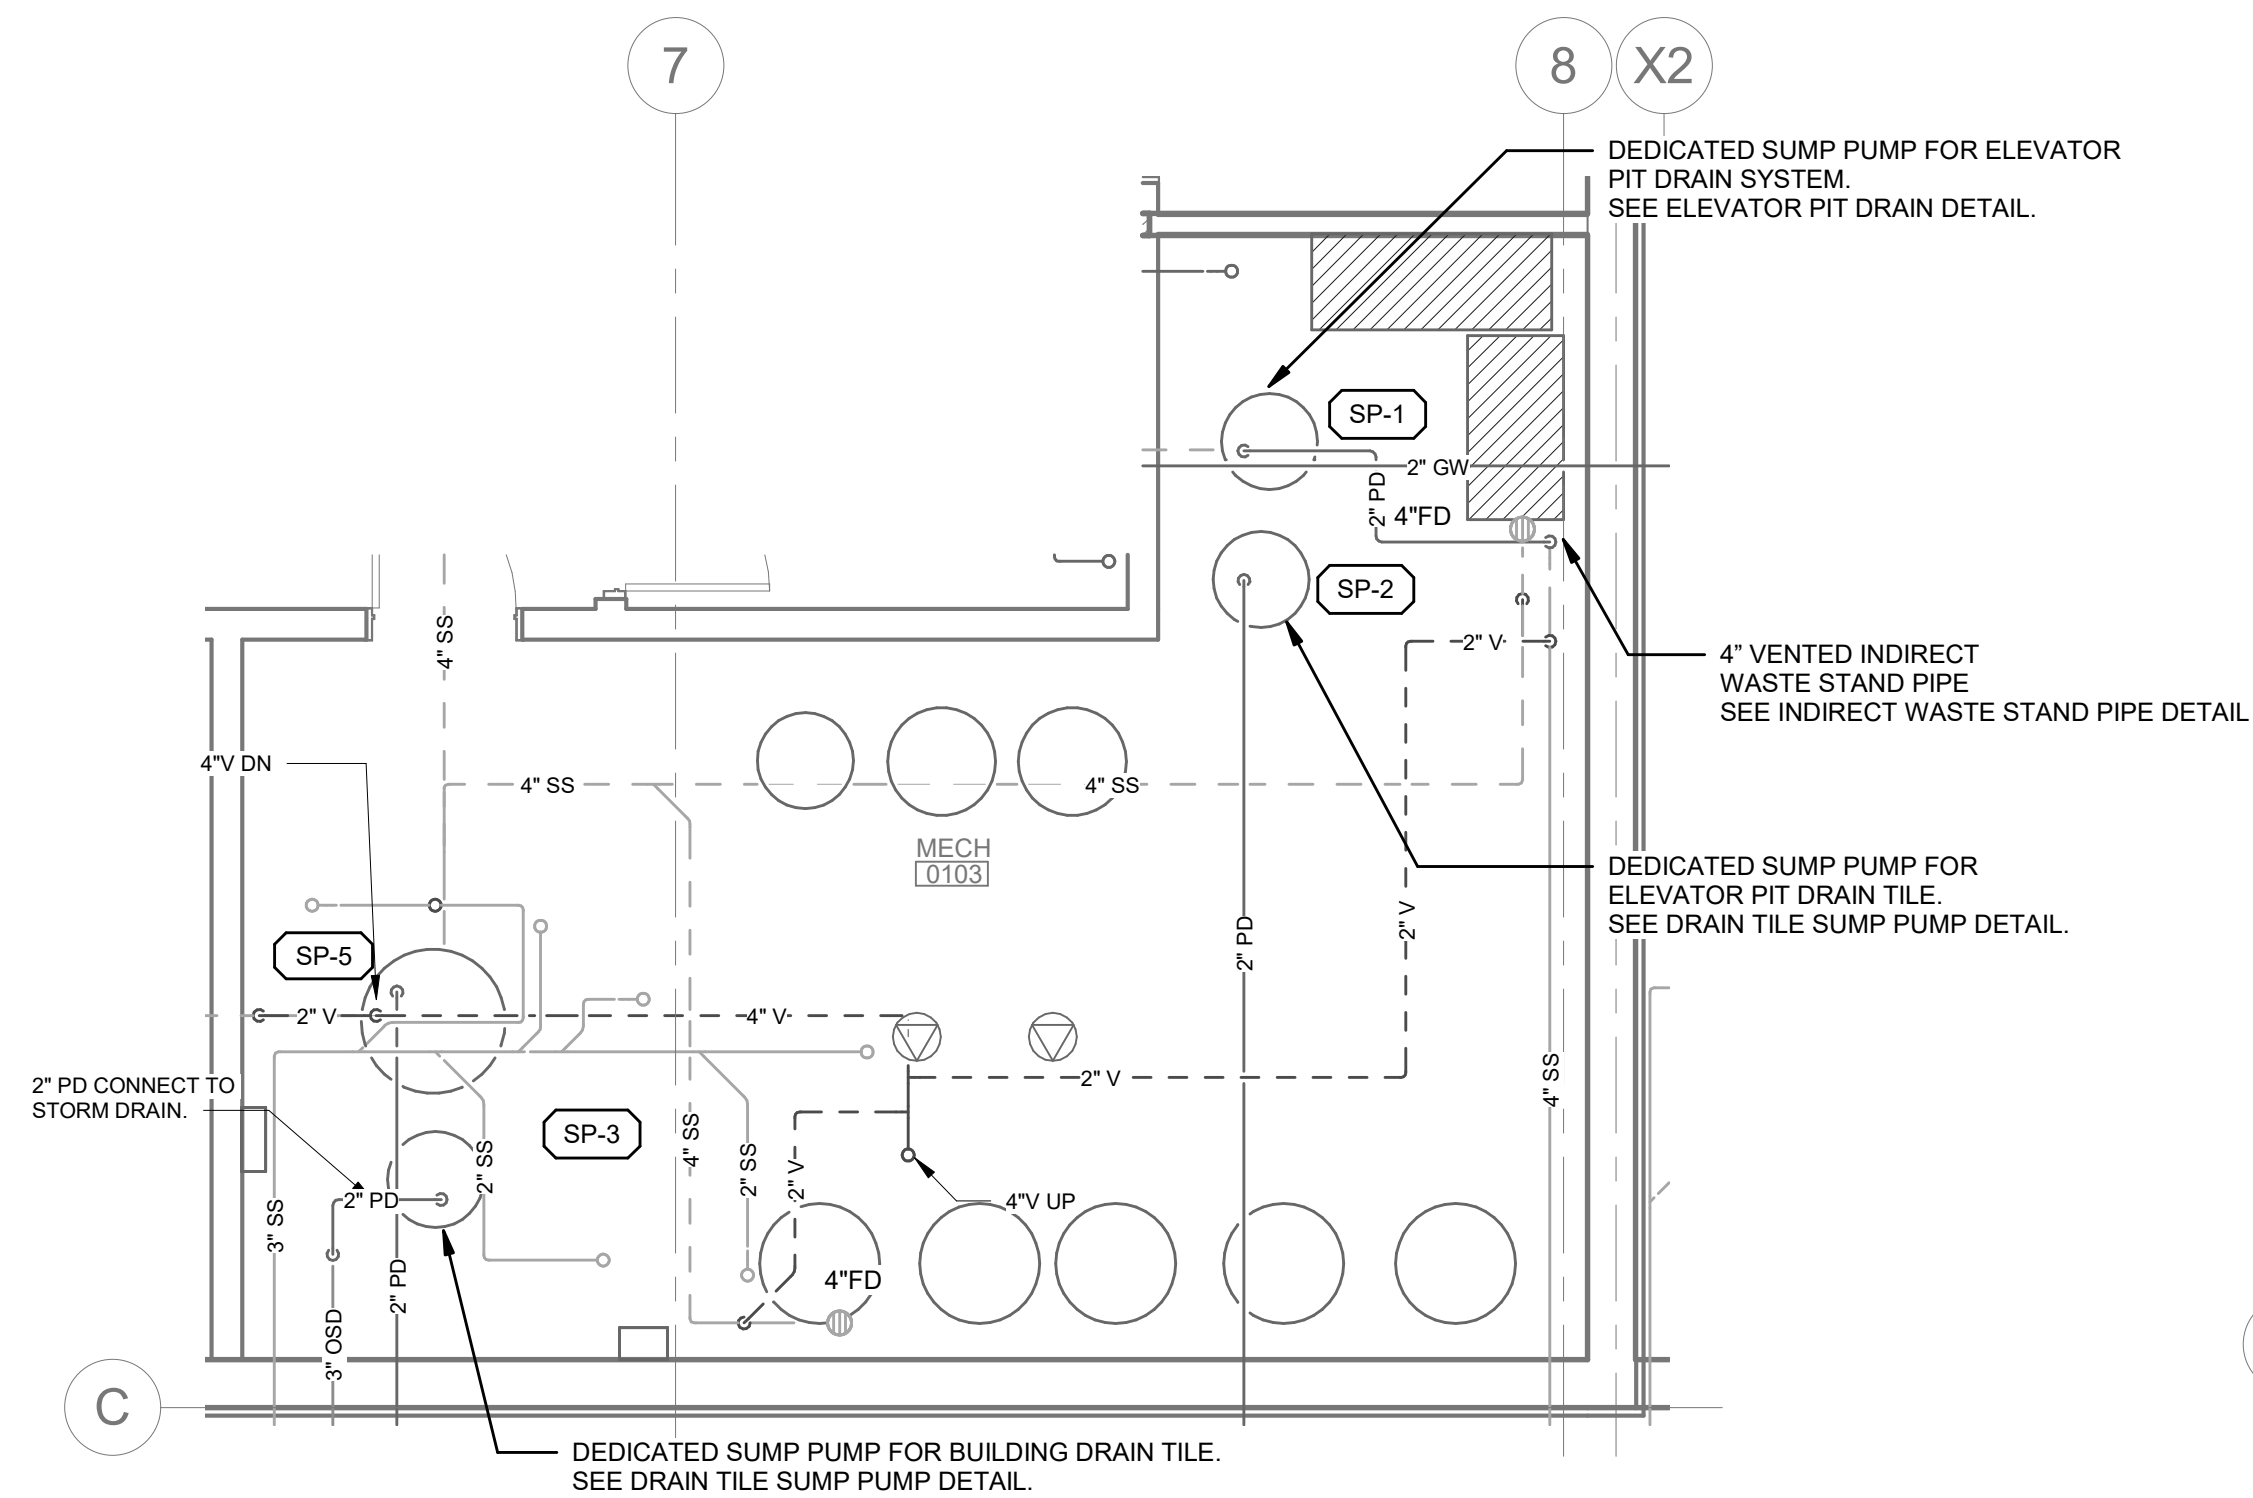


ENLARGED MECHANICAL ROOM DWV
PLAN
1/4" = 1'-0"

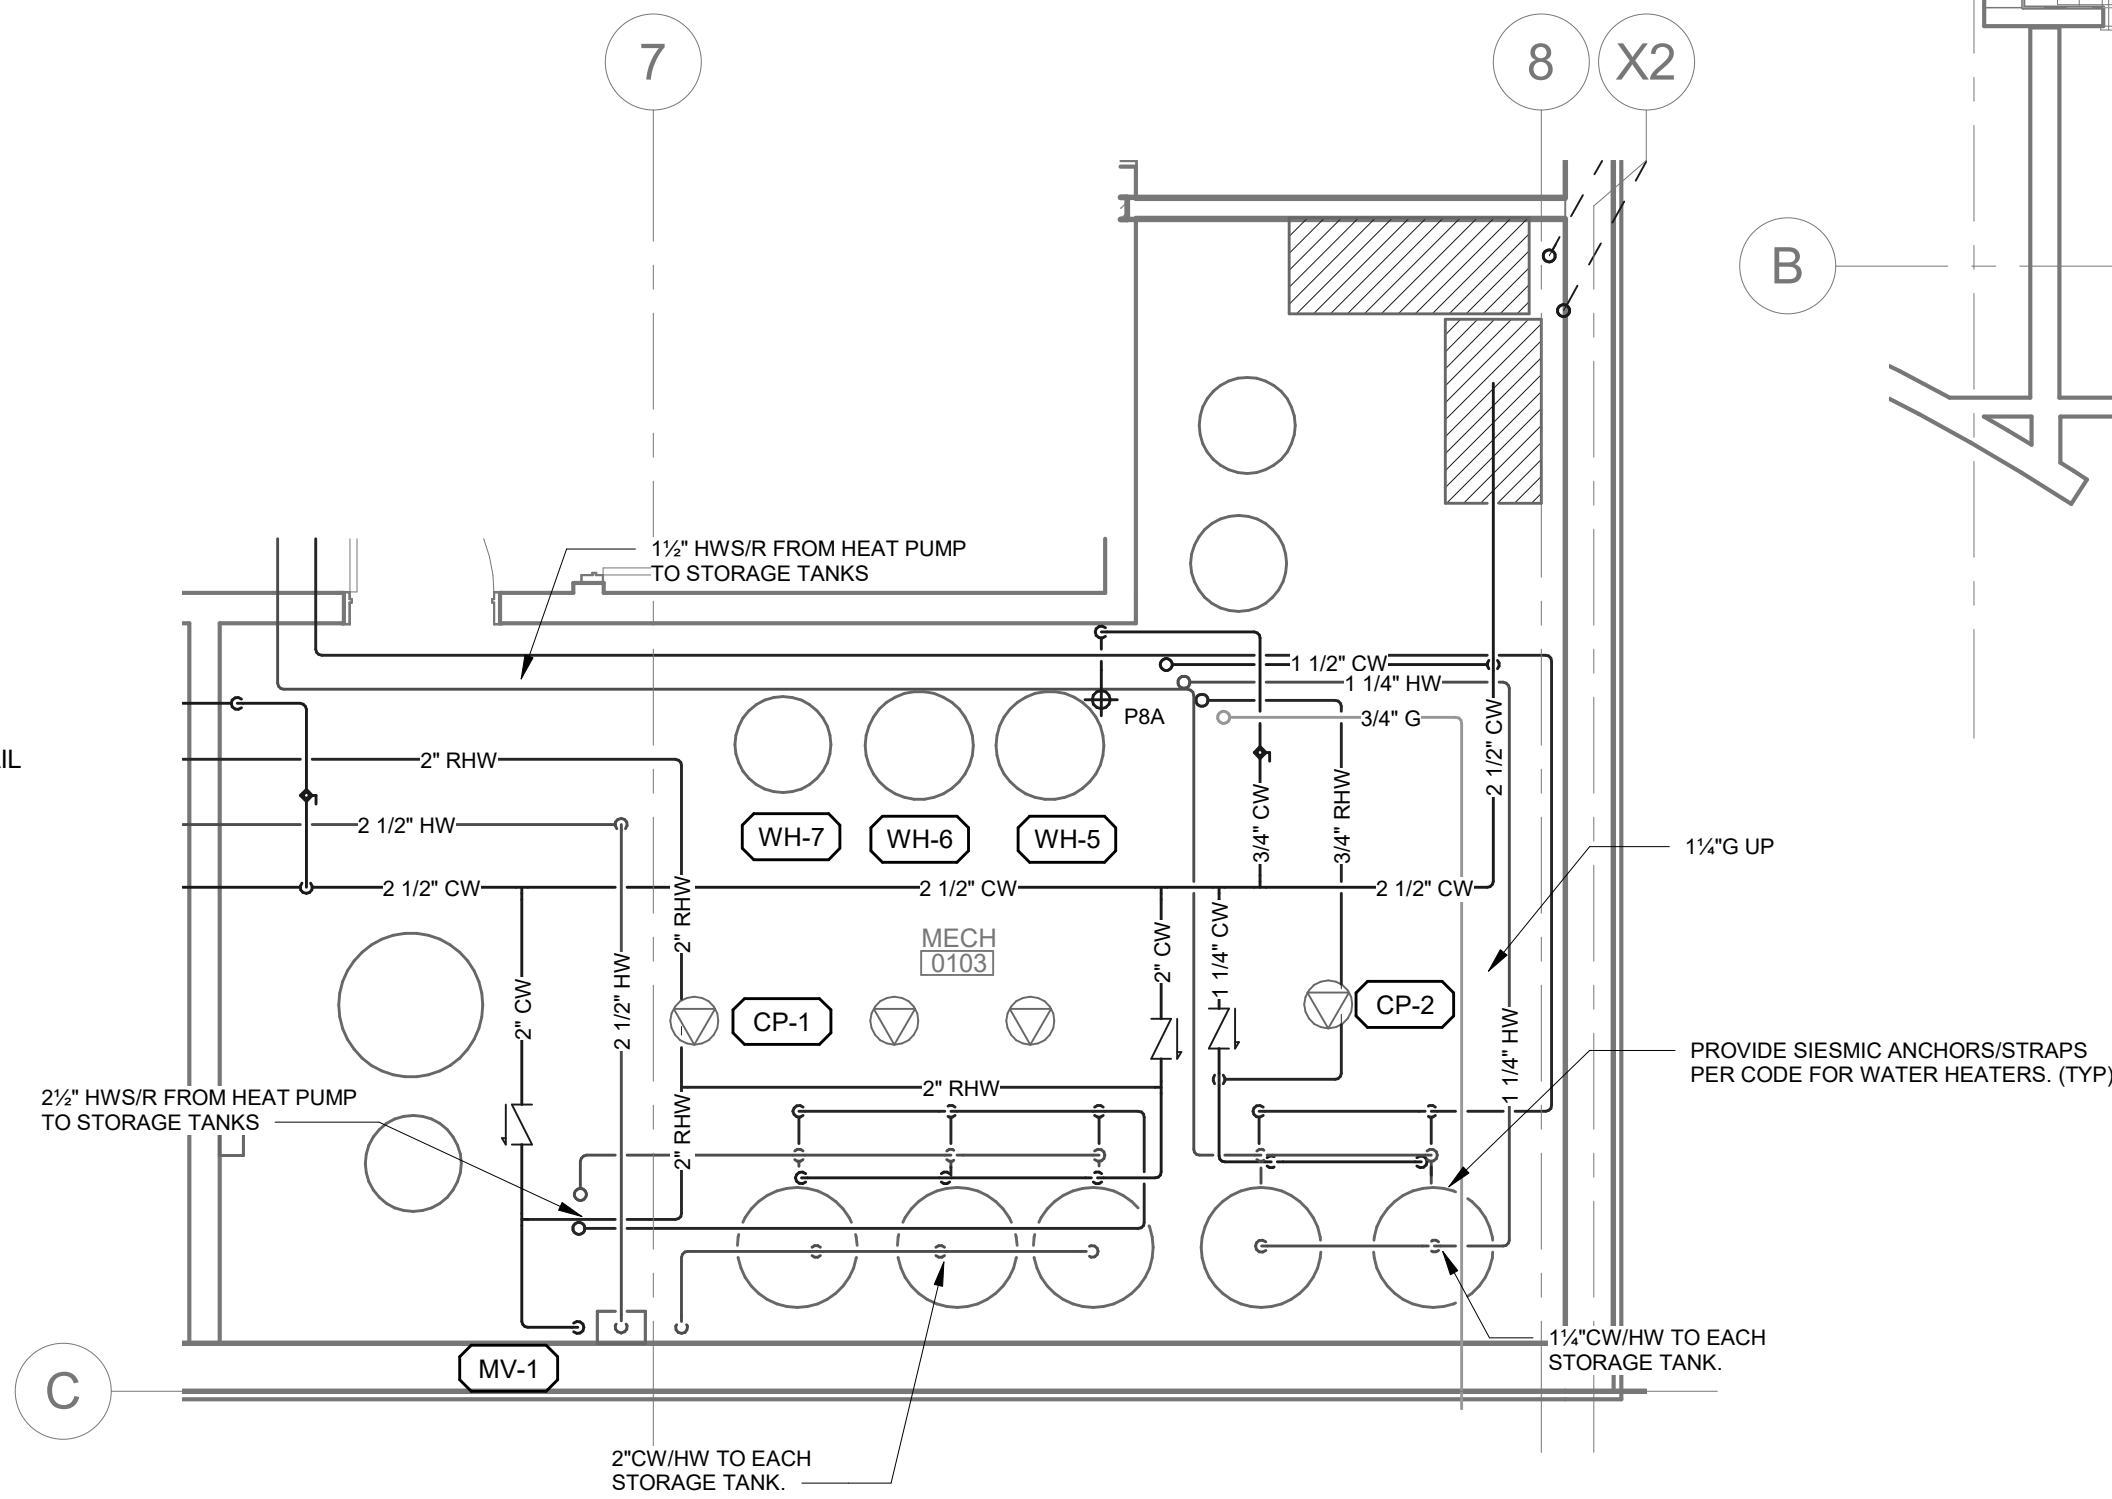


ENLARGED MECHANICAL ROOM
DOMESTIC WATER PLAN
1/4" = 1'-0"

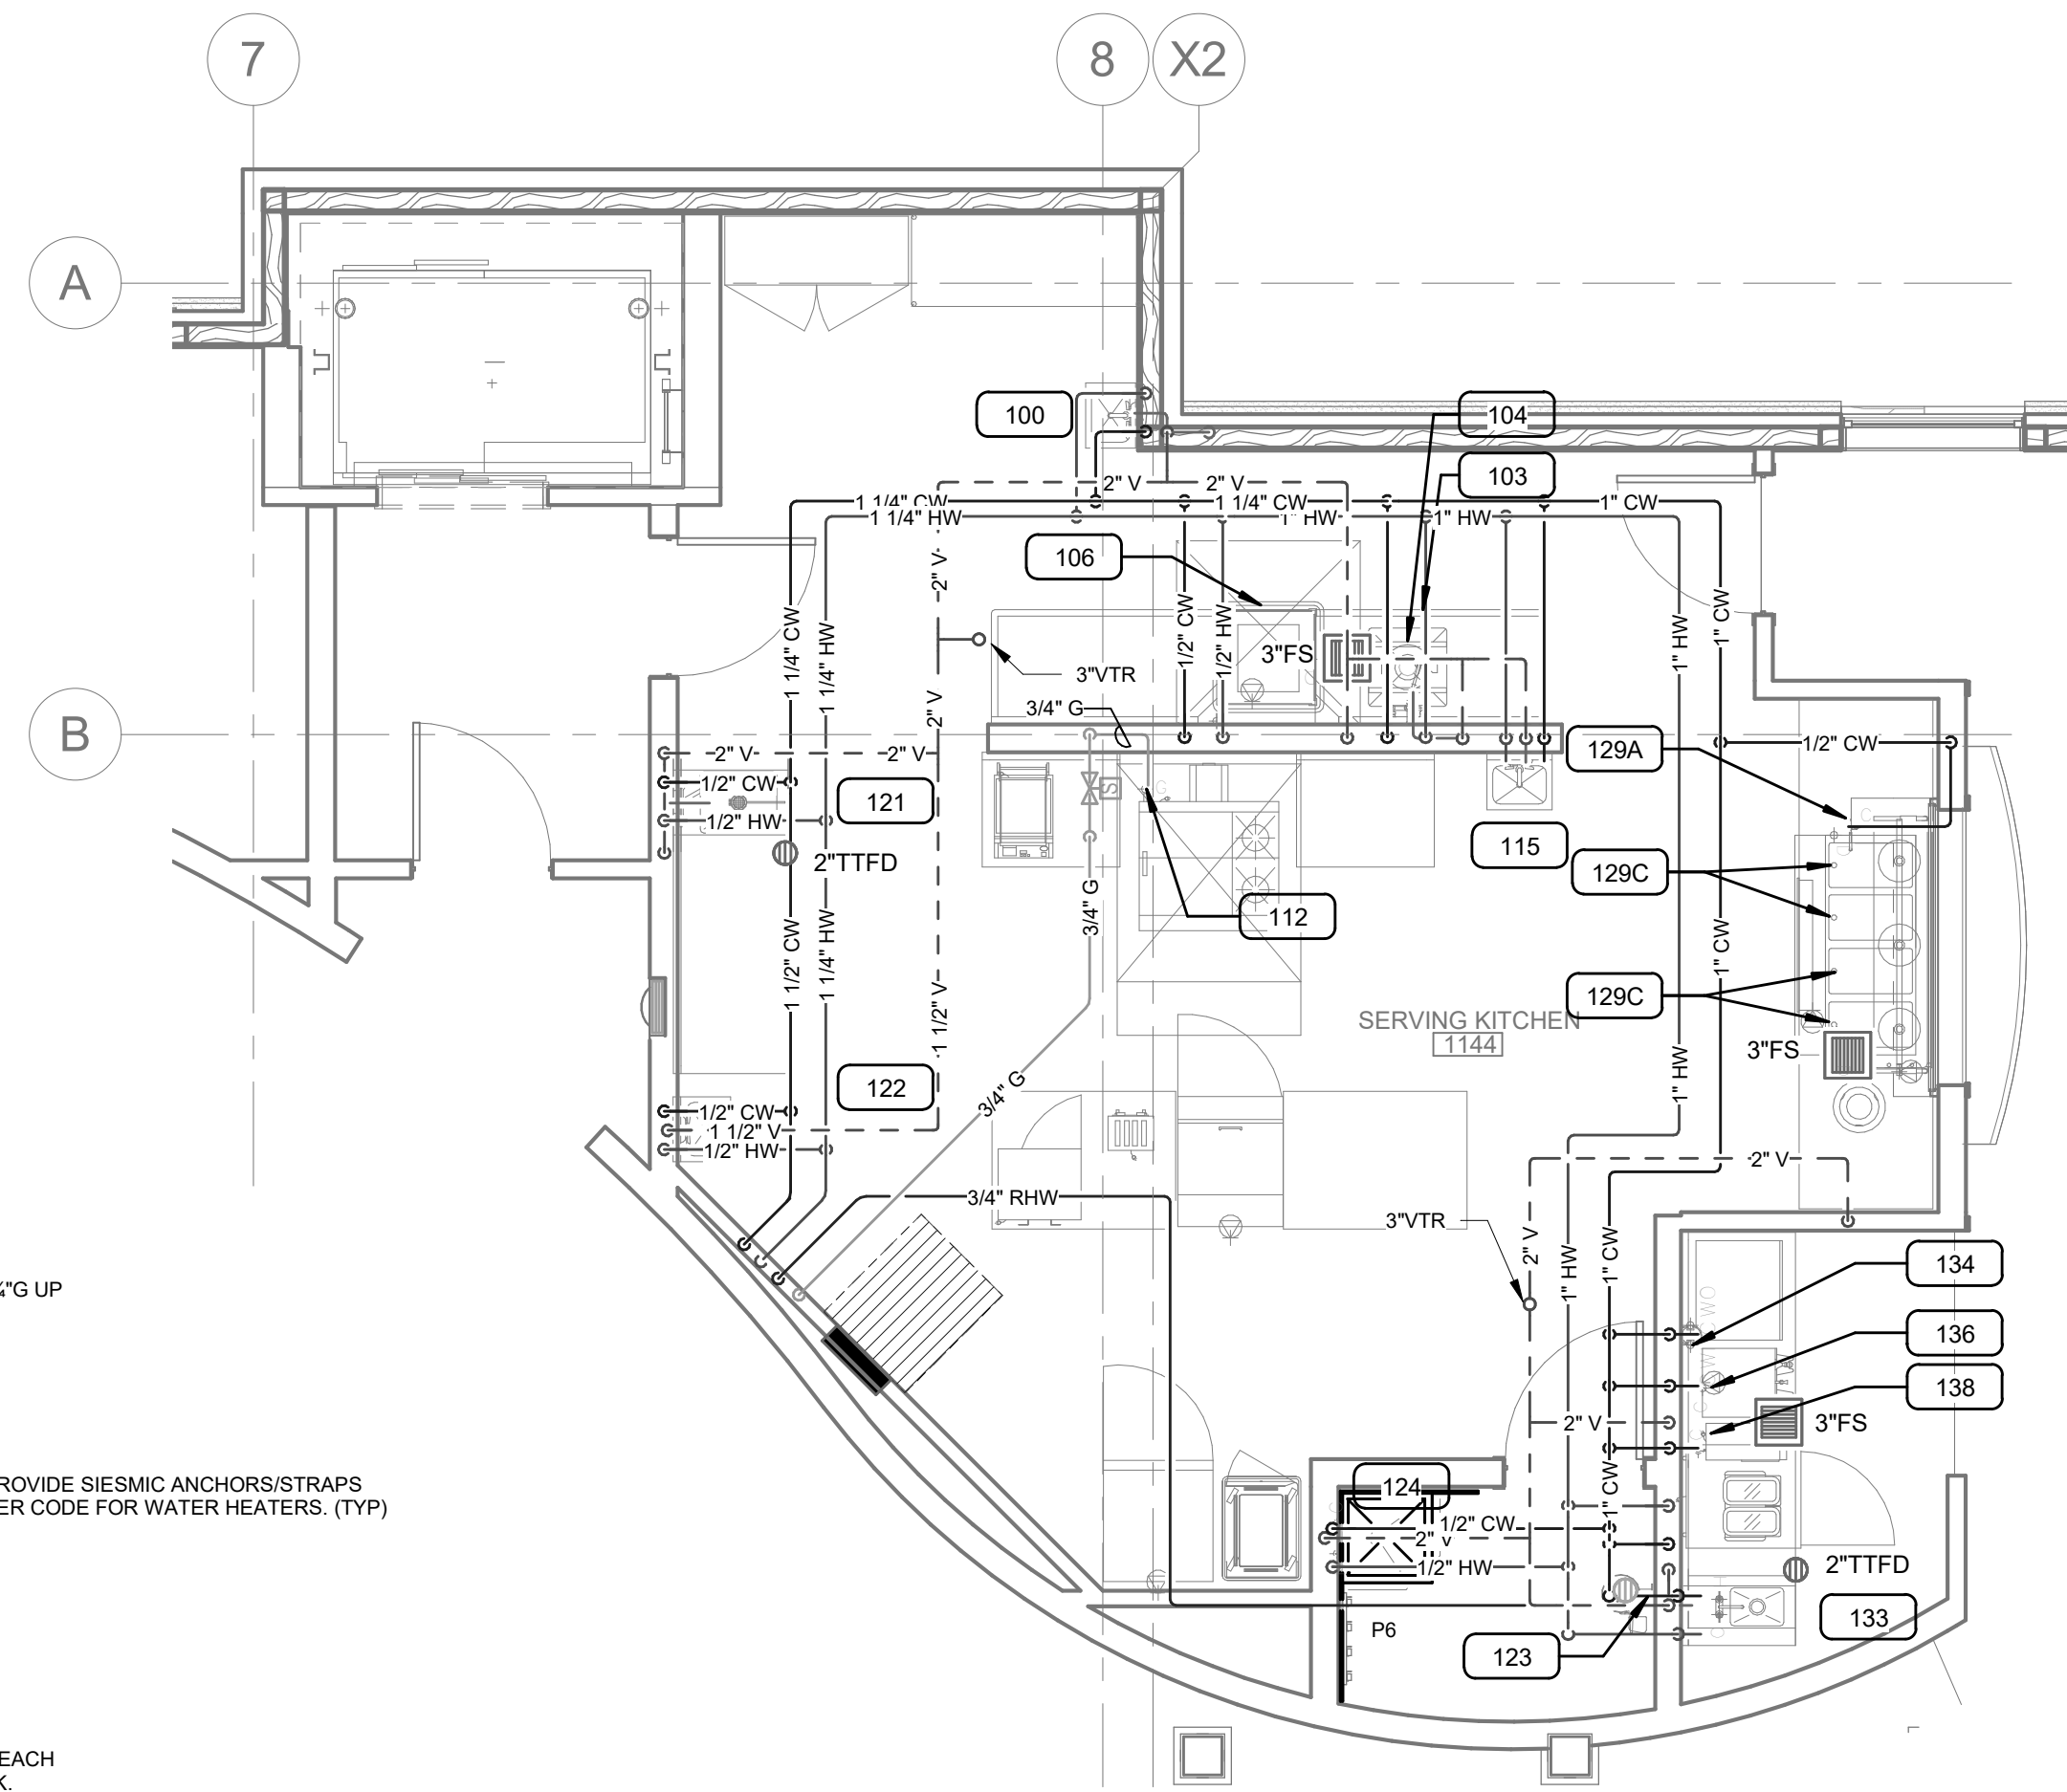


ENLARGED KITCHEN PLUMBING PLAN
1/4" = 1'-0"

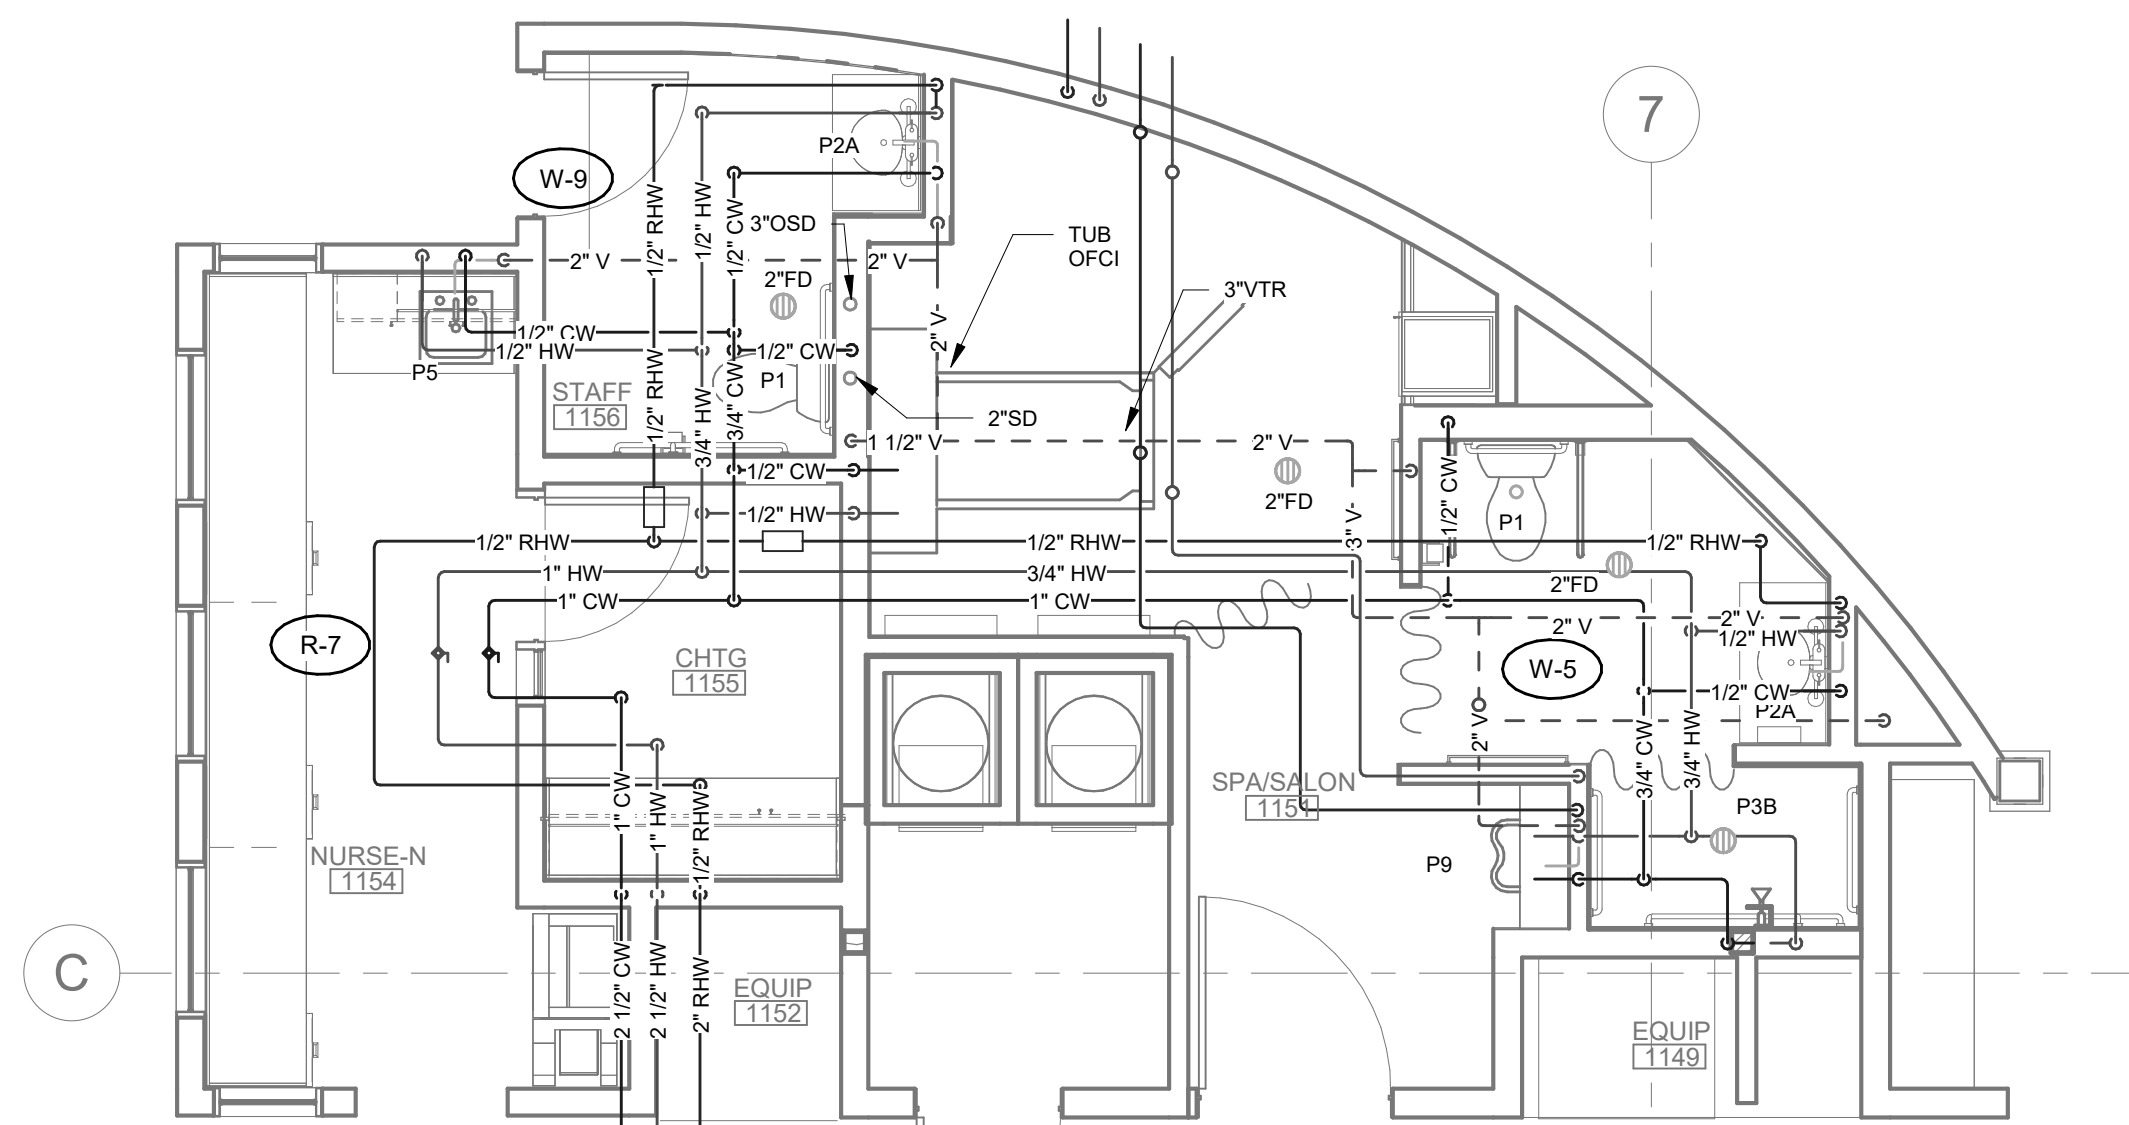


ENLARGED SPA AREA PLUMBING PLAN
1/4" = 1'-0"

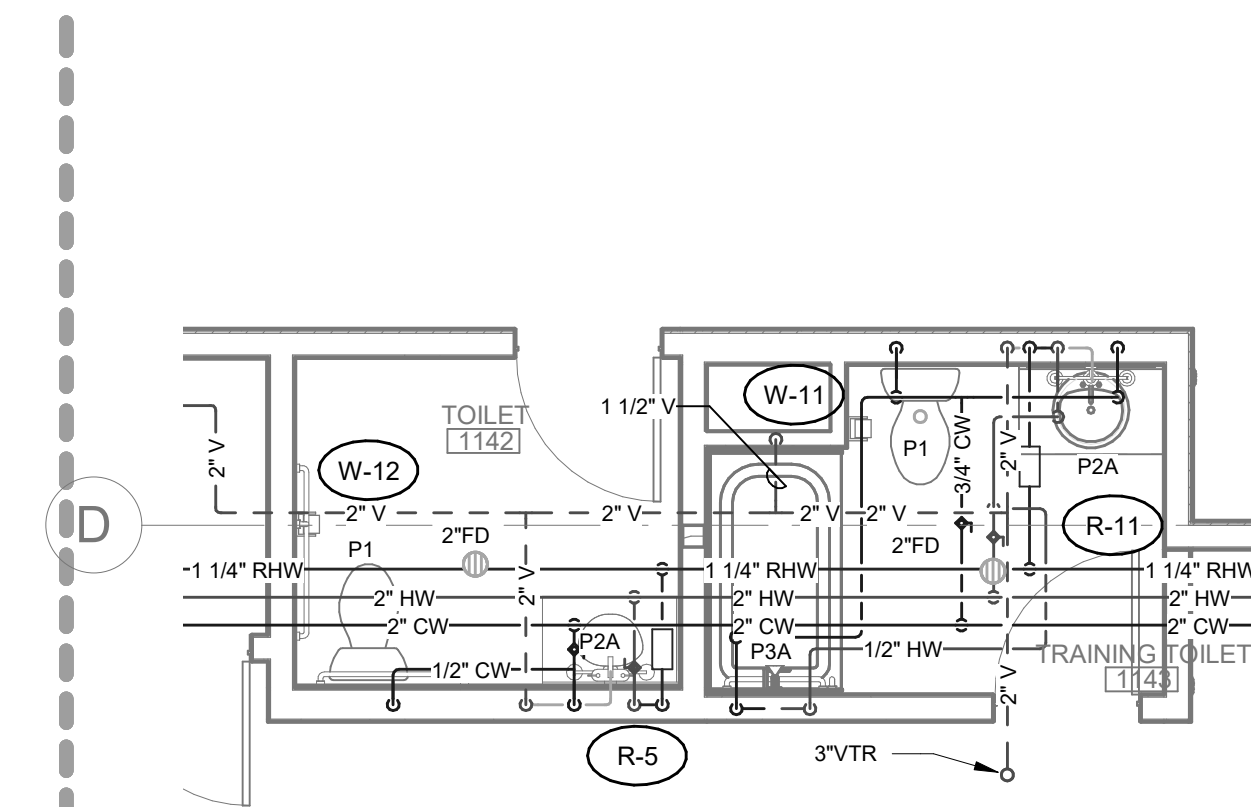


ENLARGED TRAINING AREA PLUMBING
PLAN
1/4" = 1'-0"

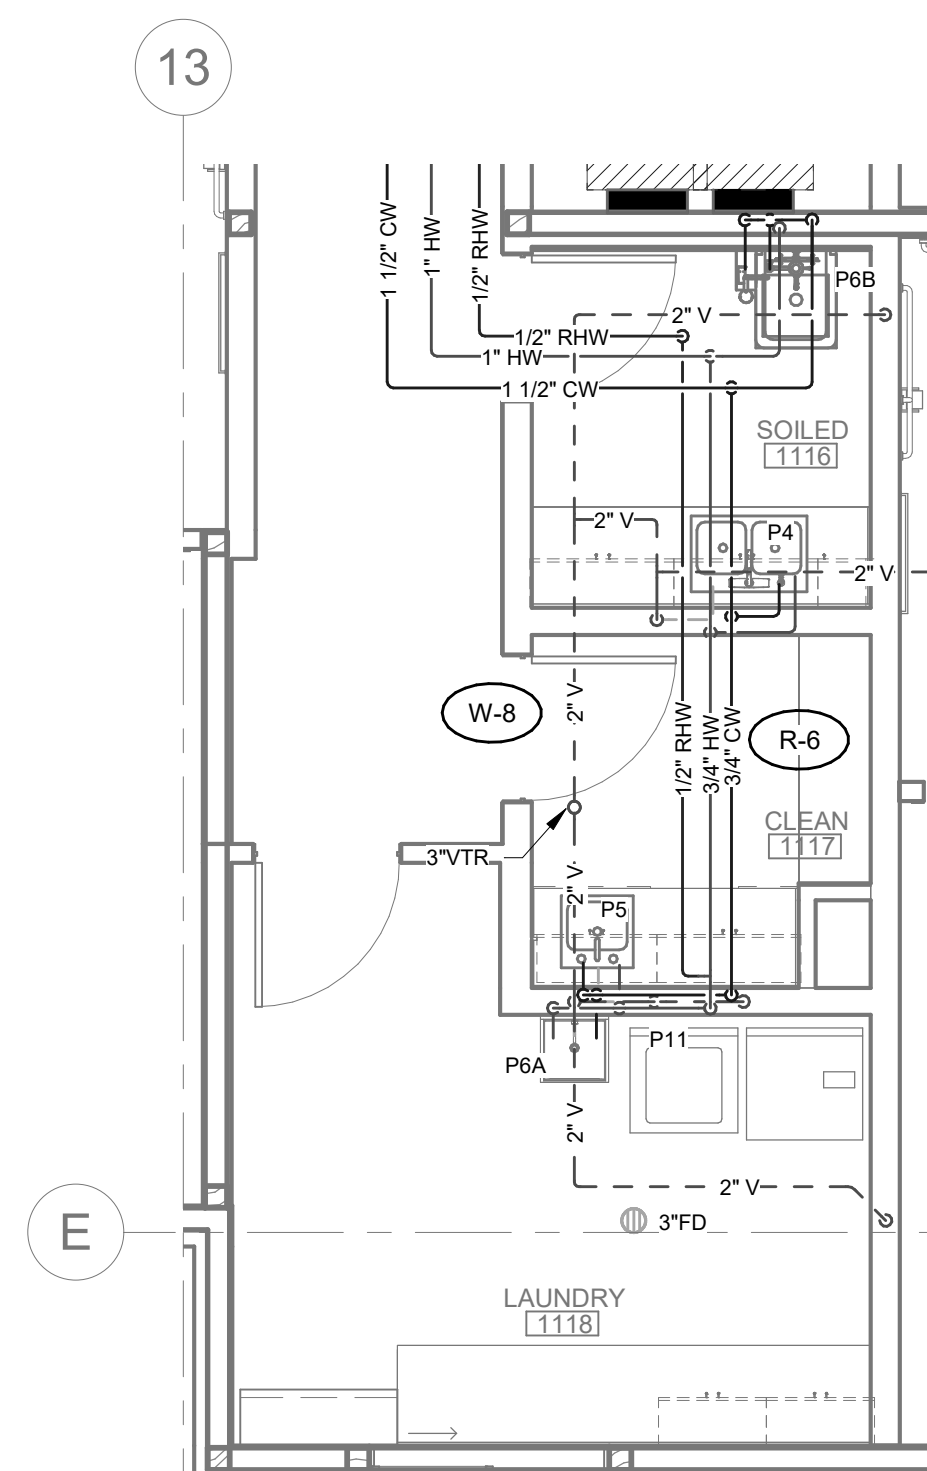


ENLARGED SOUTH LAUNDRY
PLUMBING PLAN
1/4" = 1'-0"

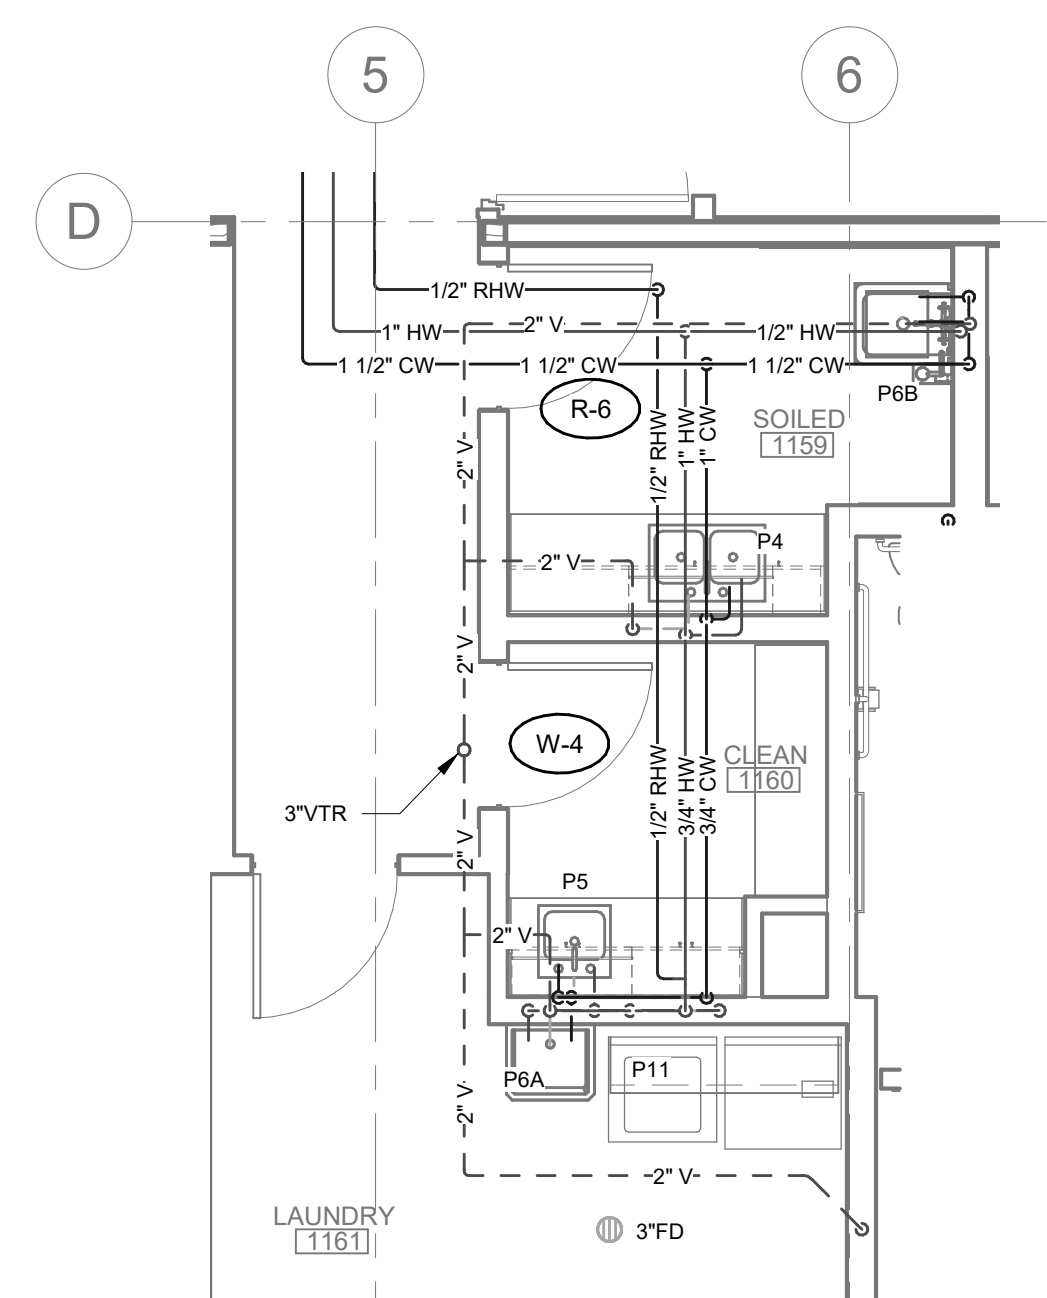

ENLARGED NORTH LAUNDRY PLAN
1/4" = 1'-0"

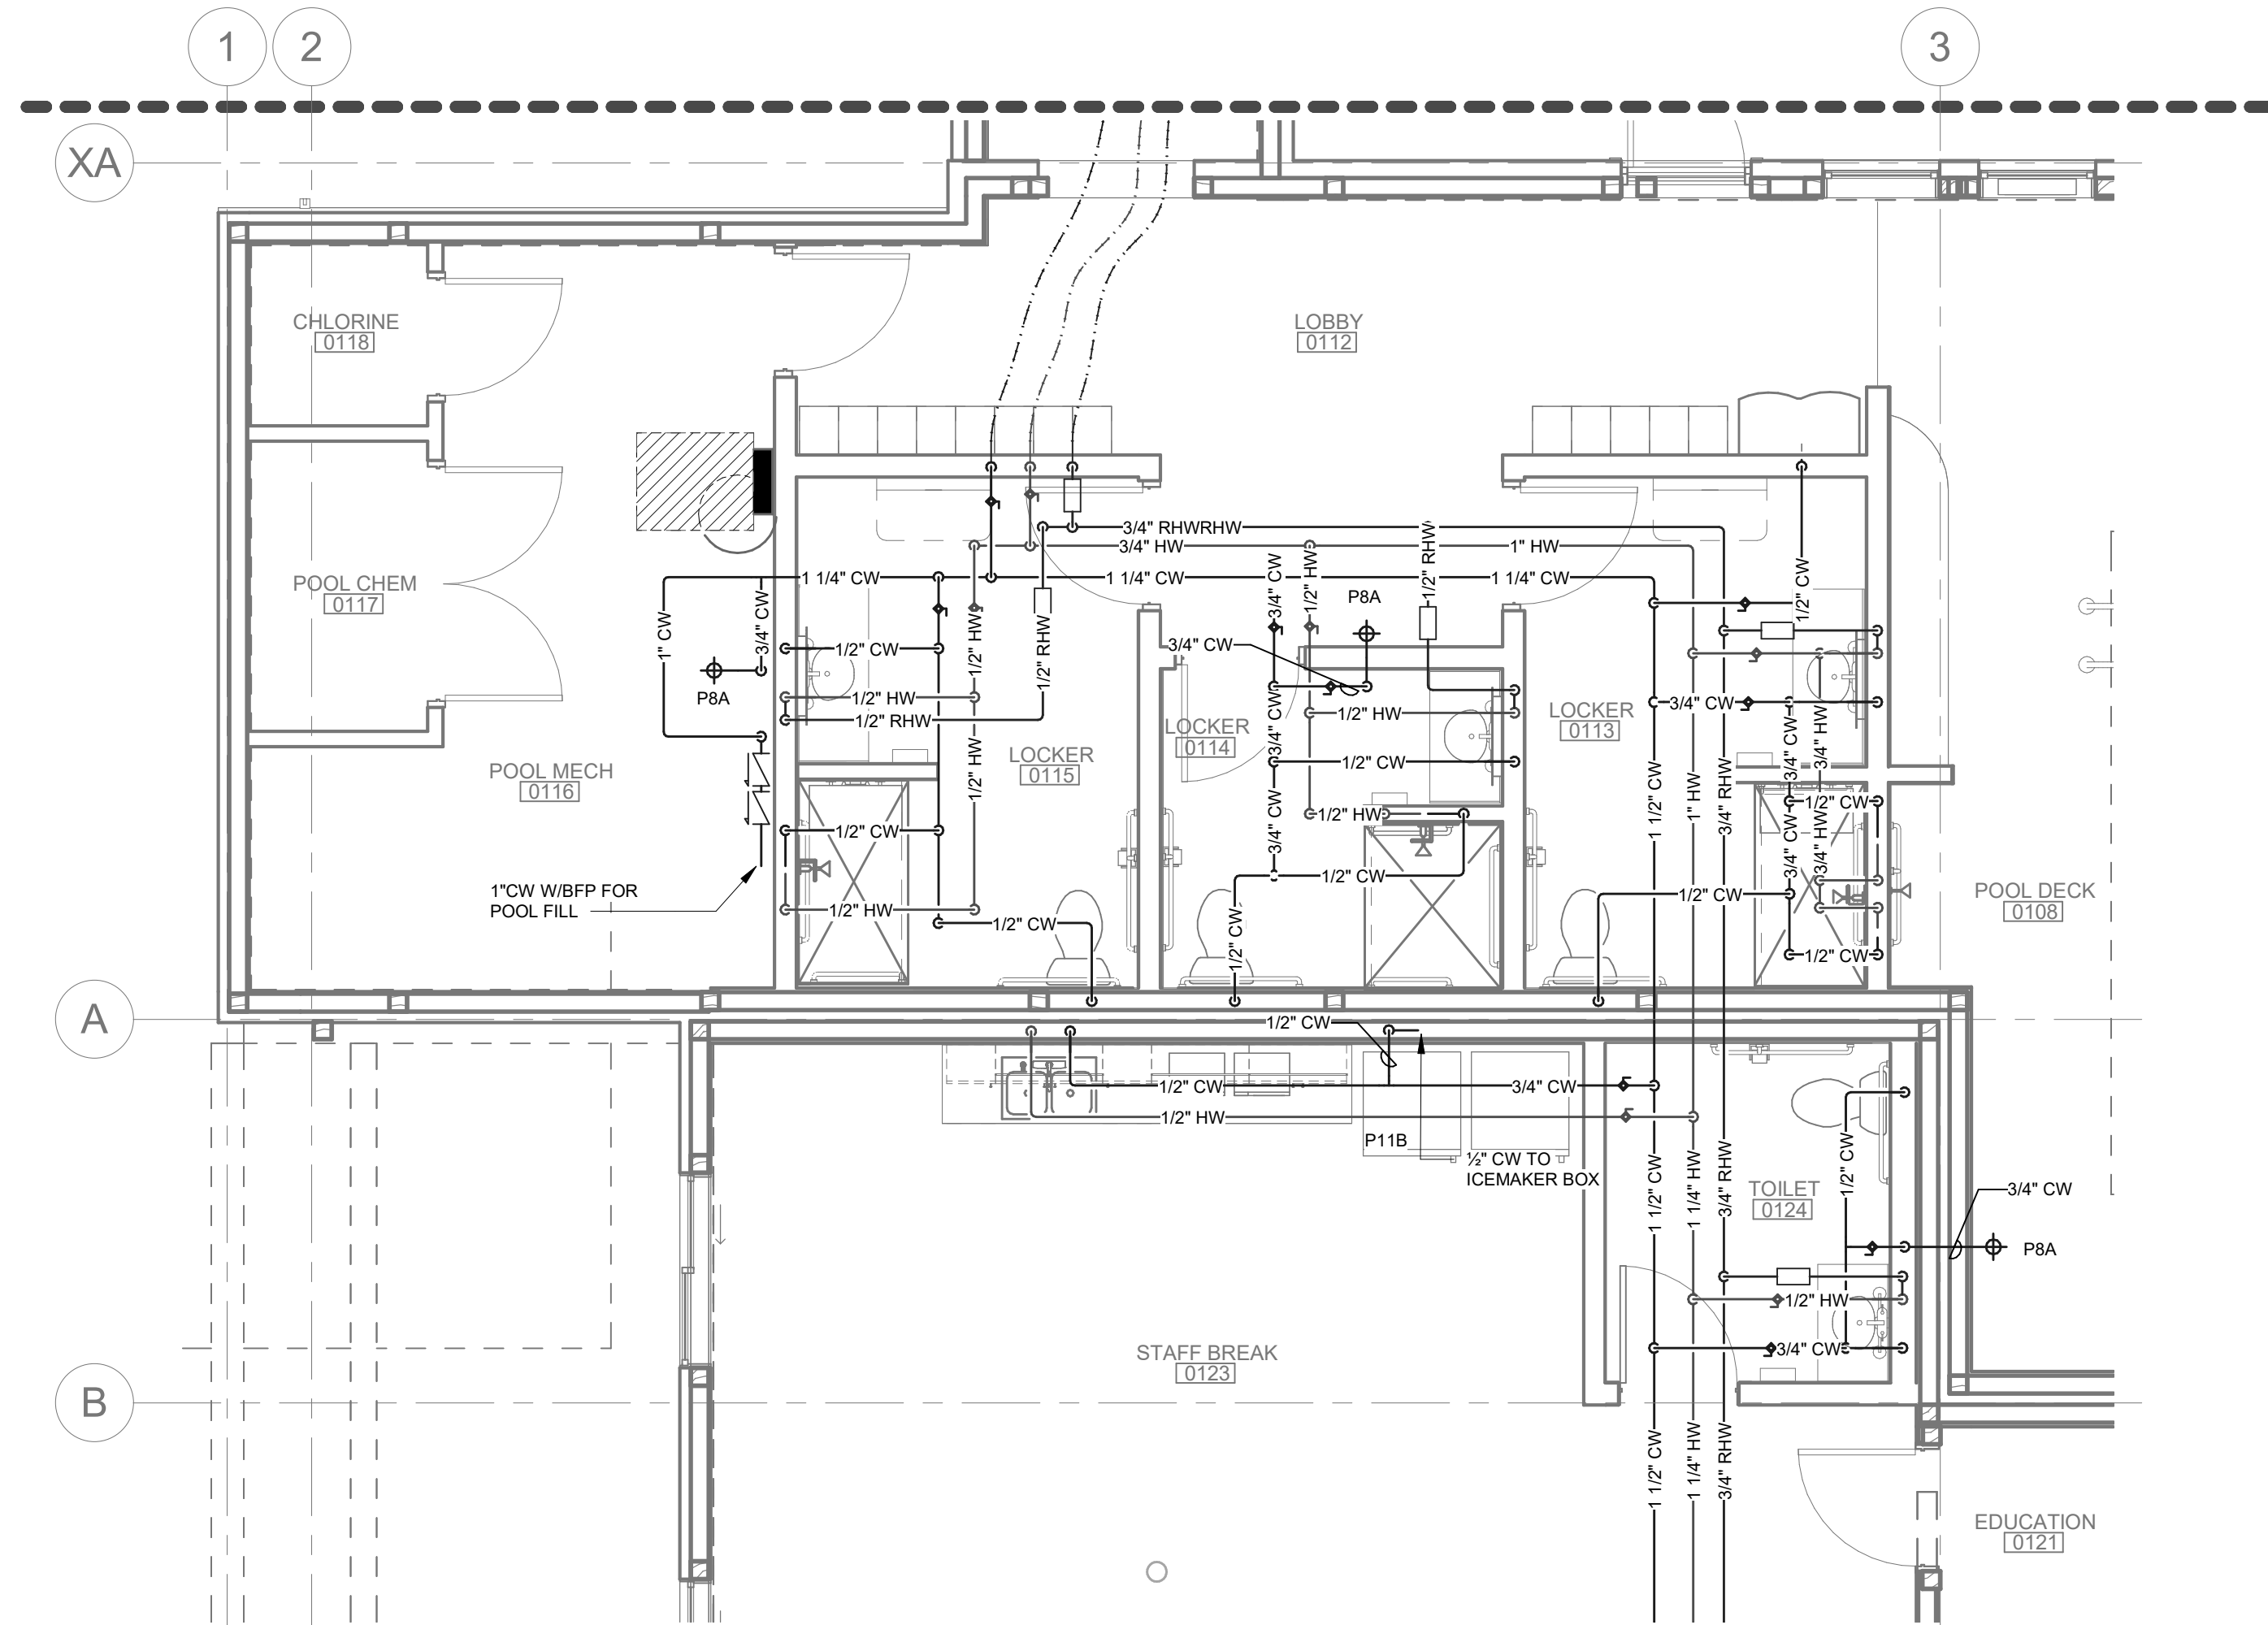


ENLARGED POOL AREA DOMESTIC
WATER PLAN
1/4" = 1'-0"

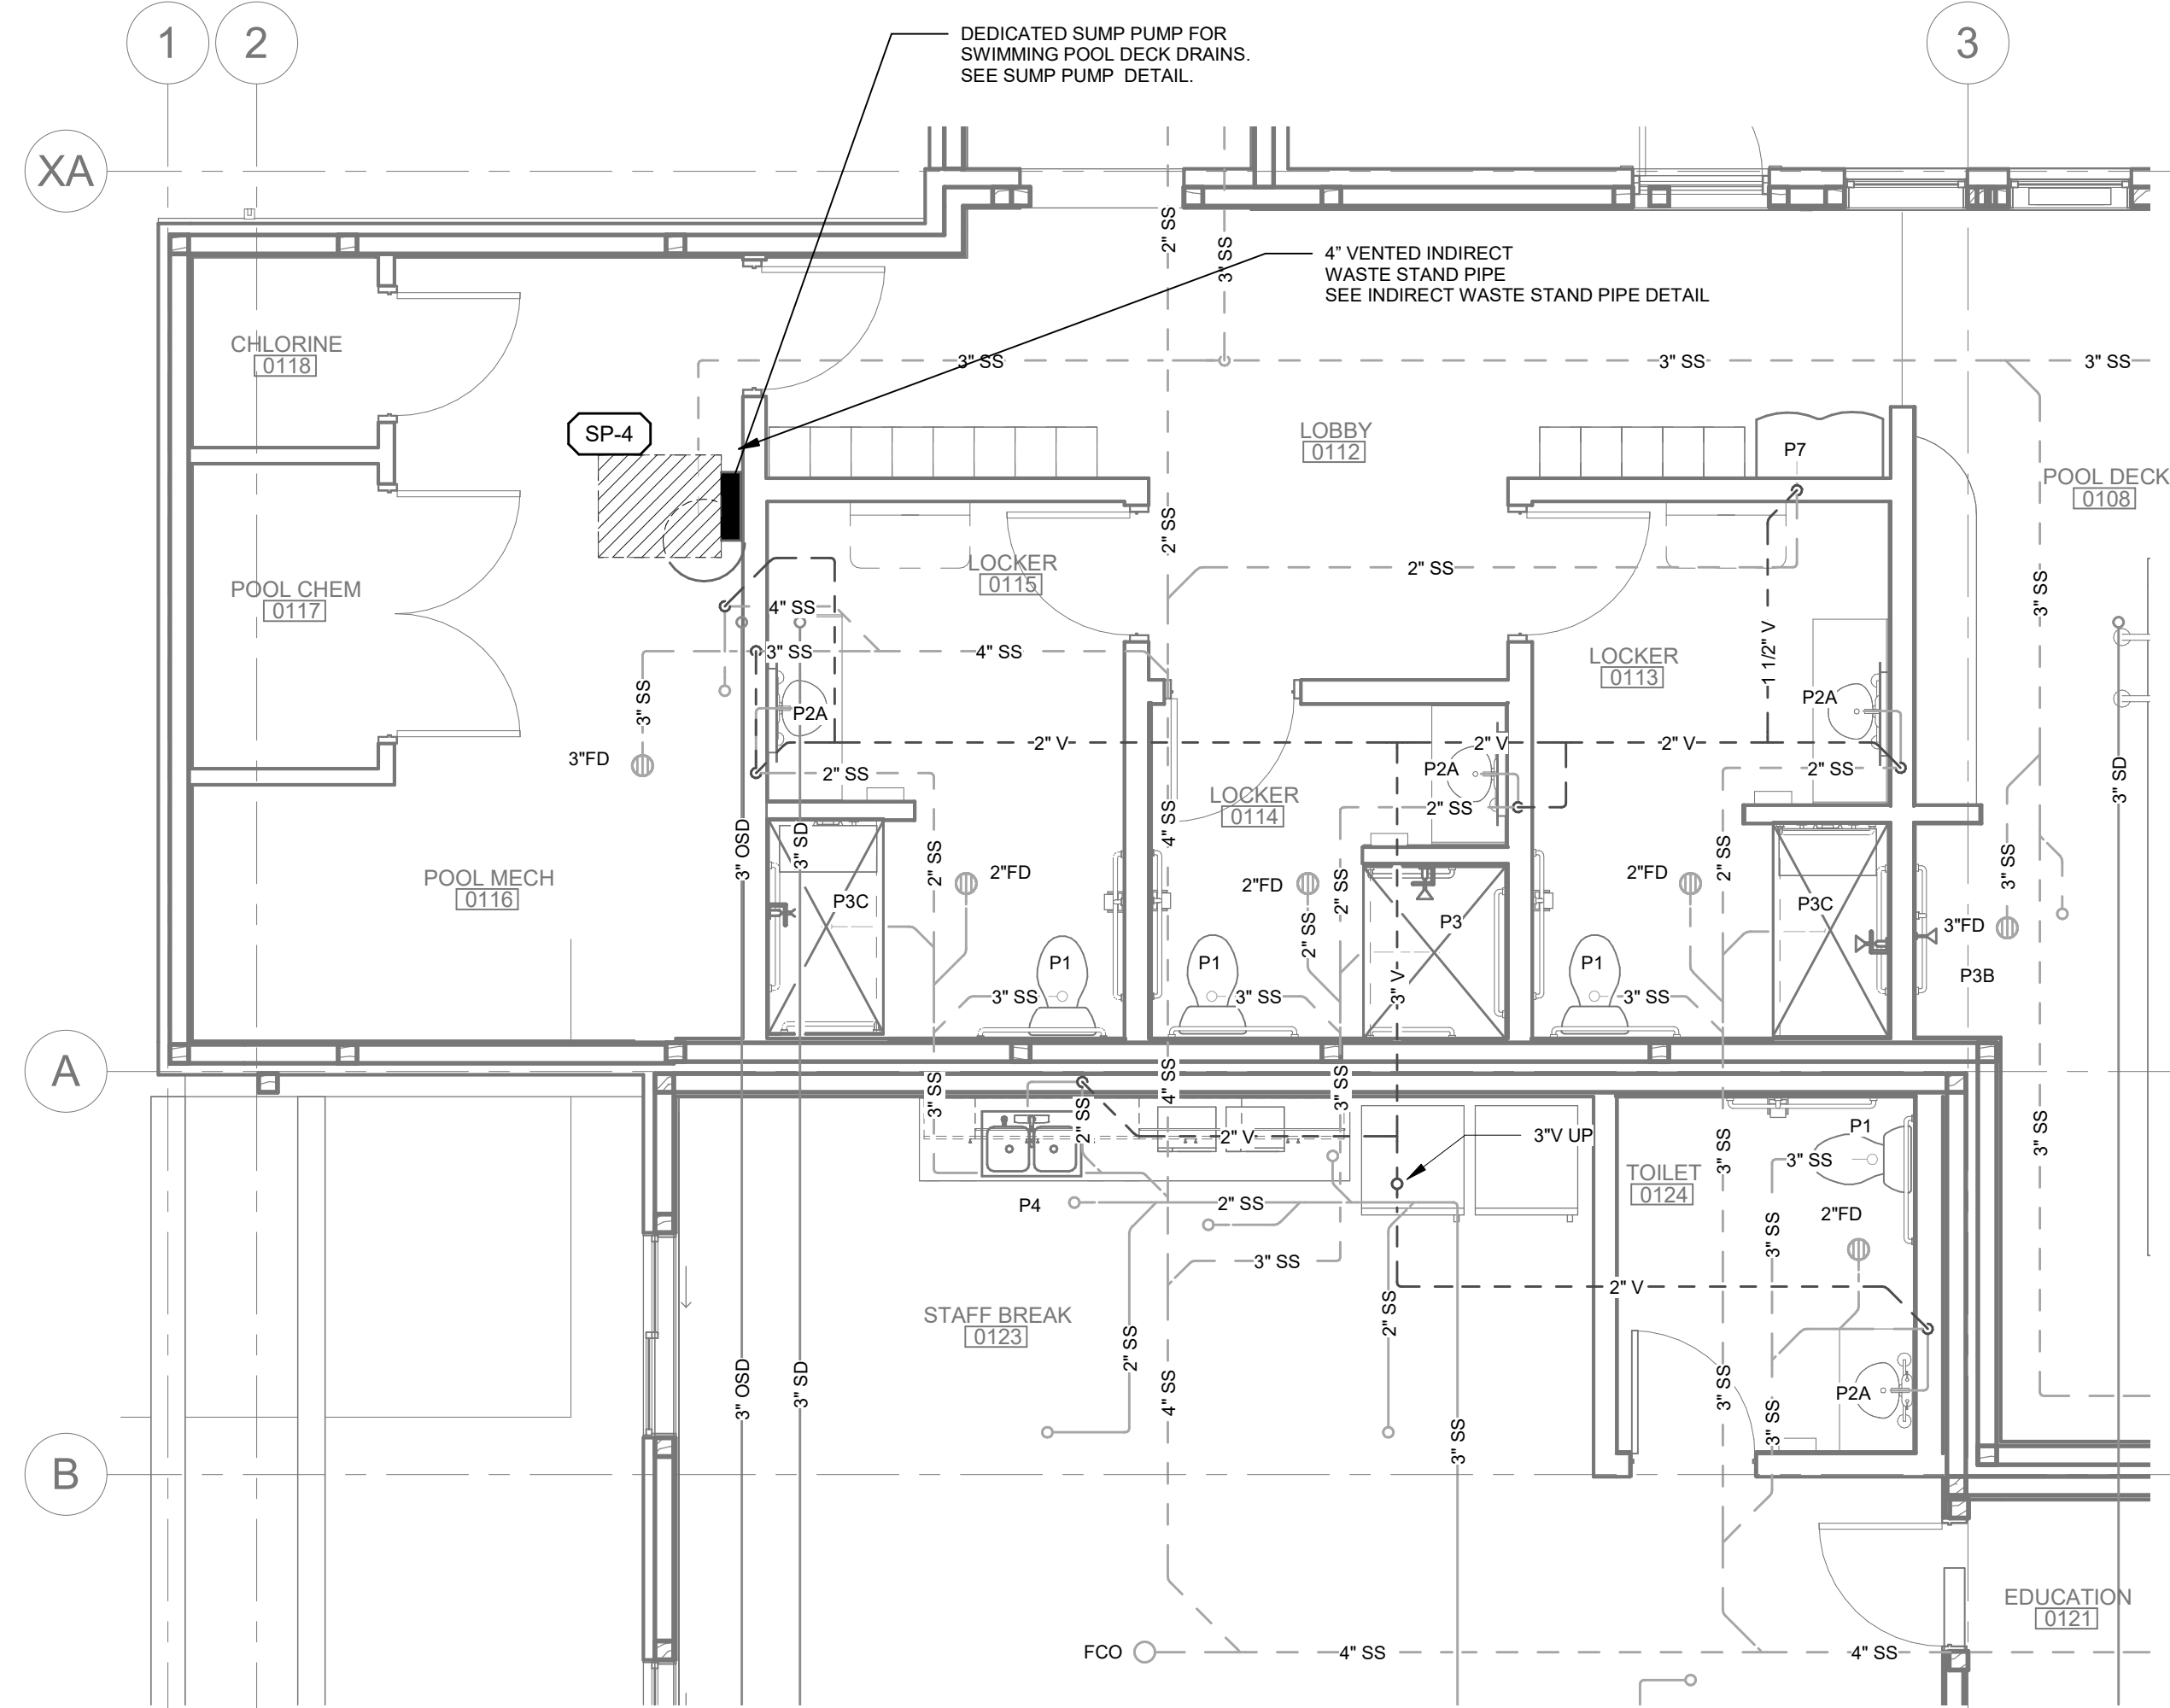

ENLARGED POOL AREA DWV PLAN
1/4" = 1'-0"

KITCHEN AIR BALANCE SCHEDULE					
EXHAUST			MAKE-UP AIR		
TAG	SERVES	CFM	TAG	SERVES	CFM
KEF-1	GREASE HOOD	900	KMUA-1	GREASE HOOD	800
KEF-2	DISHWASHER HOOD	600	ERV-2	KITCHEN	600
-	-	-	-	-	-
-	-	-	-	-	-
TOTAL EXHAUST AIR:		1500	TOTAL MAKE-UP AIR:		1400
SYSTEM BALANCE:					
PRESSURIZATION (NEG):		(100 CFM)			
PERCENTAGE (NEG):		(7%)			

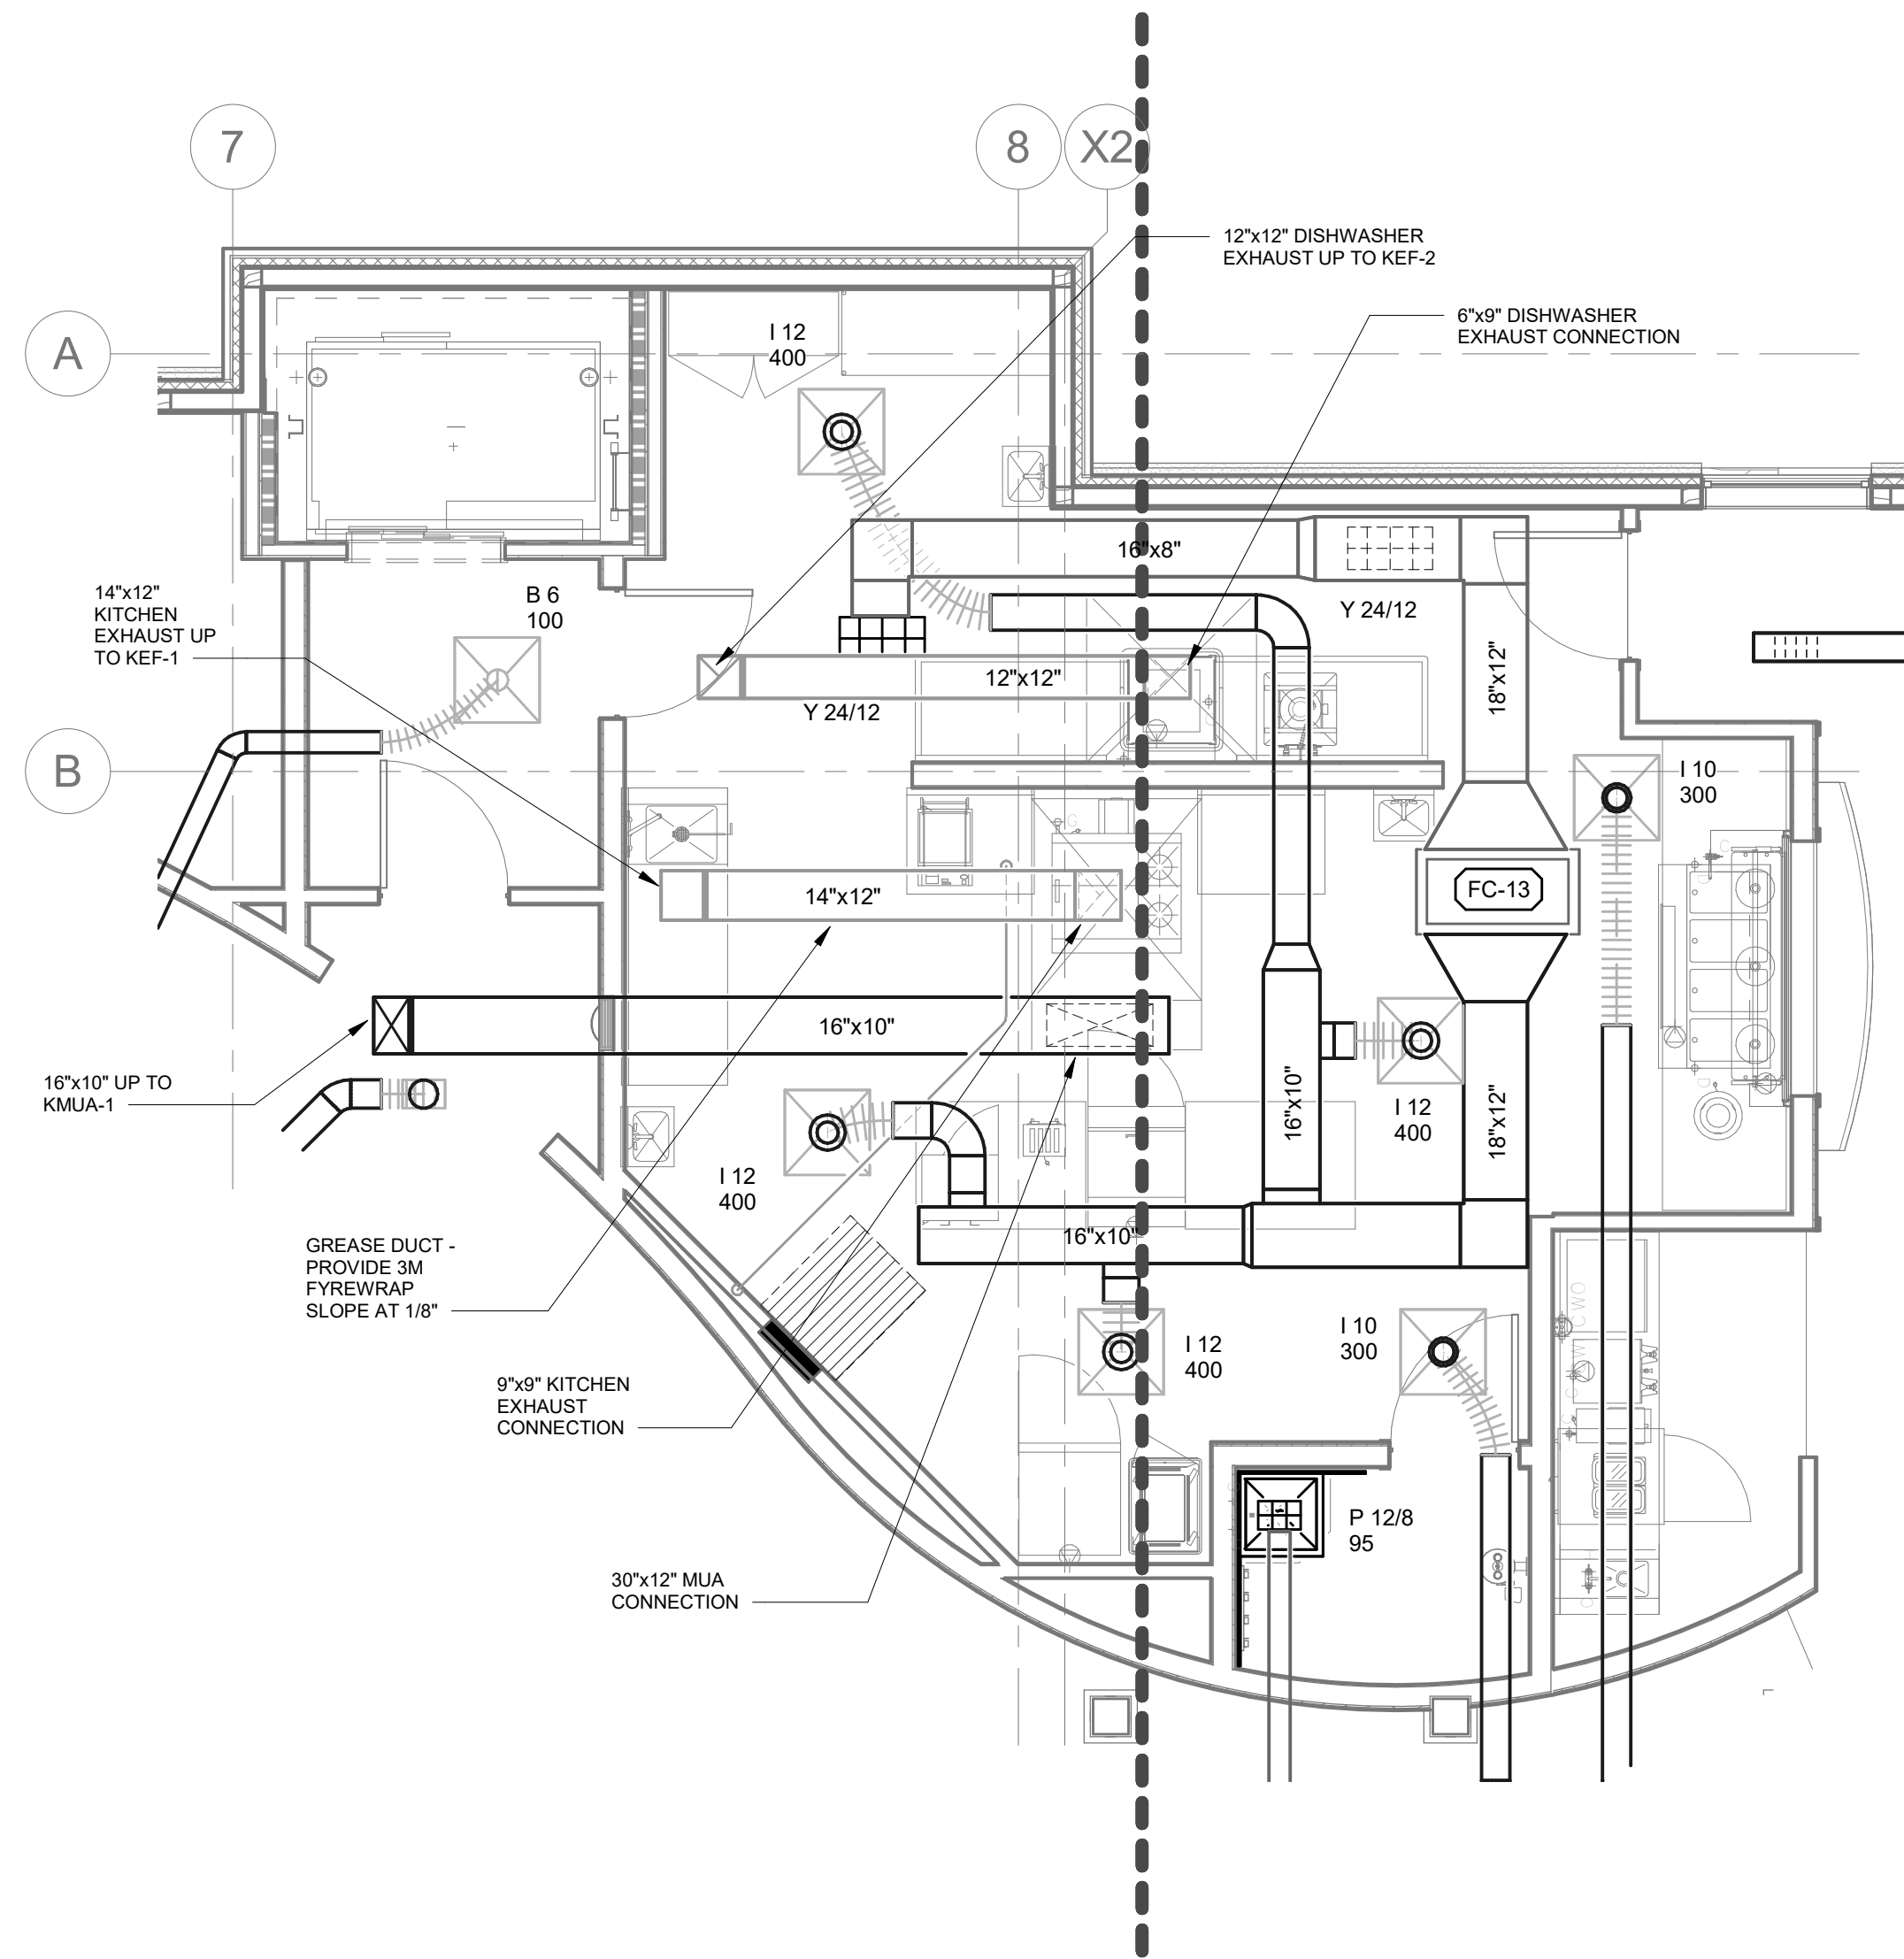


ENLARGED KITCHEN HVAC PLAN
1/4" = 1'-0"

STEEN
ENGINEERING

763-585-6742
763-585-6757 fax
Email: steen@steeneng.com
5430 Douglas Drive North
Minneapolis, MN 55429

in = site
architects

1000 university ave. w. suite 130
st. paul, minnesota 55104
612-252-4820

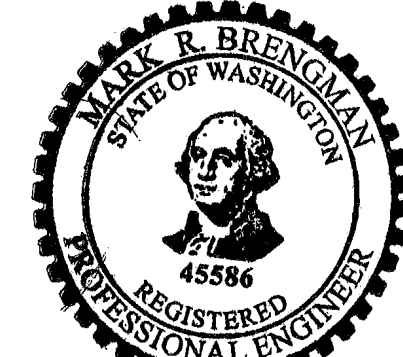


Mark R. Breneman
Signature

Mark R. Breneman
Typed or Printed Name

Mechanical 12/02/24
Discipline Date

WESLEY BRADLEY PARK PHASE 2 - CARE CENTER 707 39TH AVENUE SE PUYALLUP, WA 98374

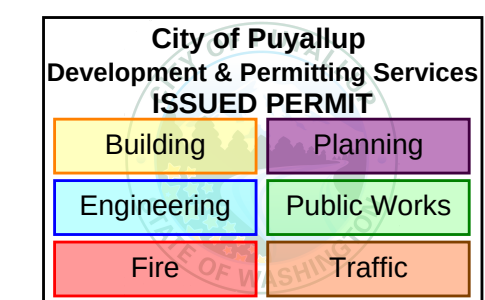

CARE CENTER
PERMIT SET
December 2, 2024

REVISIONS

No.	Description	Date
-----	-------------	------

ISA202201

PROJECT NUMBER

RDB/DCA RDB/MRB


DRAWN BY CHECKED BY

WESLEY BRADLEY PARK
PHASE 2 - CARE CENTER

ENLARGED PLAN

M3.2

WESLEY BRADLEY PARK
PHASE 2 - CARE CENTER
707 39TH AVENUE SE
PUYALLUP, WA 98374

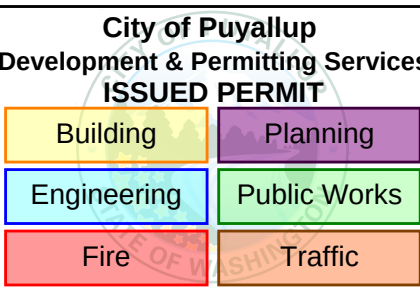

CARE CENTER
PERMIT SET
December 2, 2024

REVISIONS

No.	Description	Date
-----	-------------	------

ISA202201

PROJECT NUMBER

RDB

DRAWN BY


RDB

CHECKED BY


WESLEY BRADLEY PARK
PHASE 2 - CARE CENTER

PLUMBING RISERS


M4.0

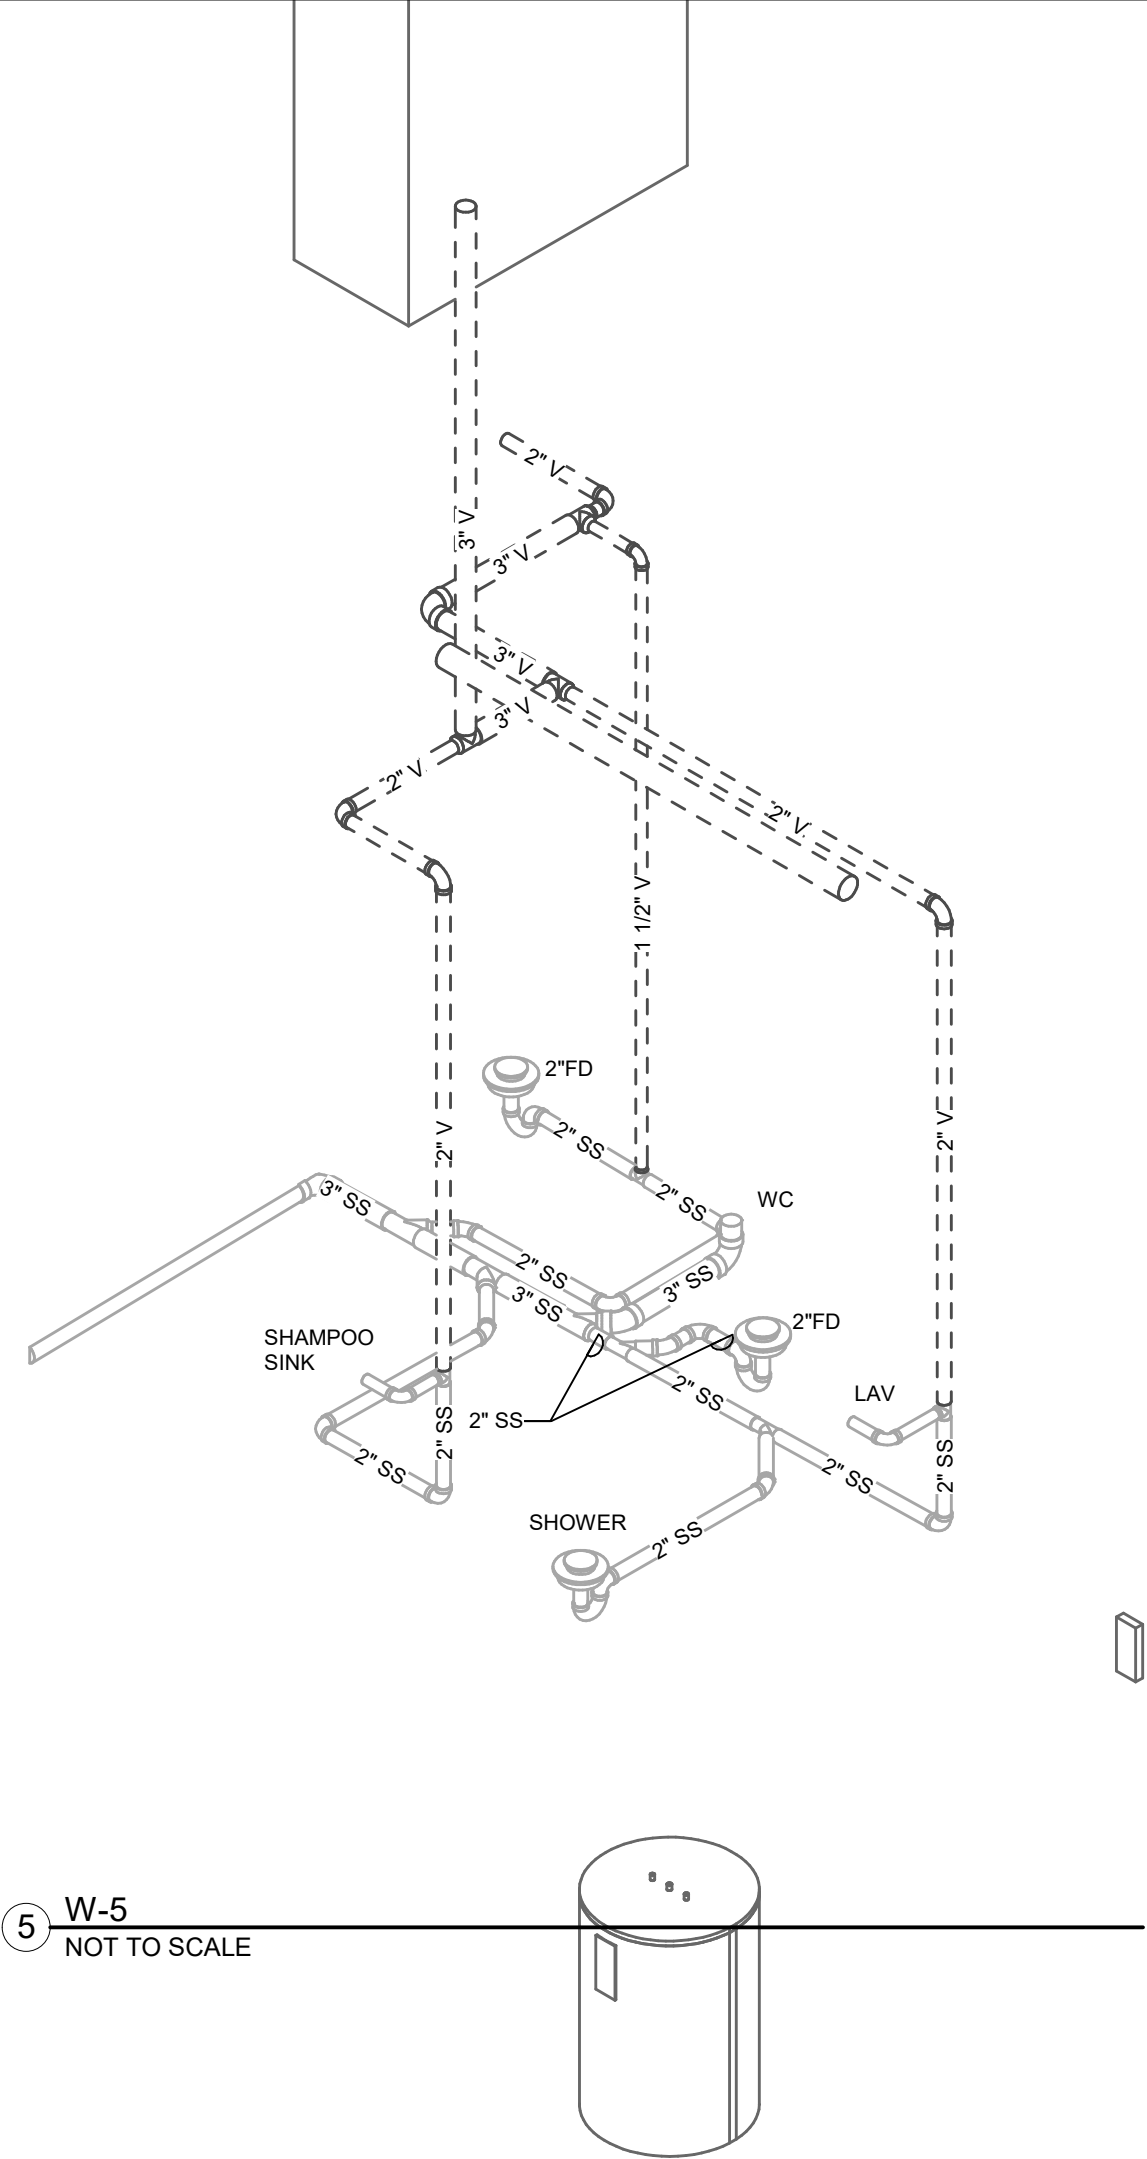


W-5
NOT TO SCALE

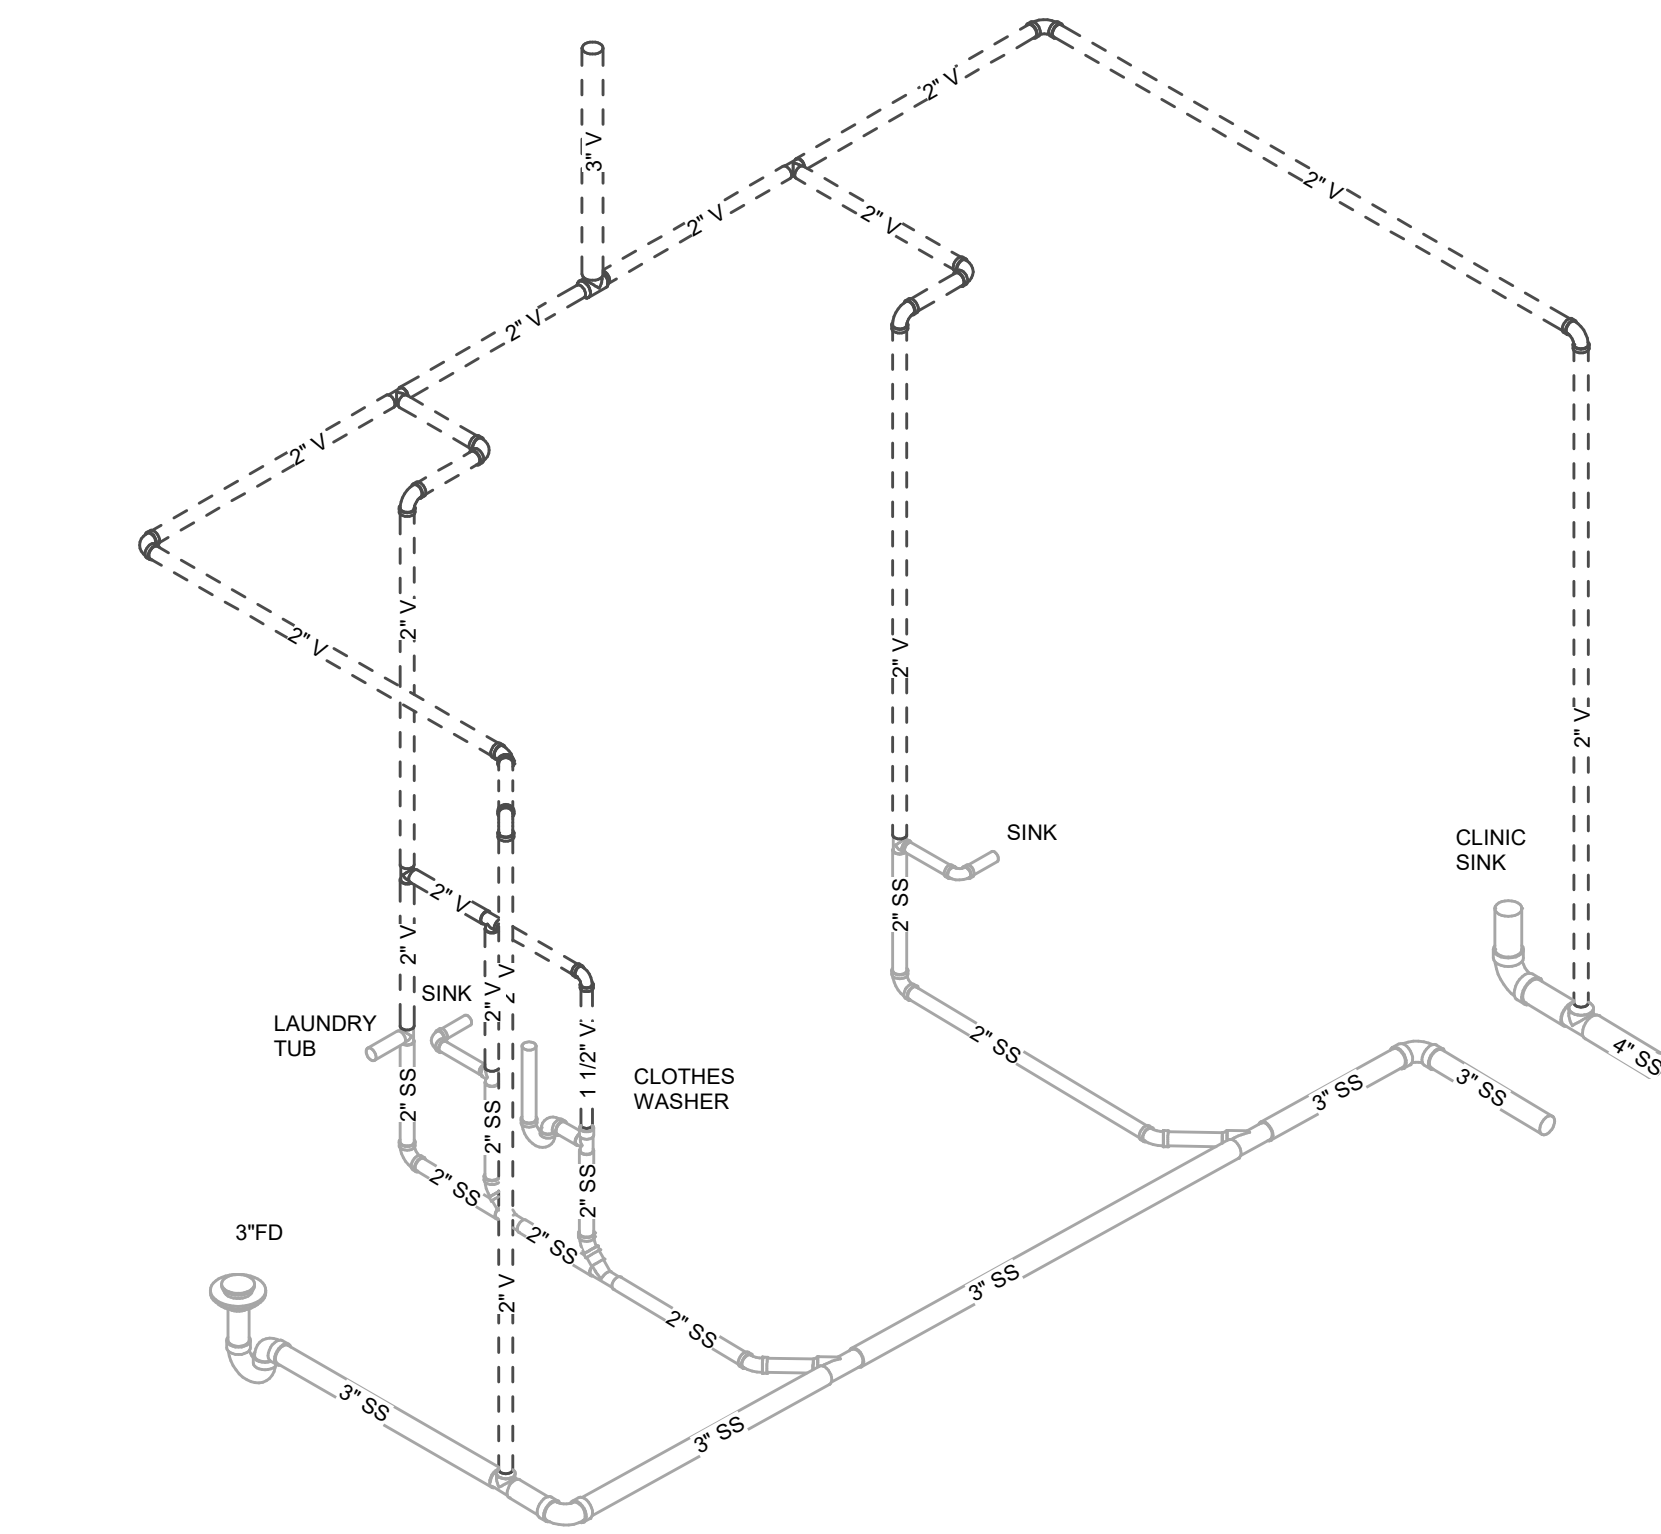


W-4
NOT TO SCALE

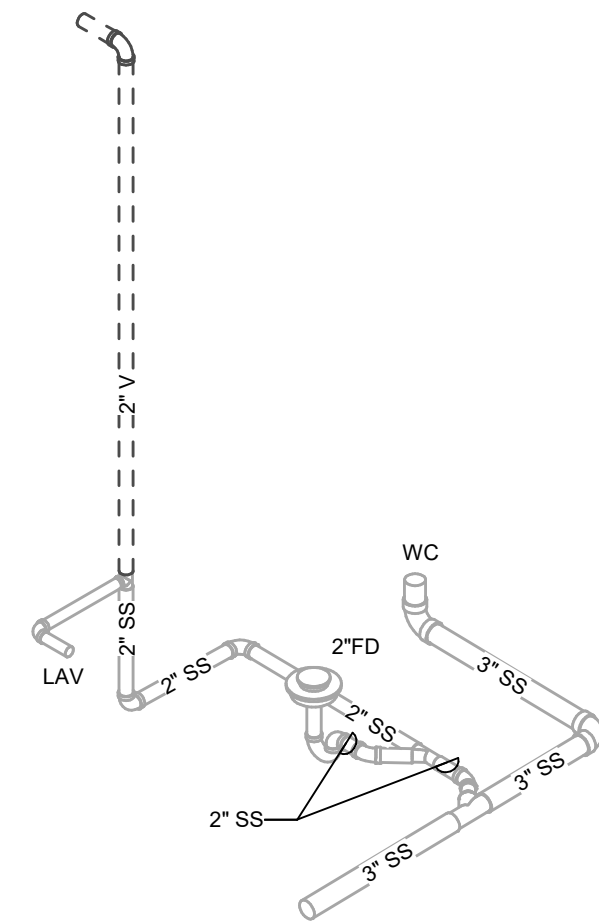


W-3
NOT TO SCALE

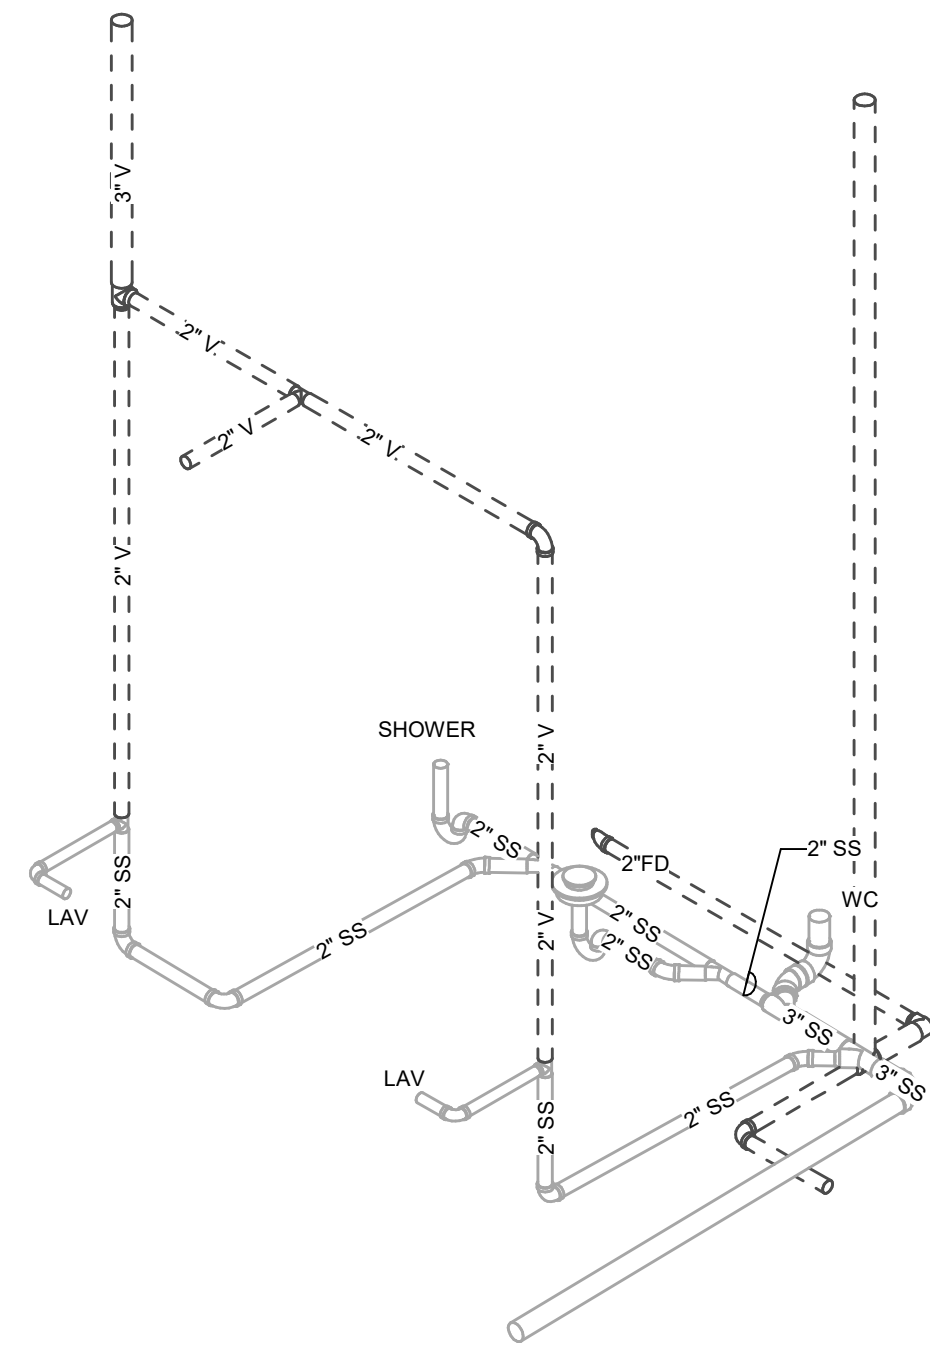


W-2
NOT TO SCALE

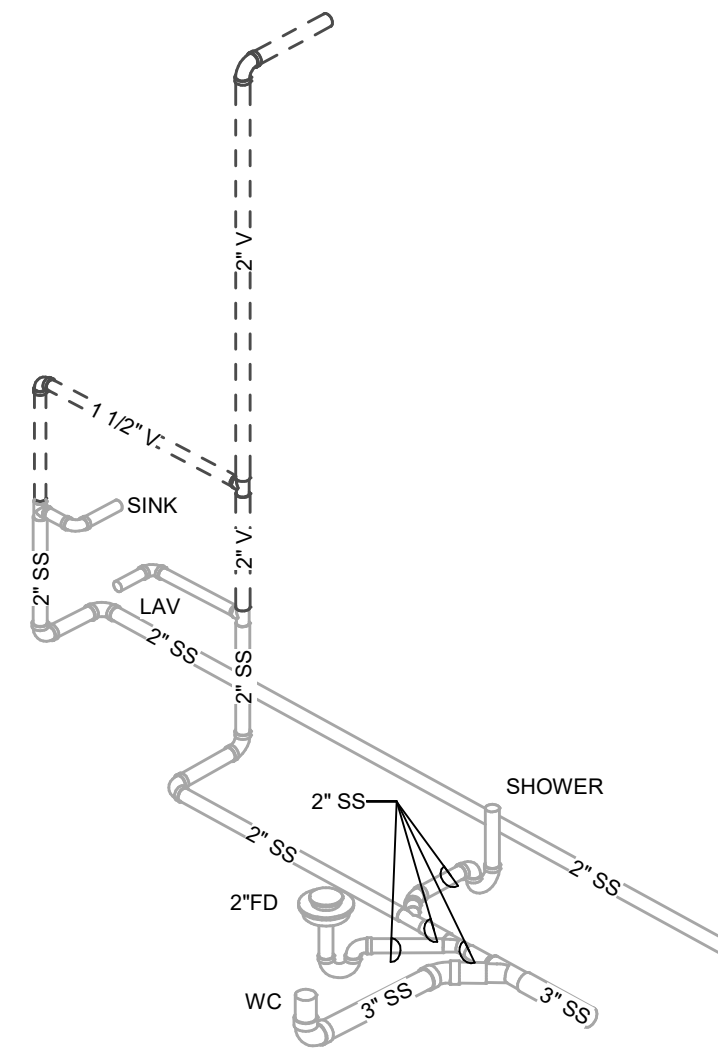


W-1
NOT TO SCALE

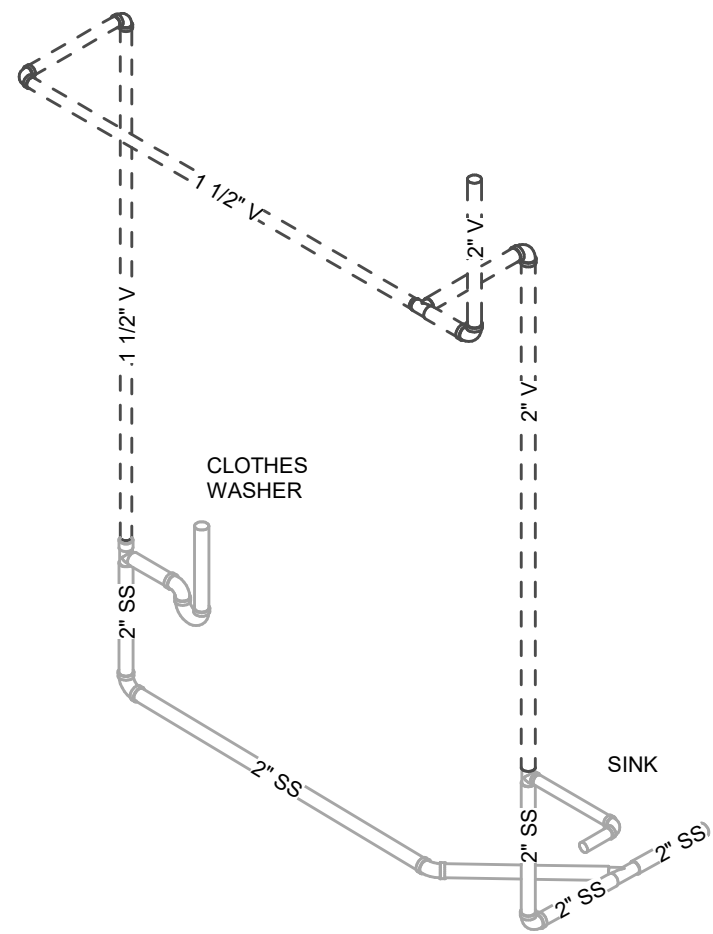


W-10
NOT TO SCALE

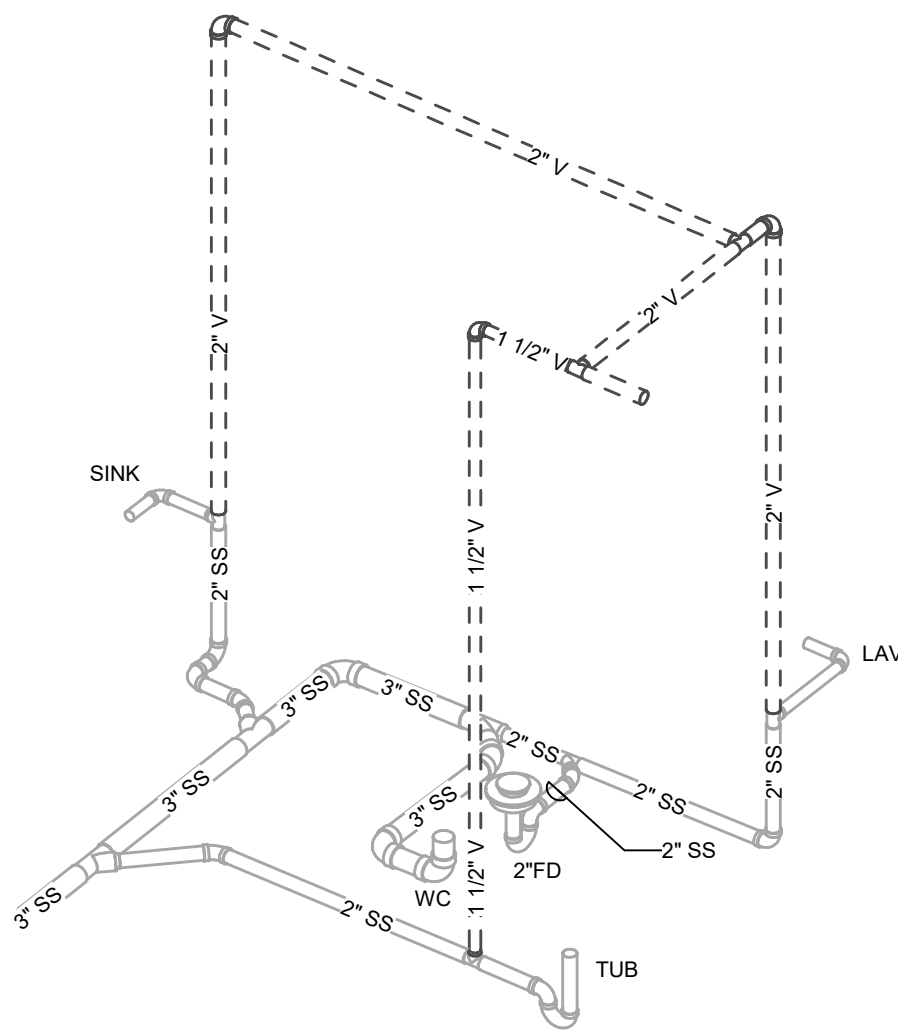


W-9
NOT TO SCALE

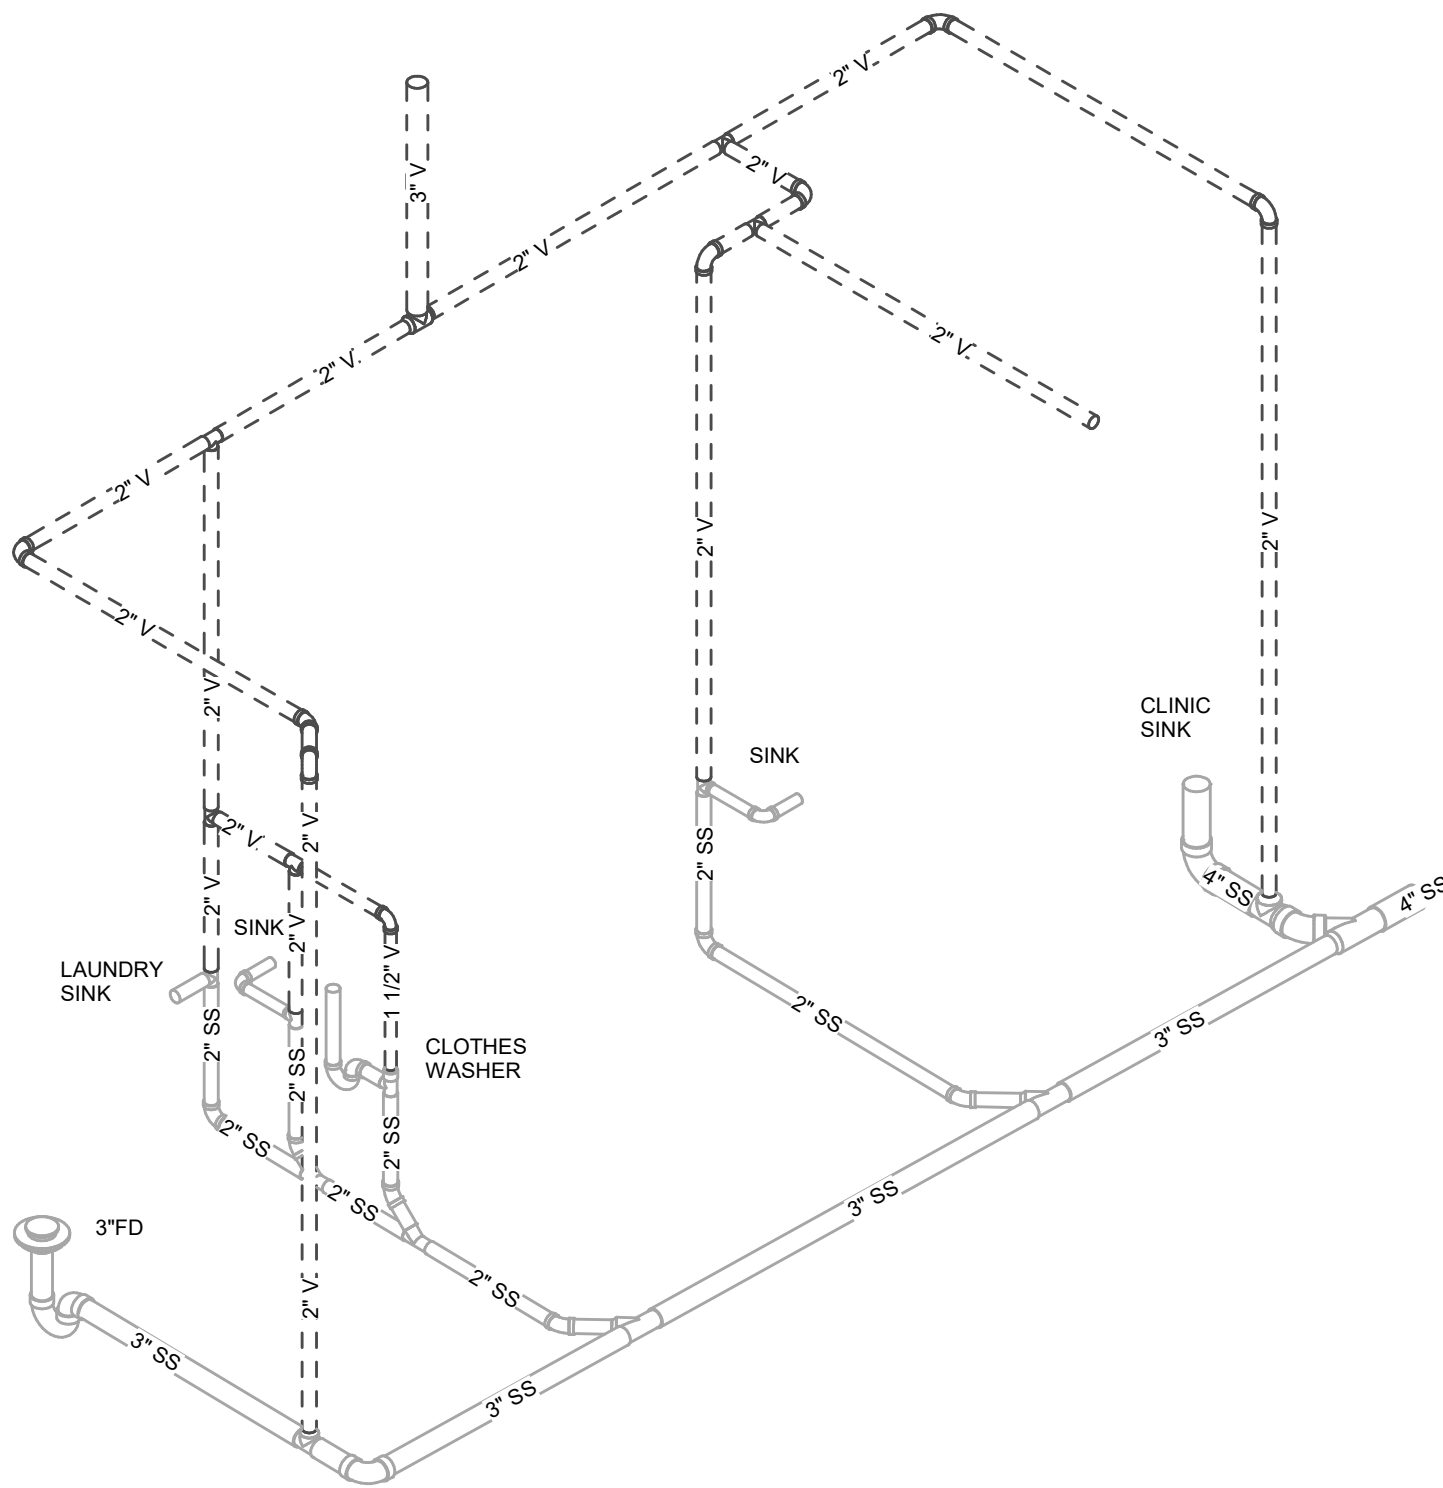


W-8
NOT TO SCALE

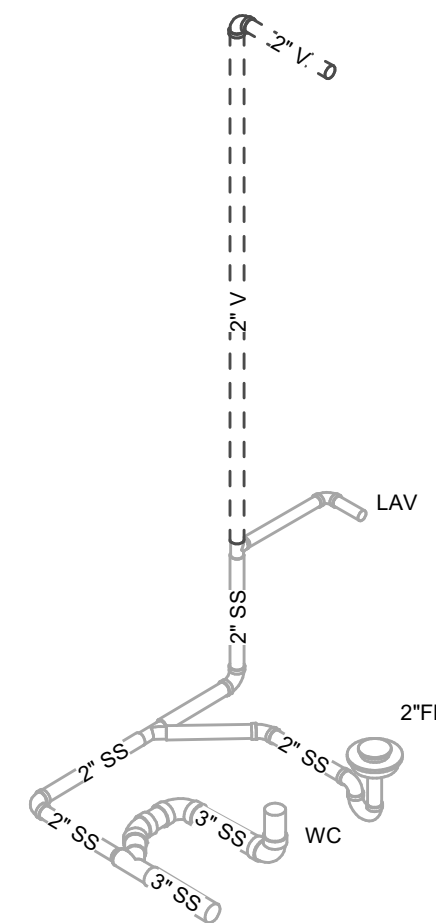


W-7
NOT TO SCALE

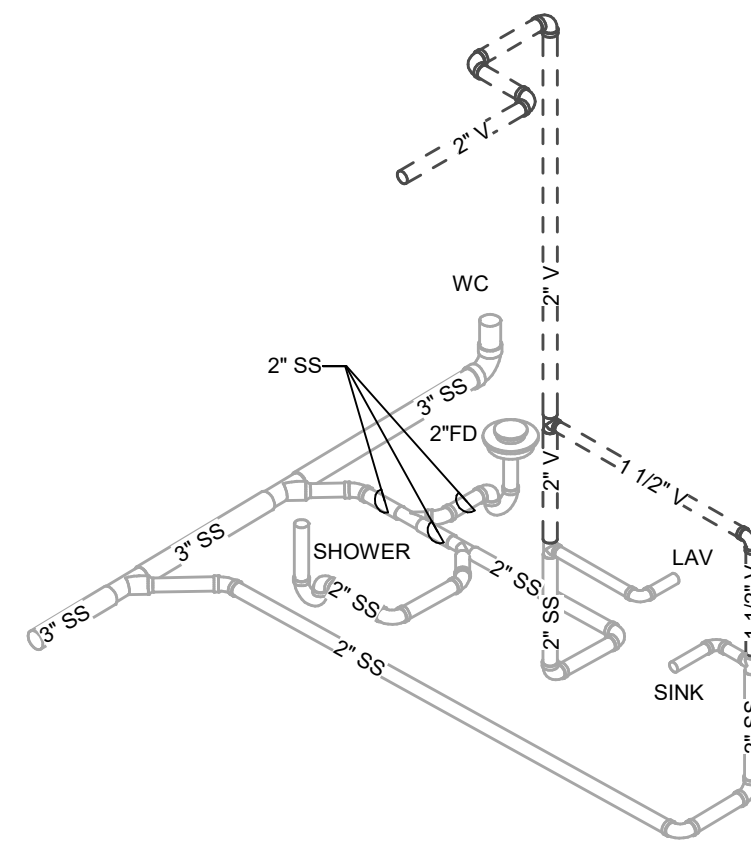


W-6
NOT TO SCALE

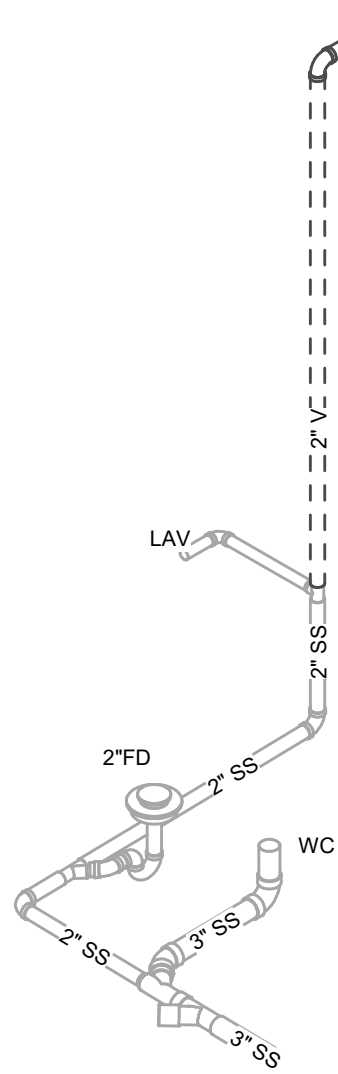

W-13
NOT TO SCALE

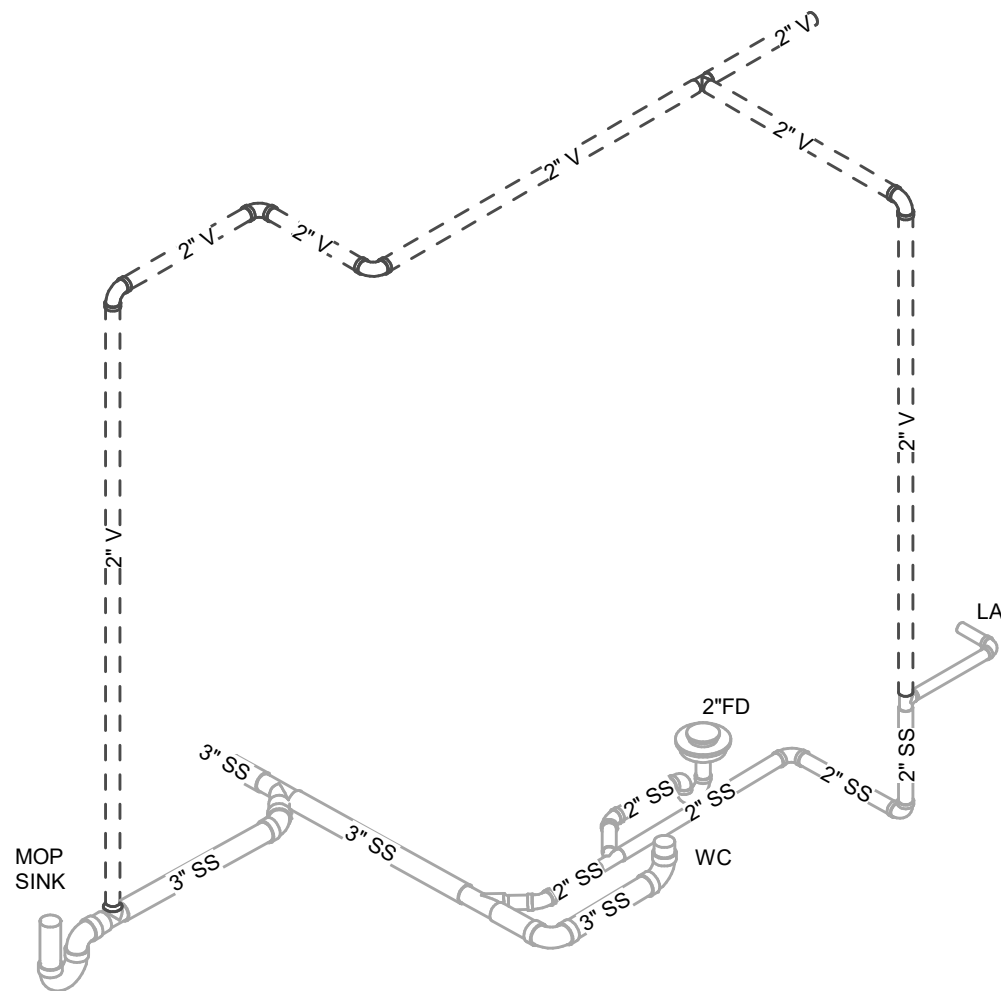


W-12
NOT TO SCALE

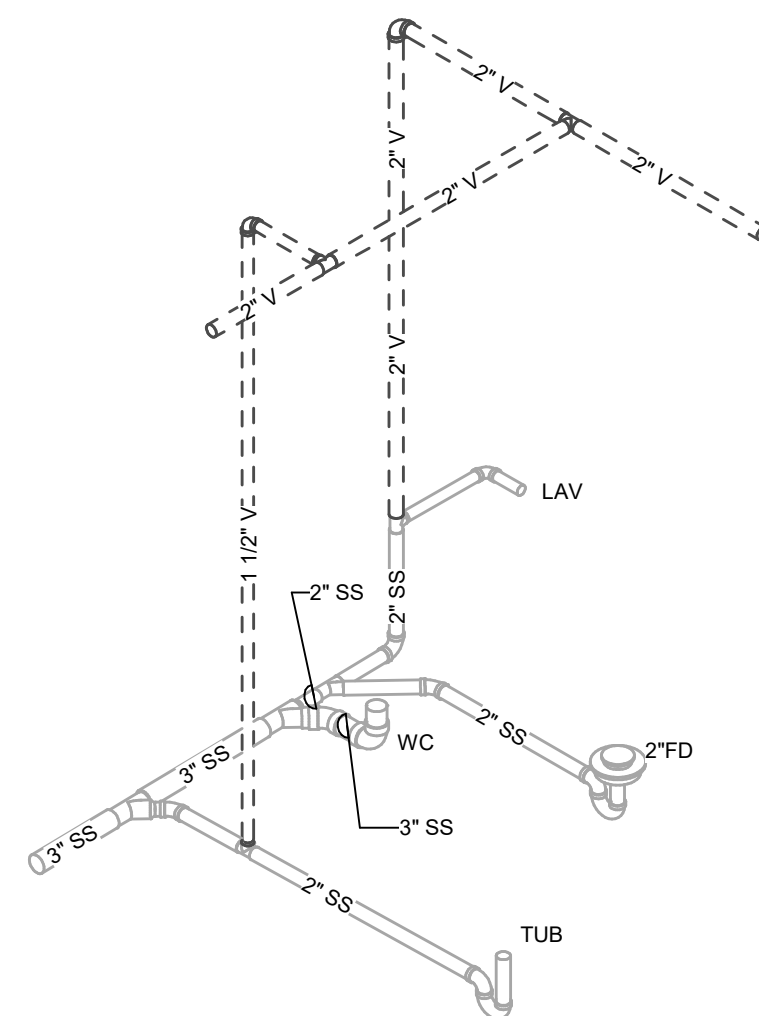


W-11
NOT TO SCALE


4 R-4
NOT TO SCALE

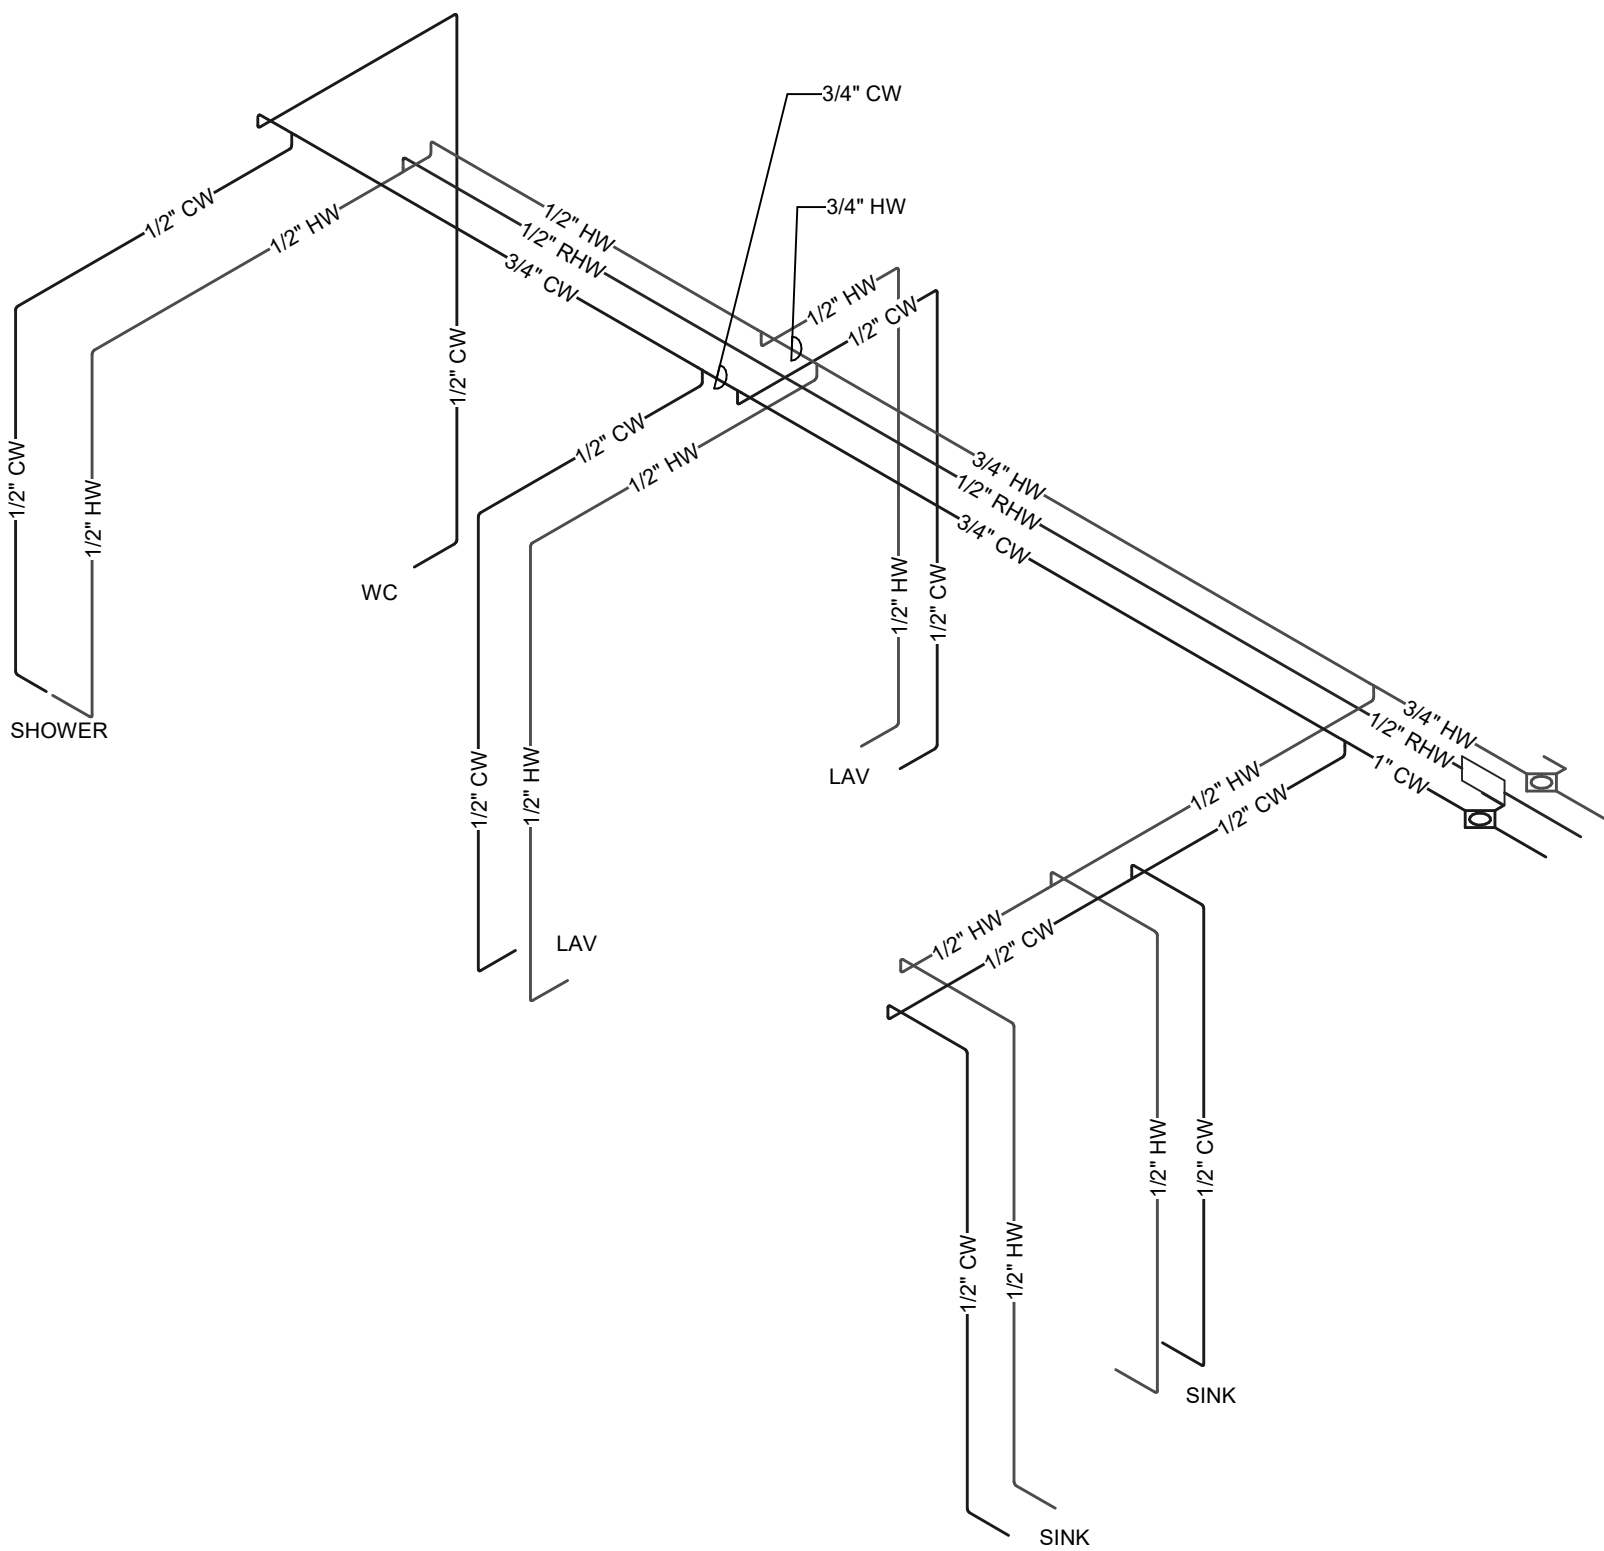



3 R-3
NOT TO SCALE

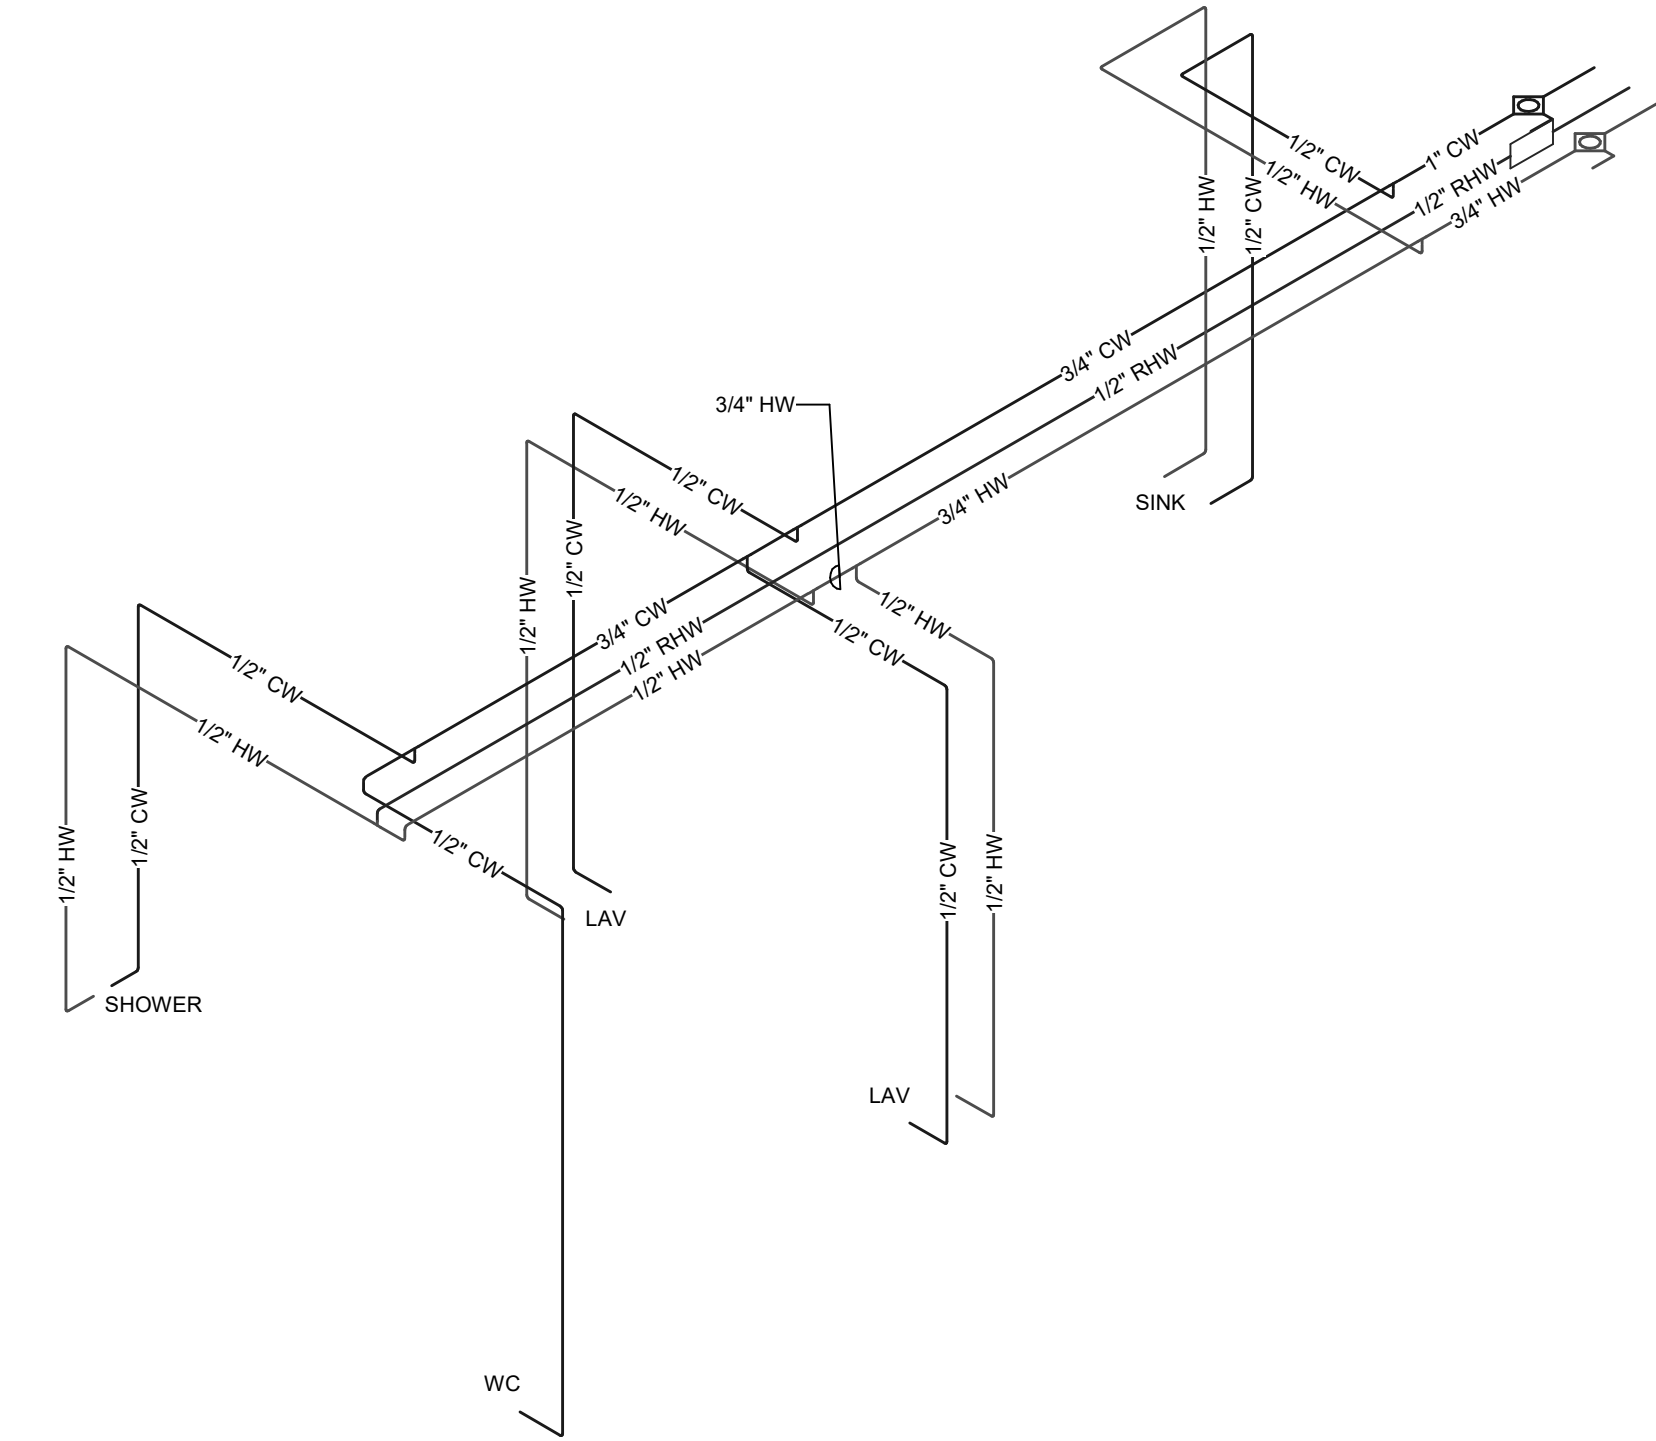


2 R-2
NOT TO SCALE

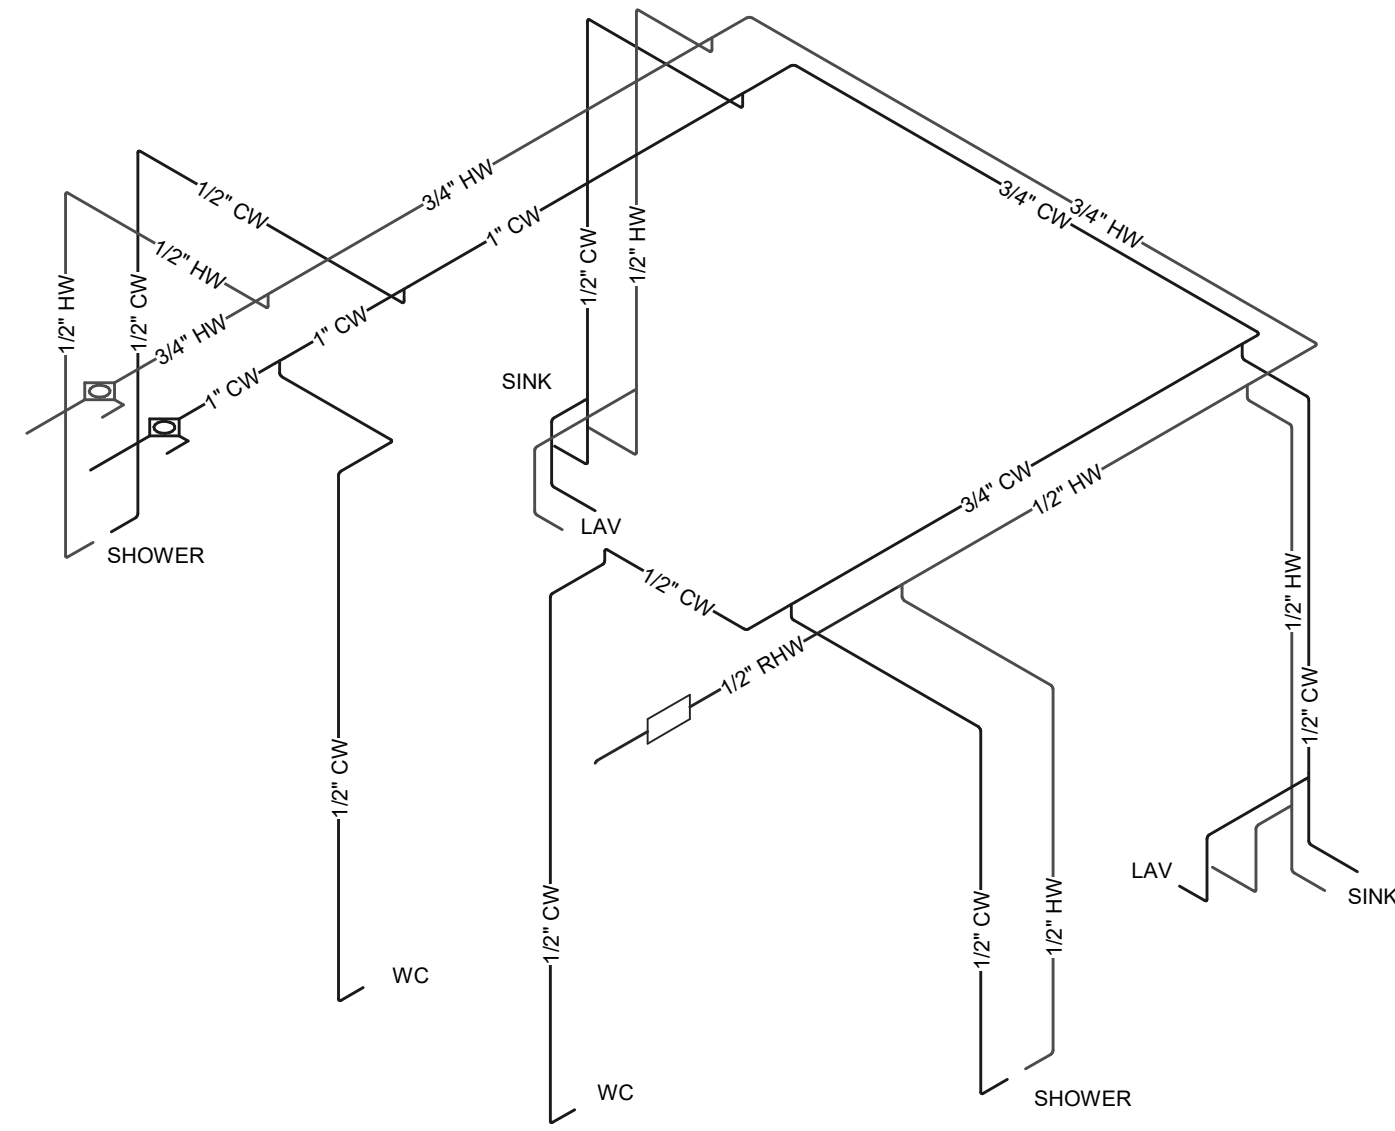


1 R-1
NOT TO SCALE

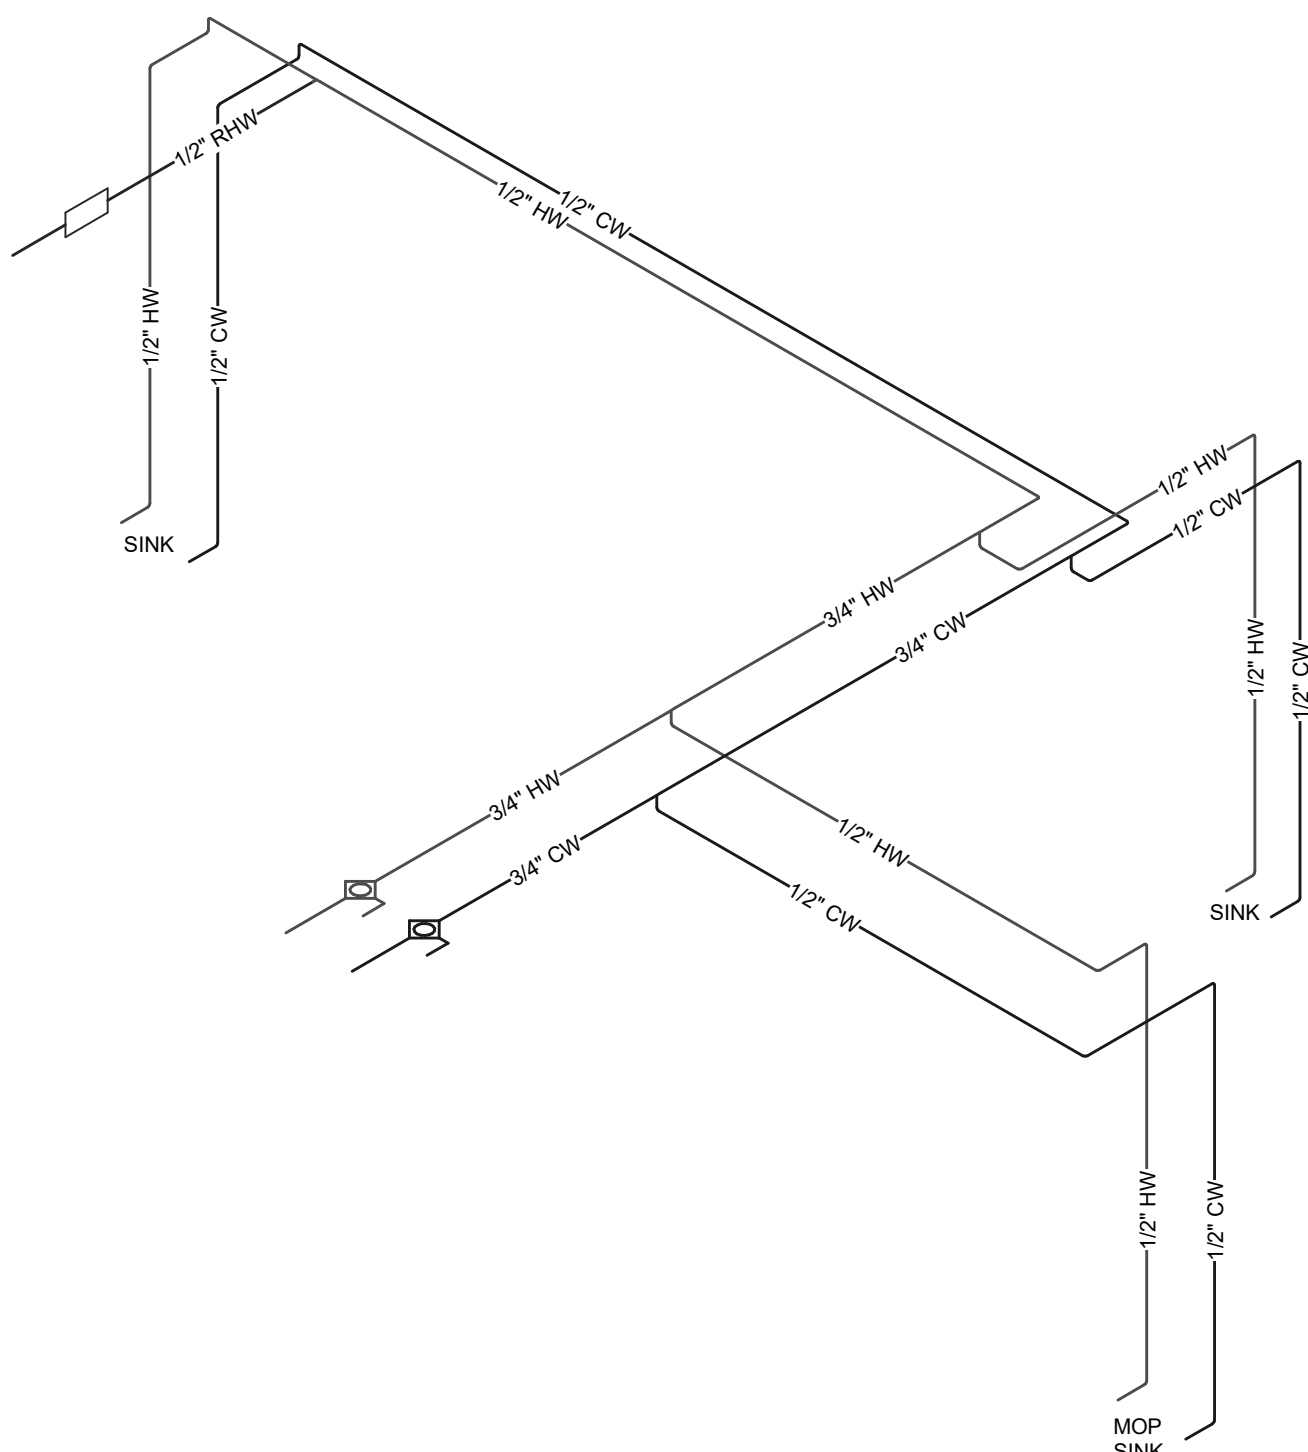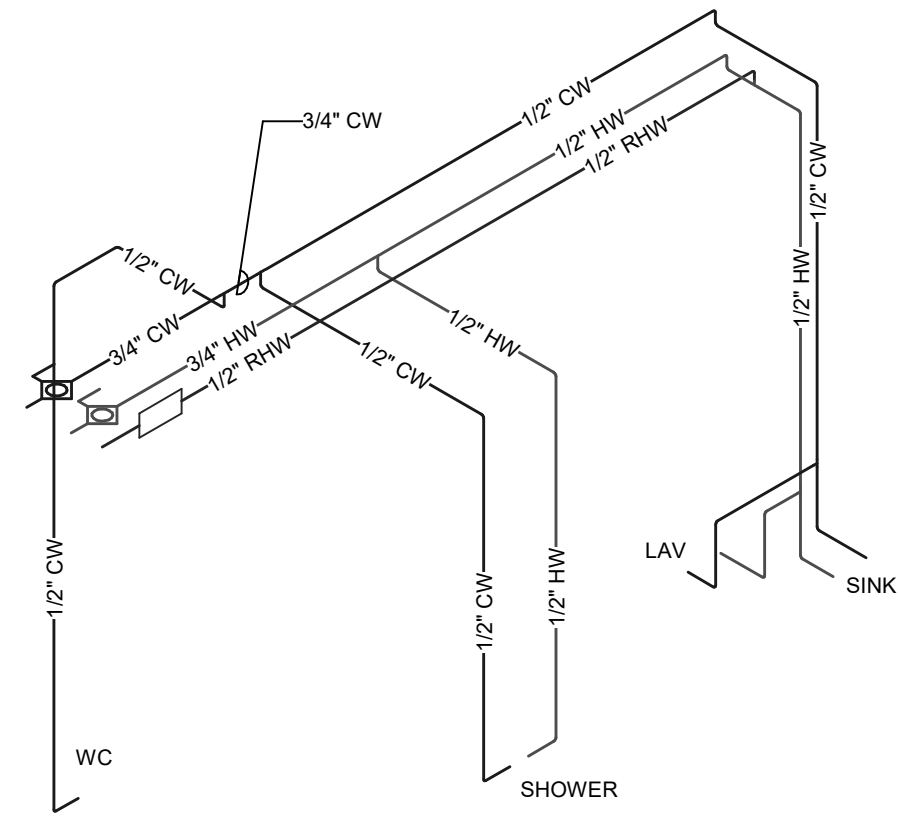


8 R-8
NOT TO SCALE

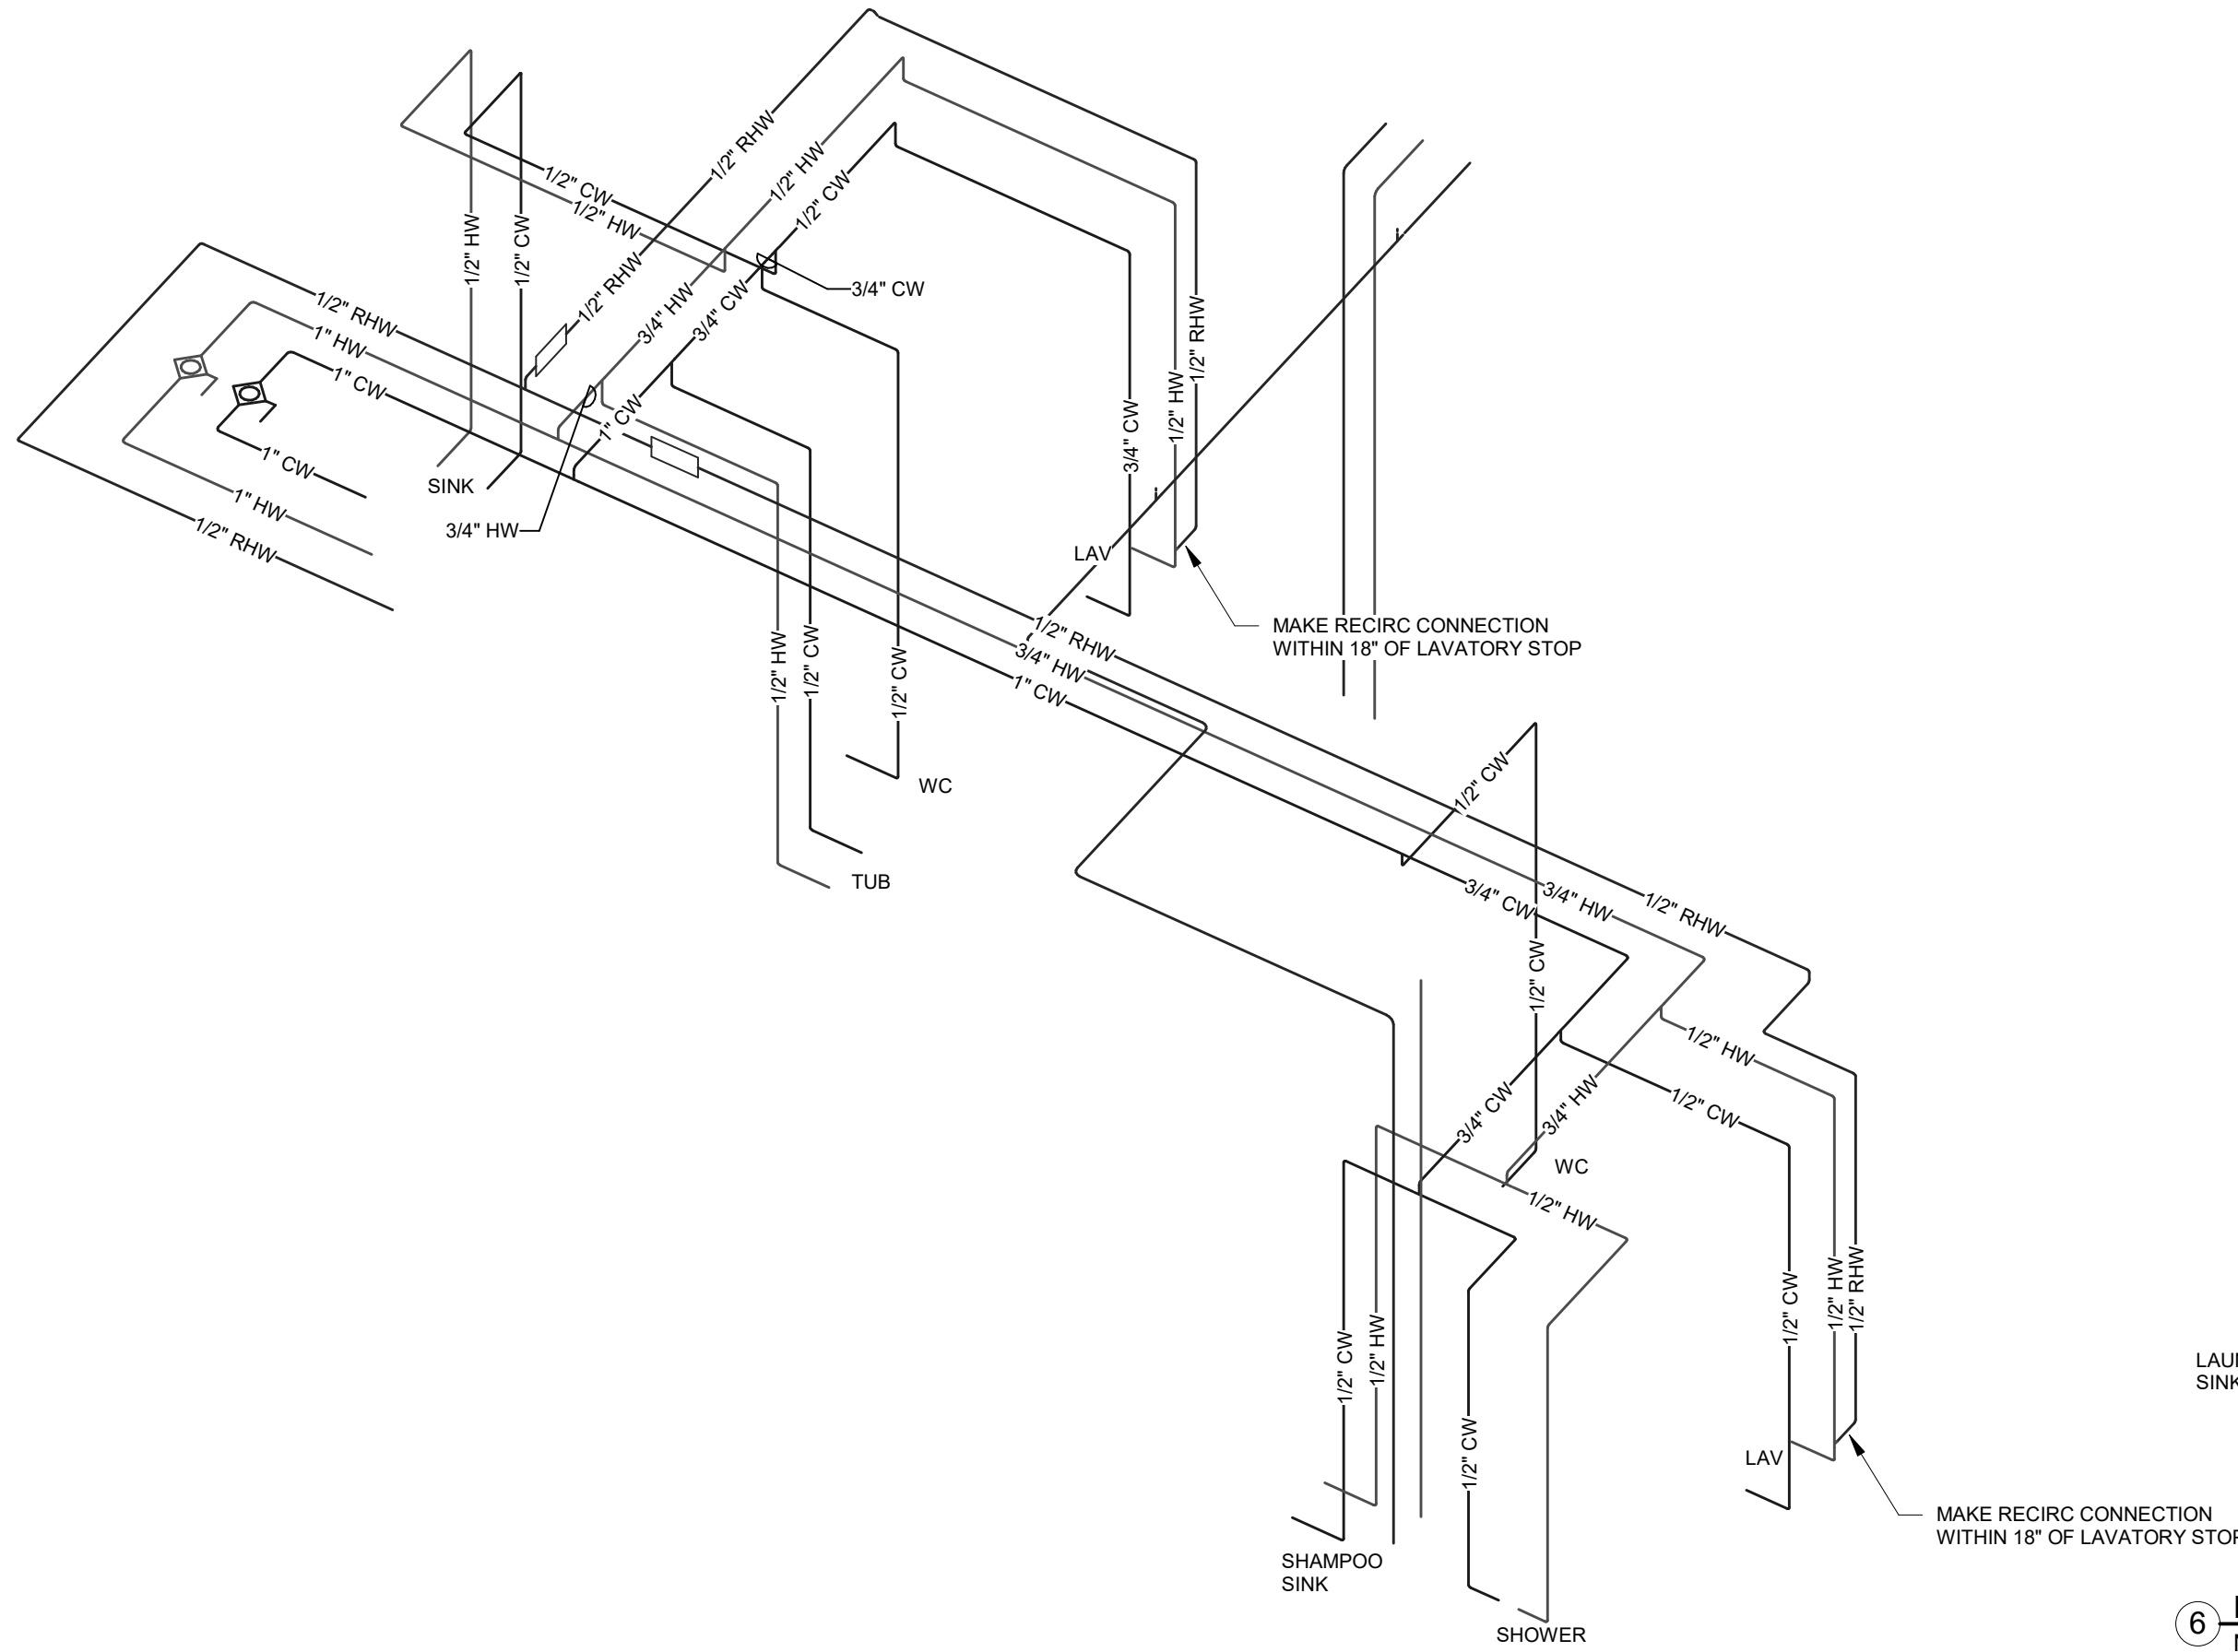

7 R-7
NOT TO SCALE

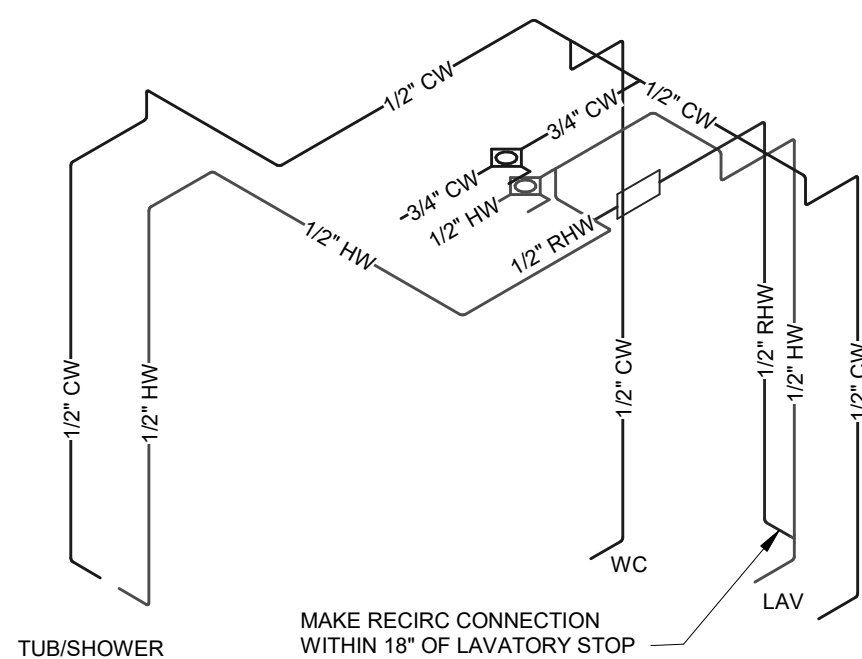


11 R-11
NOT TO SCALE

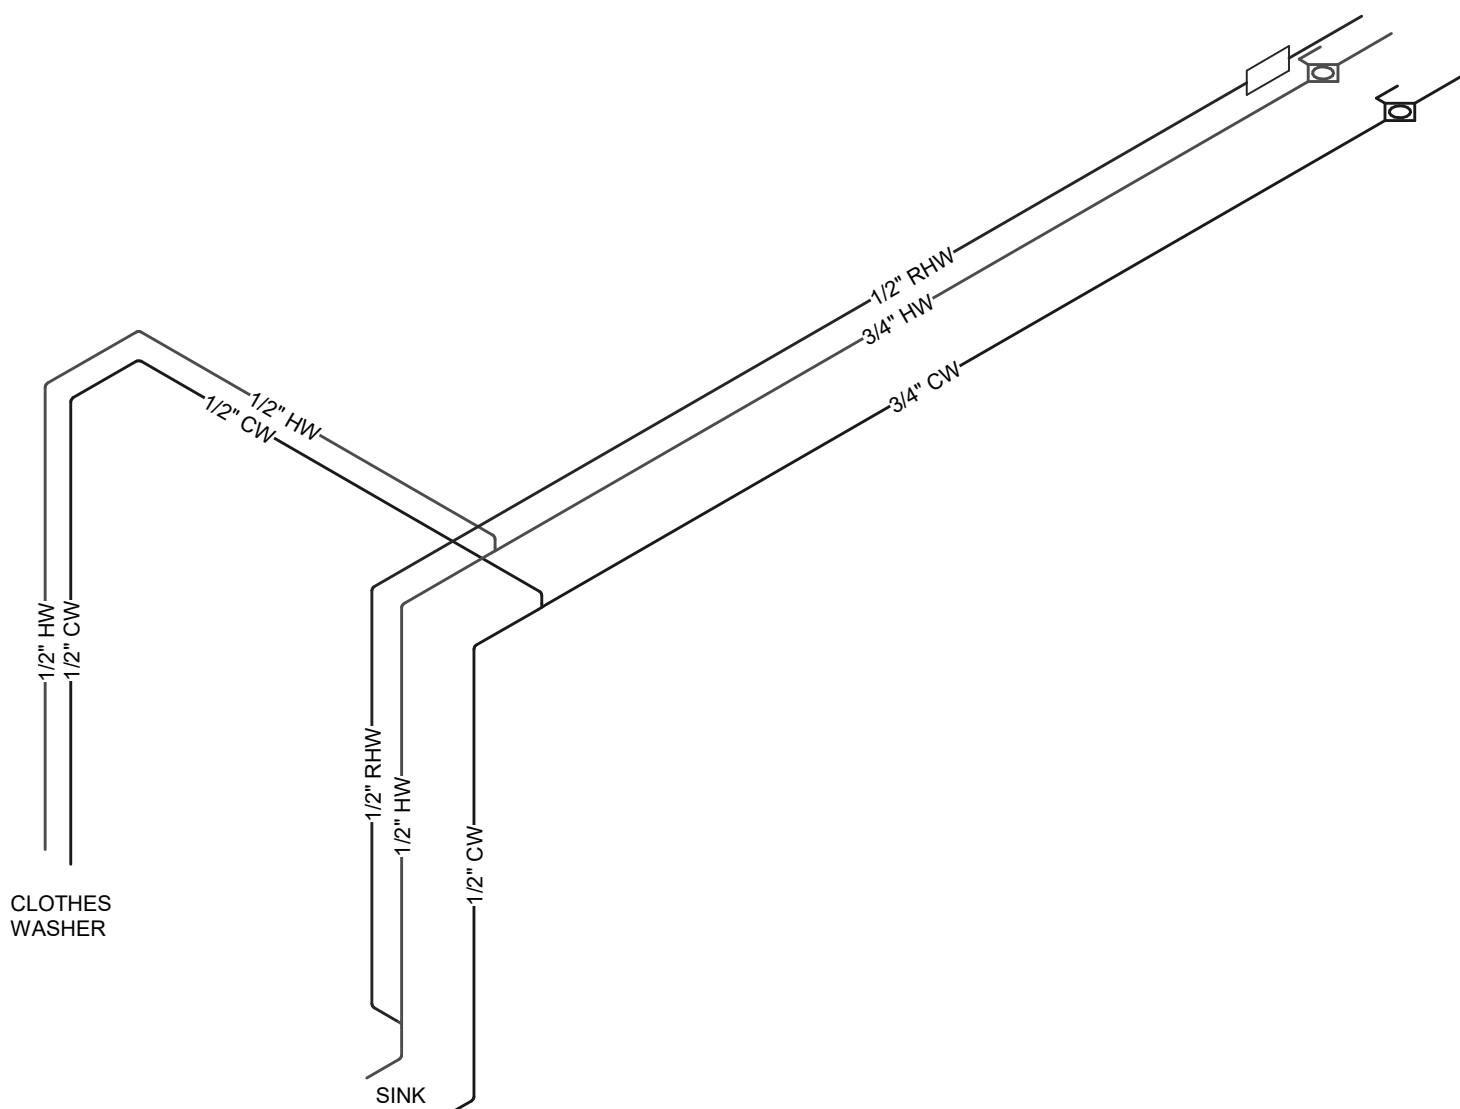


10 R-10
NOT TO SCALE

6 R-6
NOT TO SCALE

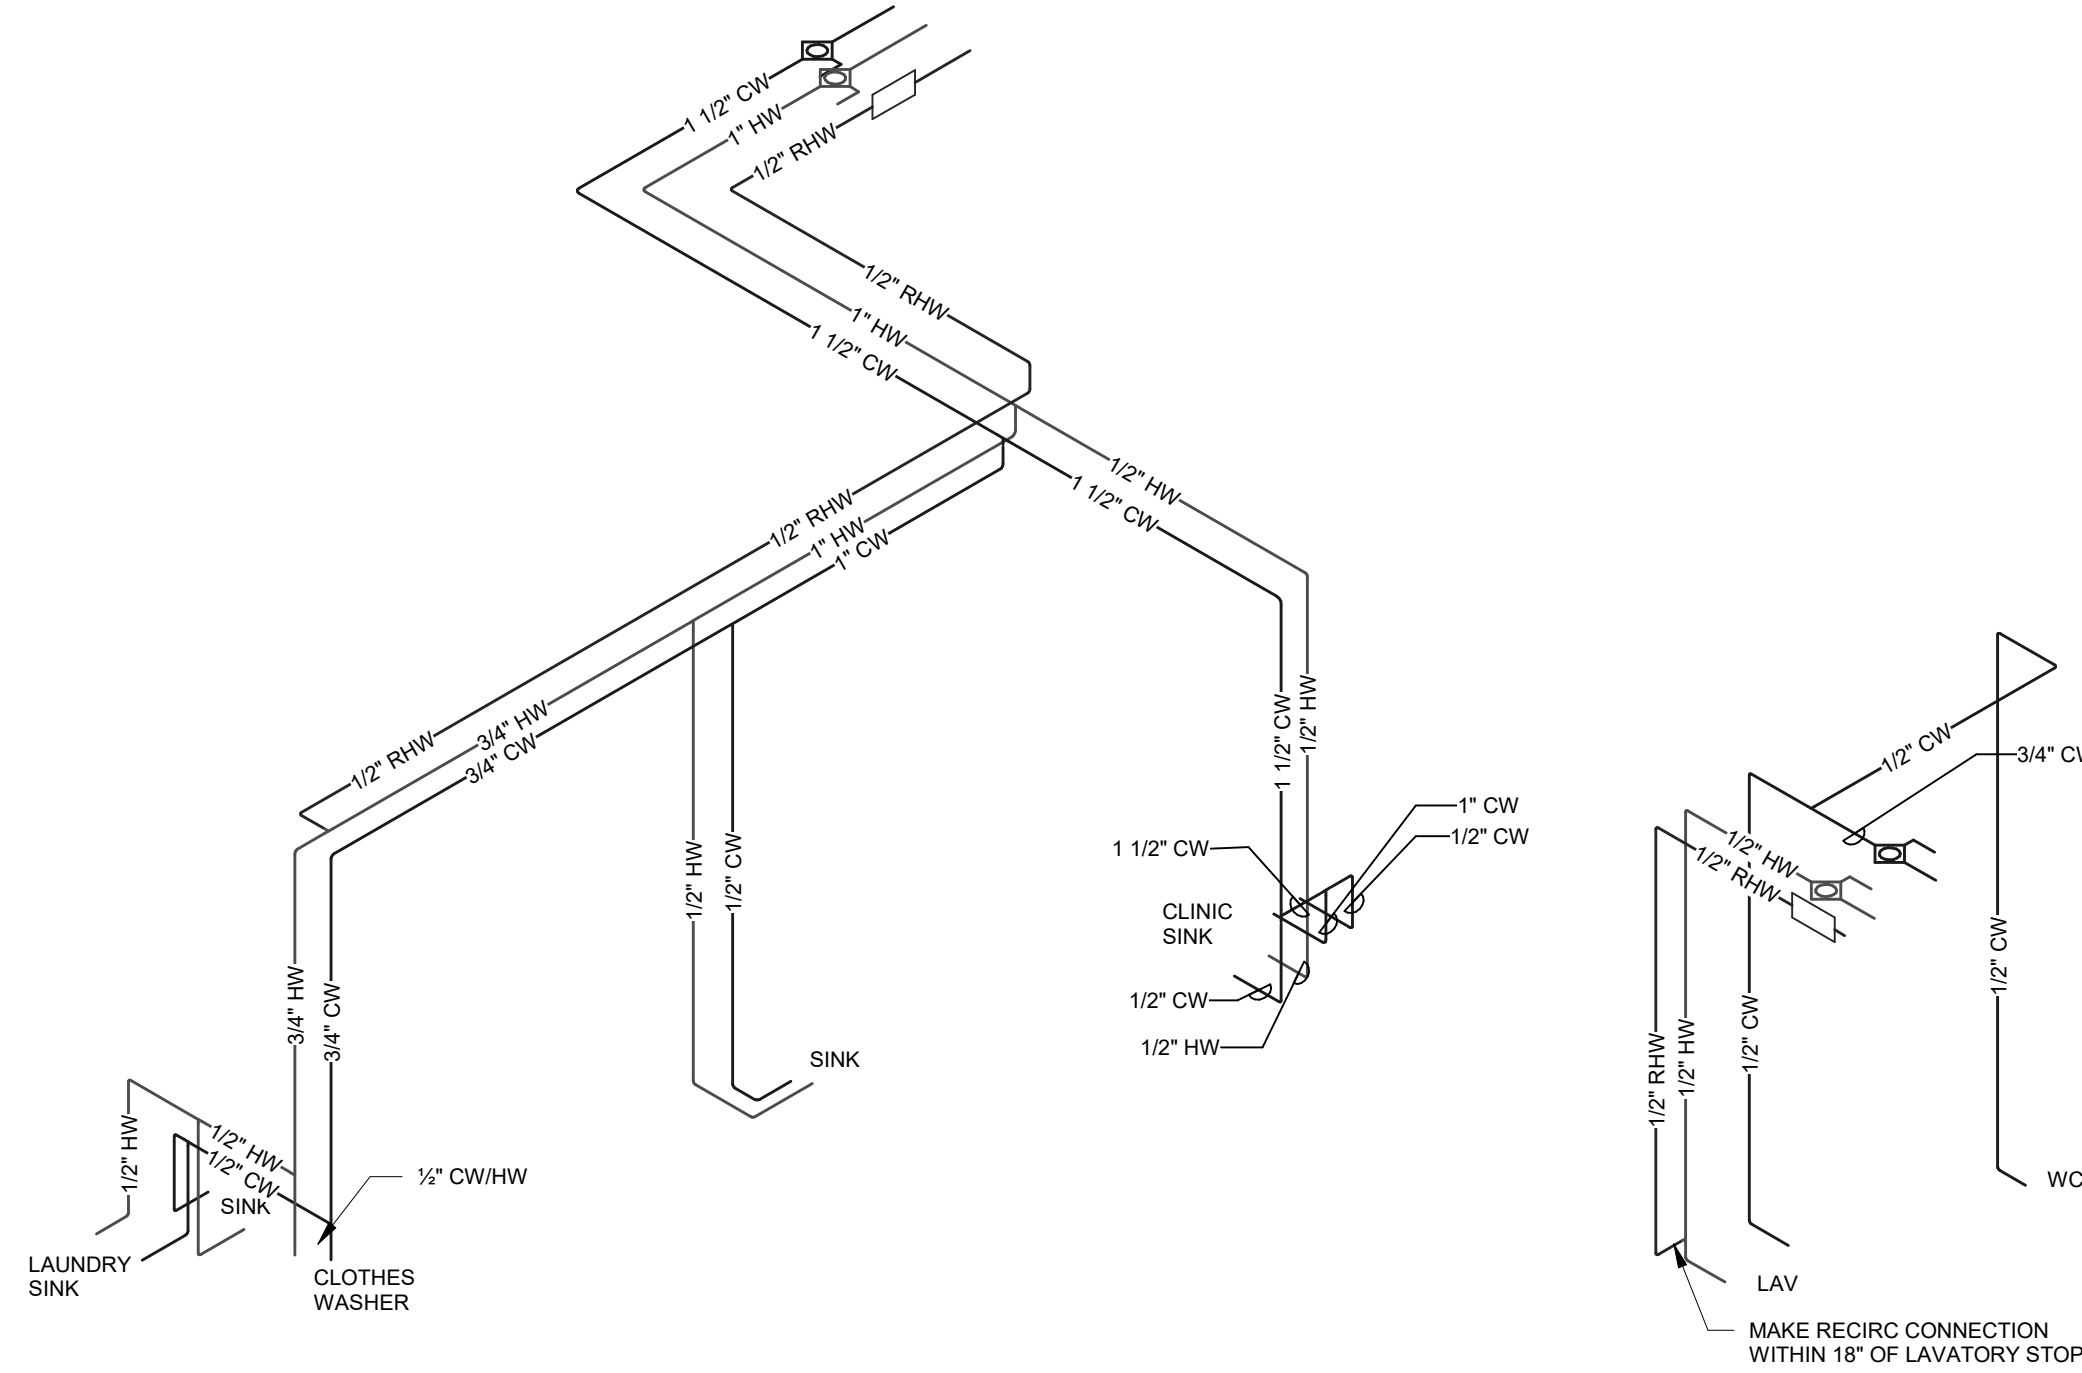

5 R-5
NOT TO SCALE

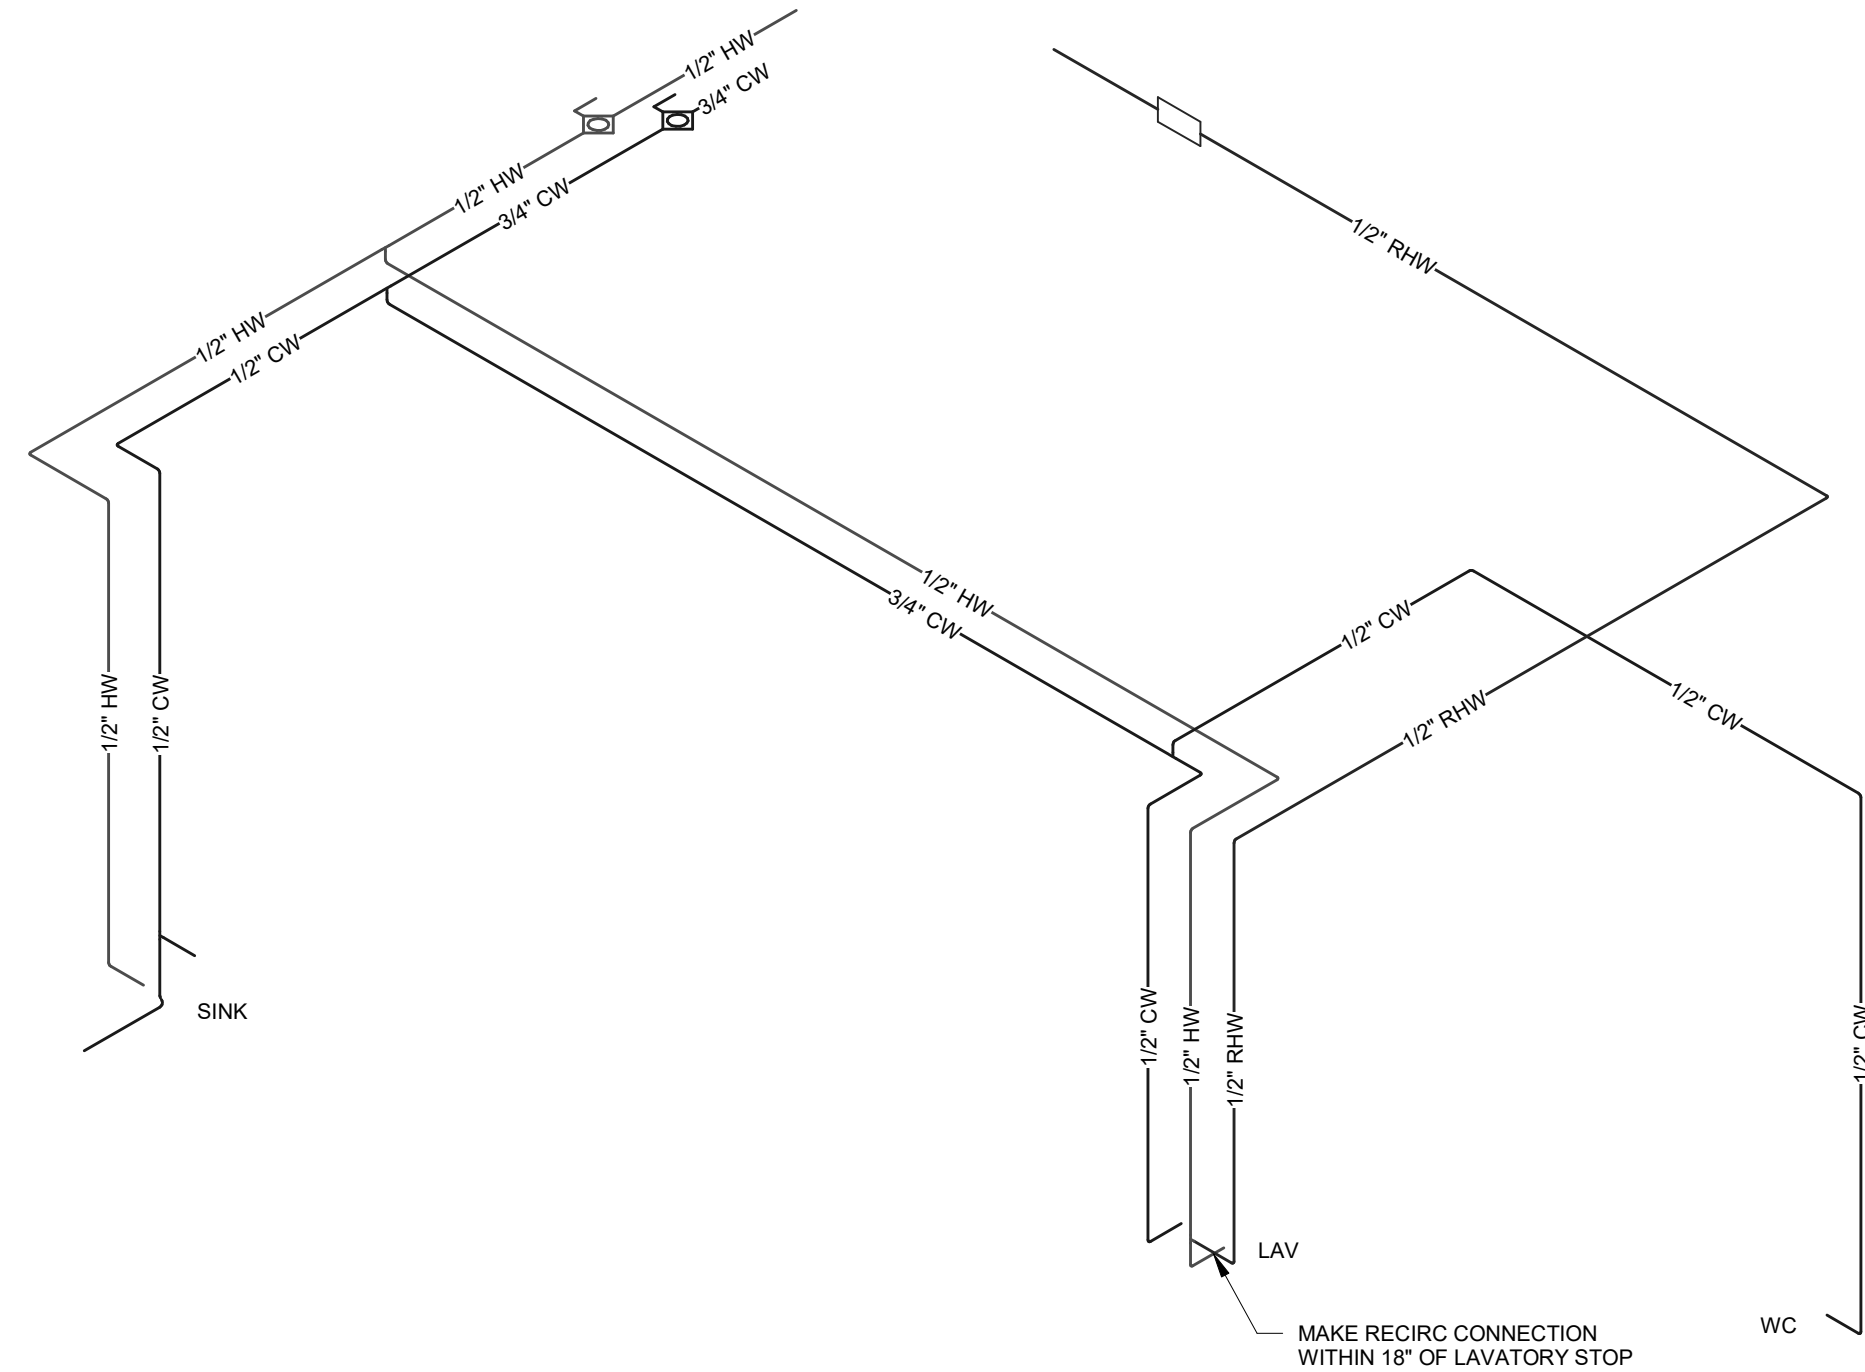

9 R-9
NOT TO SCALE

STEEN
ENGINEERING

763-585-6742
763-585-6757 fax
Email: steen@steeneng.com
5430 Douglas Drive North
Minneapolis, MN 55429



in = site
architects

1000 university ave. w. suite 130
st. paul, minnesota 55104
612-252-4820



Mark R. Breneman
Signature


Mark R. Breneman
Typed or Printed Name

Mechanical
Discipline

12/02/24
Date

WESLEY BRADLEY PARK PHASE 2 - CARE CENTER

707 39TH AVENUE SE
PUYALLUP, WA 98374

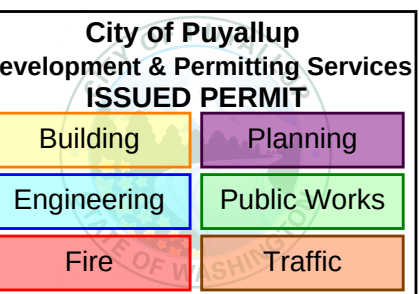

CARE CENTER
PERMIT SET
December 2, 2024

REVISIONS

No.	Description	Date
-----	-------------	------

ISA202201

PROJECT NUMBER

RDB

DRAWN BY

RDB


CHECKED BY

WESLEY BRADLEY PARK
PHASE 2 - CARE CENTER

PLUMBING RISERS

M4.1

WESLEY BRADLEY PARK
PHASE 2 - CARE CENTER
707 39TH AVENUE SE
PUYALLUP, WA 98374

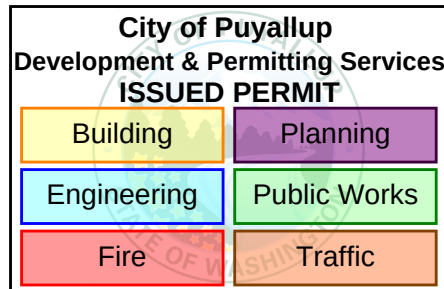

CARE CENTER
PERMIT SET
December 2, 2024

REVISIONS

No.	Description	Date
-----	-------------	------

ISA202201

PROJECT NUMBER

RDB

DRAWN BY

RDB

CHECKED BY

WESLEY BRADLEY PARK
PHASE 2 - CARE CENTER

PLUMBING RISERS

M4.2

1 POOL AREA DWV ISOMETRIC
NOT TO SCALE

2 POOL AREA DOMESTIC WATER
ISOMETRIC
NOT TO SCALE




Mark R. Breneman
Signature

Mark R. Breneman
Typed or Printed Name

Mechanical 12/02/24
Discipline Date

WESLEY BRADLEY PARK
PHASE 2 - CARE CENTER
707 39TH AVENUE SE
PUYALLUP, WA 98374

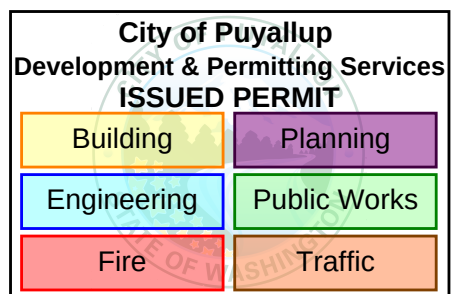

CARE CENTER
PERMIT SET
December 2, 2024

REVISIONS

No.	Description	Date
1	PERMIT RESUBMIT	4/14/25


ISA202201
PROJECT NUMBER

RDB RDB
DRAWN BY CHECKED BY


WESLEY BRADLEY PARK
PHASE 2 - CARE CENTER

PLUMBING RISERS


M4.3

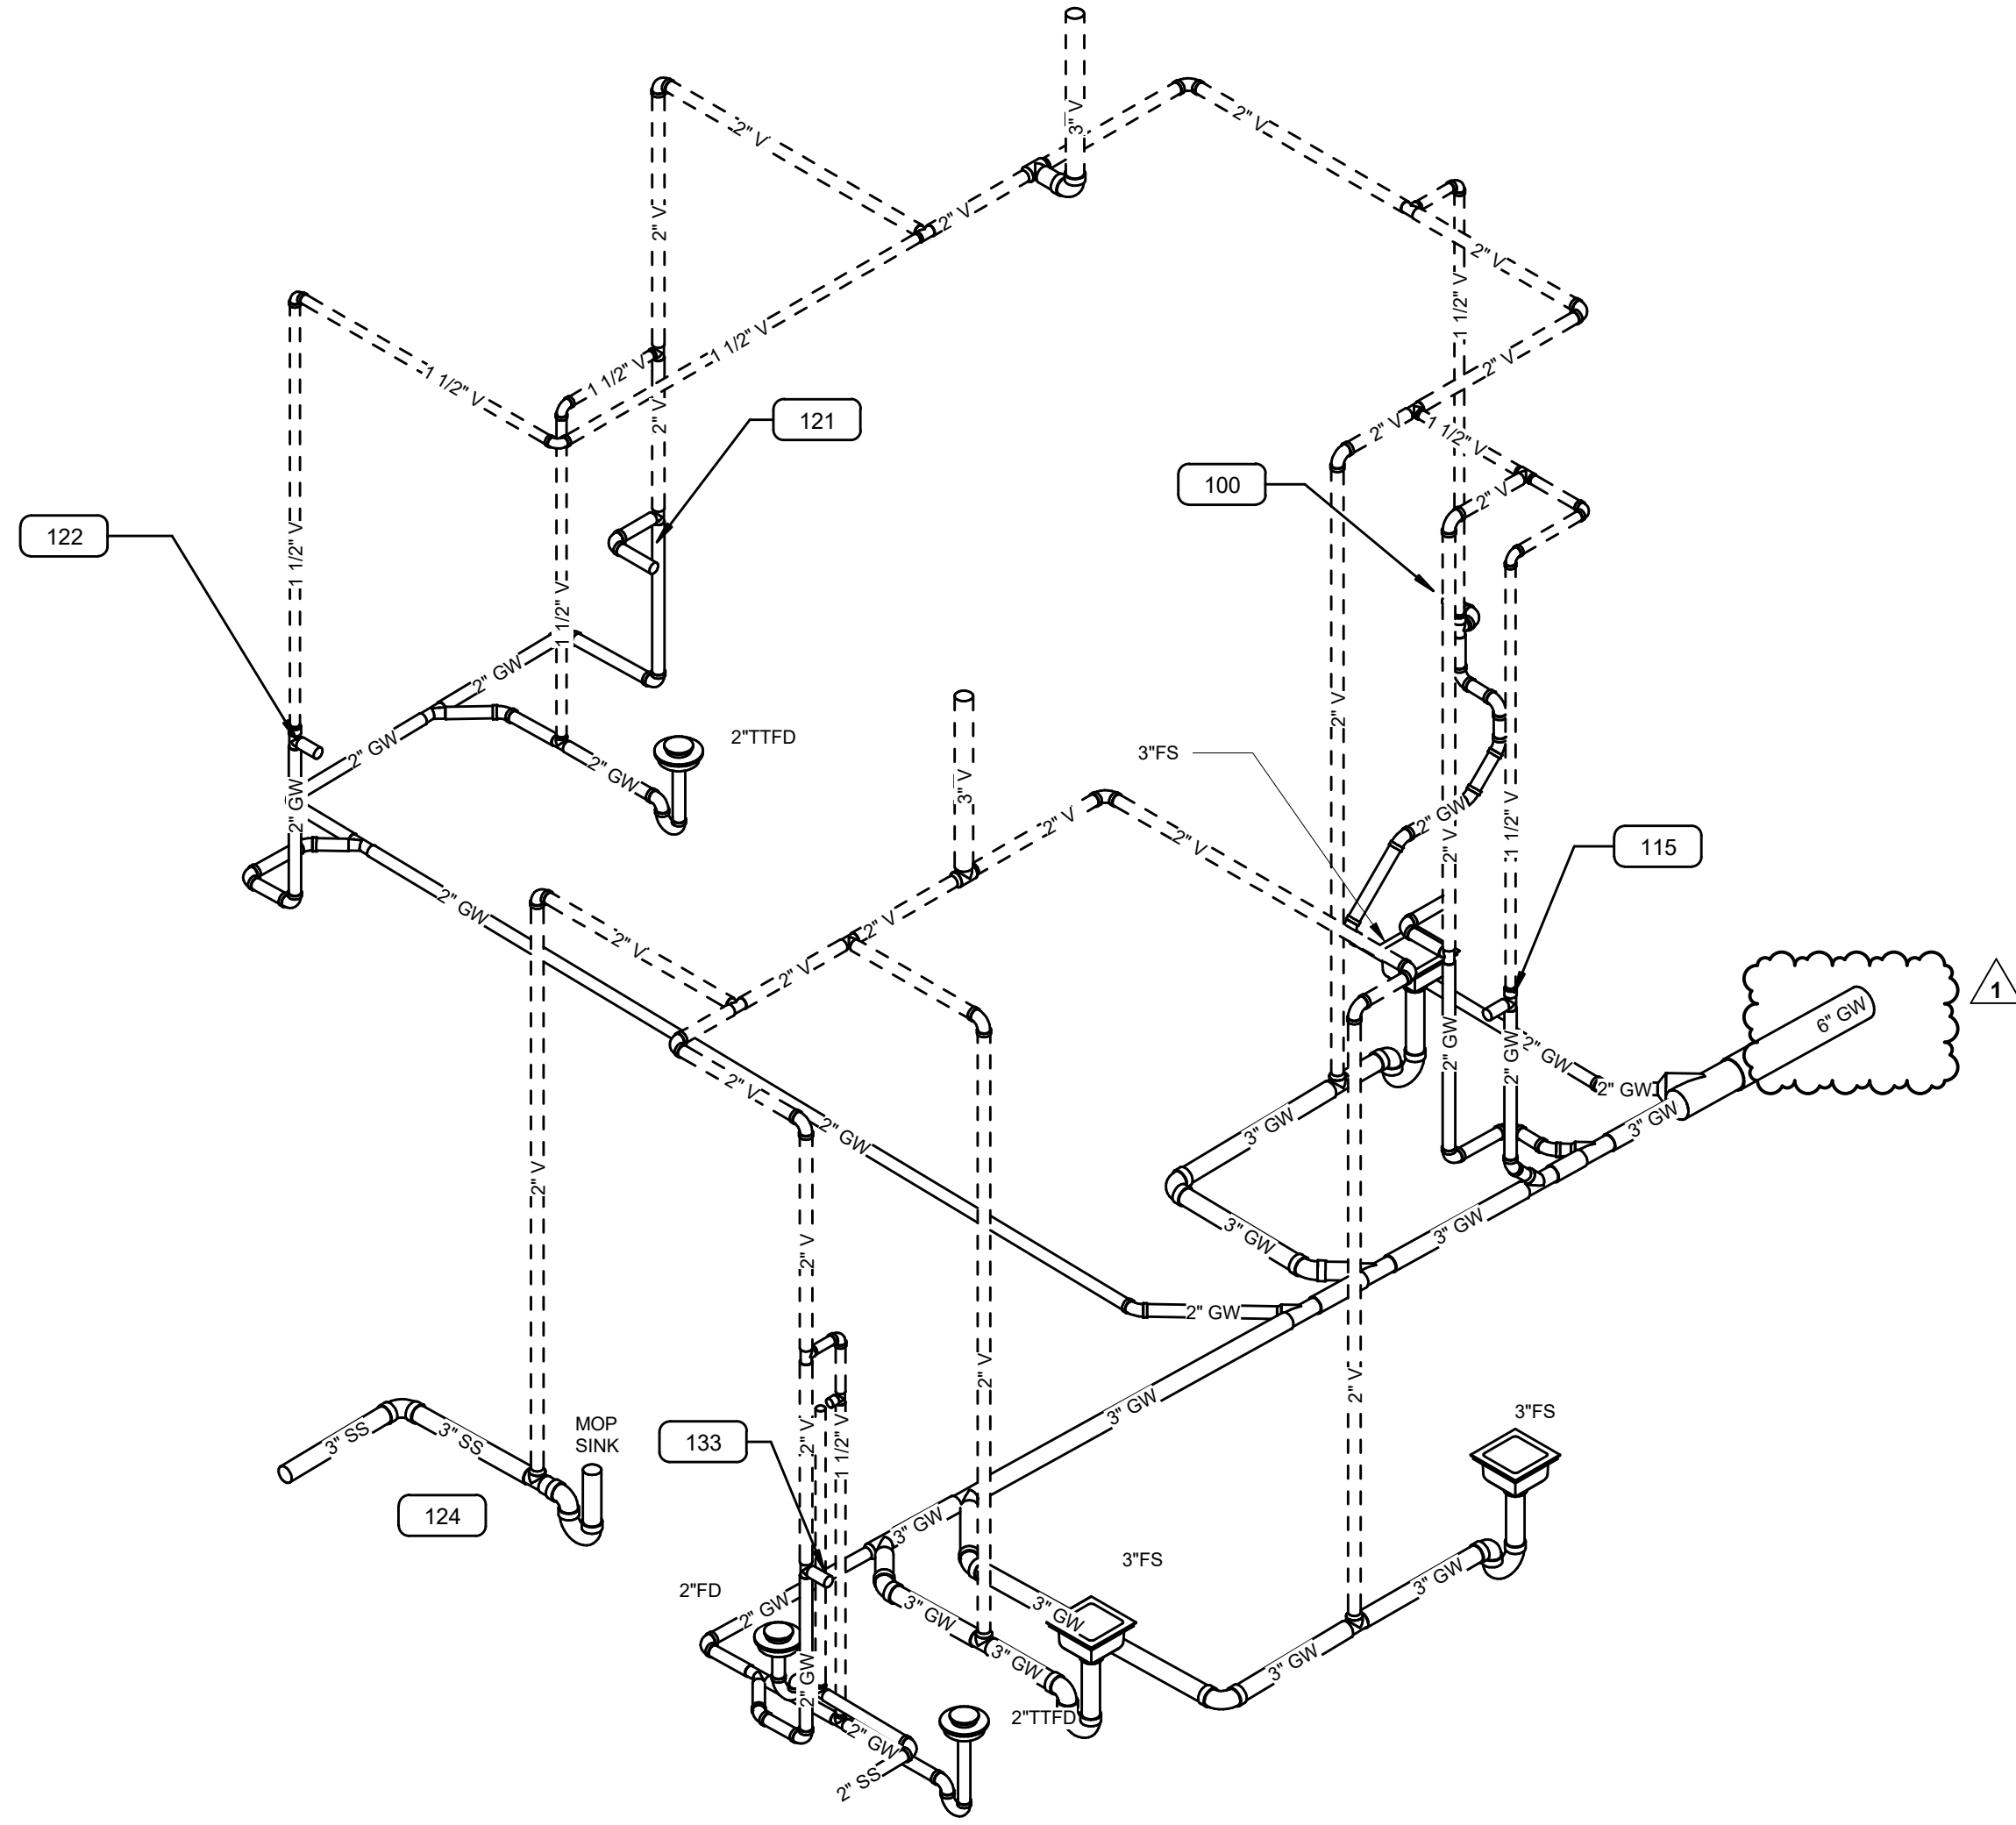


1 KITCHEN DWV ISOMETRIC
NOT TO SCALE

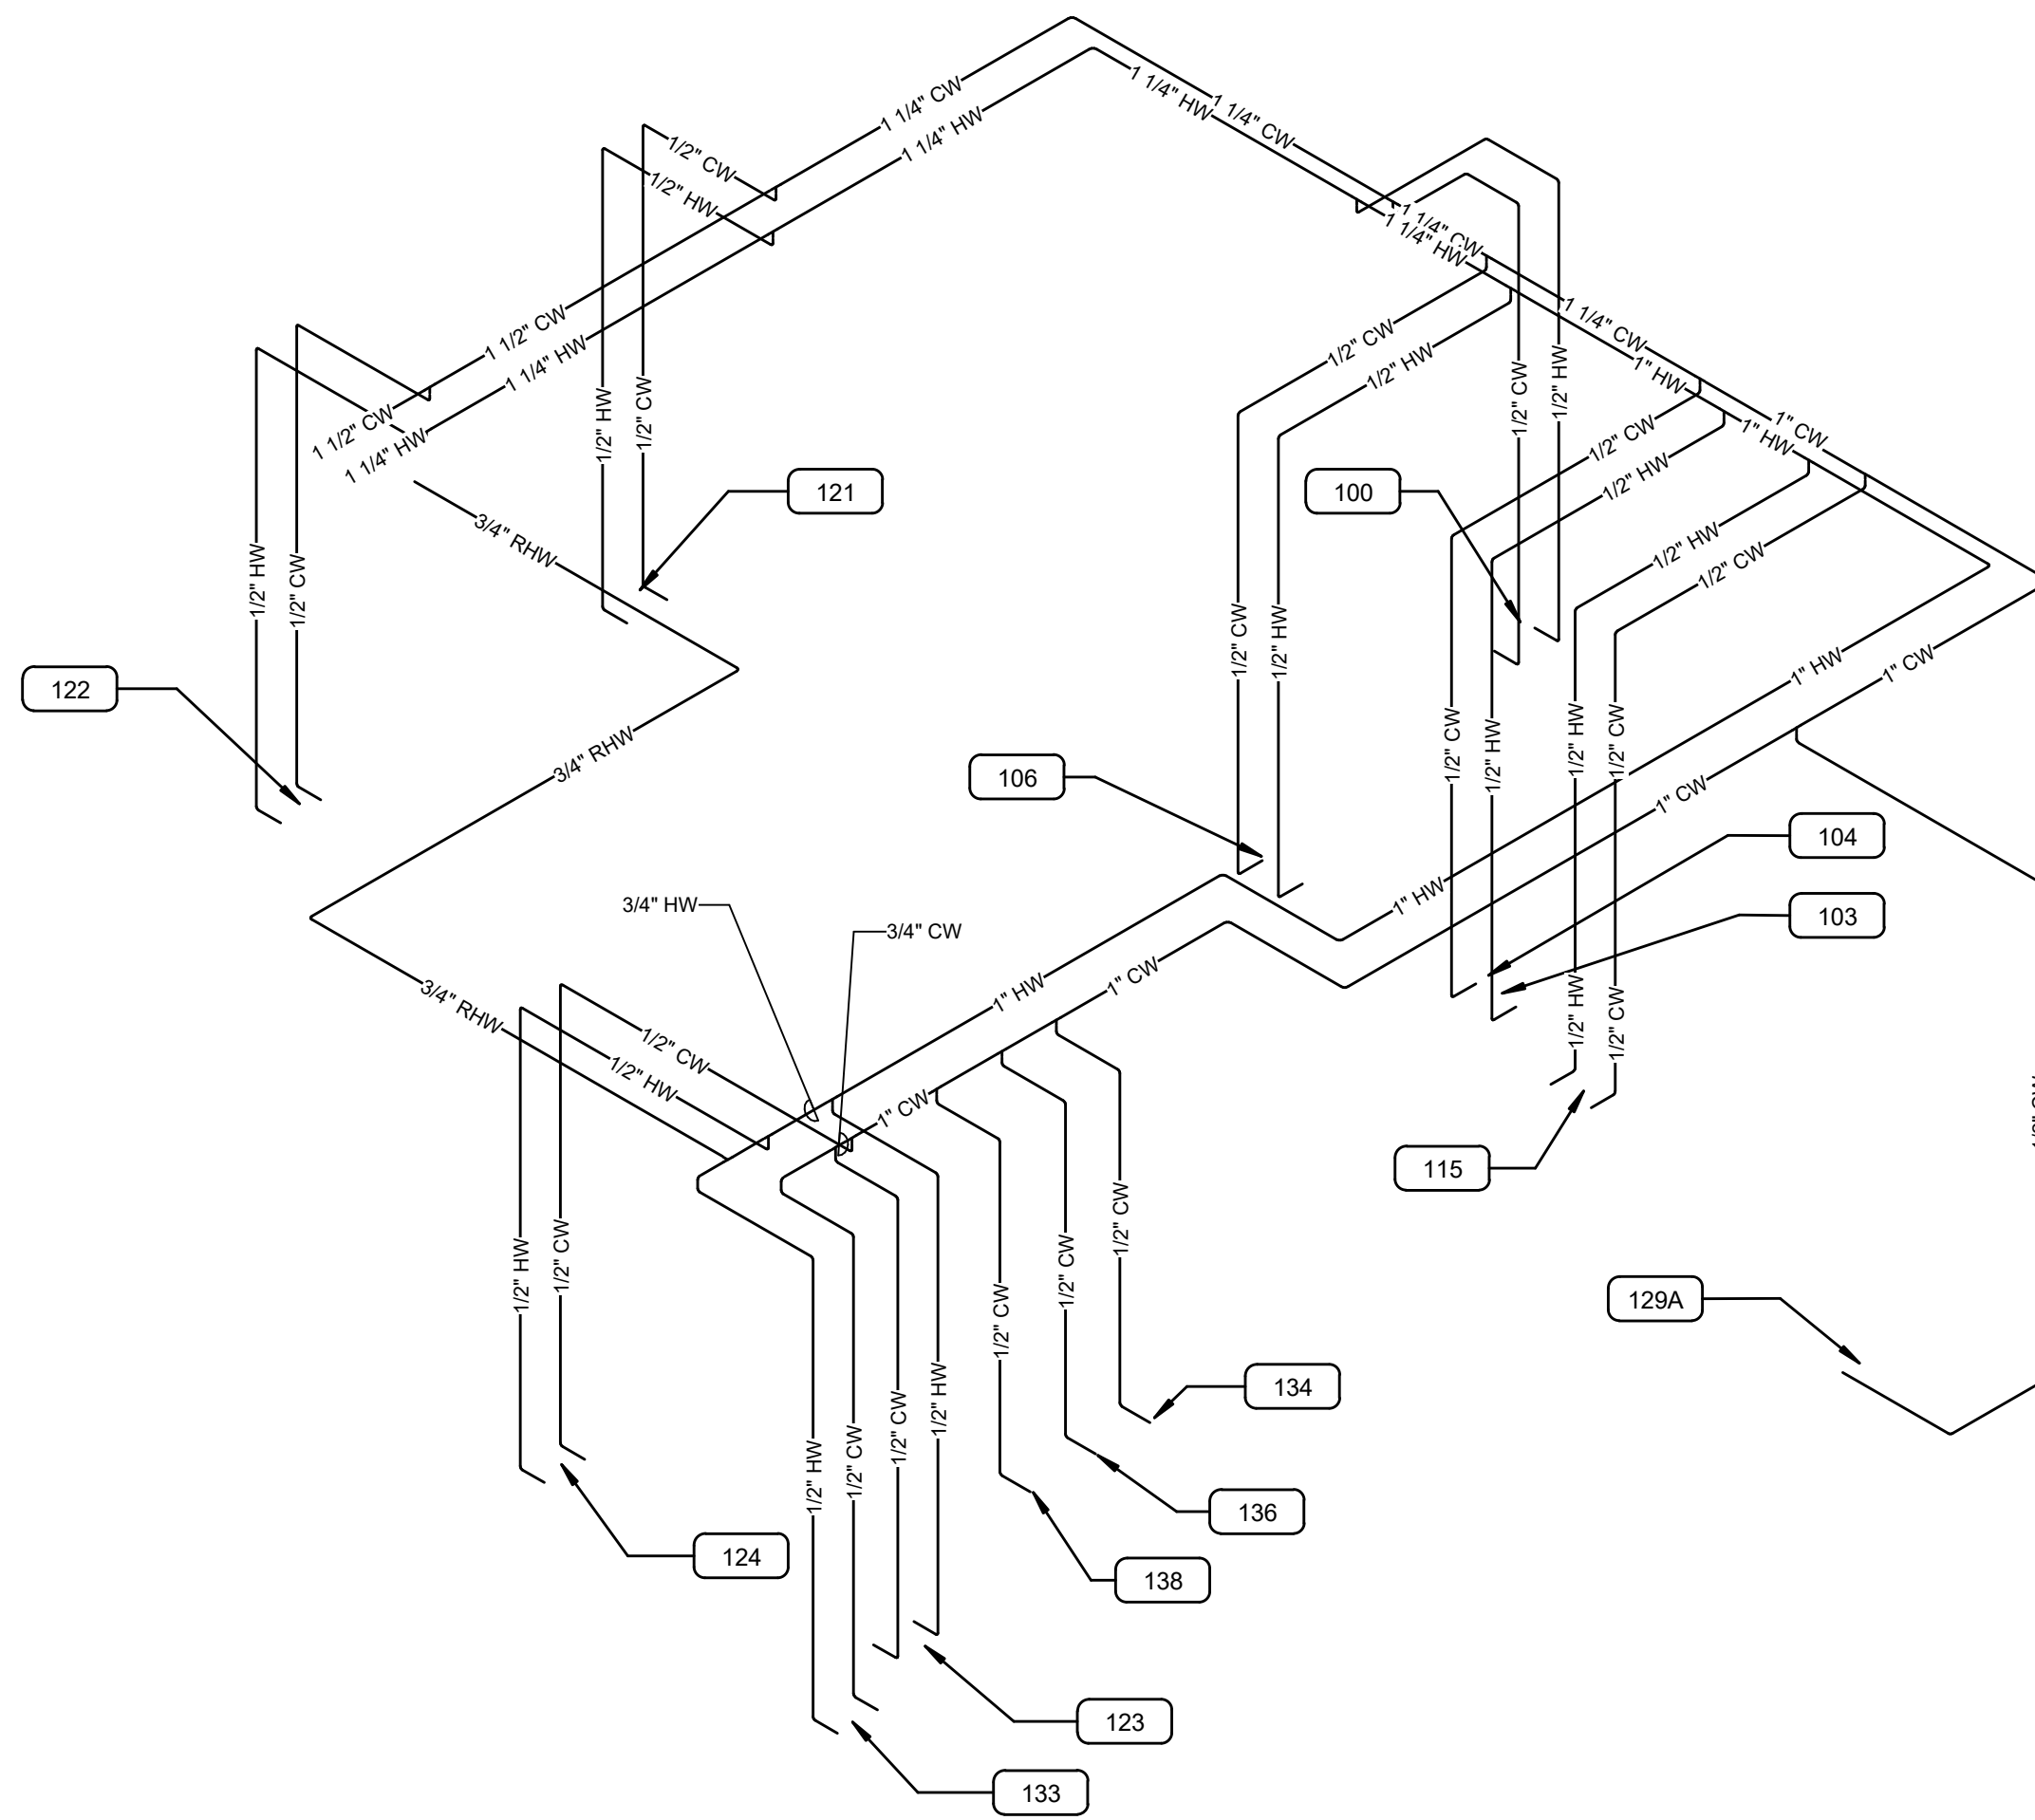


2 KITCHEN DOMESTIC WATER ISOMETRIC
NOT TO SCALE

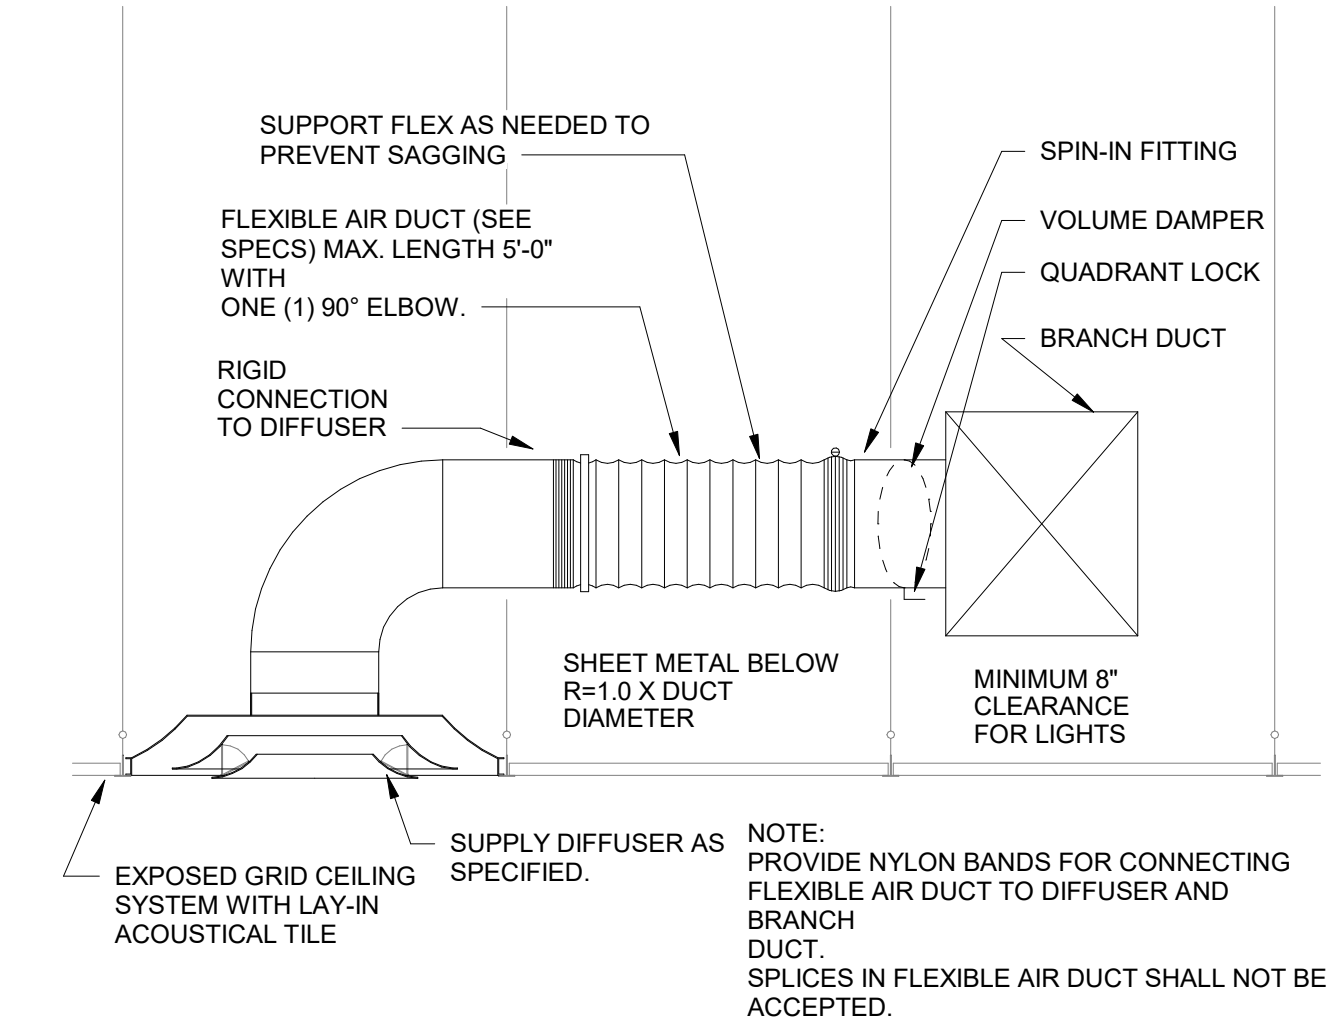


4 LAY-IN DIFFUSER DETAIL
NOT TO SCALE

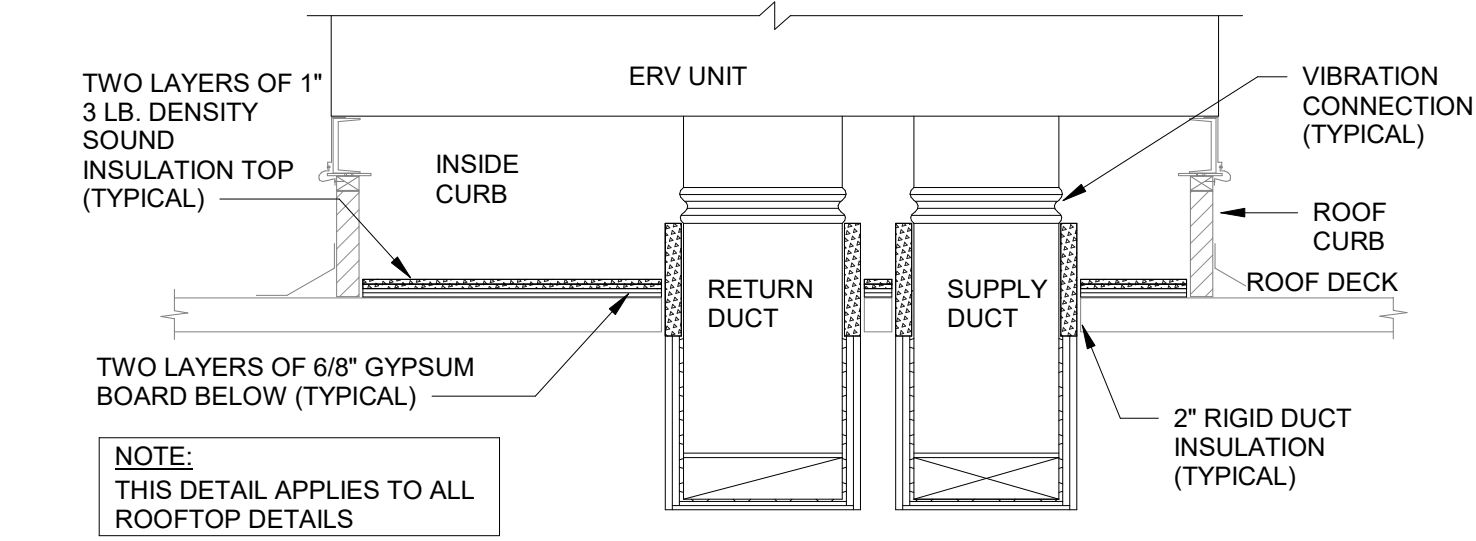


3 ERV CURB DETAIL
NOT TO SCALE

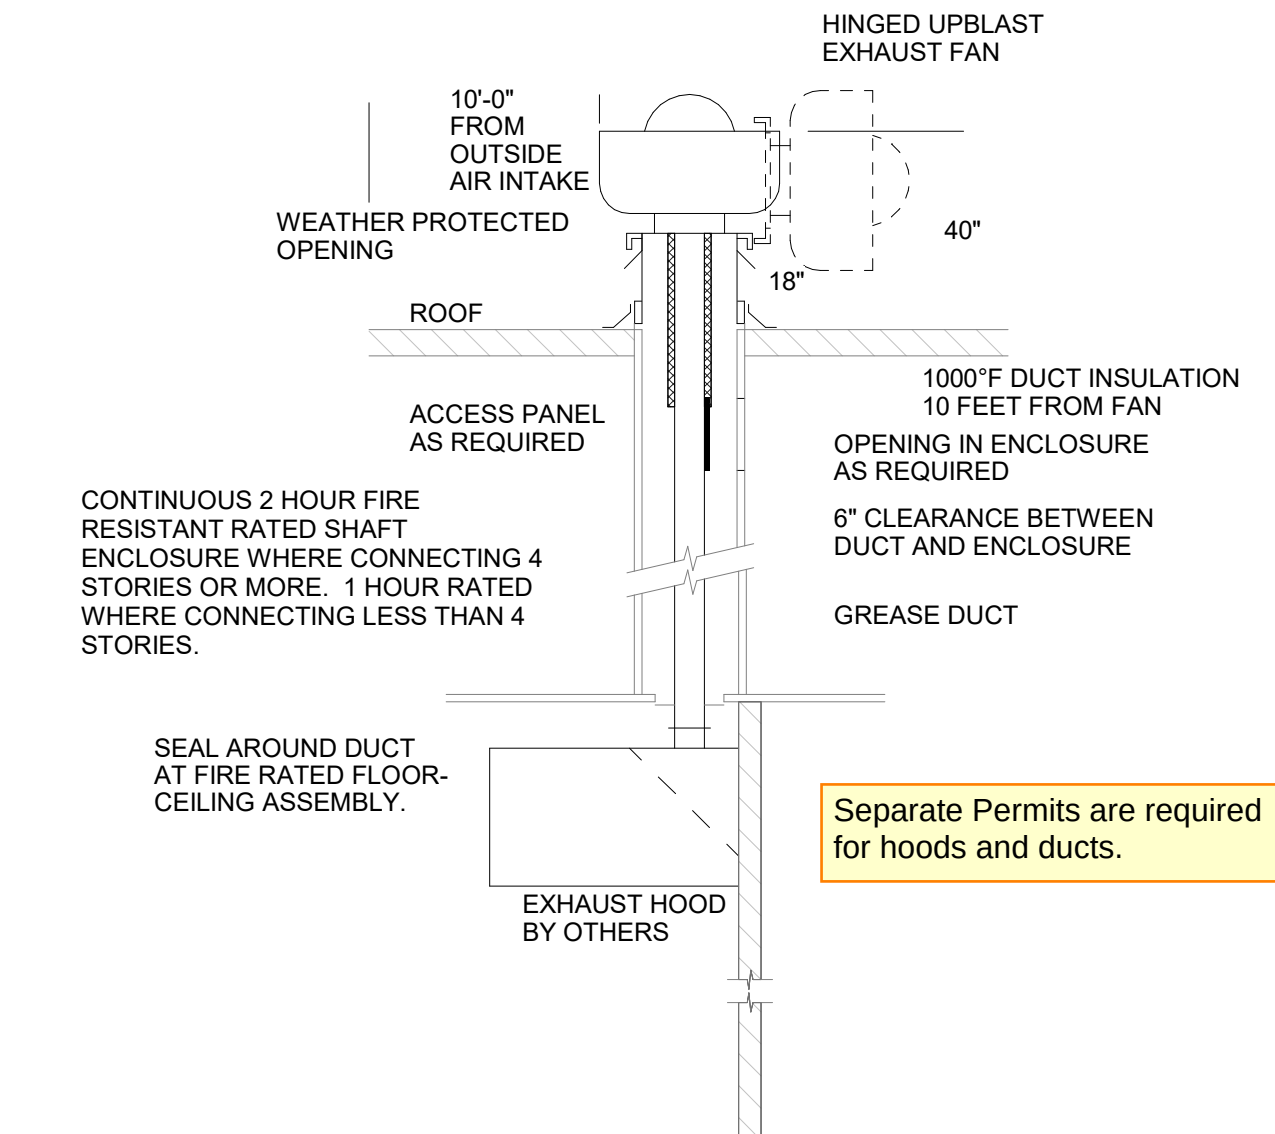


2 GREASE EXHAUST HOOD DETAIL
NOT TO SCALE

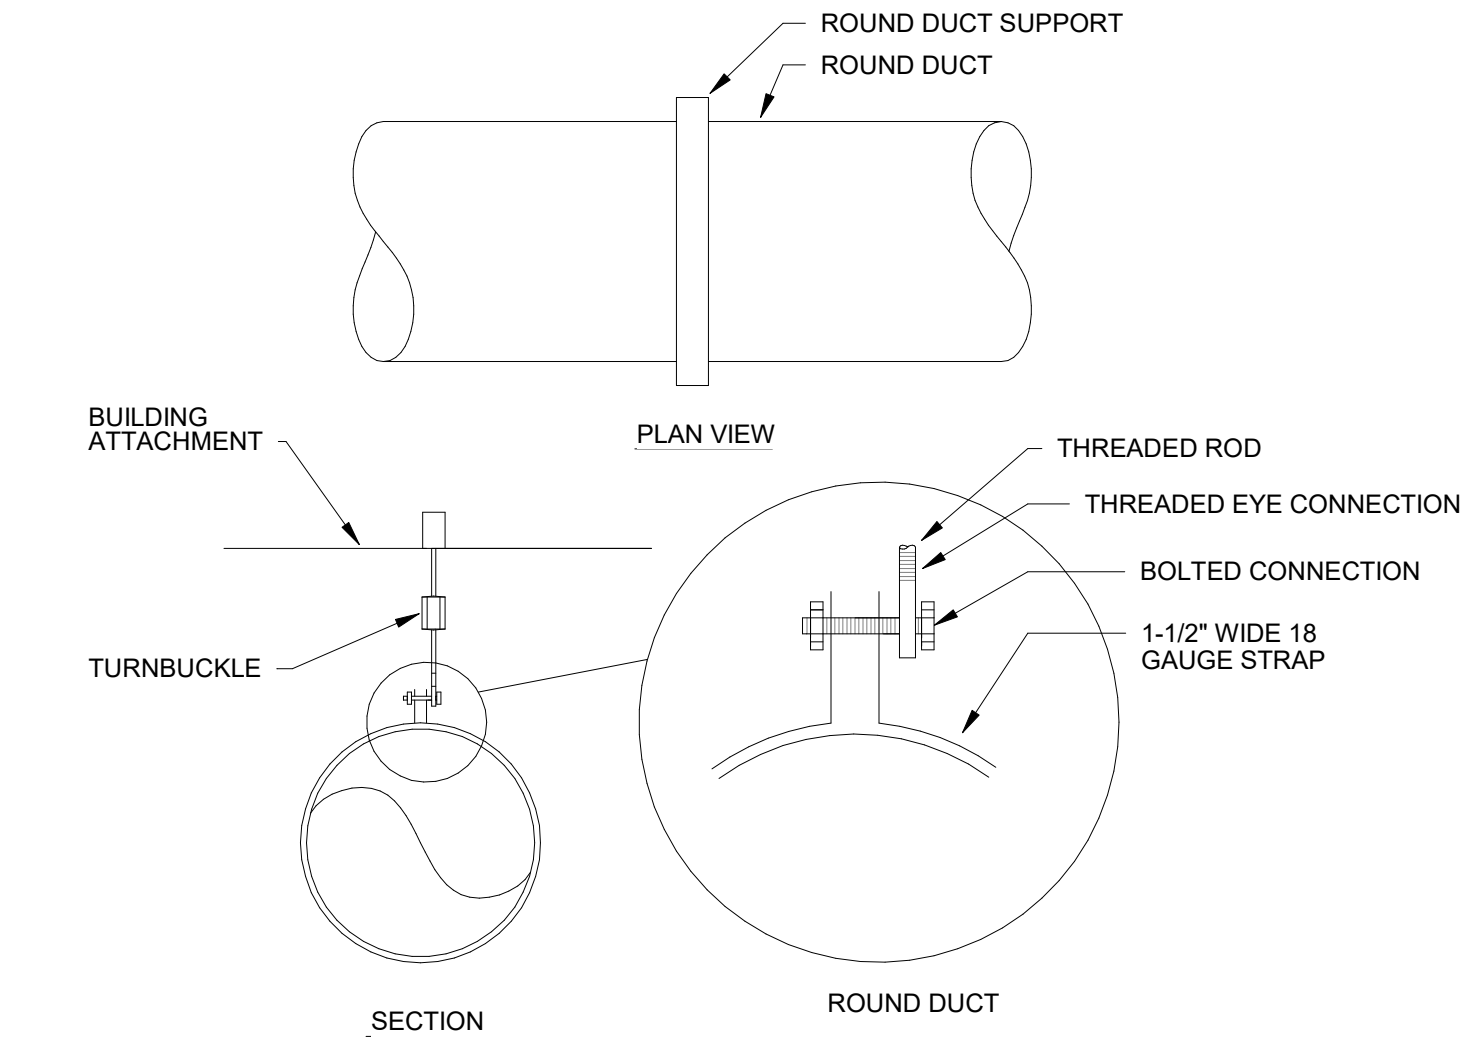


1 ROUND DUCT SUPPORT DETAIL
NOT TO SCALE

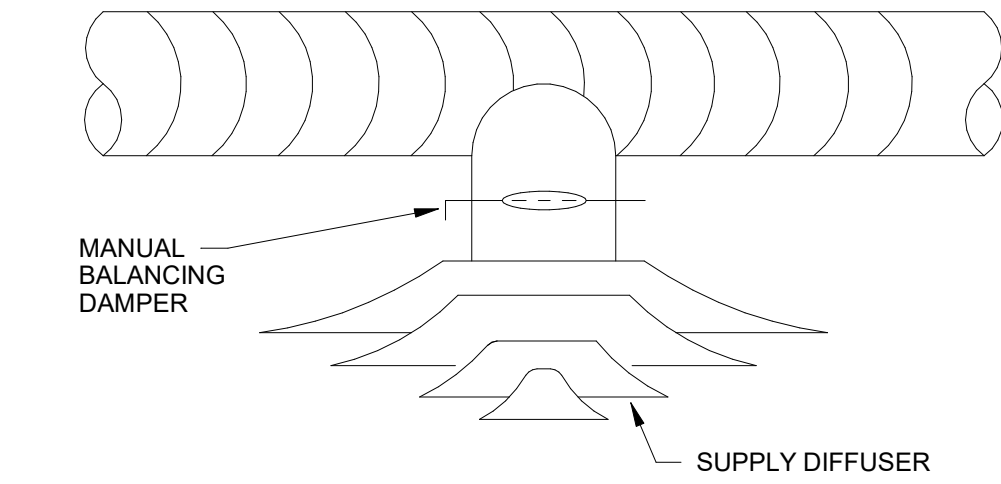


8 CONE DIFFUSER DETAIL
NOT TO SCALE

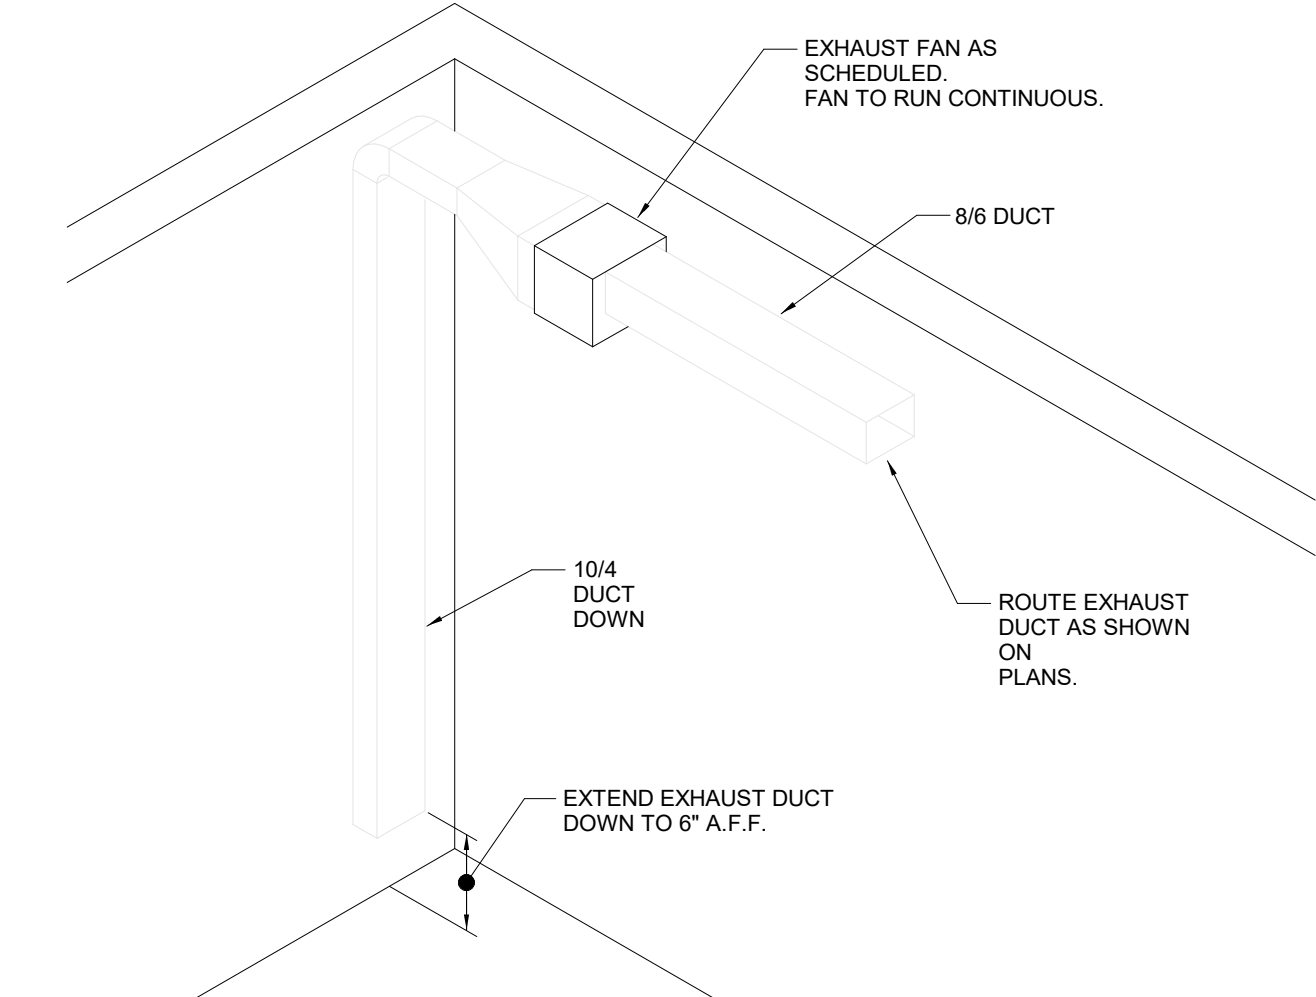


7 CHEMICAL STORAGE ROOM EXHAUST
FAN DETAIL
NOT TO SCALE

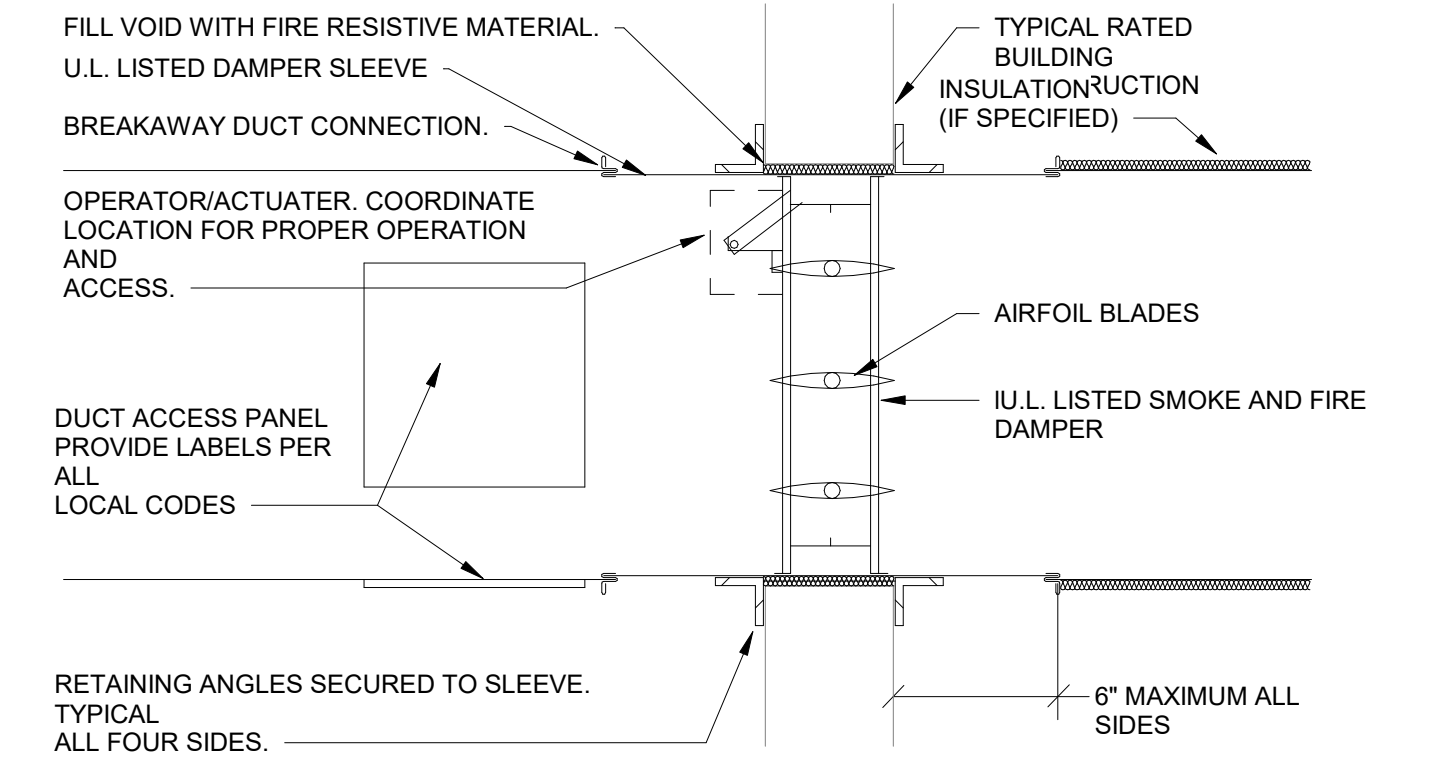


6 INLINE SMOKE/FIRE DAMPER DETAIL
NOT TO SCALE

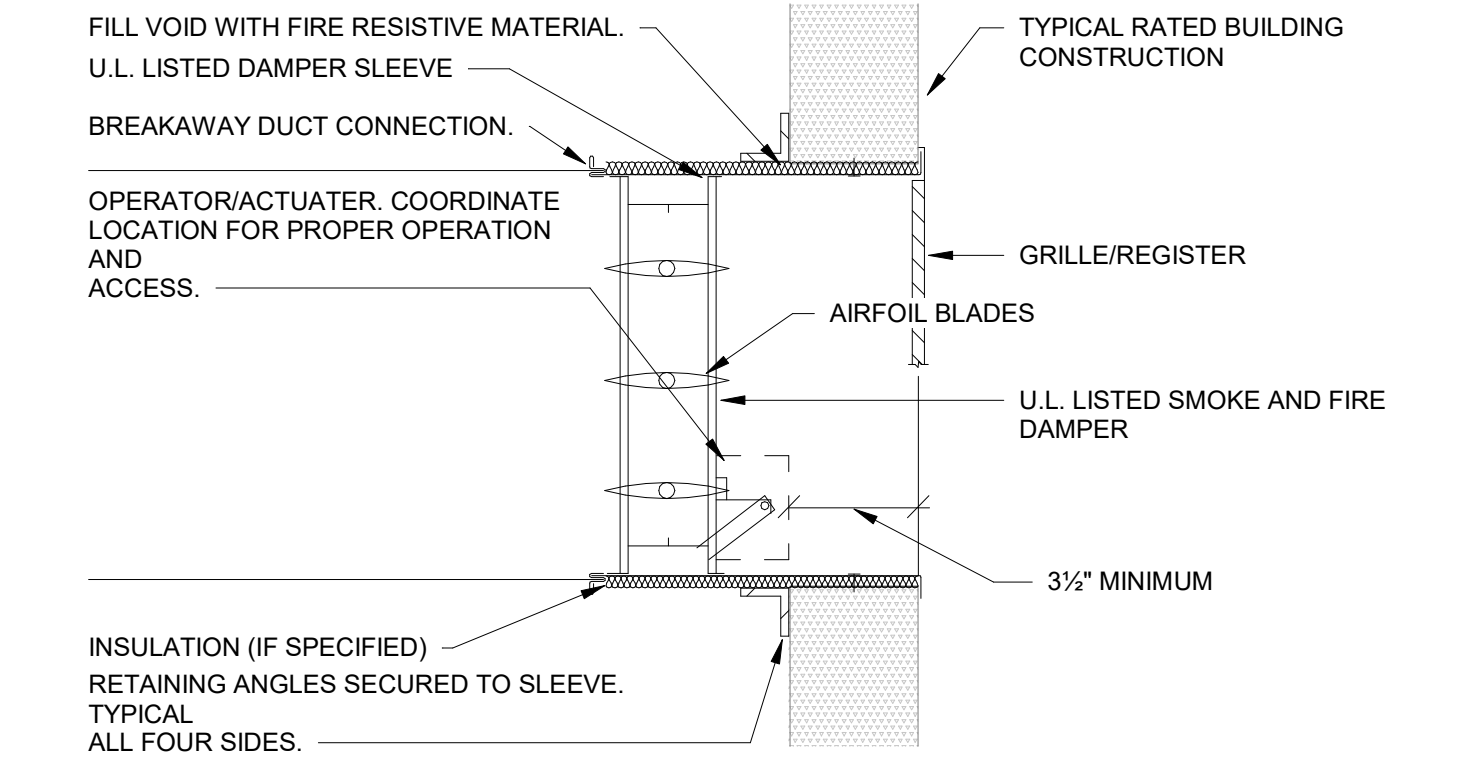

5 GRILLE SMOKE/FIRE DAMPER DETAIL
NOT TO SCALE

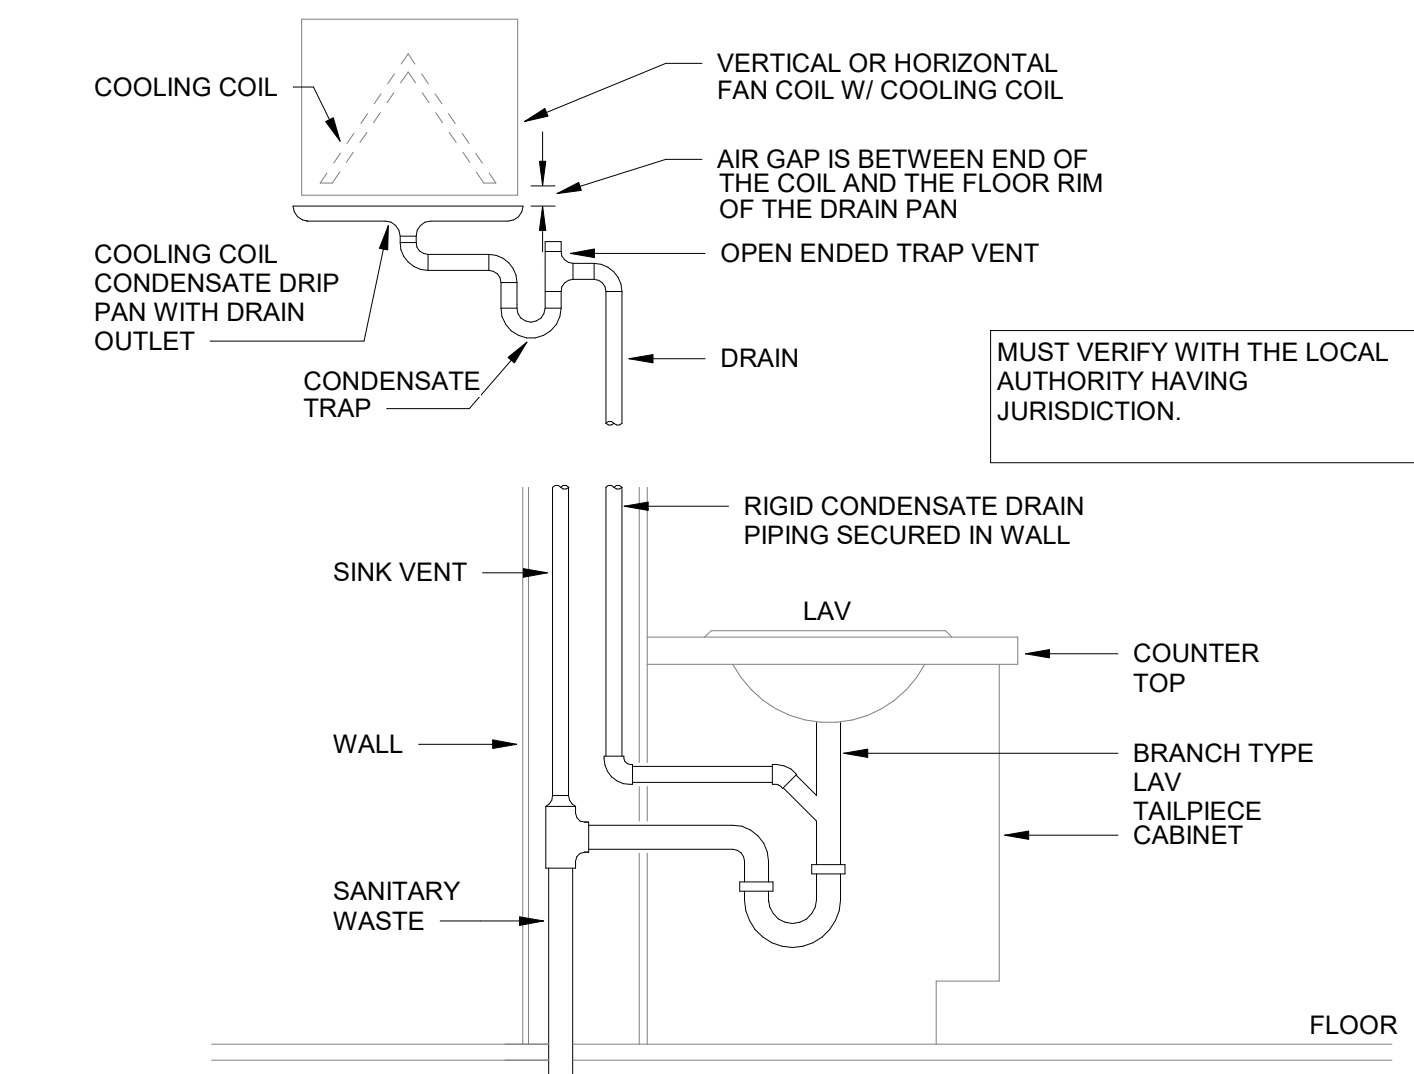

10 CONDENSATE WASTE DETAIL
NOT TO SCALE

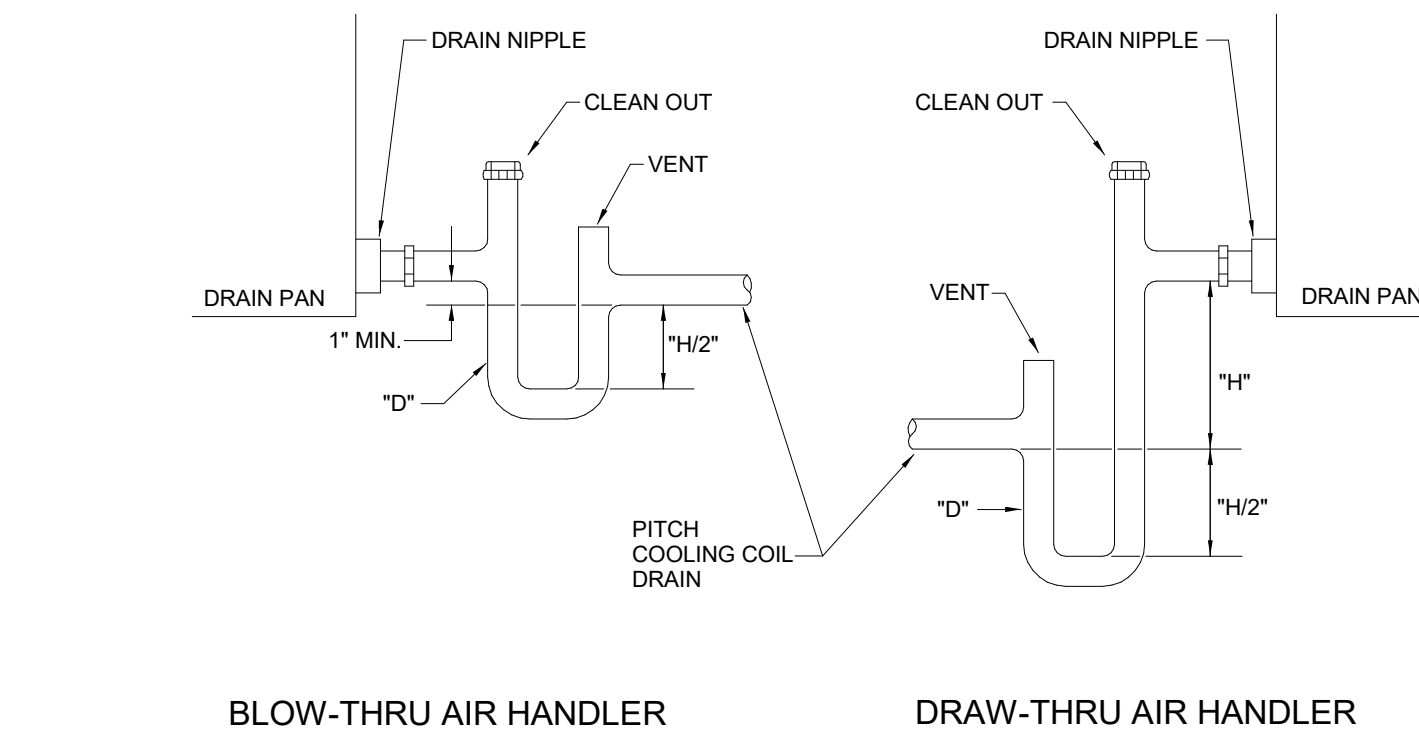


9 AHU DRAIN TRAP DETAIL
NOT TO SCALE

UNIT TOTAL PRESSURE (in. W.G.)	H	H2	D2
2	3"	1 1/2"	3/4"
3	4"	2"	3/4"
4	5"	2 1/2"	1 1/4"
6	7"	3 1/2"	1 1/2"


STEEN
ENGINEERING
763-585-6742
763-585-6757 fax
Email: steen@steeneng.com
5430 Douglas Drive North
Minneapolis, MN 55429

in = site
architects
1000 university ave. w. # suite 130
st. paul, minnesota 55104
612-252-4820

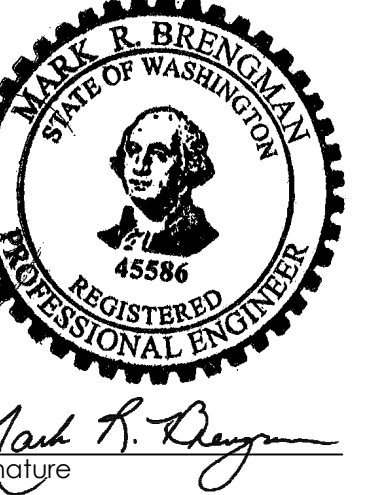

Mark R. Breneman
Typed or Printed Name
Discipline 12/02/24
Date

**WESLEY BRADLEY PARK
PHASE 2 - CARE CENTER**
707 39TH AVENUE SE
PUYALLUP, WA 98374

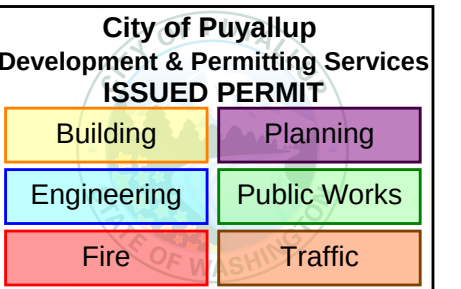

**CARE CENTER
PERMIT SET**
December 2, 2024

REVISIONS
No. Description Date

ISA202201
PROJECT NUMBER
DCA MRB
DRAWN BY CHECKED BY
WESLEY BRADLEY PARK
PHASE 2 - CARE CENTER

MECHANICAL DETAILS
M5.0




Mark R. Breneman
Signature

Mark R. Breneman
Typed or Printed Name

Mechanical
Discipline

12/02/24
Date

WESLEY BRADLEY PARK
PHASE 2 - CARE CENTER
707 39TH AVENUE SE
PUYALLUP, WA 98374

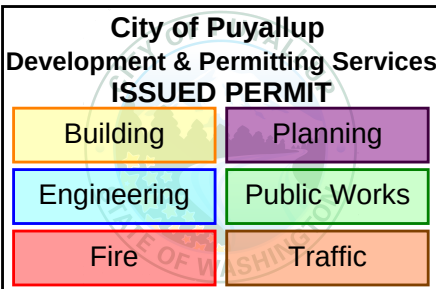

CARE CENTER
PERMIT SET
December 2, 2024

REVISIONS

No.	Description	Date
-----	-------------	------

ISA202201
PROJECT NUMBER

DCA MRB
DRAWN BY CHECKED BY

WESLEY BRADLEY PARK
PHASE 2 - CARE CENTER

MECHANICAL DETAILS

M5.1


This drawing is schematic in nature. Final routing of piping & wiring shall be determined by the installing contractor and/or designer of record. Additional refrigerant charge is needed depending on the size and length of extended piping. Please refer the amount of pre-charge and the formula of calculation which is mentioned on the data book.
1.25mm(1/8 AWG) ; 1.25mm(1/8 AWG) or more. 0.75mm(20 AWG) ; between 0.5mm(24 AWG) and 0.75mm(20 AWG).

Bradley Park	
DIAGRAM SYMBOL LEGEND	CONTAG PAGE
DISPLAY DESCRIPTION	
--- POWER WIRE	
--- CONTROL WIRE	
----- REF. PIPE	

CITY MULTI
SYSTEM SCHEMATIC DWG.

Garage
TURYE2163AN41AN [Garage]

PIPING AND CONTROLS
SYMBOL BRANCH PIPE MODEL NAME
J1 CMV-R302S-G1
J2 CMV-R303S-G1
J3 CMV-R303S-G
SYMBOL LIQUID PIPE PIPE SIZE
P1 3/8 1/8
P2 1/4 1/2
P3 3/8 1/4 1/8
P4 7/8 1/3/8
P5 1/2 1/4 1/8
SYMBOL WIRE NUMBER
NA TAR-4NANU

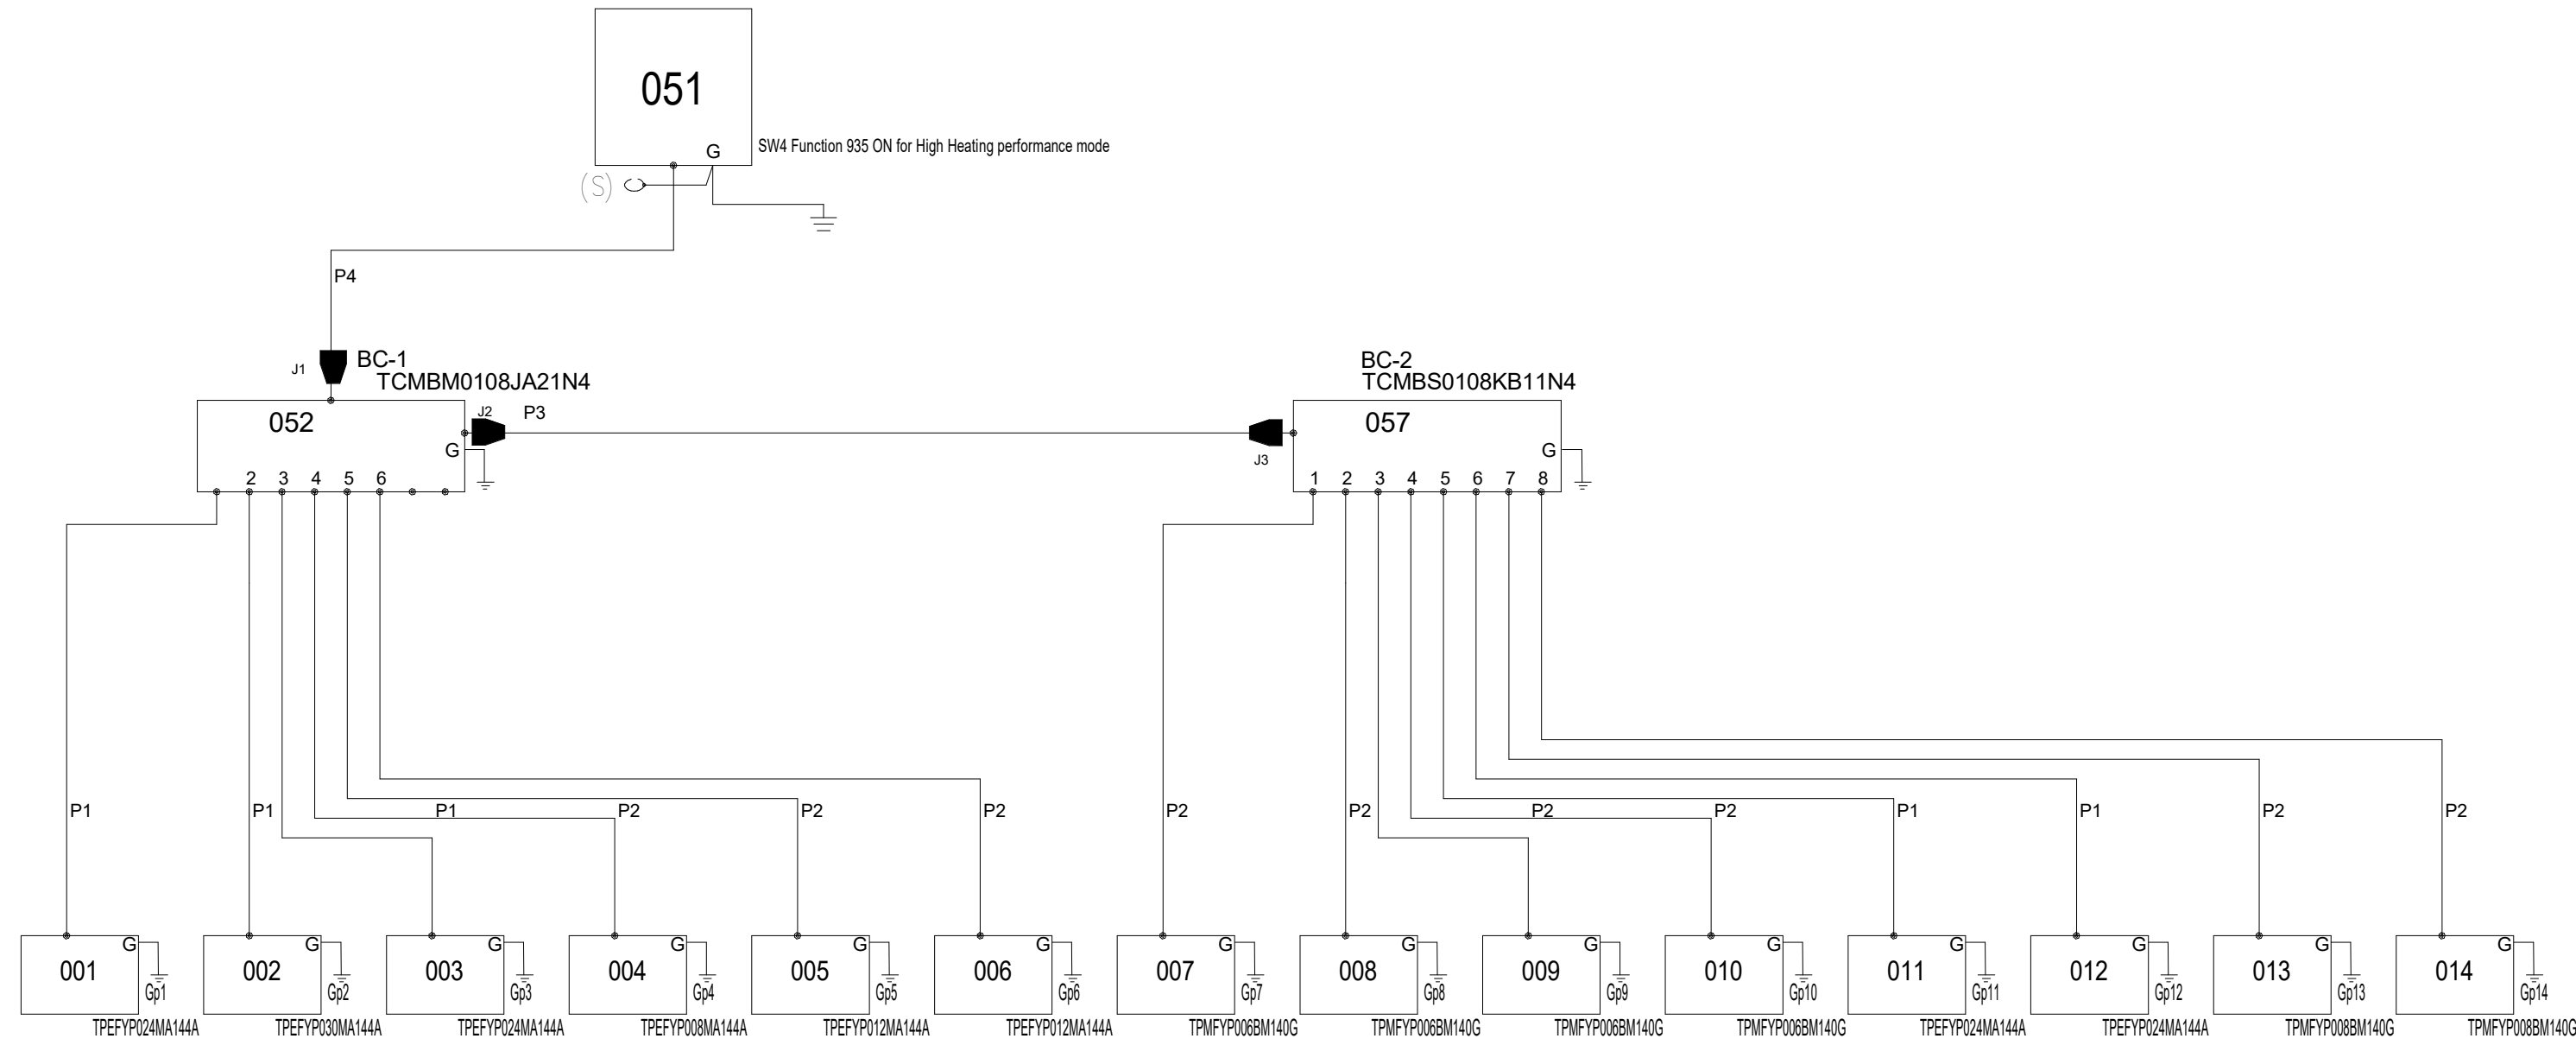


Diamond System Builder
sw: 5.6.1.1
db: 5.6.0.23
11/29/2024
2:28 PM

Office 0105 Office 0102 Education 0101 MerRemedy 010 CC Res Storage 0105 Sher 0110 CC Unit 2-1025 CC Unit 2-1026 CC Unit 2-1028 CC Unit 2-1028 Dayroom 1108 Meds 1163 CC Unit 1-1027 CC Unit 1-1028
FC-1 FC-2 FC-3 FC-4 FC-5 FC-6 FC-7 FC-8

REMARKS
Originator: Steen Engineering
Comments:

Level 1 North
TURYE2163AN41AN [Level 1 North]

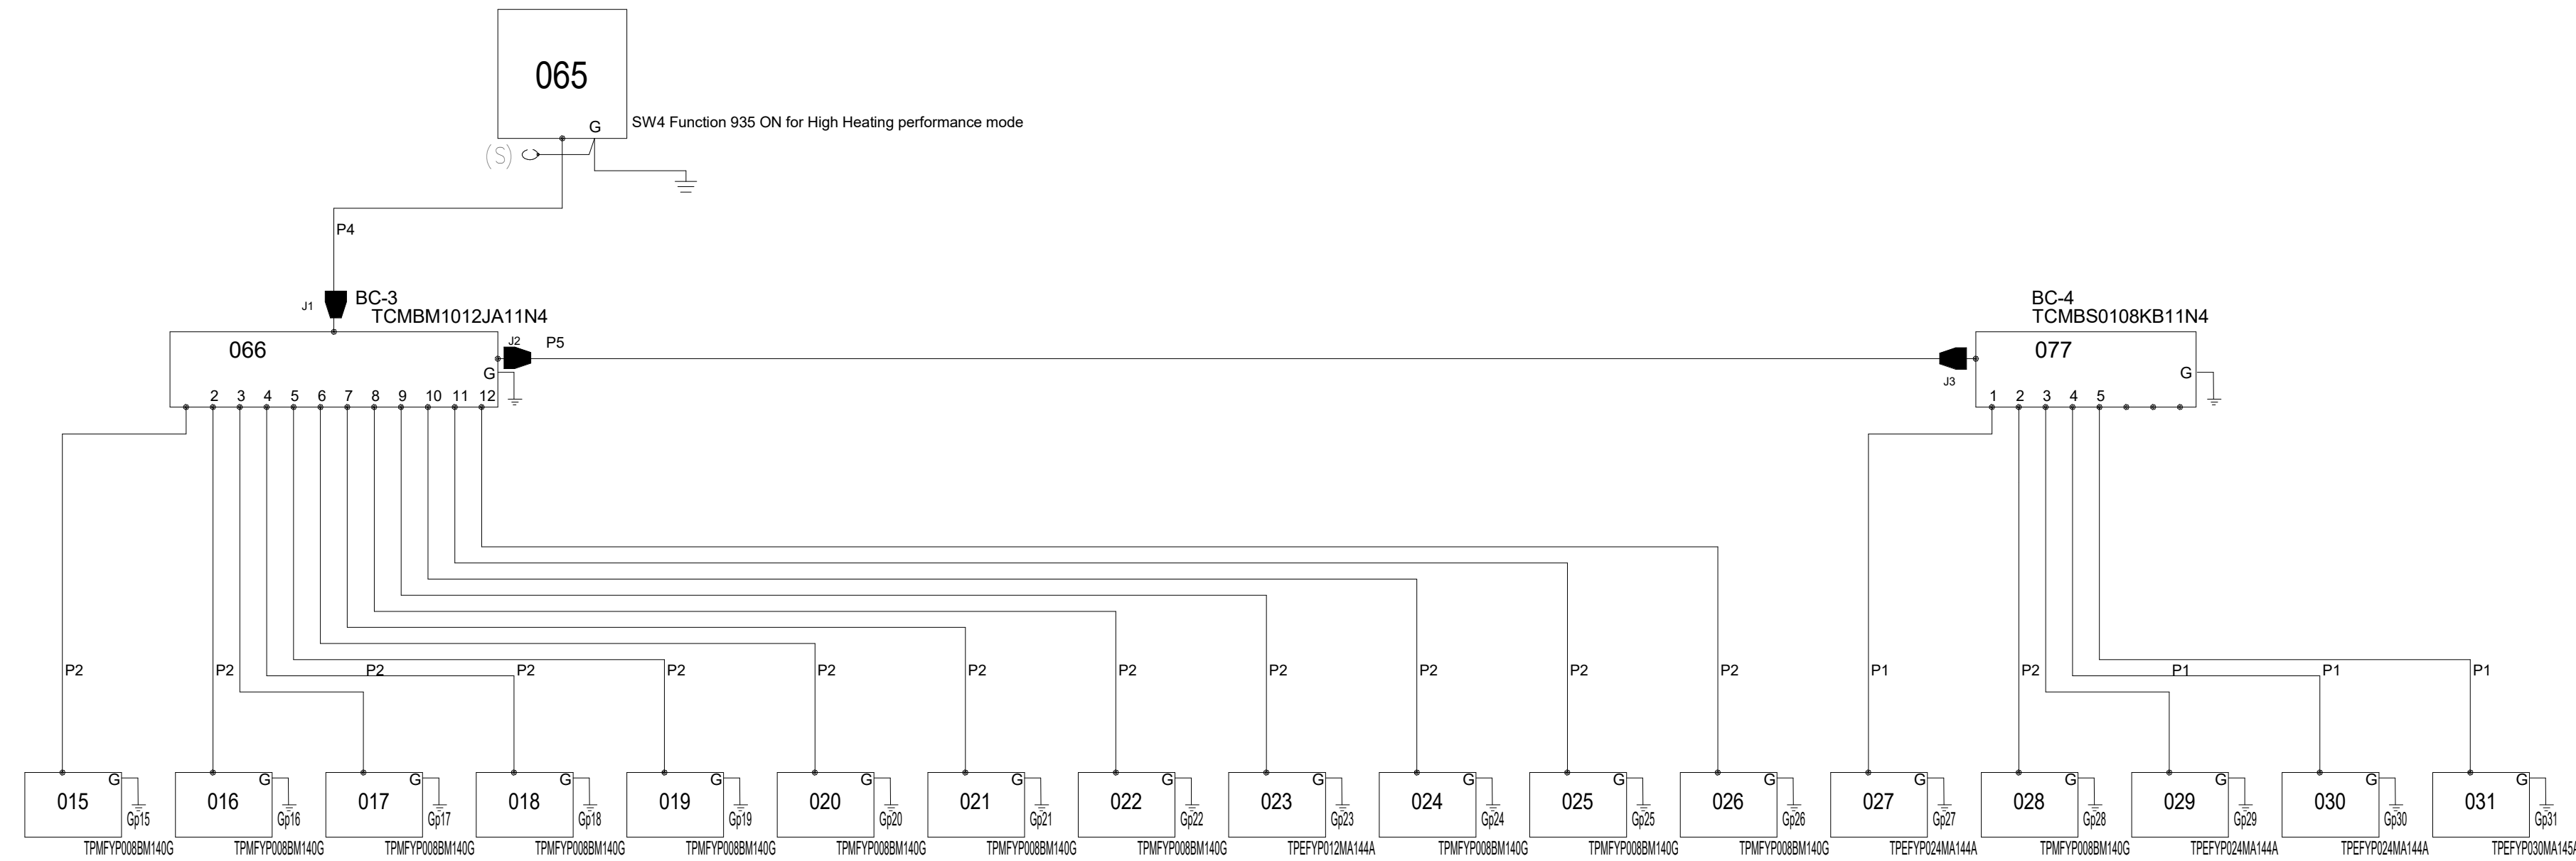

CC Unit 1-1026 CC Unit 1-1024 CC Unit 1-1023 CC Unit 1-1022 CC Unit 1-1021 CC Unit 1-1020 CC Unit 1-1025 CC Unit 1-1028 Laundry 1101 CC Unit 2-1026 CC Unit 2-1024 CC Unit 1-1022 Toilet 1102 CC Unit 1-1027 Conf Room 0101 Corridor 1109 CHTG-1155
FC-9 FC-10 FC-11 FC-12




Mark R. Breneman
Signature

Mark R. Breneman
Typed or Printed Name

Mechanical Discipline 12/02/24 Date

WESLEY BRADLEY PARK
PHASE 2 - CARE CENTER
707 39TH AVENUE SE
PUYALLUP, WA 98374

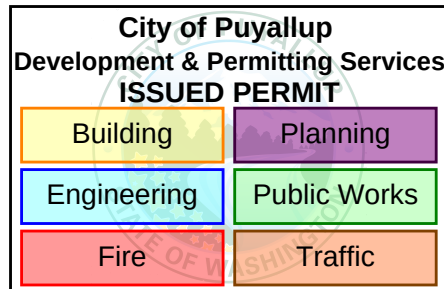

CARE CENTER
PERMIT SET
December 2, 2024

REVISIONS

No. Description Date

ISA202201

PROJECT NUMBER

DCA

DRAWN BY

MRB

CHECKED BY

WESLEY BRADLEY PARK
PHASE 2 - CARE CENTER

MECHANICAL DETAILS

M5.2


Bradley Park		
DIAGRAM SYMBOL LEGEND	CONTING	PAGE
DISPLAY		
--- POWER WIRE		
--- CONTROL WIRE		
----- REF. PIPE		

CITY MULTI
SYSTEM SCHEMATIC DWG.

This drawing is schematic in nature. Final routing of piping & wiring

shall be determined by the installing contractor and/or designer of record
Additional refrigerant charge is needed depending on the size and length of extended piping.
Please refer the amount of pre-charge and the formula of calculation which is mentioned on the data book.
1.25mm(1/8 AWG) : 1.25mm(1/8 AWG) or
0.75mm(20 AWG) : between 0.5mm(24 AWG) and 0.75mm(20 AWG).

PIPING AND CONTROLS
SYMBOL BRANCH PIPE MODEL NAME
J1 CMV-R302S-G1
J2 CMV-R302S-G1
J3 CMV-R302S-G
SYMBOL LIQUID PIPE GAS PIPE SIZE
P1 3/8 / 1/2
P2 1/4 / 1/2
P3 7/8 / 3/8
P4 3/8 / 3/4 / 7/8
SYMBOL MODEL NUMBER
MA TAB-201AAU

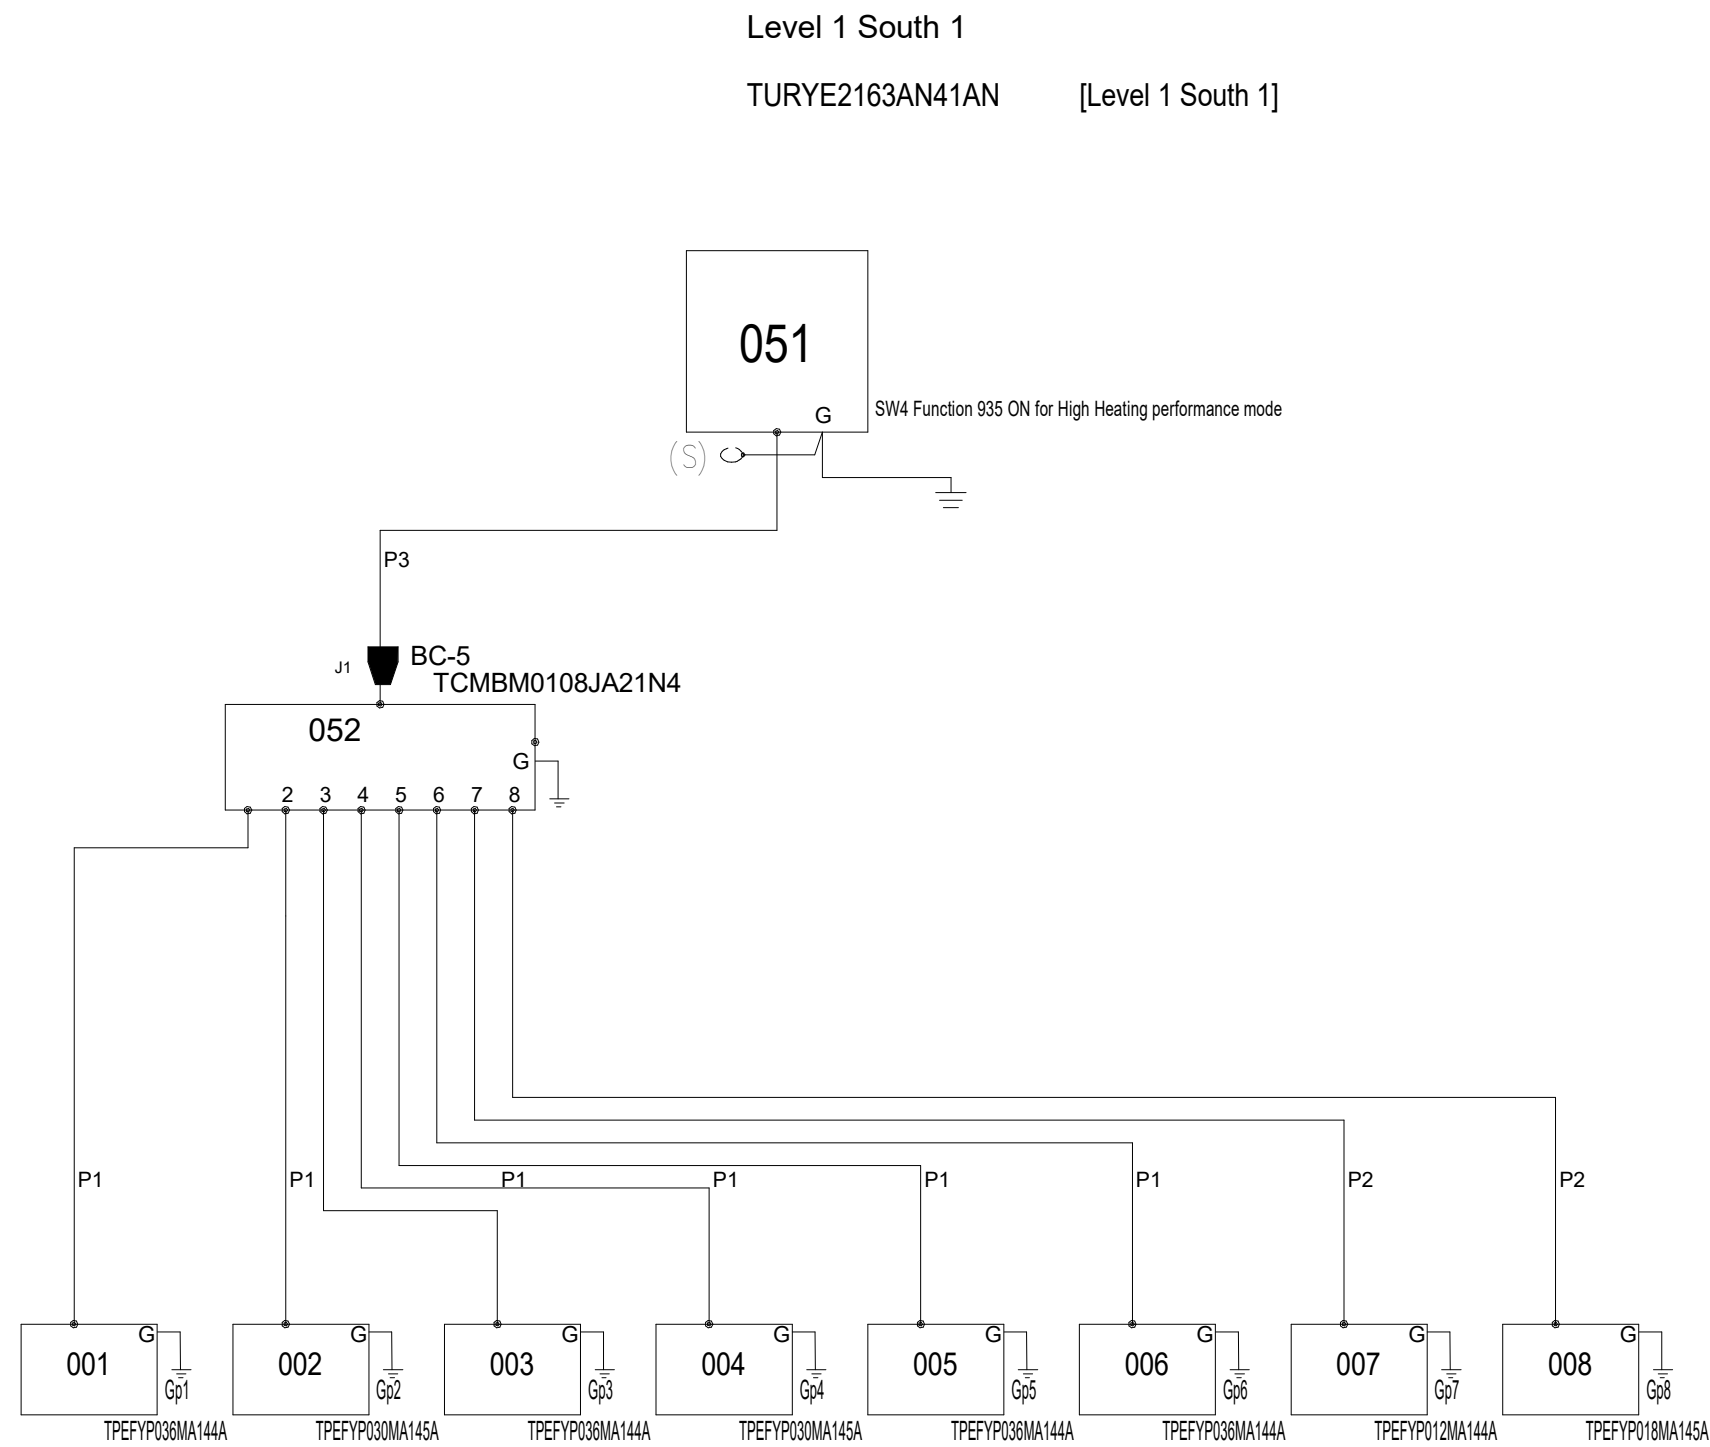

















Diamond System Builder
sw: 5.6.1.1
db: 5.6.0.23
11/29/2024 2:28 PM

Service Notes:114	Therapy:115A	Drugs:1153	Office:1155	Storage:115A	Conference:114	Social Work:1111	Director:1111
FC-13	FC-14	FC-15	FC-16	FC-17	FC-18	FC-19	FC-20

REMARKS
Originator: Steen Engineering
Comments:

Level 1 South 2
TURYE2163AN41AN [Level 1 South 2]

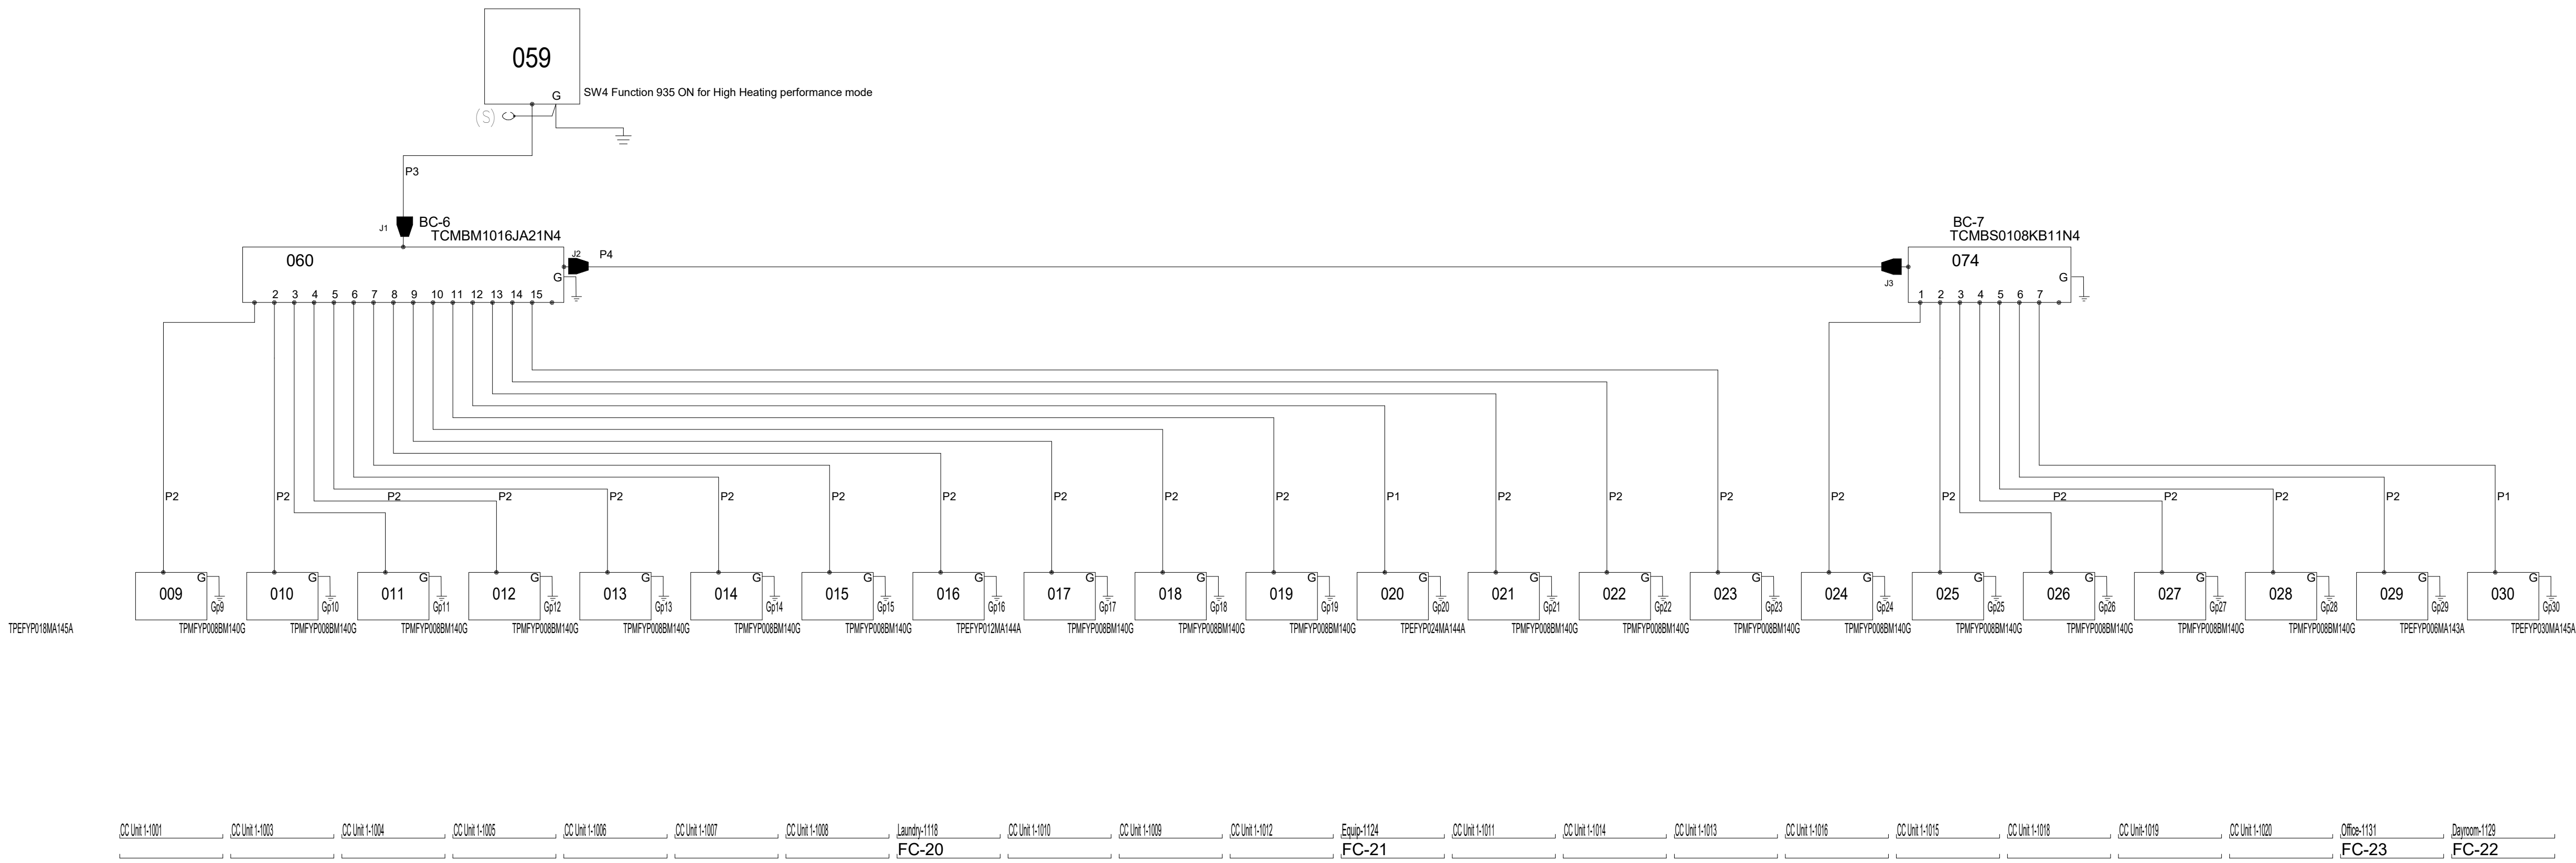

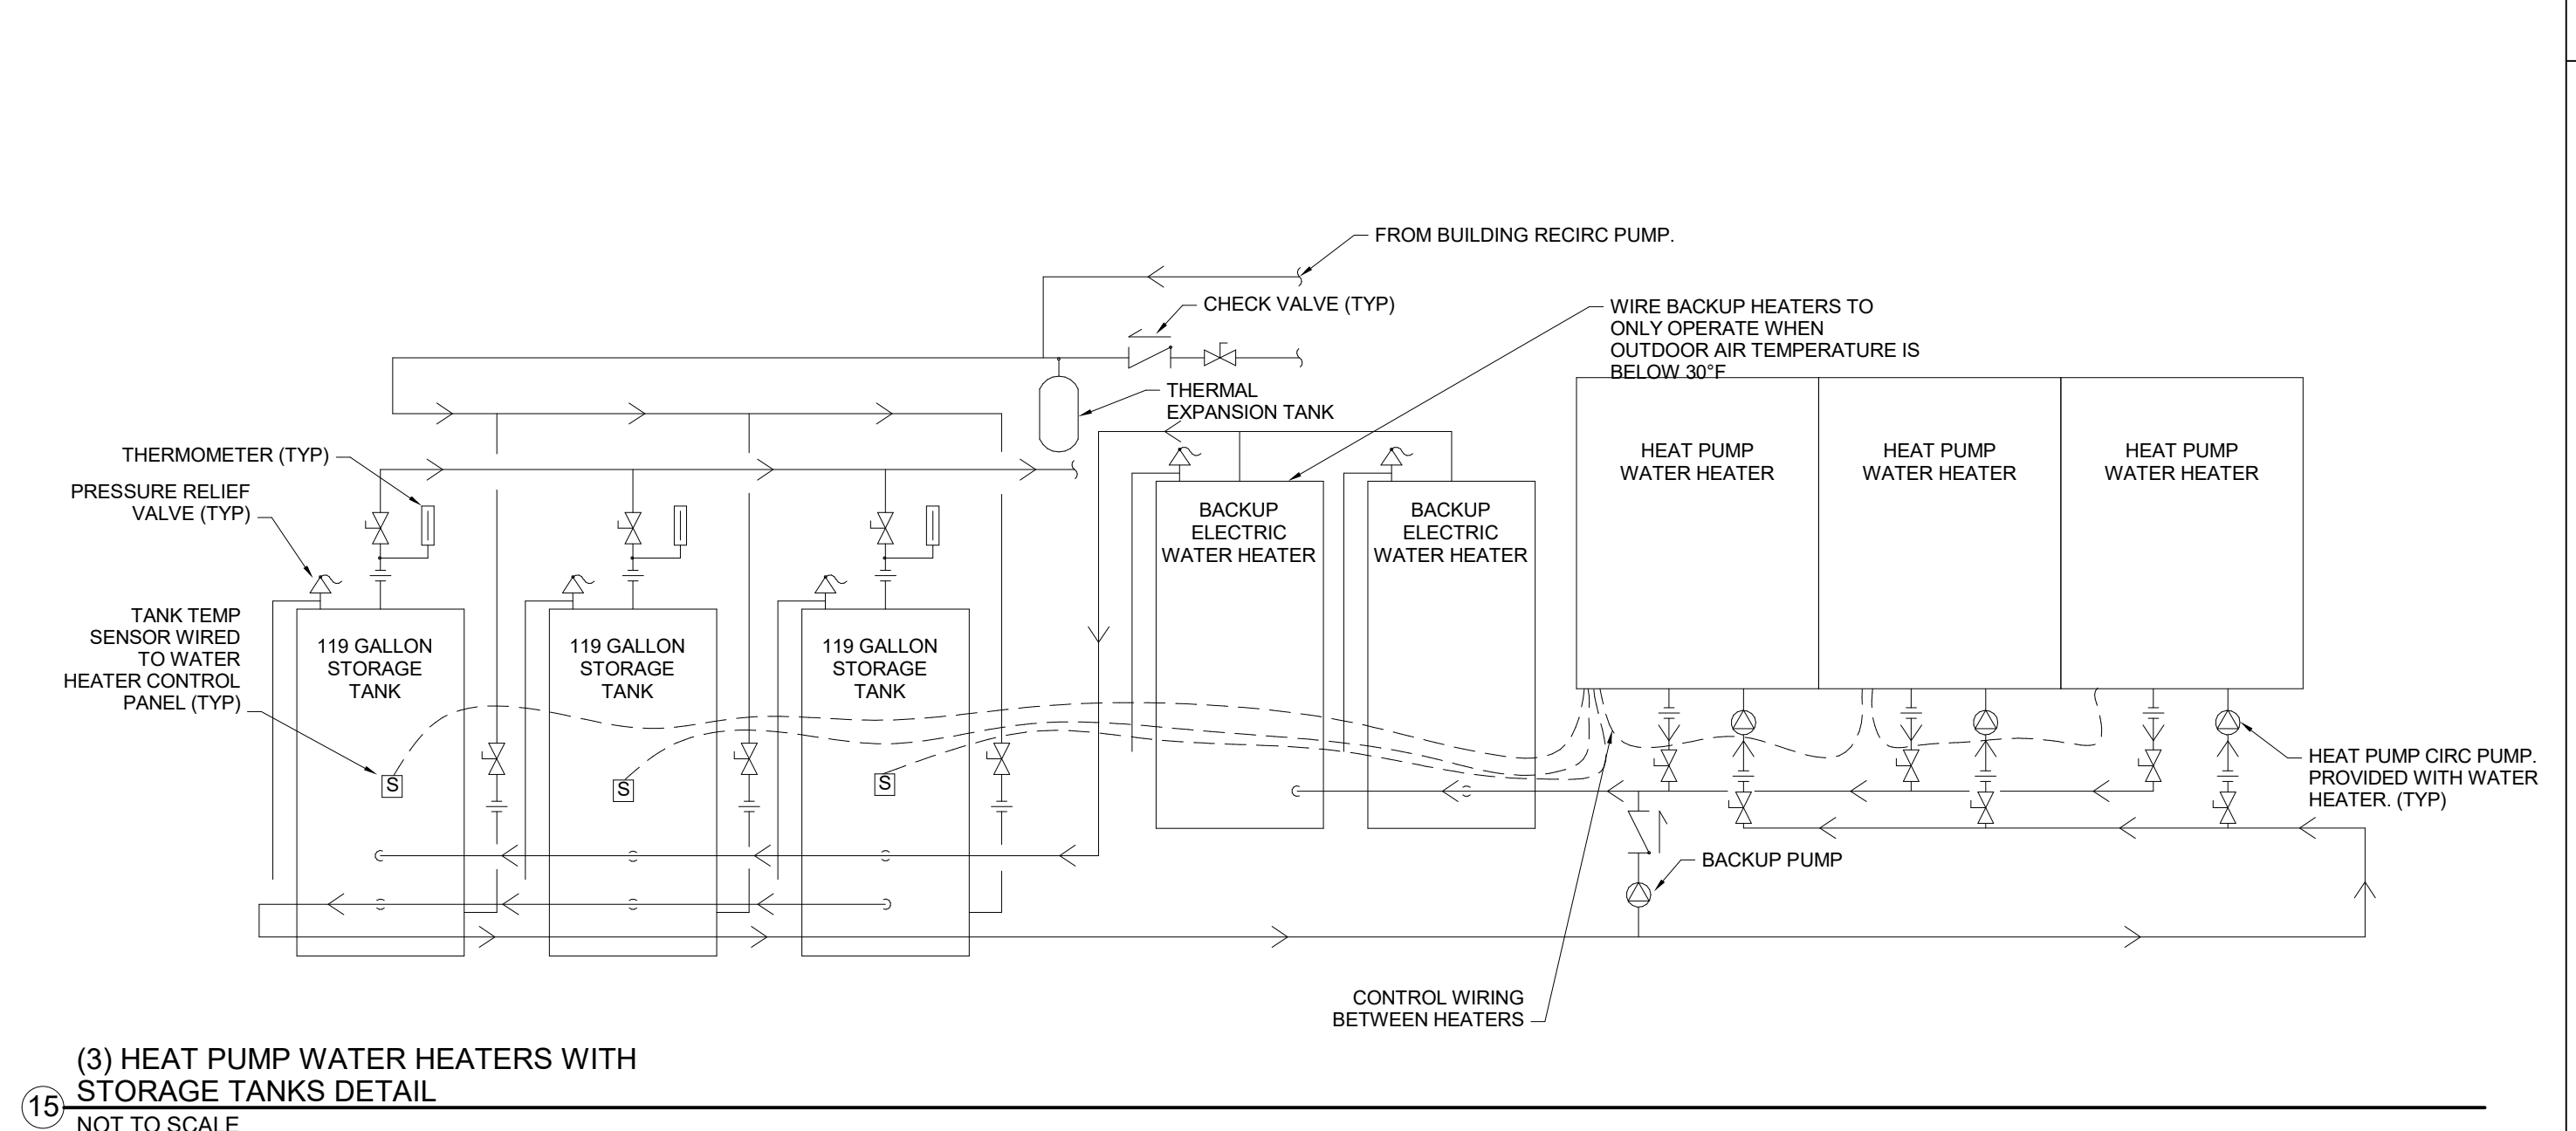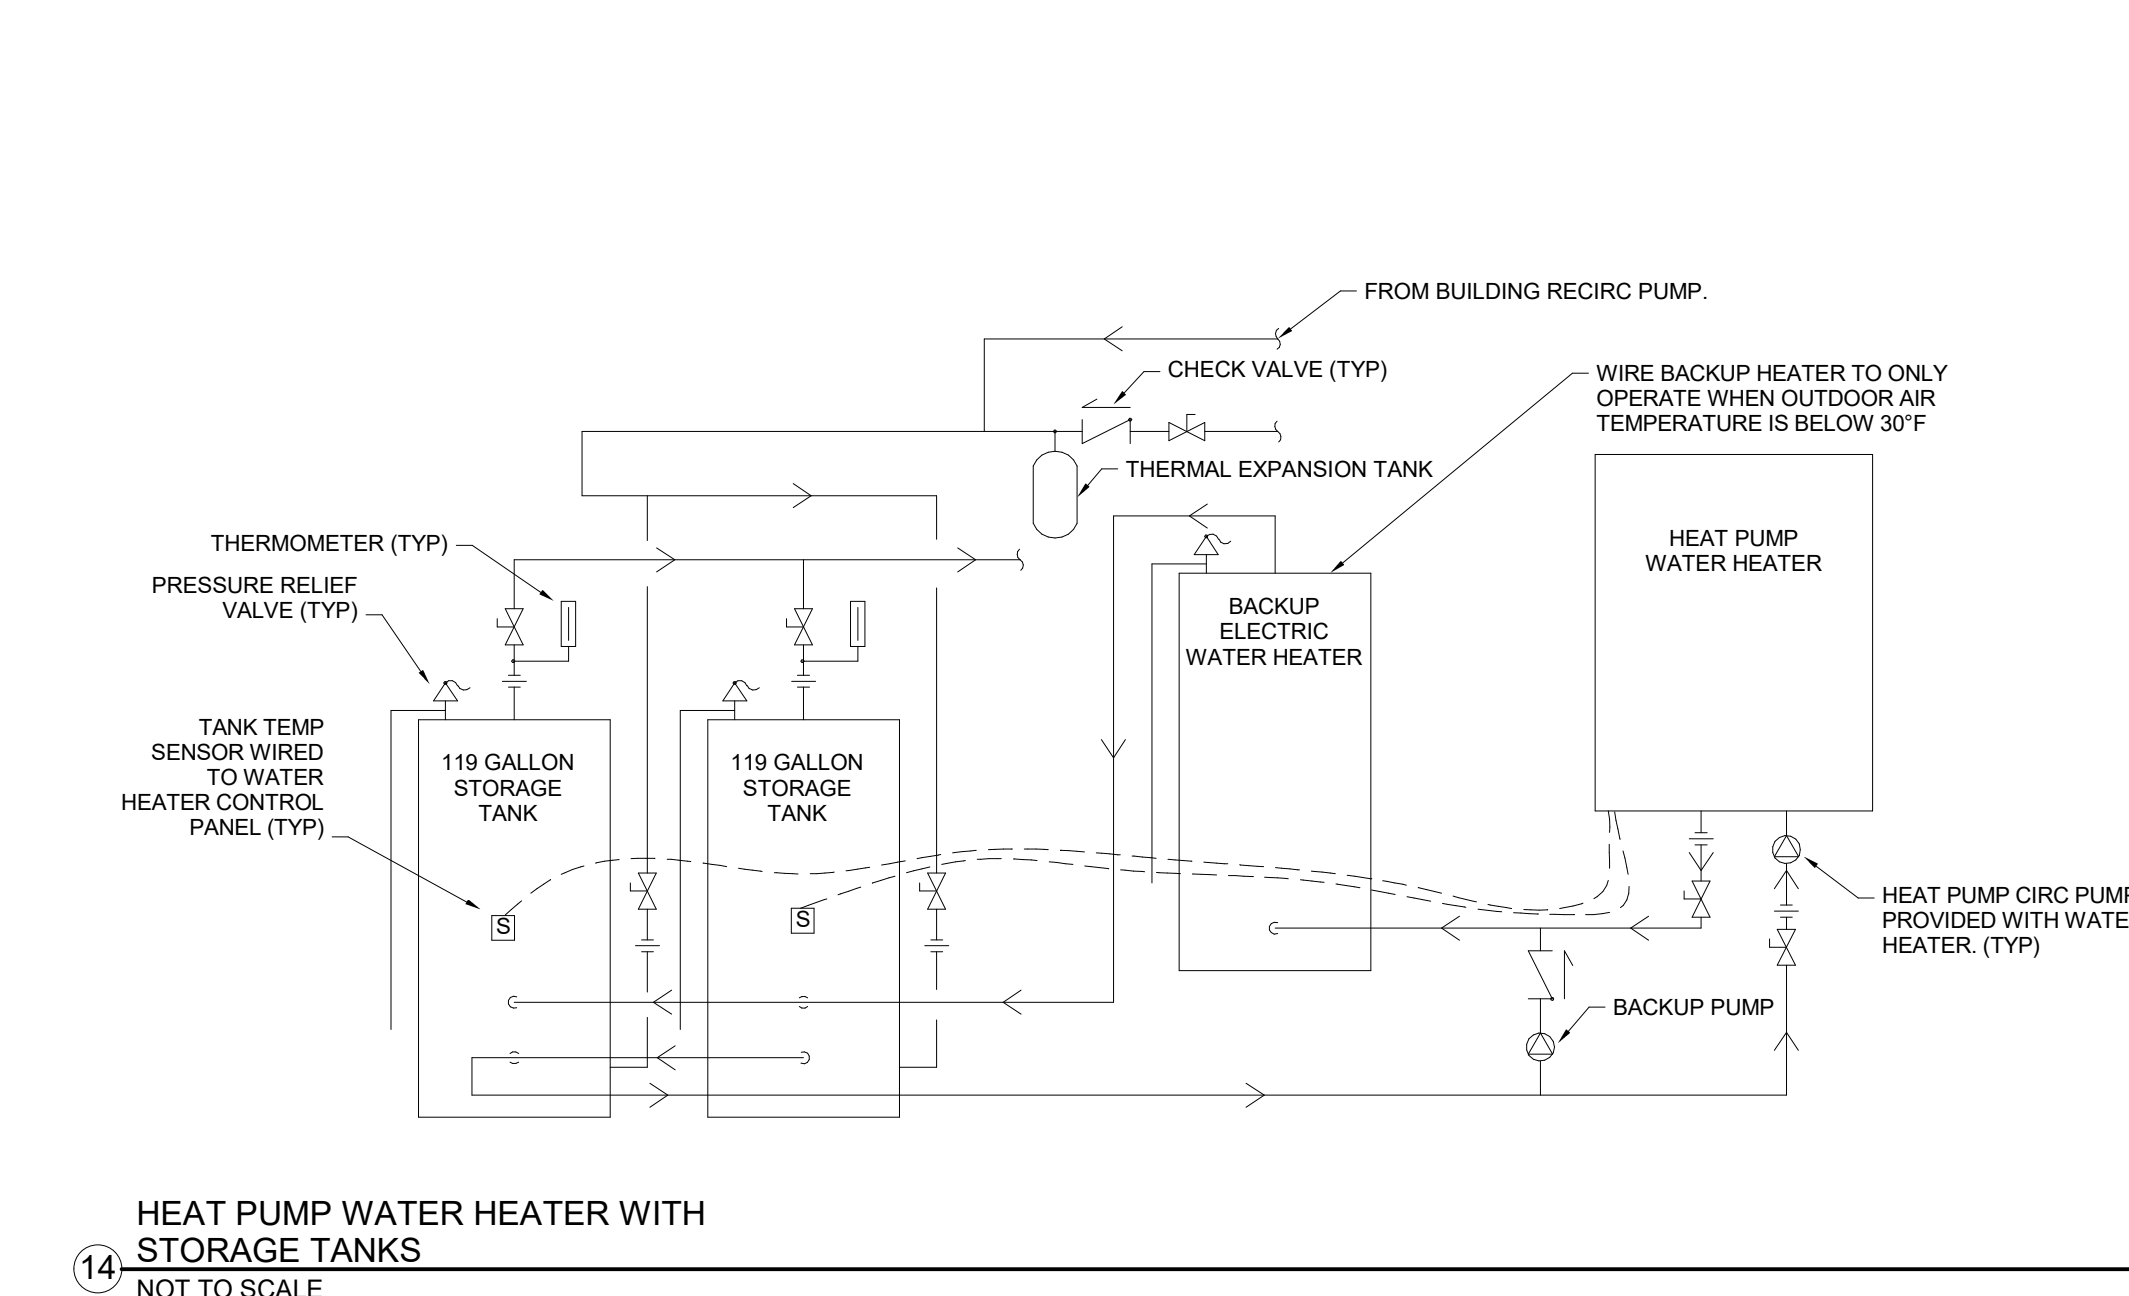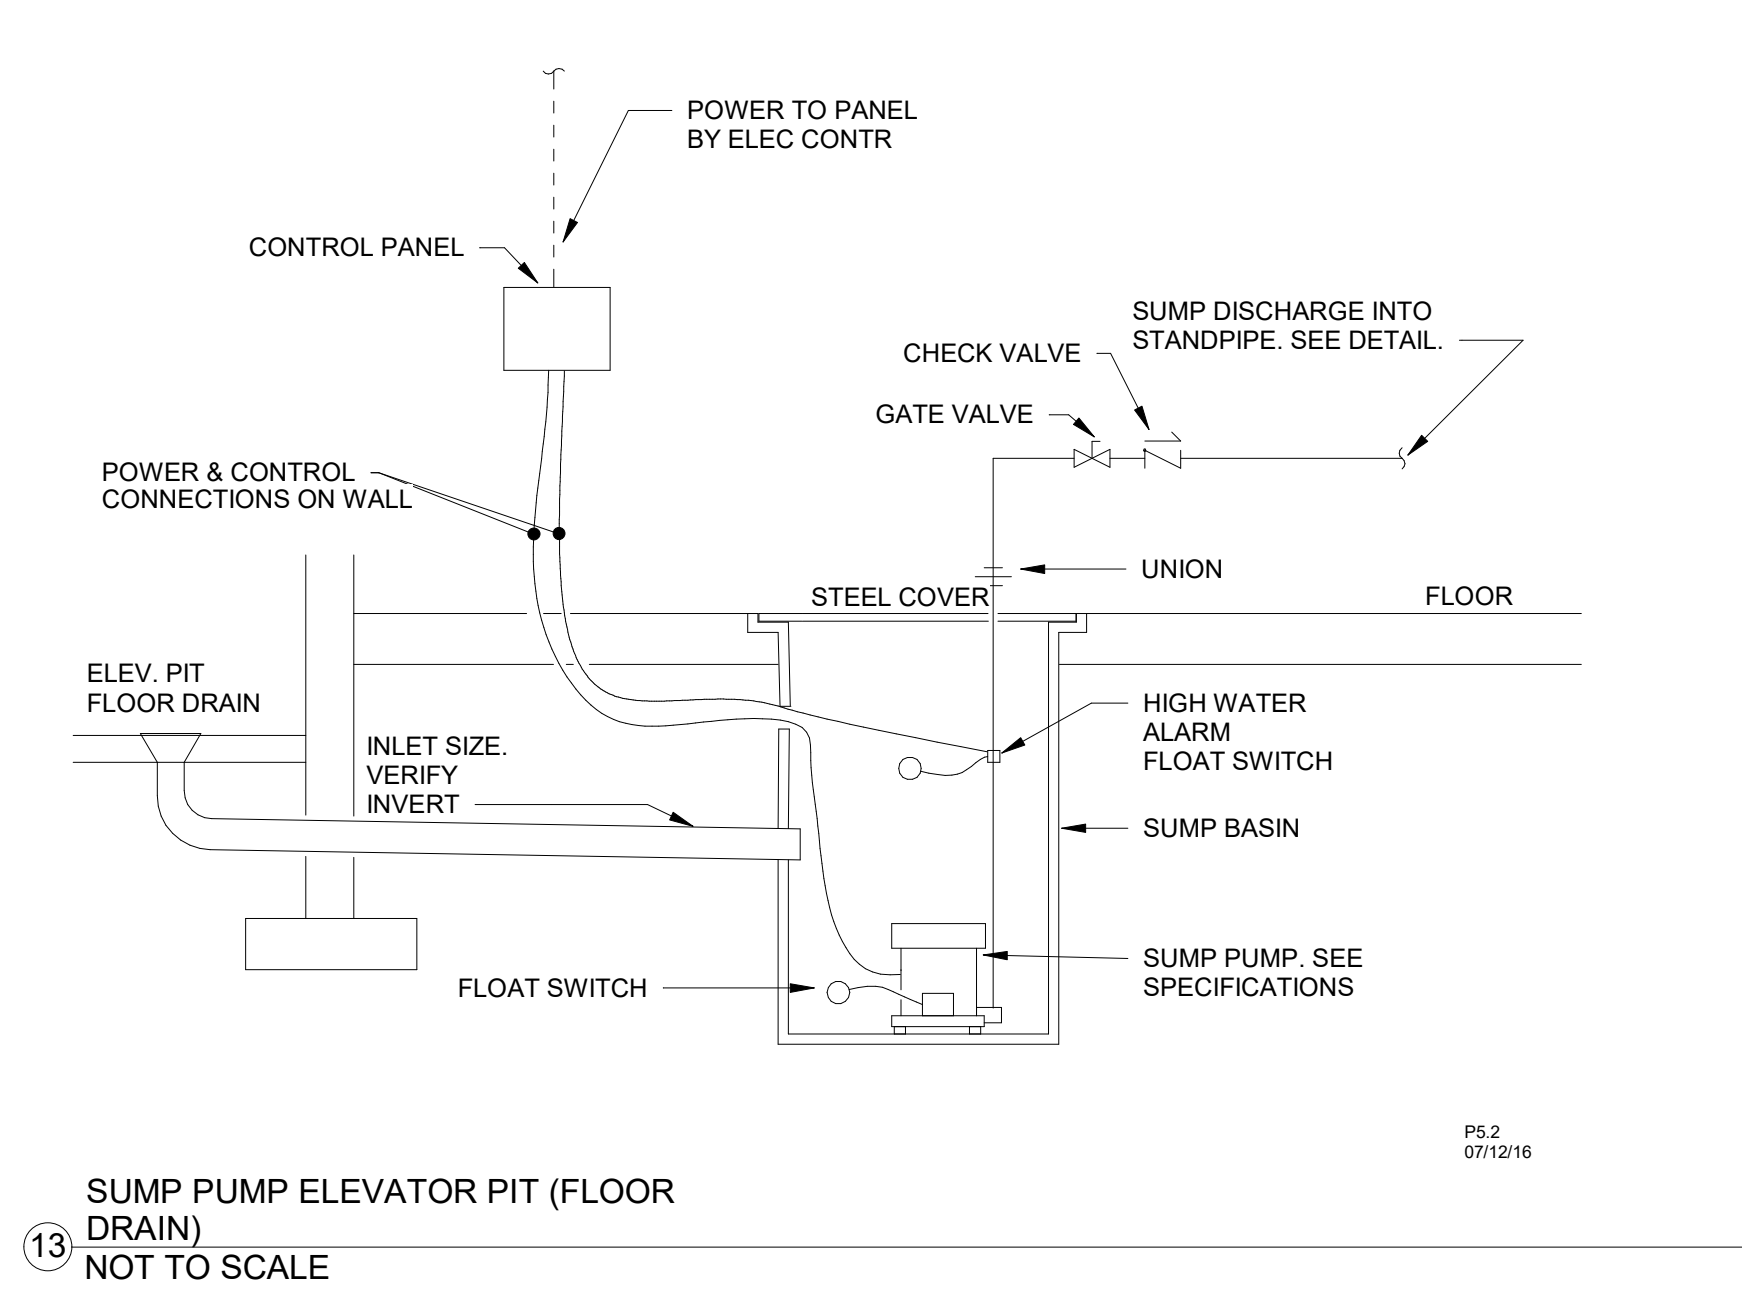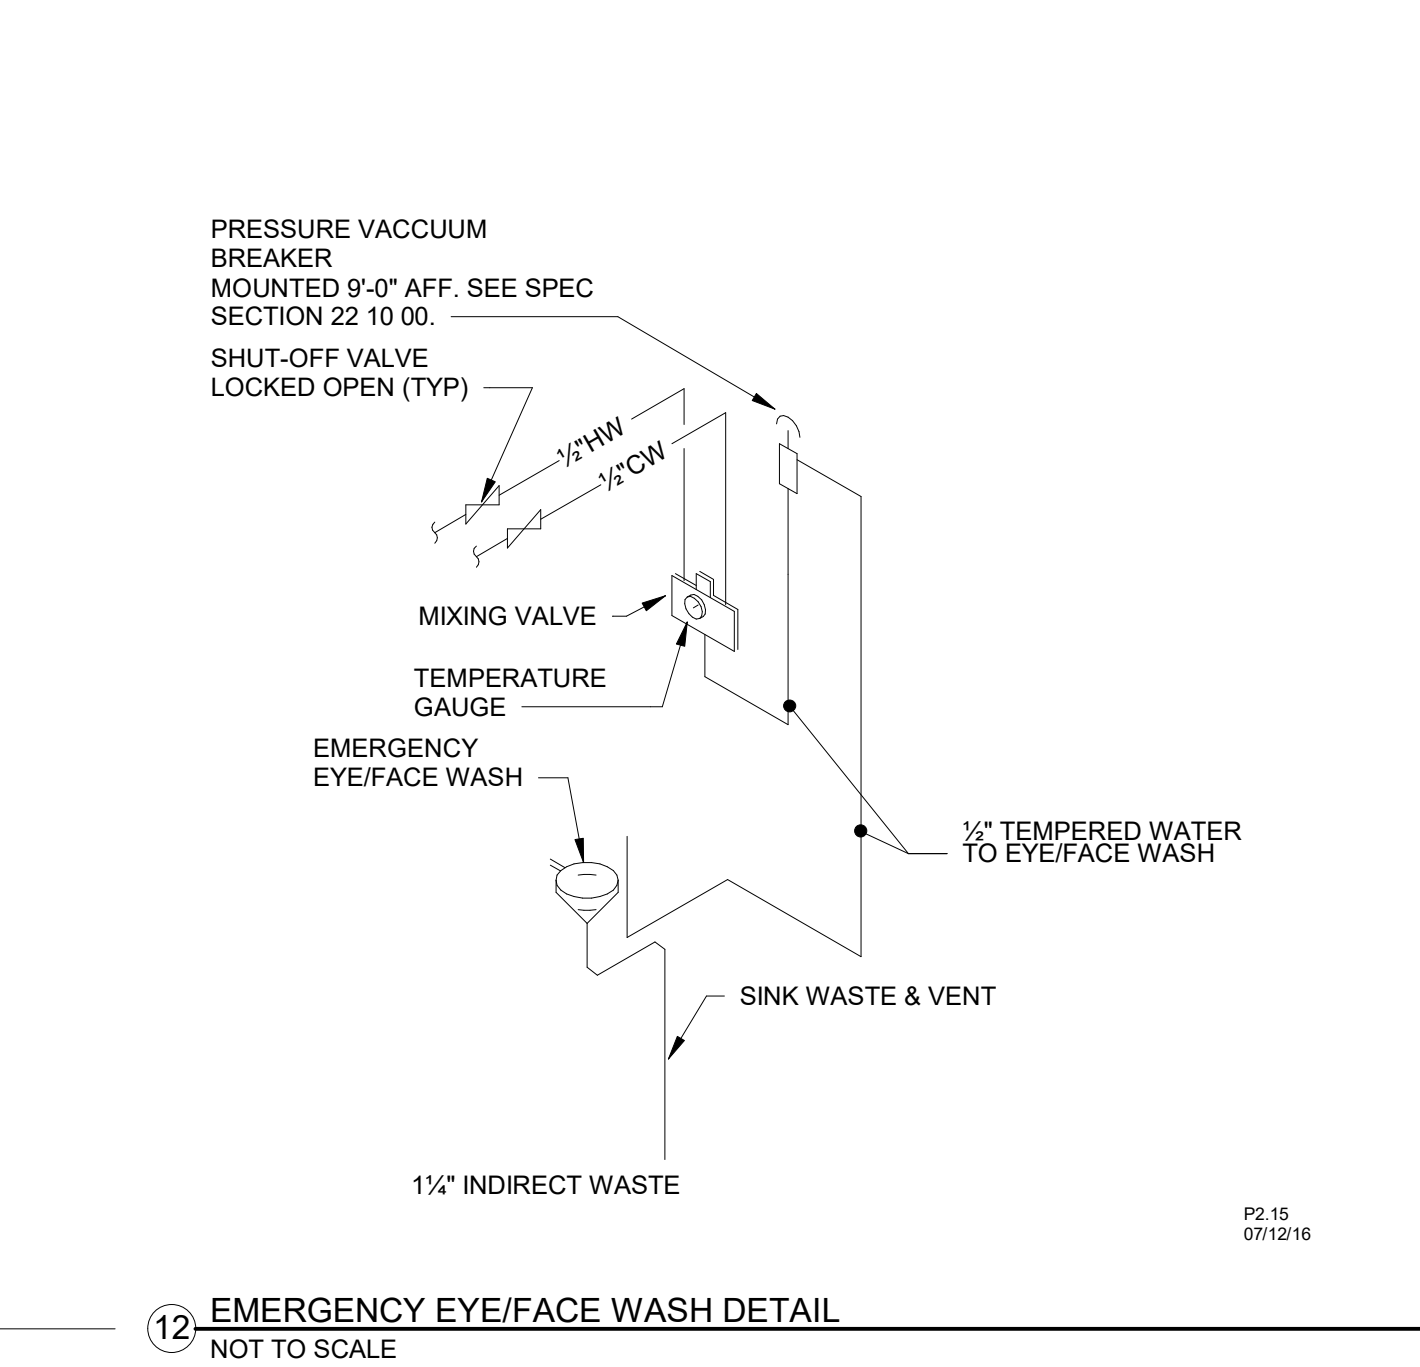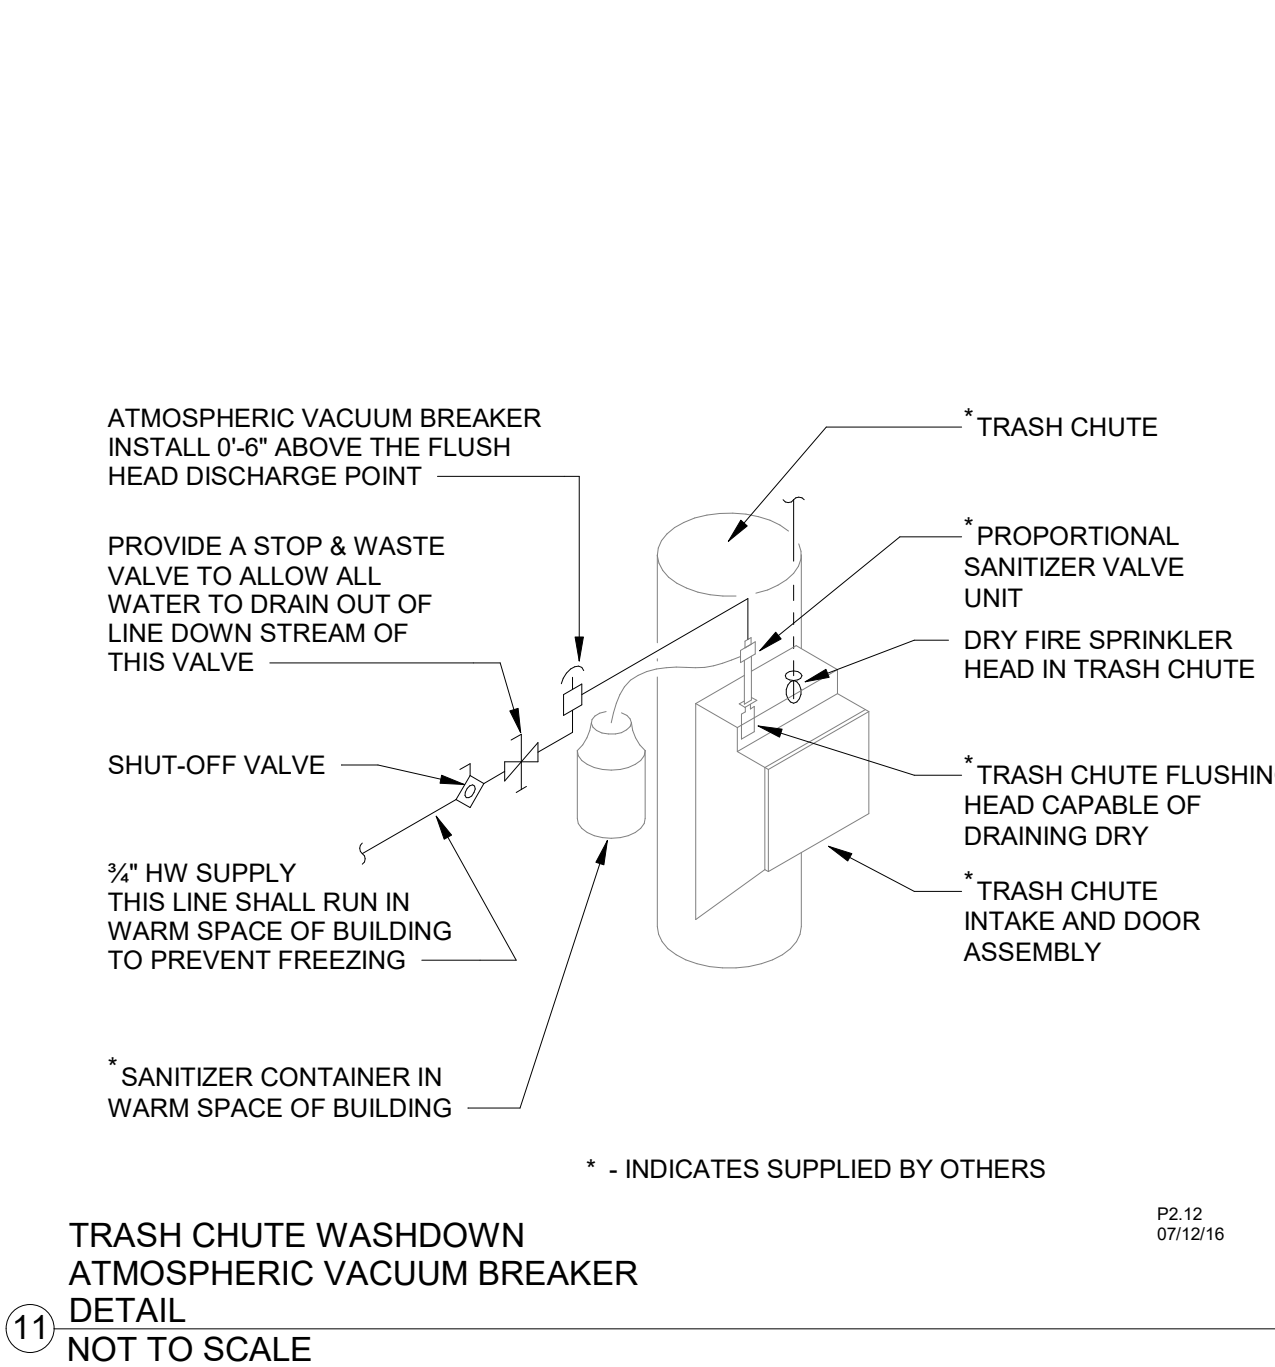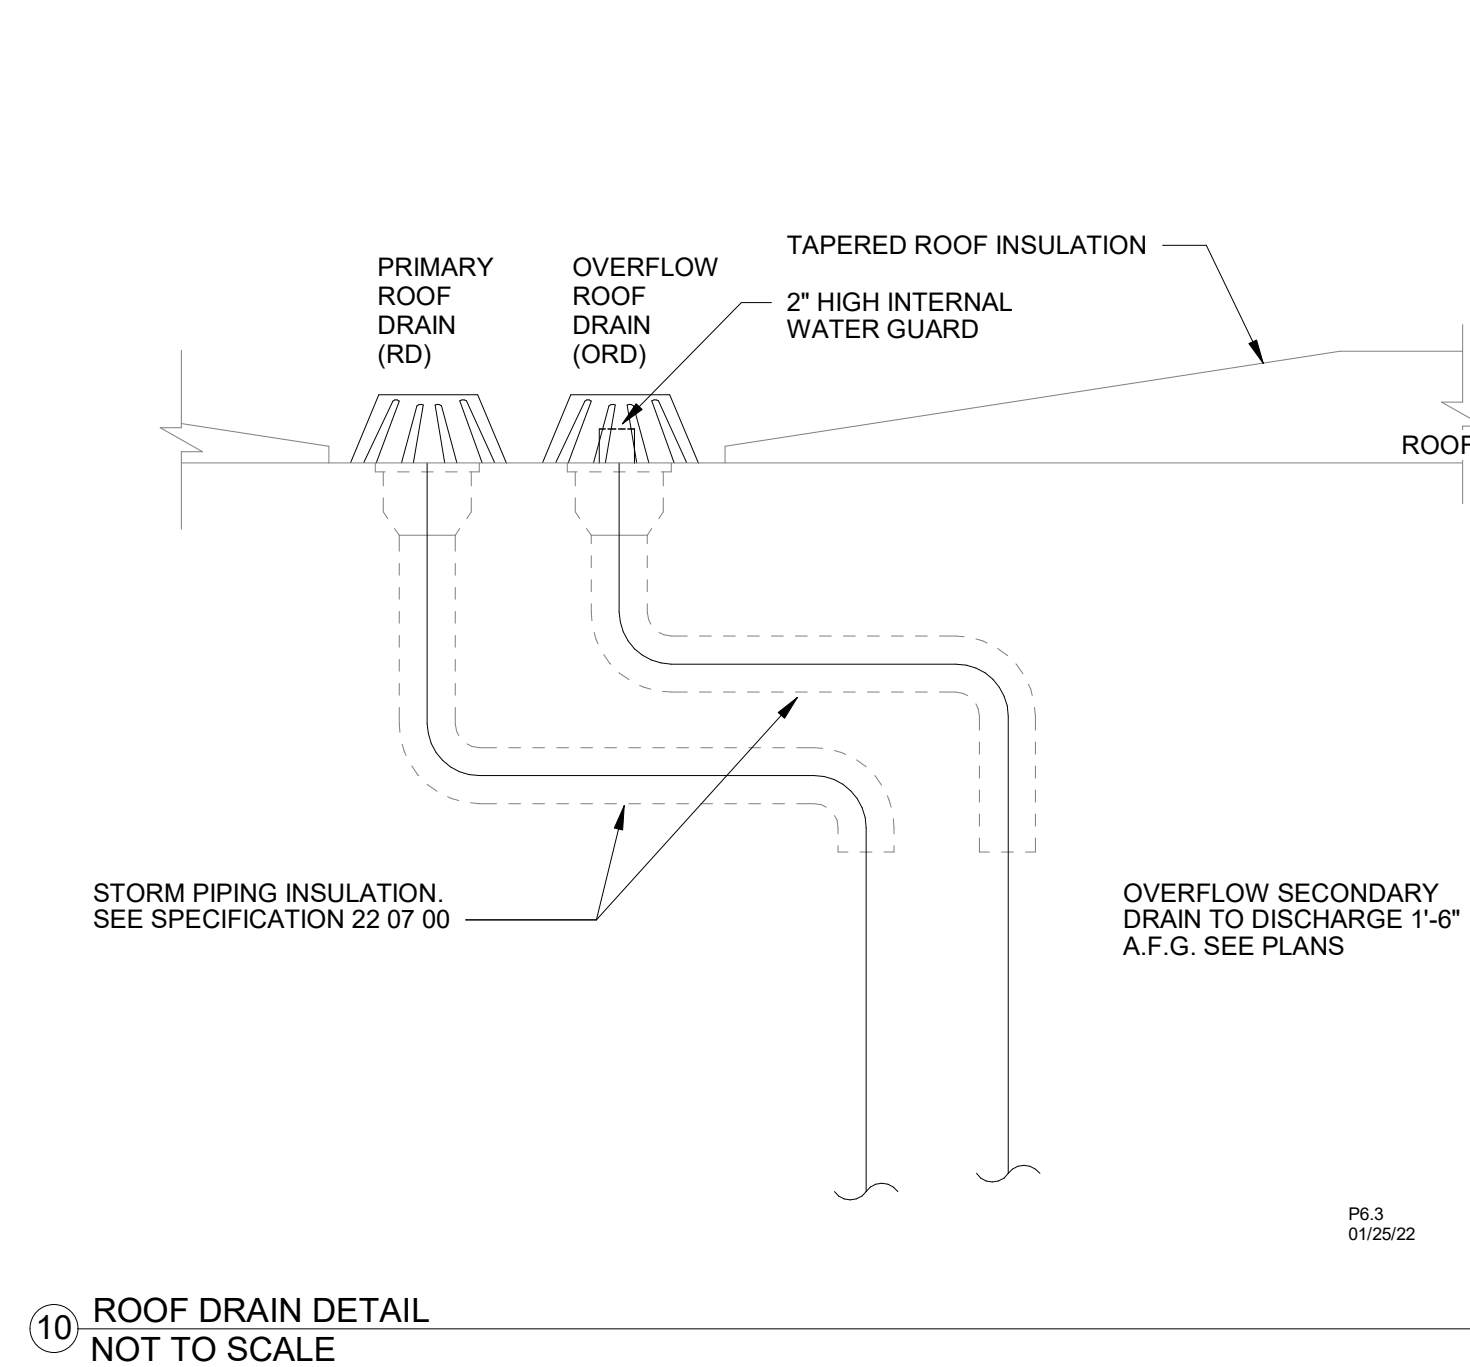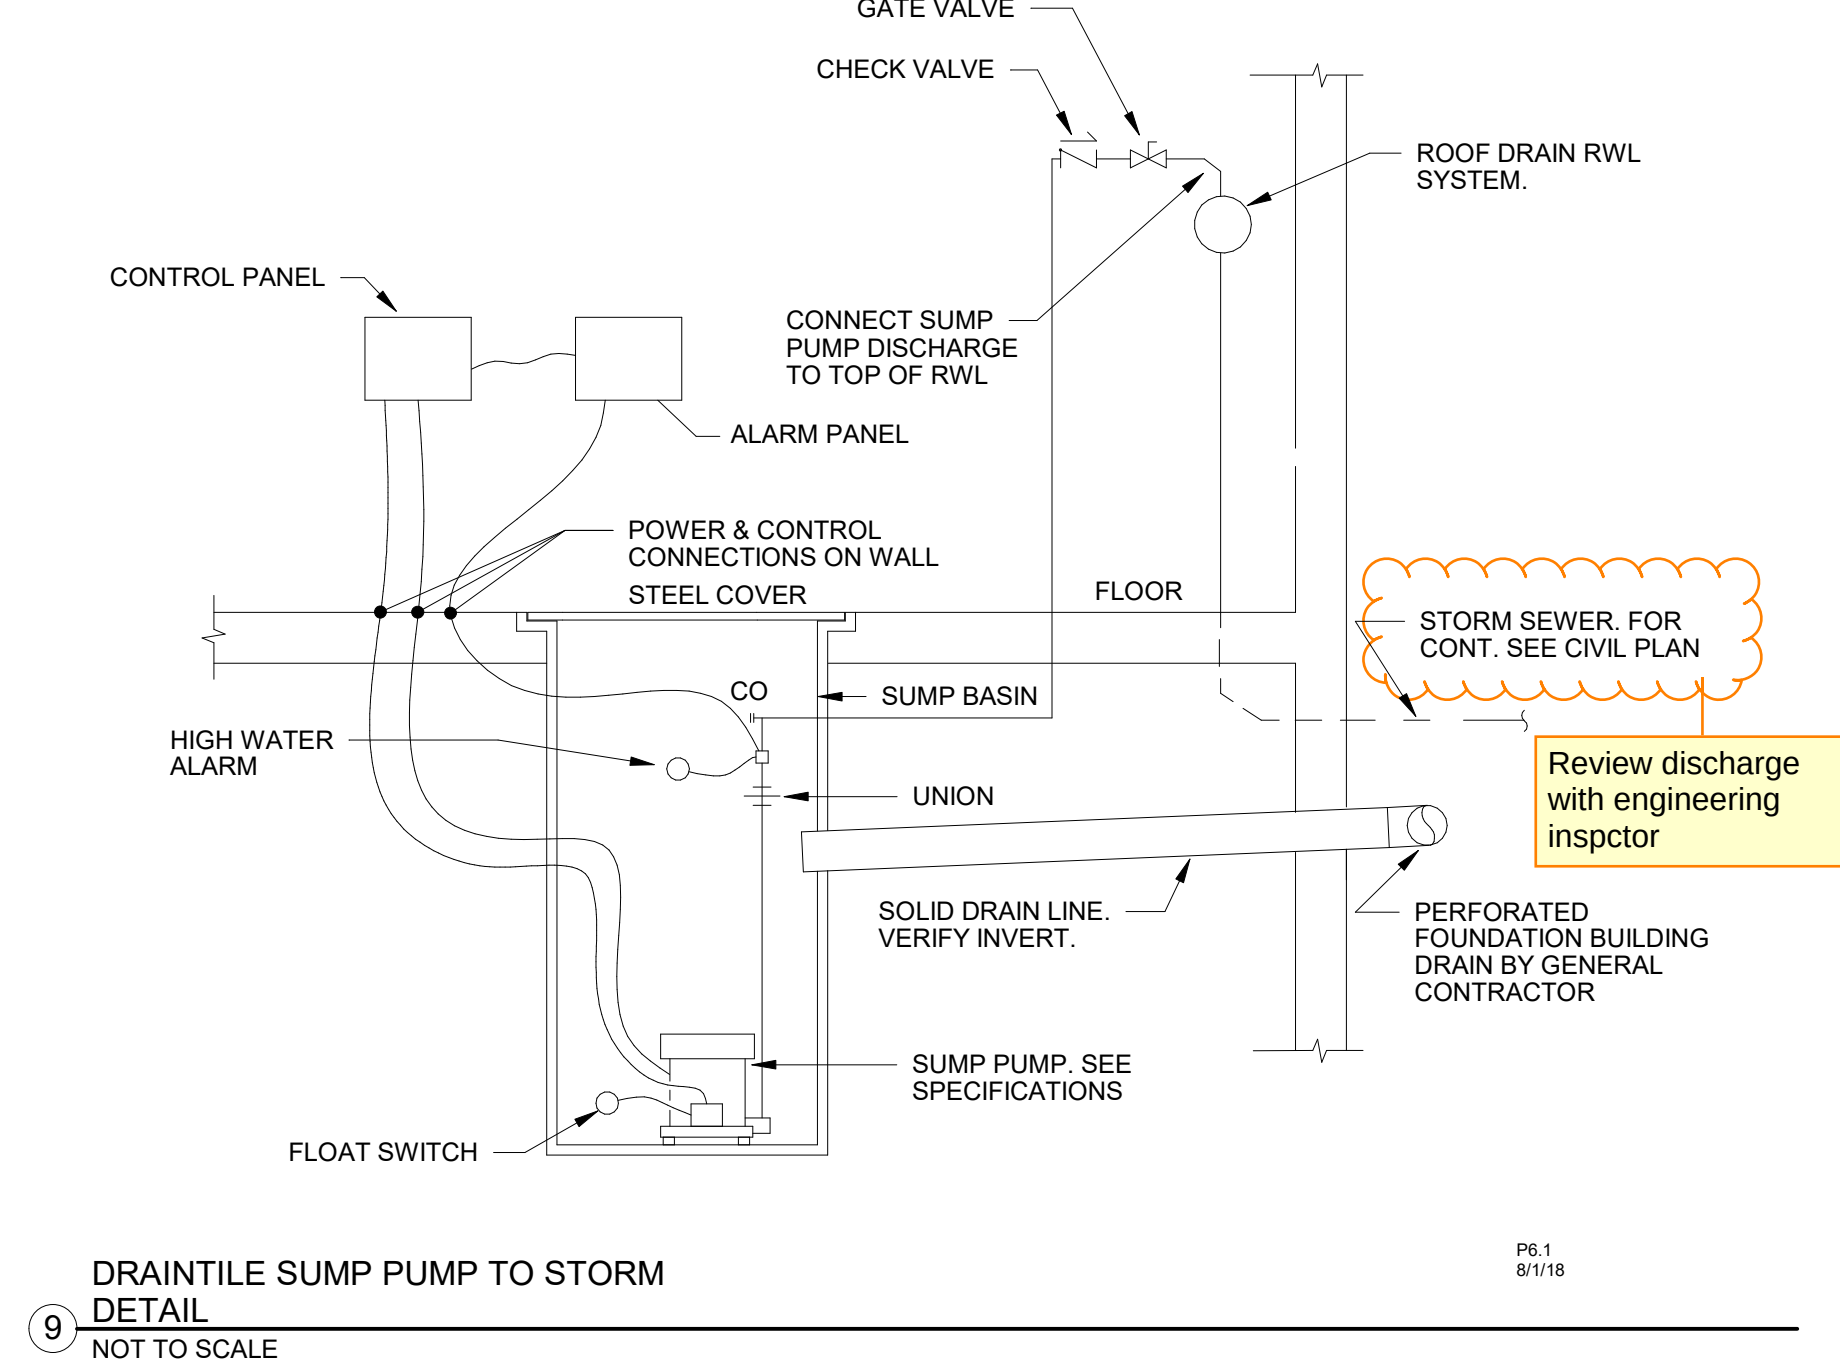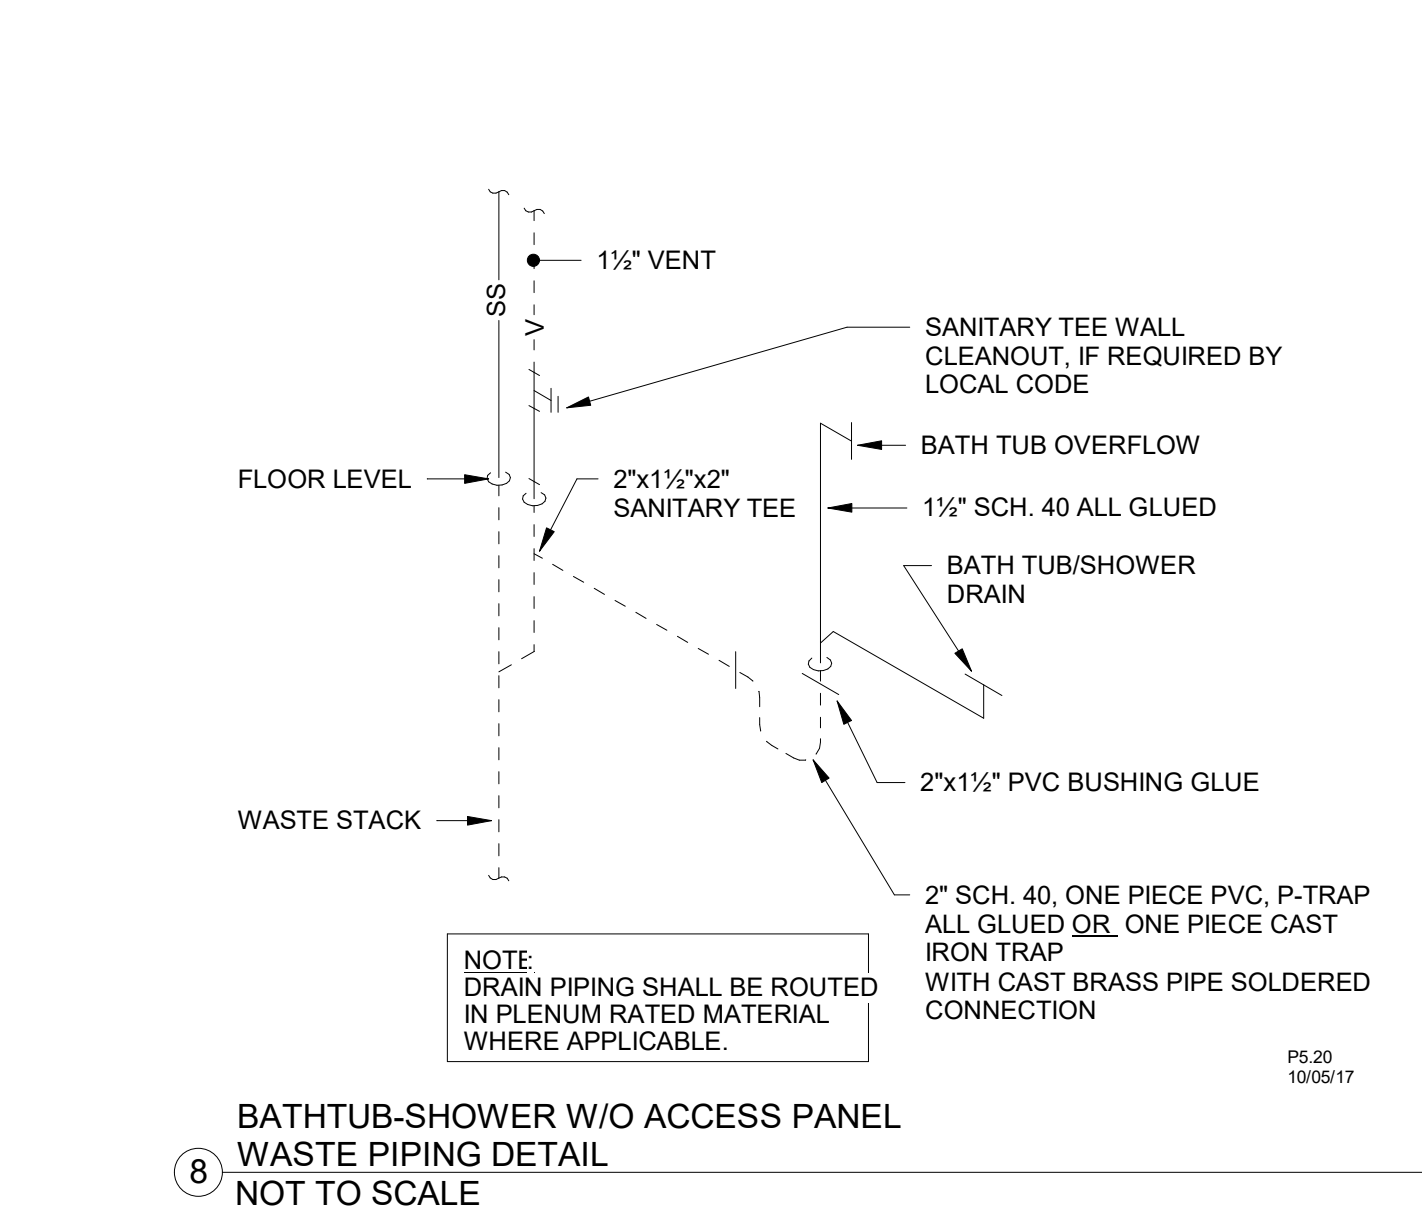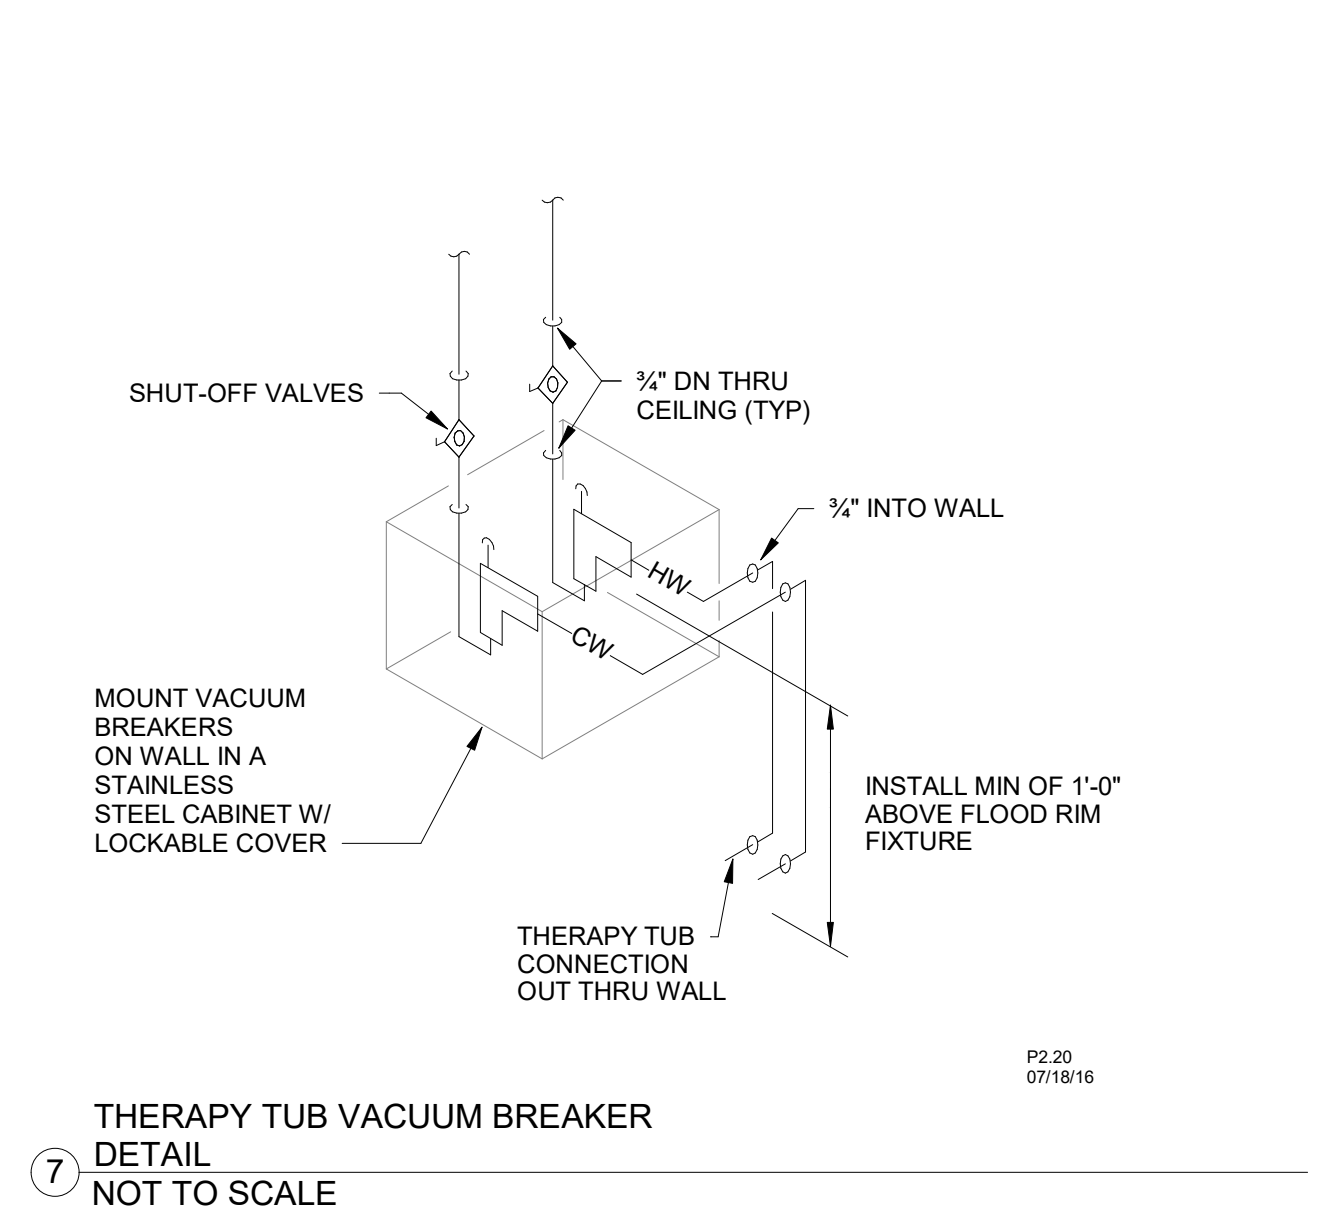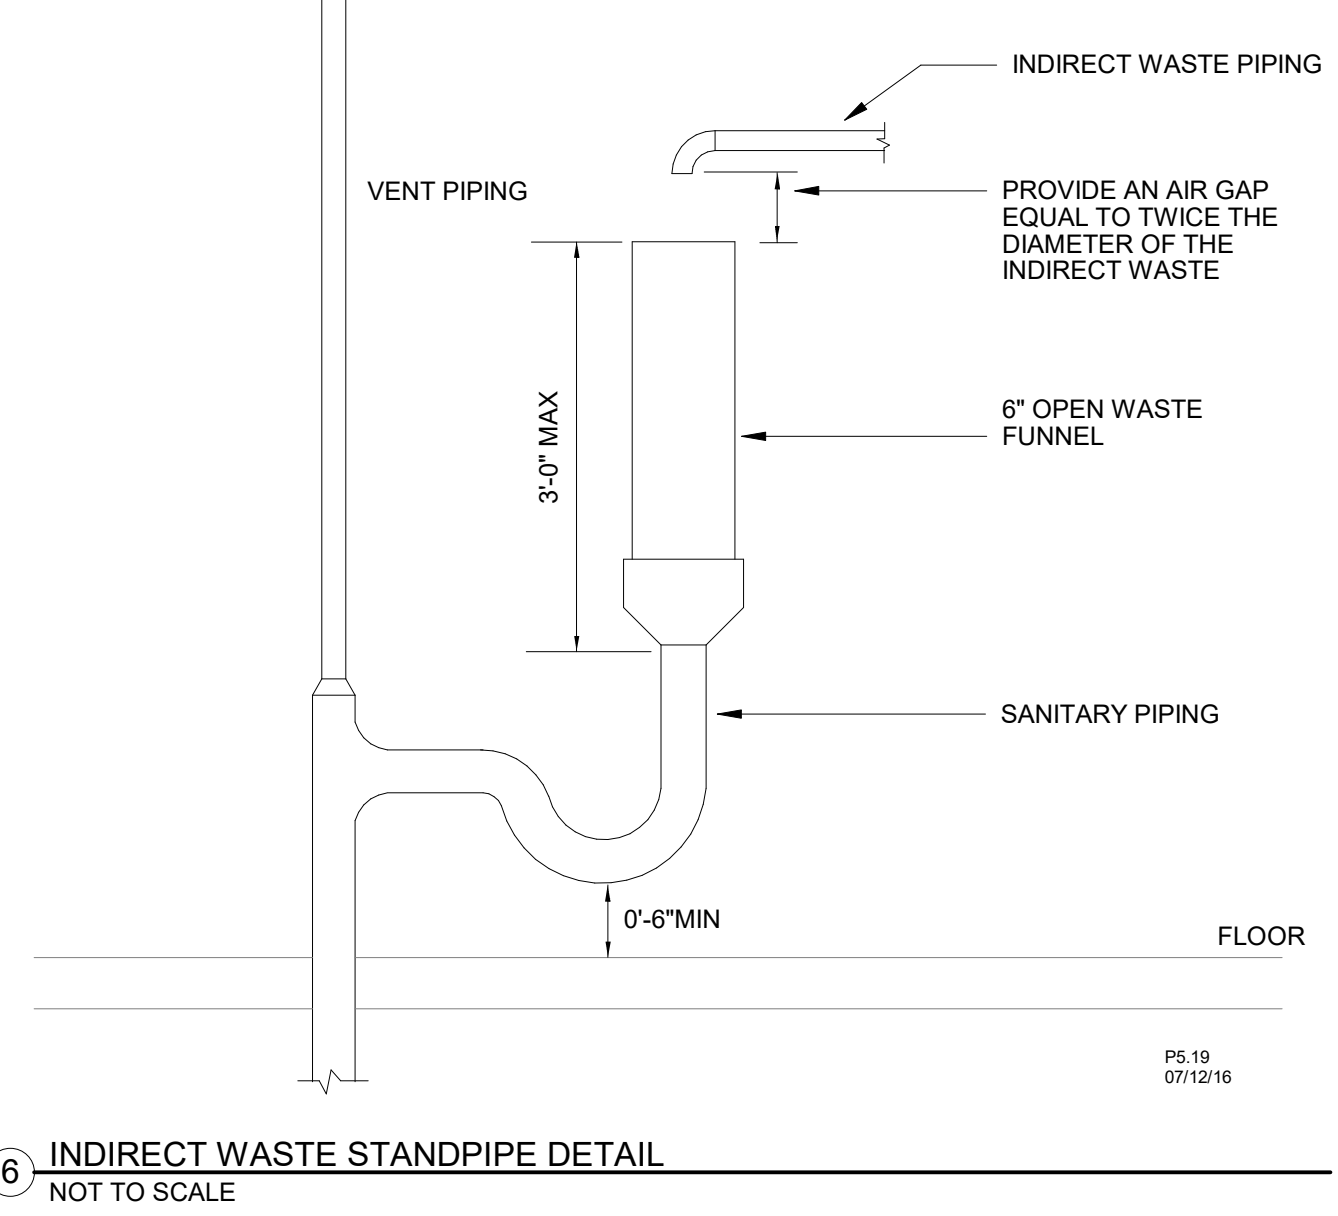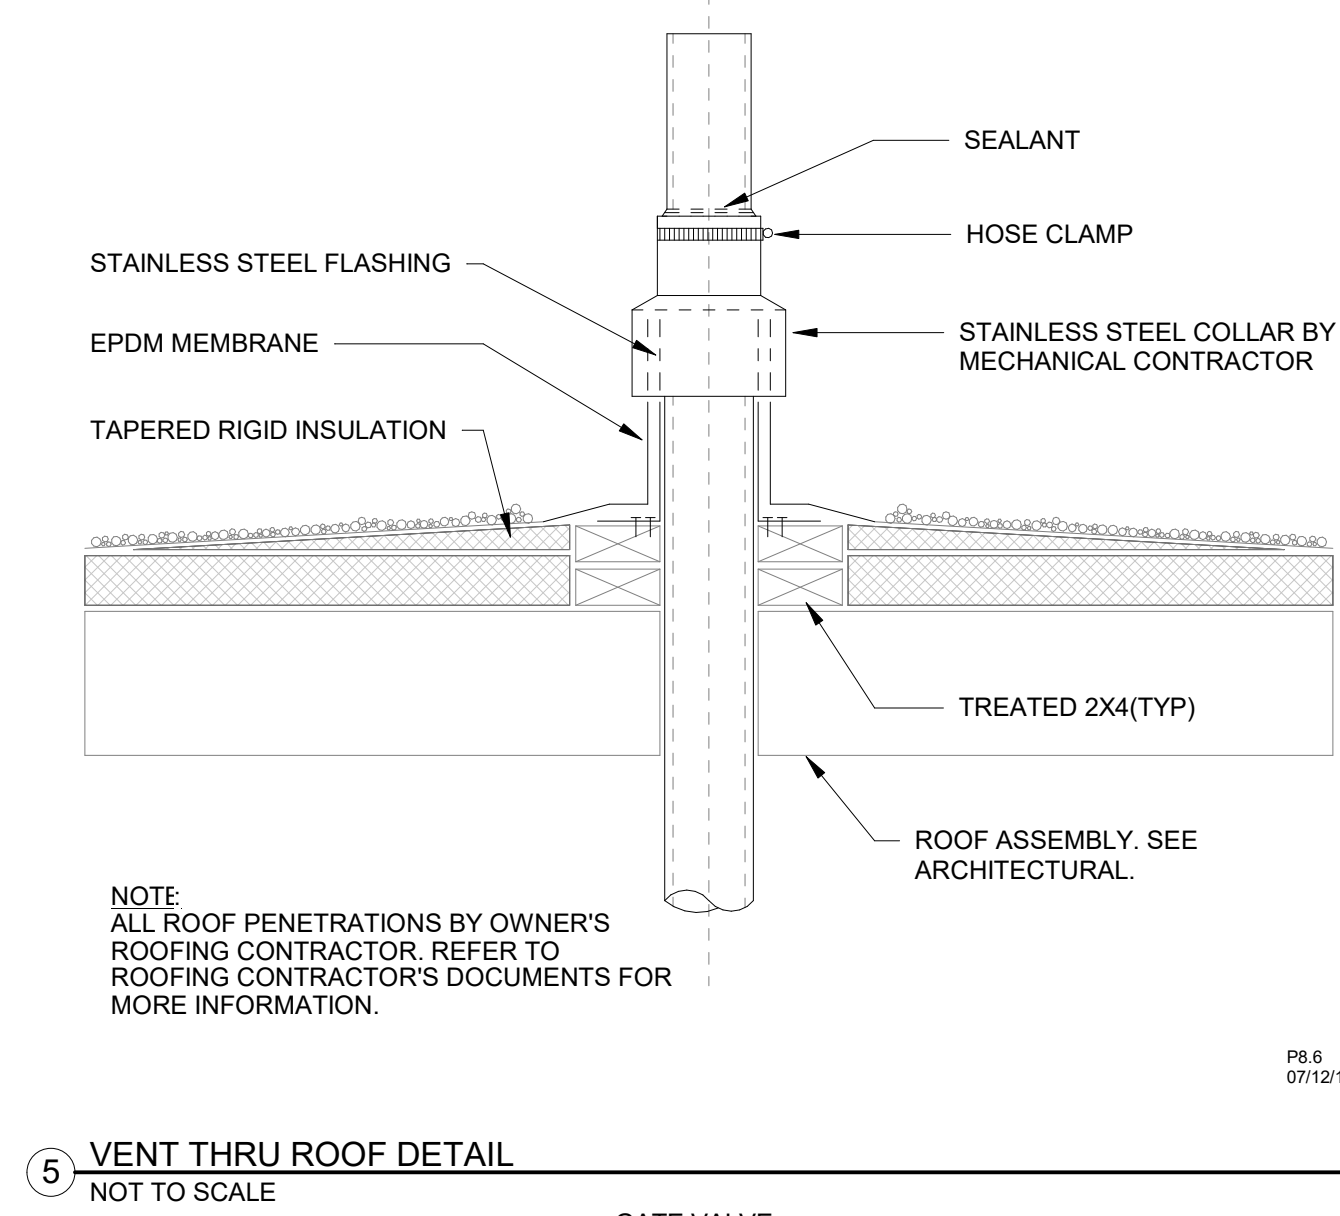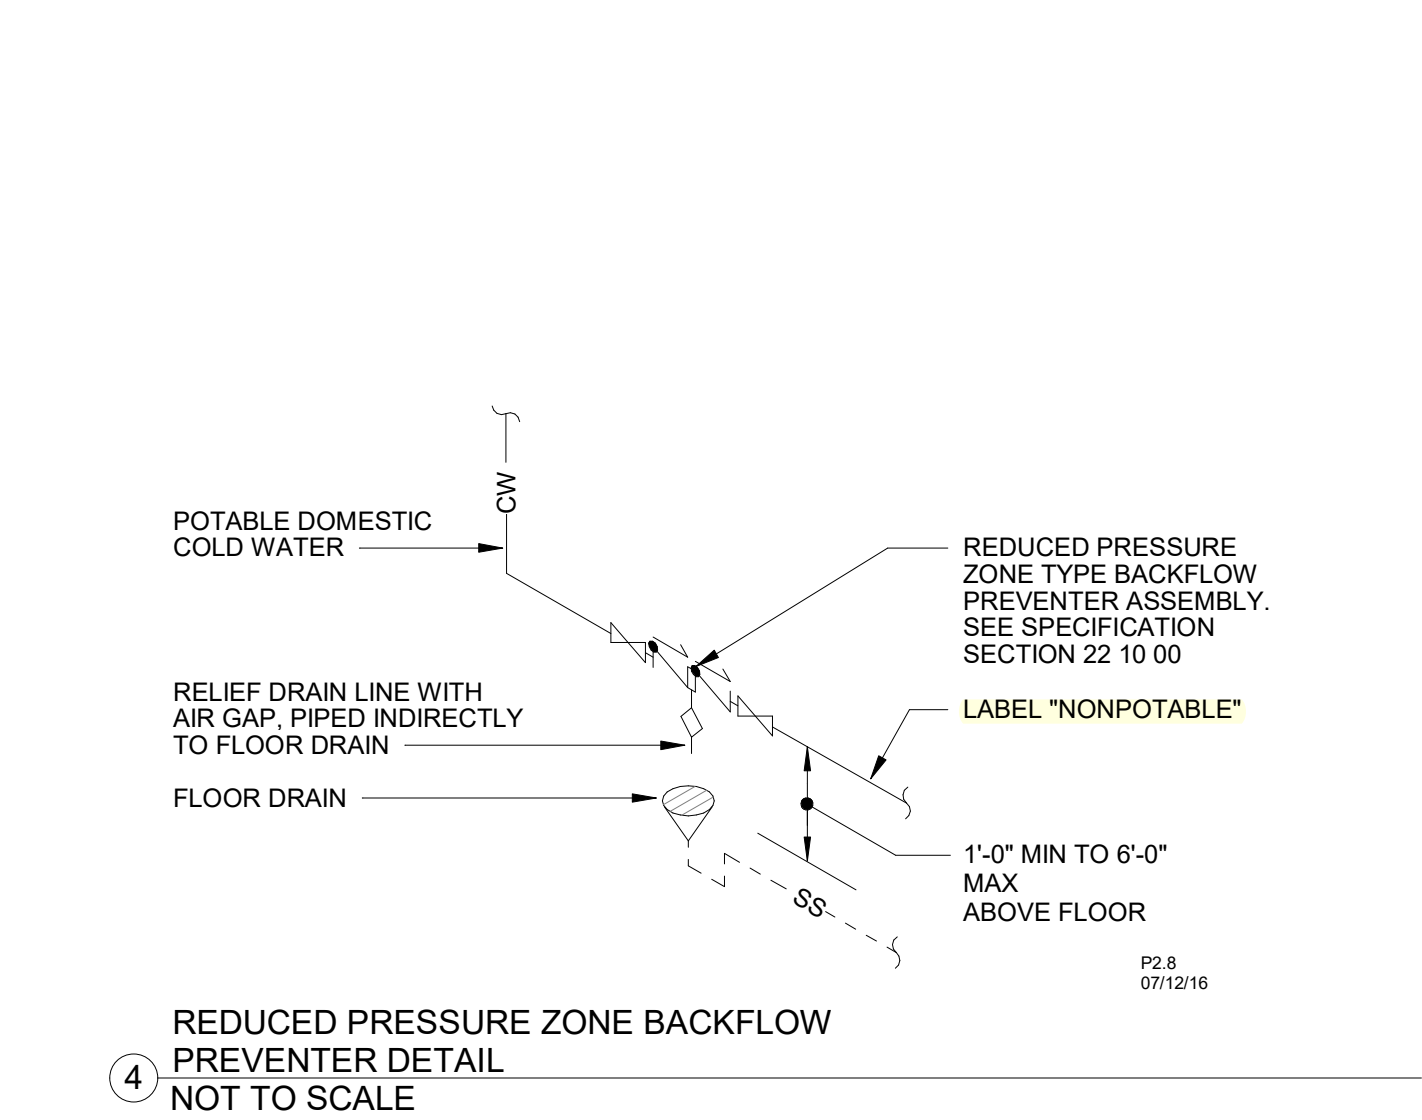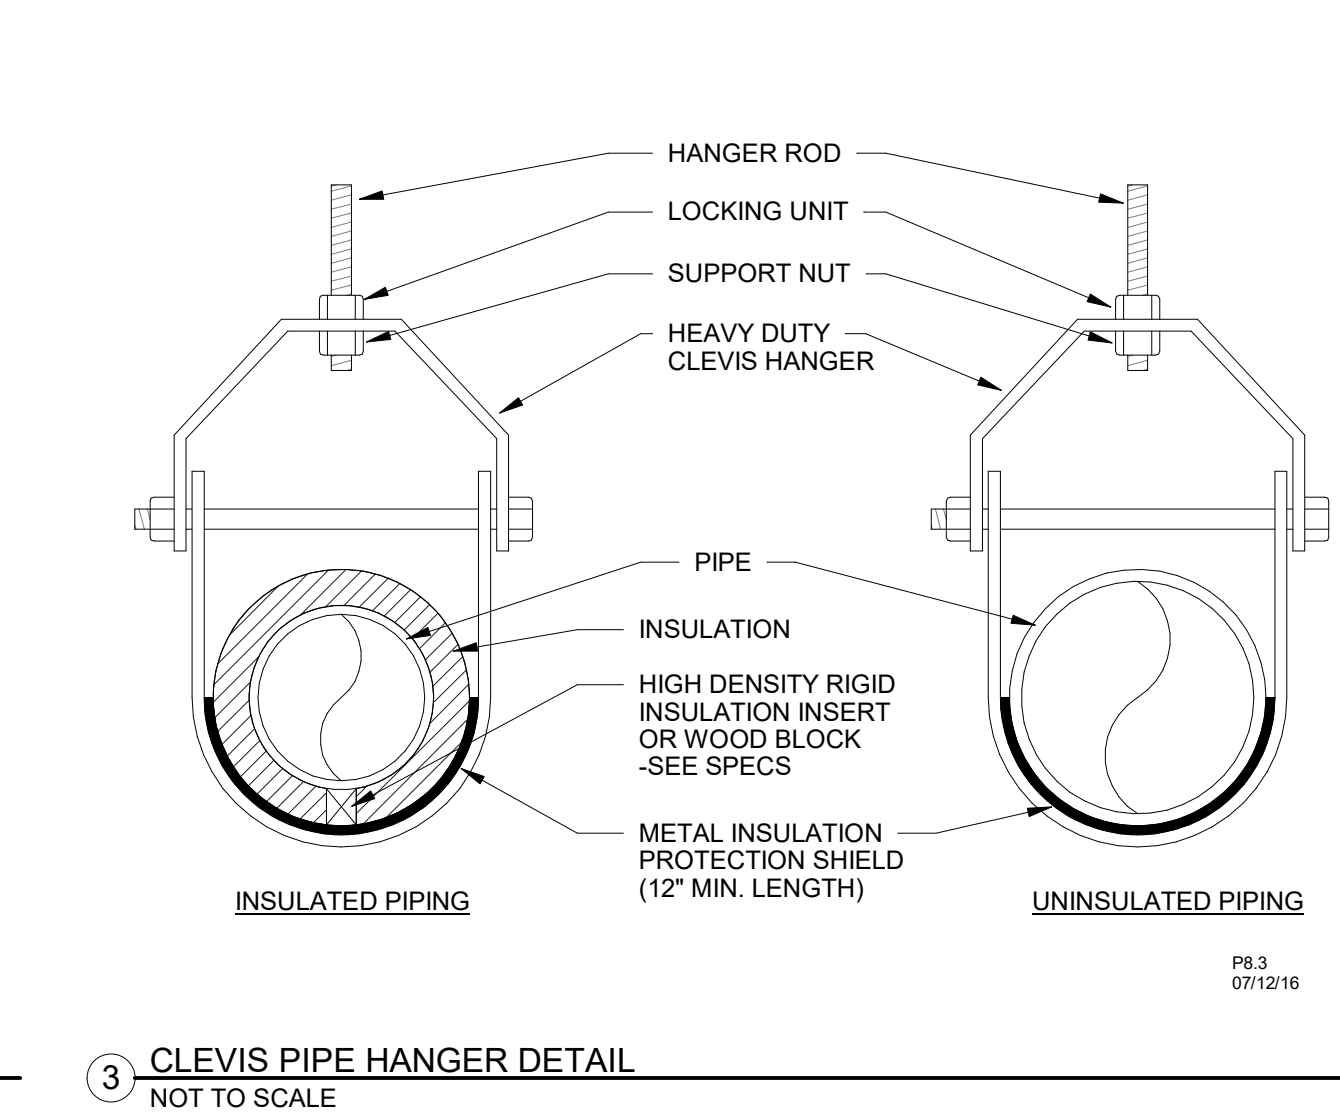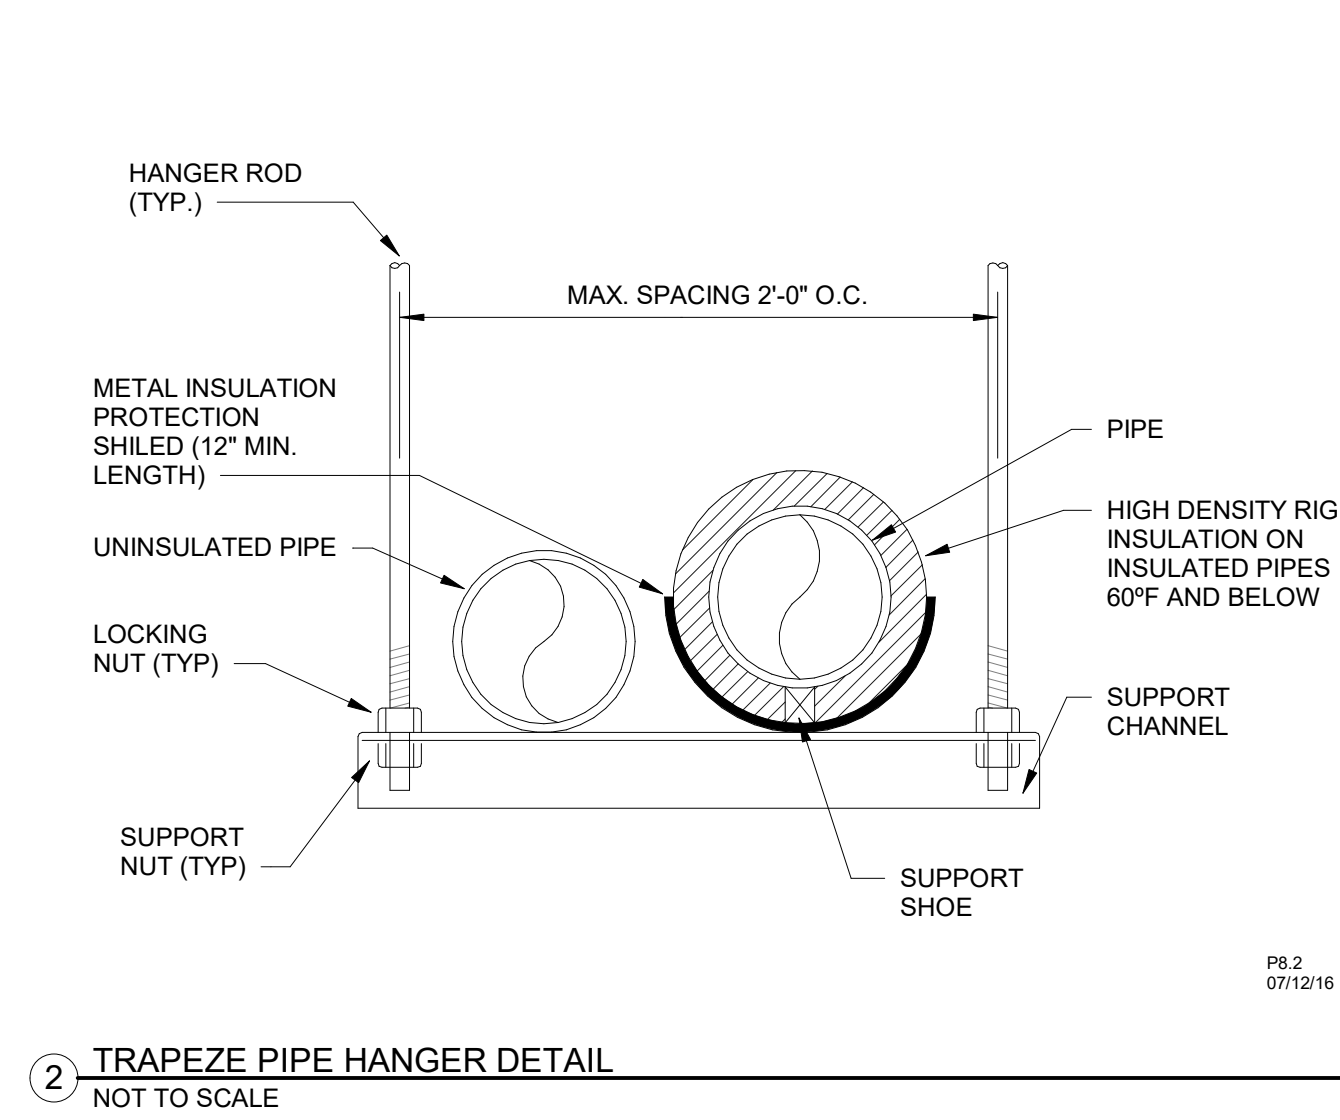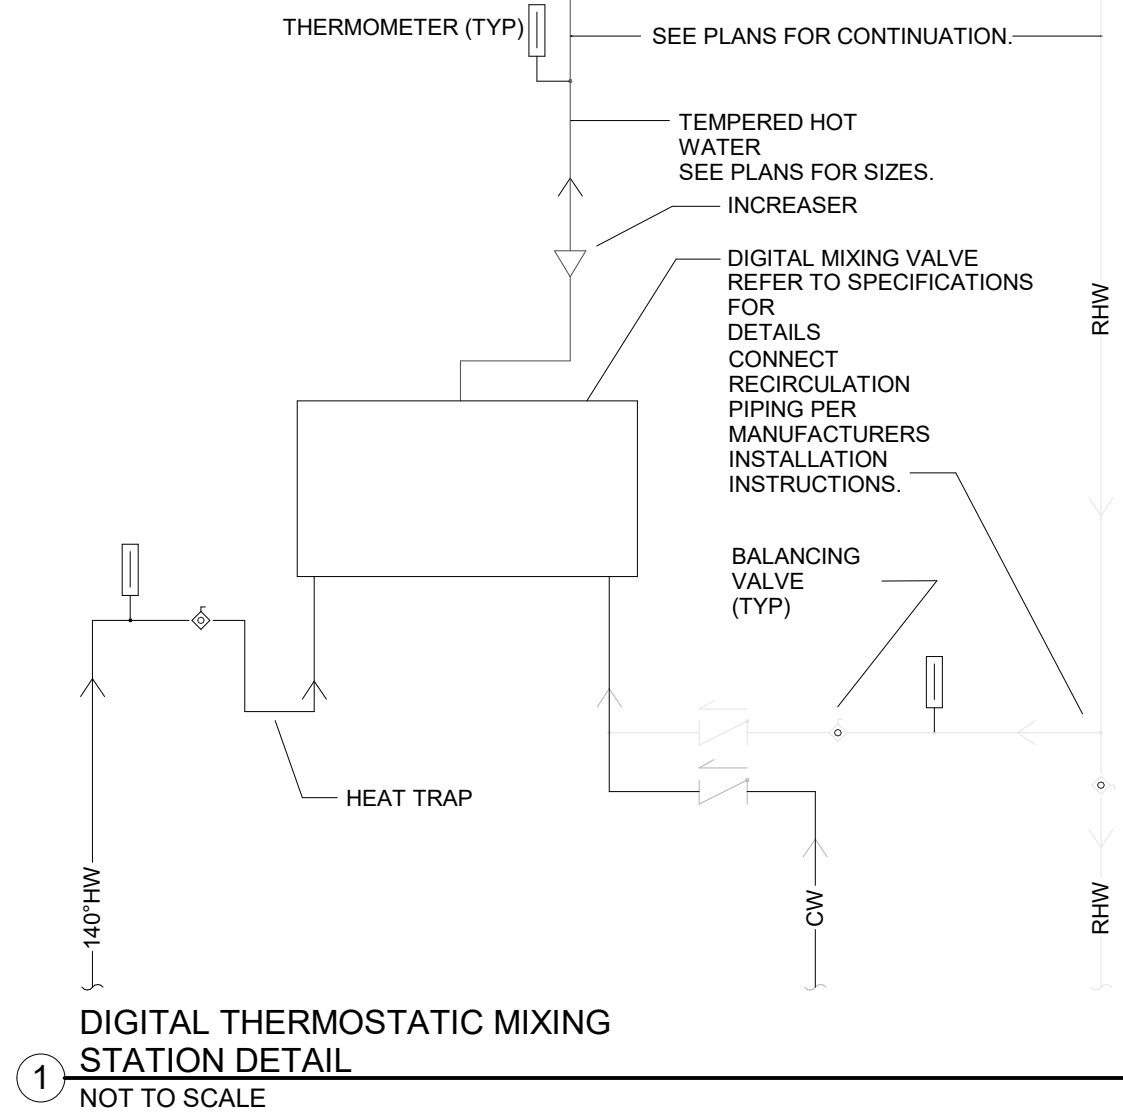

STEEN
ENGINEERING

763-585-6742
763-585-6757 fax
Email: steen@steeneng.com
5430 Douglas Drive North
Minneapolis, MN 55429

in = site
architects


1000 university ave. w. # suite 130
st. paul, minnesota 55104
612-252-4820



Mark R. Breneman
signature
Mark R. Breneman
Typed or Printed Name
Mechanical
Discipline
12/02/24
Date

WESLEY BRADLEY PARK PHASE 2 - CARE CENTER

707 39TH AVENUE SE
PUYALLUP, WA 98374

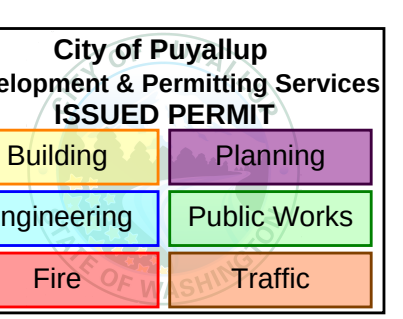

CARE CENTER
PERMIT SET
December 2, 2024

REVISIONS		
No.	Description	Date

ISA202201
PROJECT NUMBER
RDB RDB
DRAWN BY CHECKED BY
WESLEY BRADLEY PARK
PHASE 2 - CARE CENTER

MECHANICAL DETAILS
M5.3

FAN SCHEDULE																		
UNIT NO.	MANUFACTURER & MODEL NO.	LOCATION	SERVES	FAN DATA				MOTOR DATA			PANEL					NOTES		
				CFM	WEIGHT , LB	ESP (IN.WC)	FAN RPM	HP	RPM	V	PH	PANEL	CIRCUIT	CONDUIT	WIRE SIZE	BREAKER	MECH	ELEC
EF-1	GREENHECK SQ-90-VG	RESTROOMS	RESTROOMS	300	20	0.25	1100	FRAC	-	120 V	1	PP01	9	1/2"	#12	20/1	-	3
EF-2	GREENHECK SP-A125	POOL CHEM ROOM	POOL CHEM ROOM	80	20	0.25	1100	FRAC	-	120 V	1	PP01	3	1/2"	#12	20/1	-	3
EF-3	GREENHECK SQ-100-VG	POOL	POOL	1000	50	0.25	1325	1/4	120 V	1	PP01	2	1/2"	#12	15/1	1	3	
EF-4	GREENHECK G-090-E	ROOF	OXYGEN ROOM	250	60	0.25	1050	FRAC		120 V	1	LP11	22	1/2"	#12	20/1	-	3
KEF-1	GREENHECK CUE-100-A	ROOF	KITCHEN TYPE 1 HOOD	900	60	1.0	1725	1/3	120 V	1	KP11	30	1/2"	#12	20/1	-	2	
KEF-2	GREENHECK CUE-099-A	ROOF	KITCHEN CONDENSATE HOOD	600	170	1.0	1725	1/4	120 V	1	KP11	28	1/2"	#12	20/1	-	1	

MECHANICAL NOTES:

1. PROVIDE FAN WITH ALUMINUM HOUSING AND PLASTIC FAN WHEEL.

ELECTRICAL NOTES:

1. PROVIDE INTERLOCK WITH DISHWASHER SO THAT DISHWASHER DOES NOT OPERATE UNLESS FAN IS RUNNING. PROVIDE 0-30 MINUTE TIME DELAY RELAY, SET TO KEEP FAN RUNNING 10 MINUTES AFTER DISHWASHER STOPS.
2. INTERLOCK MUA WITH EF. CONNECT EF TO HEAT SENSOR, PROVIDED WITH KITCHEN HOOD, TO AUTOMATICALLY START MUA & EF UPON SIGNAL FROM HEAT SENSOR. PROVIDE OVERRIDE "ON" SWITCH WITH PILOT LIGHT NEAR HOOD TO MANUALLY START EQUIPMENT. SWITCH SHALL NOT PREVENT EF FROM RUNNING UPON SIGNAL FROM HEAT SENSOR. PROVIDE INTERLOCK WITH KITCHEN FIRE SUPPRESSION SYSTEM (KFSS) SO THAT KFSS ACTIVATION STOPS MUA. EF SHALL CONTINUE TO RUN UNTIL KFSS RESET.
3. RUNS CONTINUOUSLY.

MECHANICAL AND ELECTRICAL EQUIPMENT SCHEDULE GENERAL NOTES																	
A.	THE MECHANICAL CONTRACTOR SHALL PROVIDE ALL EQUIPMENT SCHEDULED.																
B.	THE ELECTRICAL CONTRACTOR SHALL PROVIDE POWER WIRING AND MAKE FINAL CONNECTION TO EACH PIECE OF EQUIPMENT SCHEDULED.																
C.	THE ELECTRICAL CONTRACTOR SHALL PROVIDE ALL STARTERS AND DISCONNECTS.																
D.	THE MECHANICAL CONTRACTOR SHALL PROVIDE ALL CONTROL DEVICES AS WELL AS ALL LINE VOLTAGE AND LOW VOLTAGE WIRING NECESSARY TO INSTALL AND MAKE FULLY OPERATIONAL SPECIFIED CONTROL SYSTEMS, UNLESS NOTED OTHERWISE.																
E.	THE ELECTRICAL CONTRACTOR SHALL PROVIDE ALL SINGLE PHASE LINE VOLTAGE CONTROL DEVICES, SUCH AS 120/208/240 VOLT THERMOSTATS, SWITCHES AND TIME CLOCKS DIRECTLY CONTROLLING EXHAUST FANS, UNIT HEATERS, ETC., INCLUDING ALL ELECTRICAL MATERIALS AND FINAL CONNECTIONS.																
F.	THE ELECTRICAL CONTRACTOR SHALL PROVIDE 120V JUNCTION BOX OR RECEPTACLES ADJACENT TO WATER HEATERS, SUMP PUMPS AND WATER SOFTENERS.																
G.	MECHANICAL CONTRACTOR SHALL PROVIDE EQUIPMENT AFFIXED WITH A VISIBLE NAMEPLATE MARKED WITH THE SHORT CIRCUIT CURRENT RATING (SCCR) TO COMPLY WITH SECTION 440.4(B) OF THE LATEST ADOPTED NEC. MINIMUM EQUIPMENT SCCR SHALL BE 5,000 AIC, UNLESS NOTED OTHERWISE.																

STEEN
ENGINEERING

763-585-6742
763-585-6757 fax
Email: steen@steeneng.com

5430 Douglas Drive North
Minneapolis, MN 55429



Richard D. Becker
Signature

Richard D. Becker
Typed or Printed Name

Electrical
Discipline

12/02/24
Date

in = site
architects

1000 university ave. w. suite 130
st. paul, minnesota 55104
612-252-4820



Mark R. Brennan
Signature

Mark R. Brennan
Typed or Printed Name

Mechanical
Discipline

12/02/24
Date

ELECTRIC DUCT COIL SCHEDULE																						
UNIT NO.	MANUFACTURER & MODEL NO.	LOCATION	SERVES	COIL DATA									ELECTRIC			PANEL					NOTES	
				CFM	PD (”WC)	SIZE		VEL (FPM)	EAT (°F)	LAT (°F)	CAP MBH	TEMP RISE	KW	V	PH	PANEL	CIRCUIT	CONDUIT	WIRE SIZE	BREAKER SIZE	MECH	ELEC
						LENGTH (IN)	WIDTH (IN)															
EDC-1	THERMOLEC MSCD-20LS	POOL MECH	POOL	6000		2'-2"	2'-2"		19 °F	86	187	30 °F	55	208 V	3	DP01	14,16,18	2"	#3/0	200/3	1	-

MECHANICAL NOTES:

1. DUCT HEATER TO BE CONTROLLED BY 0-10 VDC INCLUDED WITH SERESCO UNIT.

CONDENSING UNIT SCHEDULE (POOL)																	
UNIT NO.	MANUFACTURER & MODEL NO.	LOCATION	SERVES	COOLING DATA		MOTOR DATA				PANEL					NOTES		
				TONS	SEER	MCA	HP	V	PH	PANEL	CIRCUIT	CONDUIT	WIRE SIZE	BREAKER	MECH	ELEC	
DHU-1A-CU	SERESCO NC-Z-1V	WEST EXTERIOR	POOL	5	-	5	1.6	208 V	3	PP01	12, 14, 16	1/2"	#12	20/3	-	-	
DHU-1B-CU	SERESCO NC-Z-1V	WEST EXTERIOR	POOL	5	-	5	1.6	208 V	3	PP01	12, 14, 16	1/2"	#12	20/3	-	-	

POOL DEHUMIDIFICATION UNIT SCHEDULE																											
UNIT NO.	MANUFACTURER & MODEL NO.	LOCATION	SERVES	FAN DATA				COOLING DATA						HEATING DATA		MOTOR DATA				PANEL						NOTES	
				CFM	MIN OSA OA	ESP ("WC)	FAN TYPE	REFR	STAGES	MIN MOIST REMOVAL (#/HR)	SPACE TEMP (F)	HUMD RANGE (%RH)	TOTAL (MBH) (MBH)	SENS (MBH) (MBH)	TYPE	MBH	MCA	HP	V	PH	PANEL	CIRCUIT	CONDUIT	WIRE SIZE	BREAKER	MECH	ELEC
DHU-1	SERESCO NE-210-PS-1	POOL STORAGE	POOL	5600	1400 CFM	1.0	DIRECT DRIVE	R-410A	2	66.4	86	60	150.4	78.6	-	-	56	(2) 2.1	208 V	3	PP01	18,20,22	1"	#6	60/3	1,2	

MECHANICAL NOTES:

1. POOL DEHUMIDIFICATION UNIT INCLUDES FACTORY EQUIPPED POOL HEATING CONNECTIONS. POOL CONTRACTOR TO PROVIDE AND INSTALL POOL HEATING INDEPENDENT OF DHU-1.
2. POOL DEHUMIDIFICATION UNIT AIR TO BE HEATED BY ELECTRIC DUCT HEATER (EDC-1) INSTALLED DOWNSTREAM OF UNIT SUPPLY.

MAKE UP AIR UNIT SCHEDULE																				
UNIT NO.	MANUFACTURER & MODEL NO.	LOCATION	AREA SERVED	FAN DATA			ELEC HEATING DATA		MOTOR DATA					PANEL					NOTES	
				CFM	ESP (IN. WC)	FAN RPM	MBH	KW @ 208	MCA	HP	RPM	V	PH	PANEL	CIRCUIT	CONDUIT	WIRE SIZE	BREAKER	MECH	ELEC
KMUA-1	GREENHECK IGX-P109-H12-MF-C	ROOF	KITCHEN	800	1.0	1442	42.5	12.5	55	1/2	1725	208 V	3	KP11	22,24,26	1/2"	#12	15/3	1,2,3	1,2

MECHANICAL NOTES:

1. PROVIDE VFD.
2. INTERLOCK WITH TYPE 1 EXHAUST HOOD.
3. 8 STAGE TURNDOWN

ELECTRICAL NOTES:

1. EQUIPMENT CONTAINS INTEGRAL VFD(S). FEEDER SHALL BE COPPER; ALUMINUM IS NOT APPROVED FOR SUBSTITUTION.
2. PROVIDE INTERLOCK WITH KITCHEN FIRE SUPPRESSION SYSTEM (KFSS) SO THAT KFSS ACTIVATION STOPS MOTOR. MOTOR SHALL NOT START UNTIL KFSS IS RESET.

ELECTRIC HEATER SCHEDULE														
UNIT NO.	MANUFACTURER & MODEL NO.	DESCRIP.	AREA SERVED	HEATING COIL DATA				PANEL				NOTES		
				TOTAL WATTS	TOTAL (BTUH)	V	PH	PANEL	CIRCUIT	CONDUIT	WIRE SIZE	BREAKER	MECH	ELEC
ERH-A	BERKO CP751	ELECTRIC HEATER	SEE PLANS	750	2,560	120 V	1	<varies>	<varies>	1/2"	#12	15/1		1.2
FF-A	BERKO FRC-4024	ELECTRIC HEATER	SEE PLANS	3000	10,239	208 V	1	<varies>	<varies>	1/2"	#12	20/2		1

MECHANICAL NOTES:

1. EQUIPMENT FURNISHED BY MECHANICAL CONTRACTOR, INSTALLED BY ELECTRICAL CONTRACTOR.

ELECTRICAL NOTES:

1. EQUIPMENT FURNISHED BY MECHANICAL CONTRACTOR, INSTALLED BY ELECTRICAL CONTRACTOR. COORDINATE LOCATIONS WITH MECHANICAL CONTRACTOR PRIOR TO ROUGH-IN.
2. PROVIDE WALL MOUNTED 60 MINUTE TIMER SWITCH WITH COVERPLATE. COVERPLATE COLOR SHALL MATCH ADJACENT SWITCHES. LEVITON #LTB60-1L OR EQUAL.

ROOFTOP WITH ENERGY RECOVERY																					
UNIT NO.	MANUFACTURER & MODEL NO.	LOCATI ON	SERVES	FAN DATA								ENERGY WHEEL (SUPPLY SIDE)								ENERGY WHEEL EFF	
				AIRFLOW		ESP		TSP		FAN RPM		WINTER				SUMMER					
				SUP CFM	RET CFM	SUP ("WC)	RET ("WC)	SUP ("WC)	RET ("WC)	SUP	RET	EAT °F		LAT °F		EAT°F		LAT °F			
				DB	WB	DB	WB	DB	WB	DB	WB	DB	WB	DB	WB	DB	WB	SUM %	WINT %		
ERV-1	GREENHECK RVE-150-74D-0-0-A1	ROOF	BASMENT + LEVEL 1 NORTH	4500 CFM	4500	2.0	2.0	4.122	3.007	1706	1596	19 °F	16 °F	55 °F	45 °F	86 °F	66 °F	78 °F	63 °F	74.1	73.8
ERV-2	GREENHECK RVE-40-41D-0-J-A1	ROOF	LEVEL 1 SOUTH	5000 CFM	5000	2.0	2.0	4.969	3.731	2510	2399	19 °F	16 °F	49 °F	41 °F	86 °F	66 °F	80 °F	64 °F	73.3	73.1

ROOFTOP WITH ENERGY RECOVERY CONTD																					
UNIT NO.		ENERGY WHEEL (RETURN SIDE)								ENERGY WHEEL EFF		MOTOR DATA			PANEL					NOTES	
		WINTER				SUMMER				SUM %	WINT %	MCA	V	PHASE	PANEL	CIRCUIT	CONDUIT	WIRE SIZE	BREAKER	MECH	ELEC
		EAT °F		LAT °F		EAT °F		LAT °F													
		DB	WB	DB	WB	DB	WB	DB	WB												
ERV-1		70 °F	52.9 °F	33.7 °F	29.1 °F	75 °F	62.5 °F	83.8 °F	65.1 °F	73.3	73.1	38.7	208 V	3	LP11	42,44,46	3/4"	#8	40/3	1,2,3,4	1
		72 °F	55.8 °F	40.7 °F	35.5 °F	75 °F	62.5 °F	81.4 °F	65.2 °F												

HEAT PUMP DOMESTIC WATER HEATER SCHEDULE																
UNIT NO.	MANUFACTURER & MODEL NO.	LOCATION	SERVICE	MAX TEMP RISE (DEG. F)	COP	OUTPUT AT 25°F AMBIENT (MBH)	ELECTRICAL			PANEL				NOTES		
							MCA	V	PH	PANEL	CIRCUIT	CONDUIT	WIRE SIZE	BREAKER	MECH	ELEC
WH-1	AO SMITH APHA280	ROOF	RESIDENTIAL FIXTURES	15	4.27	150	87.5	208 V	3	DP02	8,10,12	1-1/4"	#6	100/3	1,2,3,4	1,2,3
WH-2	AO SMITH APHA280	ROOF	RESIDENTIAL FIXTURES	15	4.27	150	87.5	208 V	3	DP02	14,16,18	1-1/4"	#6	100/3	1,2,3,4	1,2,3
WH-3	AO SMITH APHA280	ROOF	RESIDENTIAL FIXTURES	15	4.27	150	87.5	208 V	3	DP02	20,22,24	1-1/4"	#6	100/3	1,2,3,4	1,2,3
WH-4	AO SMITH APHA200	ROOF	KITCHEN	15	4.44	105	66.25	208 V	3	DP02	19,21,23	1-1/4"	#6	80/3	1,2,3	1,2,3

MECHANICAL NOTES:

1. PROVIDE MANUFACTURERS MANIFOLD KIT WITH PUMP.
2. FURNISH MANUFACTURERS 480V TO 208V TRANSFORMER.
3. PROVIDE UNIT WITH SINGLE POINT POWER CONNECTION OPTION.
4. INTERCONNECT UNITS TO ALLOW UNITS TO CASCADE.

ELECTRICAL NOTES:

1. PROVIDE DEDICATED CIRCUIT.
2. INSTALL MANUFACTURERS TRANSFORMER FURNISHED BY PLUMBING CONTRACTOR. PROVIDE REQUIRED WIRING BETWEEN TRANSFORMER AND UNIT.
3. MCA LISTED IS AT 480V. PROVIDE BRANCH CIRCUIT SIZED FOR 208V.

SUMP PUMP SCHEDULE																	
UNIT NO.	MANUFACTURER & MODEL NO.	LOCATION	SERVICE	GPM	HEAD (FT. WC)	BASIN		MOTOR DATA				PANEL				NOTES	
						DIA. (IN)	DEPTH (IN)	MCA	HP	RPM	V	PH	PANEL	CIRCUIT	CONDUIT	WIRE SIZE	BREAKER
SP-1	WEIL 1411	MECH 0103	ELEVATOR PIT DRAIN	50	20	24	108		1/2	1750	120 V	1	LP01	12	1/2"	#12	20/1
SP-2	WEIL 1408	MECH 0103	ELEVATOR PIT DRAINTILE	20	20	24	108		1/3	1750	120 V	1	LP01	14	1/2"	#12	15/1
SP-3	WEIL 1411	MECH 0103	BUILDING DRAIN TILE	40	15	24	60		1/2	1750	120 V	1	LP01	16	1/2"	#12	20/1
SP-4	WEIL 1411	POOL MECH 0116	POOL DECK DRAINS	35	15	24	72		1/2	1750	120 V	1	PP01	4	1/2"	#12	20/1
SP-5	WEIL 1411	MECH 0103	LOWER LEVEL DRAINS	40	20	36	72		1/2	1750	120 V	1	LP01	18	1/2"	#12	20/1

MECHANICAL NOTES:

1. REFER TO SPECIFICATIONS FOR FURTHER DETAILS.
2. DUPLEX PUMPS. PUMPS SHALL ALTERNATE OPERATION.

ELECTRICAL NOTES:

1. PROVIDE WIRING FROM CONTROL PANEL TO PUMPS.

DIGITAL MIXING VALVE SCHEDULE																			
FIXTURE TYPE	MANUFACTURER & MODEL #	LOCATION	SERVES	GPM	PRESSURE DROP	INLET CONNECTION	OUTLET CONNECTION	MINIMUM FLOW	MINIMUM RECIRCULATION FLOW	MOTOR DATA			PANEL					NOTES	
										V	PHASE	KVA	PANEL	CIRCUIT	CONDUIT	WIRE SIZE	BREAKER	MECH	ELEC
MOV-1	POWERS IS2150F	MECH 0103	RESIDENTIAL FIXTURES	65	5.00 psi	2"	3"	0 GPM	3 GPM	120 V	1	1000 VA	LP01	33	1/2"	#12	20/1	1	1

MECHANICAL NOTES:

1. REFER TO PLUMBING SPECIFICATIONS FOR FURTHER DETAILS.

ELECTRICAL NOTES:

1. PROVIDE DEDICATED CIRCUIT FROM PANEL LP01.

DOMESTIC CIRCULATION PUMP SCHEDULE																
UNIT NO.	MANUFACTURER & MODEL NO.	LOCATION	SERVICE	GPM	HEAD (FT. WC)	MOTOR				PANEL				NOTES		
						HP	RPM	V	PH	PANEL	CIRCUIT	CONDUIT	WIRE SIZE	BREAKER	MECH	ELEC
CP-1	B&G ECO CIRC XL N 55-45	MECH 0103	RESIDENTIAL FIXTURES	22	25	1/2	VAR	120 V	1	LP01	32	1/2"	#12	20/1	1	1
CP-2	B&G NBF-45	MECH 0103	KITCHEN/LAUNDRY	2	10	FRAC	3300	120 V	1	LP01	34	1/2"	#12	20/1	2	2
CP-3	B&G ECO CIRC XL N 20-140	MECH 0103	RESIDENTIAL FIXTURES	55	5	1/2	VAR	208 V	1	DP02	2.4	1/2"	#12	20/1	1	1
CP-4	B&G PL45	MECH 0103	RESIDENTIAL FIXTURES	15	5	1/6	3300	120 V	1	DP02	6	1/2"	#12	20/1	1	1

MECHANICAL NOTES:

1. RUNS CONTIOUSLY.
2. CONTROLLED BY AQUASTAT.

ELECTRICAL NOTES:

1. ECM MOTOR. PROVIDE NEUTRAL CONDUCTOR WITH PHASE CONDUCTORS. PROVIDE TIME CLOCK FOR OPERATION. SET TIME CLOCK TO OPERATING HOURS.

ELECTRIC DOMESTIC WATER HEATER SCHEDULE																
UNIT NO.	MANUFACTURER & MODEL NO.	LOCATION	SERVICE	MAX TEMP RISE (DEG. F)	STORAGE (GAL)	RECOVERY (GPH)	ELECTRICAL			PANEL				NOTES		
							KW	V	PH	PANEL	CIRCUIT	CONDUIT	WIRE SIZE	BREAKER	MECH	ELEC
WH-5	AO SMITH DSE-65-75	MECH 0103	WH-1/2/3 BACKUP	95	65	341	75	208 V	3	DP02	1,3,5	2-1/2"	#350	300/3		
WH-6	AO SMITH DSE-65-75	MECH 0103	WH-1/2/3 BACKUP	95	65	341	75	208 V	3	DP02	7,9,11	2-1/2"	#350	300/3		
WH-7	AO SMITH DVE-52-40.5	MECH 0103	WH-4 BACKUP	115	52	151	40.5	208 V	3	DP02	13,15,17	1-1/2"	#1/0	150/3		

FAN COIL UNIT SCHEDULE (VRF)																	
UNIT NO.	MANUFACTURER & MODEL NO.	SERVES	FAN DATA			COOLING DATA	HEATING DATA	MOTOR DATA			PANEL				NOTES		
			CFM	OA CFM	ESP (IN. WC)	TOTAL (MBH)	MBH	MCA	V	PH	PANEL	CIRCUIT	CONDUIT	WIRE SIZE	BREAKER	MECH	ELEC
FC-1	MITSUBISHI TRANE TPEFY024MA144A	OFFICE 0125	800	0 CFM	0.3	24	27	2.88	208 V	1	LP01	28.30	1/2"	#12	20/2	2	-
FC-2	MITSUBISHI TRANE TPEFY030MA144A	STAFF BREAK 0123	1000	230 CFM	0.3	30	34	2.88	208 V	1	LP01	28.30	1/2"	#12	20/2	2	-
FC-3	MITSUBISHI TRANE TPEFY024MA144A	EDUCATION 0121	800	210 CFM	0.3	24	27	2.88	208 V	1	LP01	28.30	1/2"	#12	20/2	2	-
FC-4	MITSUBISHI TRANE TPEFY009MA144A	MED RECORDS 0120	330	65 CFM	0.3	9	9	2.88	208 V	1	LP01	28.30	1/2"	#12	20/2	2	-
FC-5	MITSUBISHI TRANE TPEFY012MA144A	RES STORAGE 0105	400	270 CFM	0.3	12	13	2.88	208 V	1	LP01	28.30	1/2"	#12	20/2	2	-
FC-6	MITSUBISHI TRANE TPEFY012MA144A	CORRIDOR E0107	400	0 CFM	0.3	12	13	2.88	208 V	1	LP01	28.30	1/2"	#12	20/2	2	-
FC-7	MITSUBISHI TRANE TPEFY024MA144A	DAYROOM 1168	800	320 CFM	0.3	24	27	2.88	208 V	1	LP11	30.32	1/2"	#12	20/2	2	-
FC-8	MITSUBISHI TRANE TPEFY024MA144A	NORTH CORRIDOR	800	365 CFM	0.3	24	27	2.88	208 V	1	LP11	30.32	1/2"	#12	20/2	2	-
FC-9	MITSUBISHI TRANE TPEFY024MA144A	CORRIDOR 1158	800	0 CFM	0.3	24	27	2.88	208 V	1	EOSLP02	14.16	1/2"	#12	20/2	2	-
FC-10	MITSUBISHI TRANE TPEFY024MA144A	CONF ROOM E101	800	150 CFM	0.3	24	27	2.88	208 V	1	EOSLP02	14.16	1/2"	#12	20/2	2	-
FC-11	MITSUBISHI TRANE TPEFY024MA144A	CORRIDOR 1158	800	0 CFM	0.3	24	27	2.88	208 V	1	EOSLP02	14.16	1/2"	#12	20/2	2	-
FC-12	MITSUBISHI TRANE TPEFY012MA144A	SPA/SALON 1151	600	0 CFM	0.3	18	20	2.88	208 V	1	EOSLP02	14.16	1/2"	#12	20/2	2	-
FC-13	MITSUBISHI TRANE TPEFY036MA144A	SERVING KITCHEN 1144	1200	0 CFM	0.3	36	40	2.88	208 V	1	LP11	34.36	1/2"	#12	15/2	1,2	-
FC-14	MITSUBISHI TRANE TPEFY030MA144A	THERAPY 1134	1000	235 CFM	0.3	30	34	2.88	208 V	1	LP11	34.36	1/2"	#12	15/2	1,2	-
FC-15	MITSUBISHI TRANE TPEFY036MA144A	DINING 1133	1200	285 CFM	0.3	36	40	2.94	208 V	1	LP12	44.46	1/2"	#12	15/2	2	-
FC-16	MITSUBISHI TRANE TPEFY030MA144A	THERAPY 1134	1000	235 CFM	0.3	30	34	2.94	208 V	1	LP12	44.46	1/2"	#12	15/2	2	-
FC-17	MITSUBISHI TRANE TPEFY036MA144A	CHAPEL 1113	1200	0 CFM	0.3	36	40	2.94	208 V	1	LP12	44.46	1/2"	#12	15/2	2	-
FC-18	MITSUBISHI TRANE TPEFY036MA144A	COMMONS 1101	1200	0 CFM	0.3	36	40	2.94	208 V	1	LP12	44.46	1/2"	#12	15/2	2	-
FC-19	MITSUBISHI TRANE TPEFY012MA144A	OFFICE 1106	800	180 CFM	0.3	18	20	2.94	208 V	1	LP12	44.46	1/2"	#12	15/2	2	-
FC-20	MITSUBISHI TRANE TPEFY018MA144A	DIRECTOR 1111	600	170 CFM	0.3	18	20	2.94	208 V	1	LP12	44.46	1/2"	#12	15/2	2	-
FC-21	MITSUBISHI TRANE TPEFY024MA144A	NURSE 1122	800	100 CFM	0.3	24	27	2.94	208 V	1	LP12	48.50	1/2"	#12	15/2	2	-
FC-22	MITSUBISHI TRANE TPEFY030MA144A	DAYROOM 1129	1200	220 CFM	0.3	36	40	2.94	208 V	1	LP12	48.50	1/2"	#12	15/2	2	-
FC-23	MITSUBISHI TRANE TPMFY006BM140F	OFFICE 1131	300	0 CFM	0.3	18	20	2.94	208 V	1	LP12	48.50	1/2"	#12	15/2	2	-
FC-24	MITSUBISHI TRANE TPEFY012MA144A	LAUNDRY 1116	400	100 CFM	0.3	12	13	2.94	208 V	1	LP12	48.50	1/2"	#12	15/2	2	-
FC-25	MITSUBISHI TRANE TPEFY012MA144A	LAUNDRY 1116	400	100 CFM	0.3	12	13	2.88	208 V	1	EOSLP02	14.16	1/2"	#12	15/2	1,2	-
FC-A	MITSUBISHI TRANE TPMFY006BM140F	1 BED RESIDENT RM	330	0 CFM	-	8	9	0.25	208 V	1			1/2"	#12	20/2	2	1
FC-B	MITSUBISHI TRANE TPMFY006BM140F	2 BED RESIDENT RM	300	0 CFM	-	6	6.7	0.25	208 V	1			1/2"	#12	20/2	2	1

MECHANICAL NOTES:

1. SHALL BE ON EMERGENCY POWER.
2. REFER TO VRF PIPING DIAGRAMS ON M5.1 & M5.2 FOR FULL DIAGRAM, INCLUDING REFRIGERANT PIPE SIZING.

ELECTRICAL NOTES:

1. REFER TO PLANS FOR CIRCUITING.

CONDENSING UNIT SCHEDULE																
UNIT NO.	MANUFACTURER & MODEL NO.	LOCATION	SERVES	COOLING DATA			MOTOR DATA			PANEL					NOTES	
				TONS	MBH	EER	MCA	V	PH	PANEL	CIRCUIT	CONDUIT	WIRE SIZE	BREAKER	MECH	ELEC
CU-1	MITSUBISHI TRANE TURYE2163AN11AN	WEST EXTERIOR	FC-1, FC-2, FC-3, FC-4, FC-5, FC-6, FC-7,FC-8, FC-A, FC-B	18	216	20.5	88	208 V	3	LP01	36,38,40	1-1/4"	#3	100/3	2	-
CU-2	MITSUBISHI TRANE TURYE2163AN11AN	WEST EXTERIOR	FC-9, FC-10, FC-11, FC-12, FC-25, FC-A	18	216	20.5	88	208 V	3	EOSLP01	7,9,11	1-1/4"	#3	100/3	1,2	-
CU-3	MITSUBISHI TRANE TURYE2163AN11AN	WEST EXTERIOR	FC-13, FC-14, FC-15, FC-16, FC-17, FC-18, FC-19, FC-20	18	216	20.5	88	208 V	3	DP01	2,4,6	1-1/4"	#3	100/3	2	-
CU-4	MITSUBISHI TRANE TURYE2163AN11AN	WEST EXTERIOR	FC-21, FC-22, FC-23, FC-24, FC-A	18	216	20.5	88	208 V	3	DP01	8,10,12	1-1/4"	#3	100/3	2	-