

SITE PLAN

The approved construction plans, documents, and all engineering must be posted on the job at all inspections in a visible and readily accessible location.

Full sized legible color plans are required to be provided by the permittee on site for inspection.

Approval of submitted plans is not an approval of omissions or oversights by this office or non compliance with any applicable regulations of local government. The contractor is responsible for making sure that the building complies with all applicable codes and regulations of the local government.



SIGN LOCATION

SIGNAGE SPECIFICATIONS



CHANNEL LETTERS ON RACEWAY

WHITE ACRYLIC FACE
VINYL OVERLAY
BLACK TRIM
CAP AND BLACK
RETURN 040 ALUMINUM



SIGN ALLOWABLE


32 sq. ft.

1 sq. ft to 1 lineal foot
to store front




SIGN TOTAL SQ. FT = 31.67

SIGN WEIGHT = 55LBS

AREA MAP

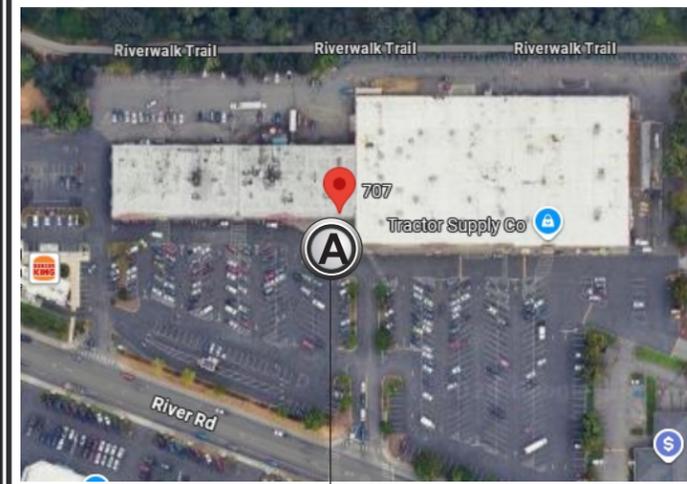

SIGN LOCATION

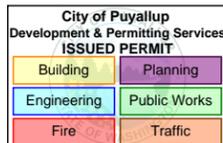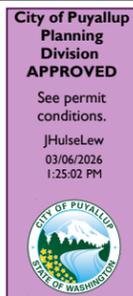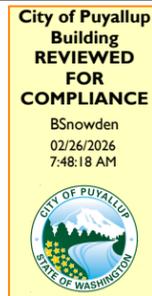

**707 RIVER ROAD
PUYALLUP, WA 98391**

per FMC 22.26.012 (c,2)
**INTERNALLY LED ILLUMINATED
LIGHT OUT WILL NOT EXCEED
100 NITS.**

per FMC 22.26.012 (d)
**15AMP IN-WALL 3-WAY DAYLIGHT
ADJUSTING DIGITAL
TIMER SWITCH WITH
SCREW TERMINALS
MANUFACTURE: DEFIANT**

**ALL PENTRATION MUST BE SEALED
IN A WATERTIGHT MANNER.
(SILICONE)**

ELECTRICAL

SIGN WILL BE ILLUMINATED
WITH HANLEY 1 WATT PER
MODULE LED WHITE WITH
60 WATTS
POWER SUPPLY CLASS 2
1 @ 20 amp sign circuit
110v

UL LABEL WILL BE PLACE
ON THE SIDE OF THE RACEWAY
BEHIND THE LOGO
NO VISIBLE TO THE PUBLIC

Separate Electrical Permit is required with the Washington State Department of Labor & Industries.



WHOLESALE SIGN MANUFACTURER
**7808 RIVER ROAD EAST
PUYALLUP, WA 98371**
206-468-3999 253-236-8074



Date: _____
Salesperson: TL
Coordinator: TL
Designer: JT
Scale: 3/8"=1'

Revisions

△	△
△	△
△	△
△	△

CUSTOMER APPROVAL

Customer Signature _____ Date _____
COPY, COLORS & SIZES

US SIGN does **NOT** provide primary
electrical to sign location-
RESPONSIBILITY OF OTHERS!

Customer Signature _____ Date _____
This design is the exclusive property of US SIGN
and cannot be reproduced in whole or in part,
without their prior written approval

File Name: _____

Page: ##

Of: ##

PRSG20260219



OPTION 1

SCALE: NTS




SITE PLAN

(A) CHANNEL LETTERS ON RACEWAY



EXISTING

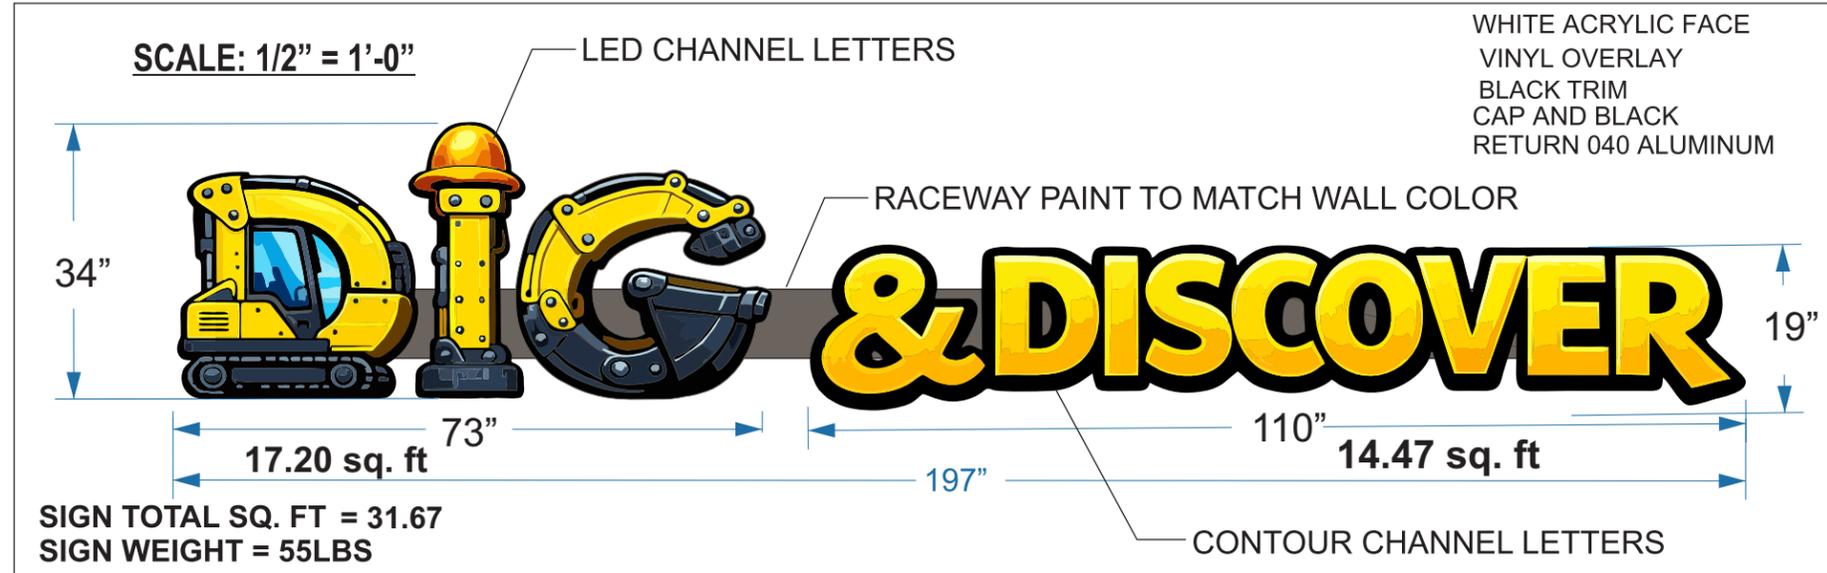

US SIGN 1
WHOLESALE SIGN MANUFACTURER
7808 RIVER ROAD EAST
PUYALLUP, WA 98371
206-468-3999 253-236-8074



Date: _____
Salesperson: TL
Coordinator: TL
Designer: JT
Scale: 3/8"=1'

Revisions

△	△
△	△
△	△
△	△

CUSTOMER APPROVAL

Customer Signature _____ Date _____
COPY, COLORS & SIZES

US SIGN does **NOT** provide primary electrical to sign location-
RESPONSIBILITY OF OTHERS!

Customer Signature _____ Date _____
This design is the exclusive property of US SIGN and cannot be reproduced in whole or in part, without their prior written approval.

File Name: _____
Page: ##
Of: ##

U.L. LABELS REQUIRED
INSTALL IN ACCORDANCE W/
NATIONAL ELECTRIC CODES

PRSG20260219

SCALE: NTS



ELEVATION

SIGN ALLOWABLE
32 sq. ft.

1 sq. ft to 1 lineal foot
to store front

ALL PENTRATION MUST BE SEALED
IN A WATERTIGHT MANNER.
(SILICONE)

UL LABEL WILL BE PLACE
ON THE SIDE OF THE RACEWAY
BEHIND THE LOGO
NO VISIBLE TO THE PUBLIC

**15AMP IN-WALL 3-WAY DAYLIGHT
ADJUSTING DIGITAL
TIMER SWITCH WITH
SCREW TERMINALS
MANUFACTURE: DEFIANT**

ELECTRICAL


SIGN WILL BE ILLUMINATED
WITH HANLEY 1 WATT PER
MODULE LED WHITE WITH
60 WATTS
POWER SUPPLY CLASS 2
1 @ 20 amp sign circuit
110v

INTERNALLY LED ILLUMINATED
LIGHT OUT WILL NOT EXCEED
100 NITS.



PROPOSED

CHANNEL LETTERS ON RACEWAY- ATTACHMENT DETAIL

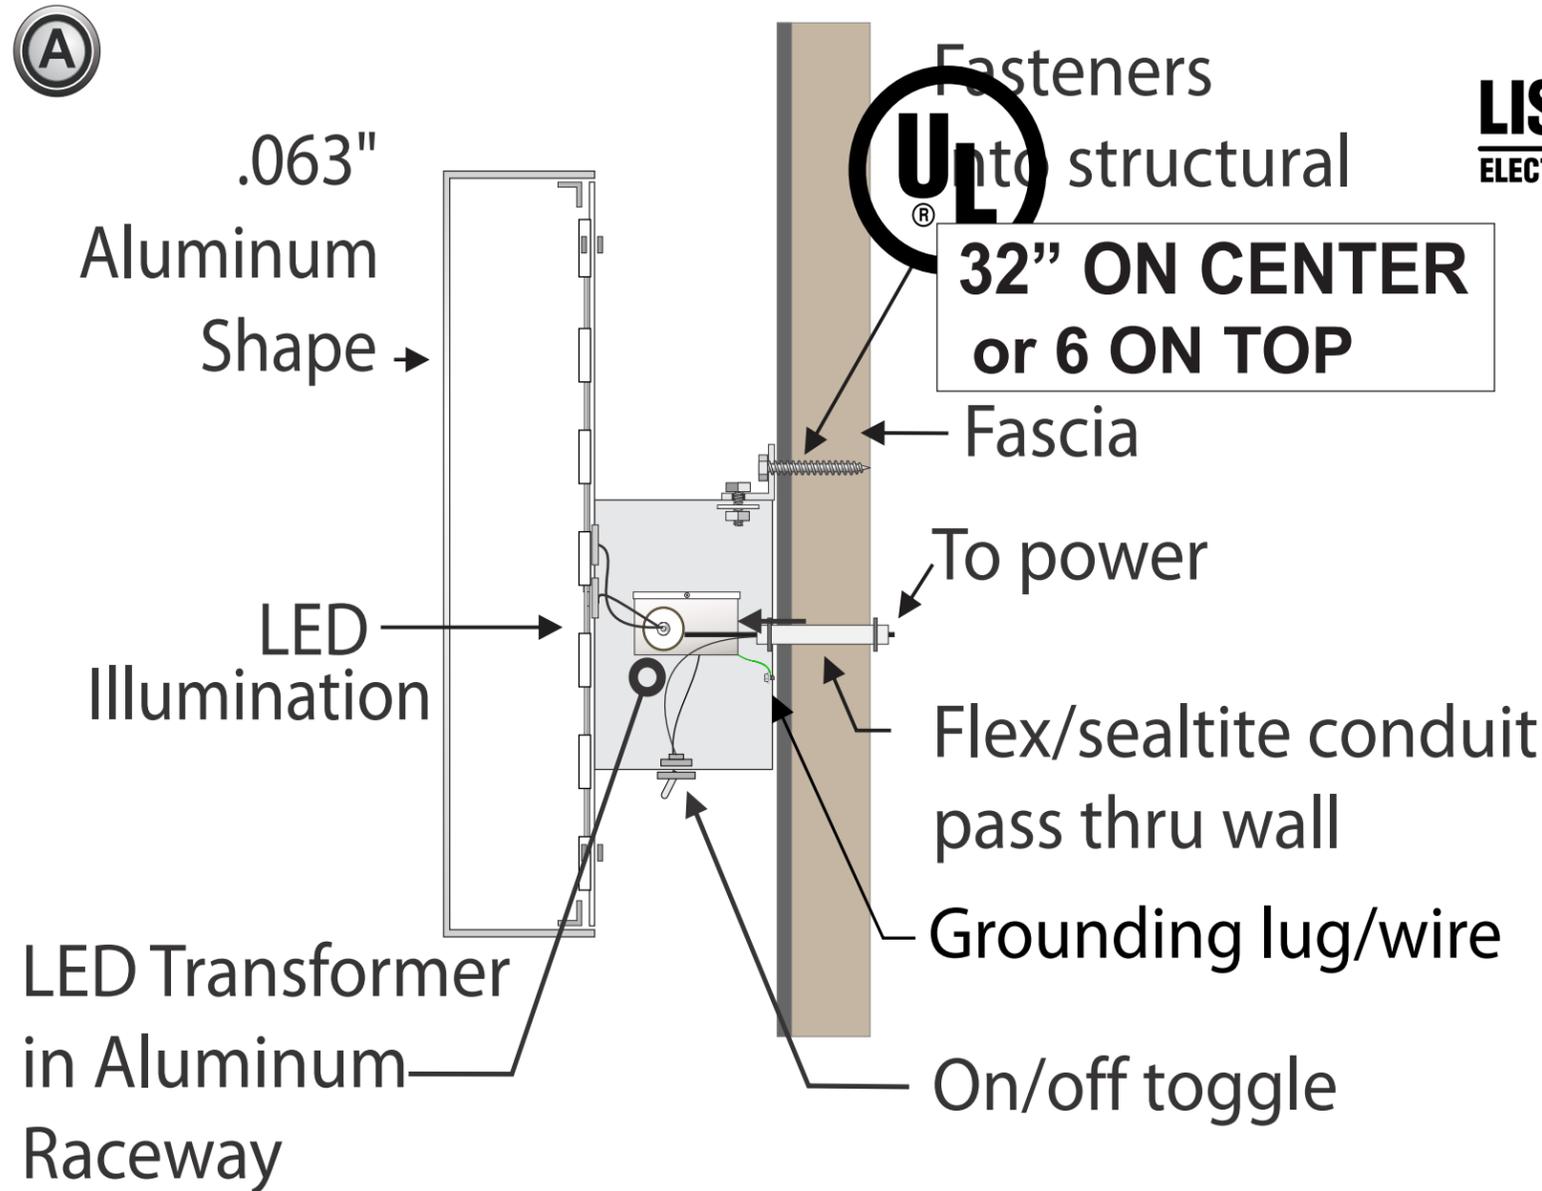

LISTED
ELECTRIC SIGN

**32" ON CENTER
or 6 ON TOP**

STUCCO / DRIVET
3/8" x 3" LAG BOLTS



UL This sign intended to be installed in accordance with the requirements of Article 600 of the National Electrical Code and /or other applicable local codes.

SIGN ALLOWABLE
32 sq. ft.

1 sq. ft to 1 lineal foot
to store front

SIGN TOTAL SQ. FT = 31.67
SIGN WEIGHT = 55LBS

WHITE ACRYLIC FACE
VINYL OVERLAY
BLACK TRIM
CAP AND BLACK
RETURN 040 ALUMINUM

ALL PENTRATION MUST BE SEALED
IN A WATERTIGHT MANNER.
(SILICONE)

UL LABEL WILL BE PLACE
ON THE SIDE OF THE RACEWAY
BEHIND THE LOGO
NO VISIBLE TO THE PUBLIC

**15AMP IN-WALL 3-WAY DAYLIGHT
ADJUSTING DIGITAL
TIMER SWITCH WITH
SCREW TERMINALS
MANUFACTURE: DEFIANT**

ELECTRICAL

SIGN WILL BE ILLUMINATED
WITH HANLEY 1 WATT PER
MODULE LED WHITE WITH
60 WATTS
POWER SUPPLY CLASS 2
1 @ 20 amp sign circuit
110v

INTERNALLY LED ILLUMINATED
LIGHT OUT WILL NOT EXCEED
100 NITS.

US SIGN 1
WHOLESALE SIGN MANUFACTURER
7808 RIVER ROAD EAST
PUYALLUP, WA 98371
206-468-3999 253-236-8074



Date: _____
Salesperson: TL
Coordinator: TL
Designer: JT
Scale: 3/8"=1'

Revisions

△	△
△	△
△	△
△	△

CUSTOMER APPROVAL

Customer Signature _____ Date _____
COPY, COLORS & SIZES

US SIGN does **NOT** provide primary
electrical to sign location-
RESPONSIBILITY OF OTHERS!

Customer Signature _____ Date _____

This design is the exclusive property of US SIGN
and cannot be reproduced in whole or in part,
without their prior written approval

File Name: _____

Page: ##

Of: ##

UL U.L. LABELS REQUIRED
INSTALL IN ACCORDANCE W/
NATIONAL ELECTRIC CODES

PRSG20260219

SCALE: NTS



ATTACHMENT